


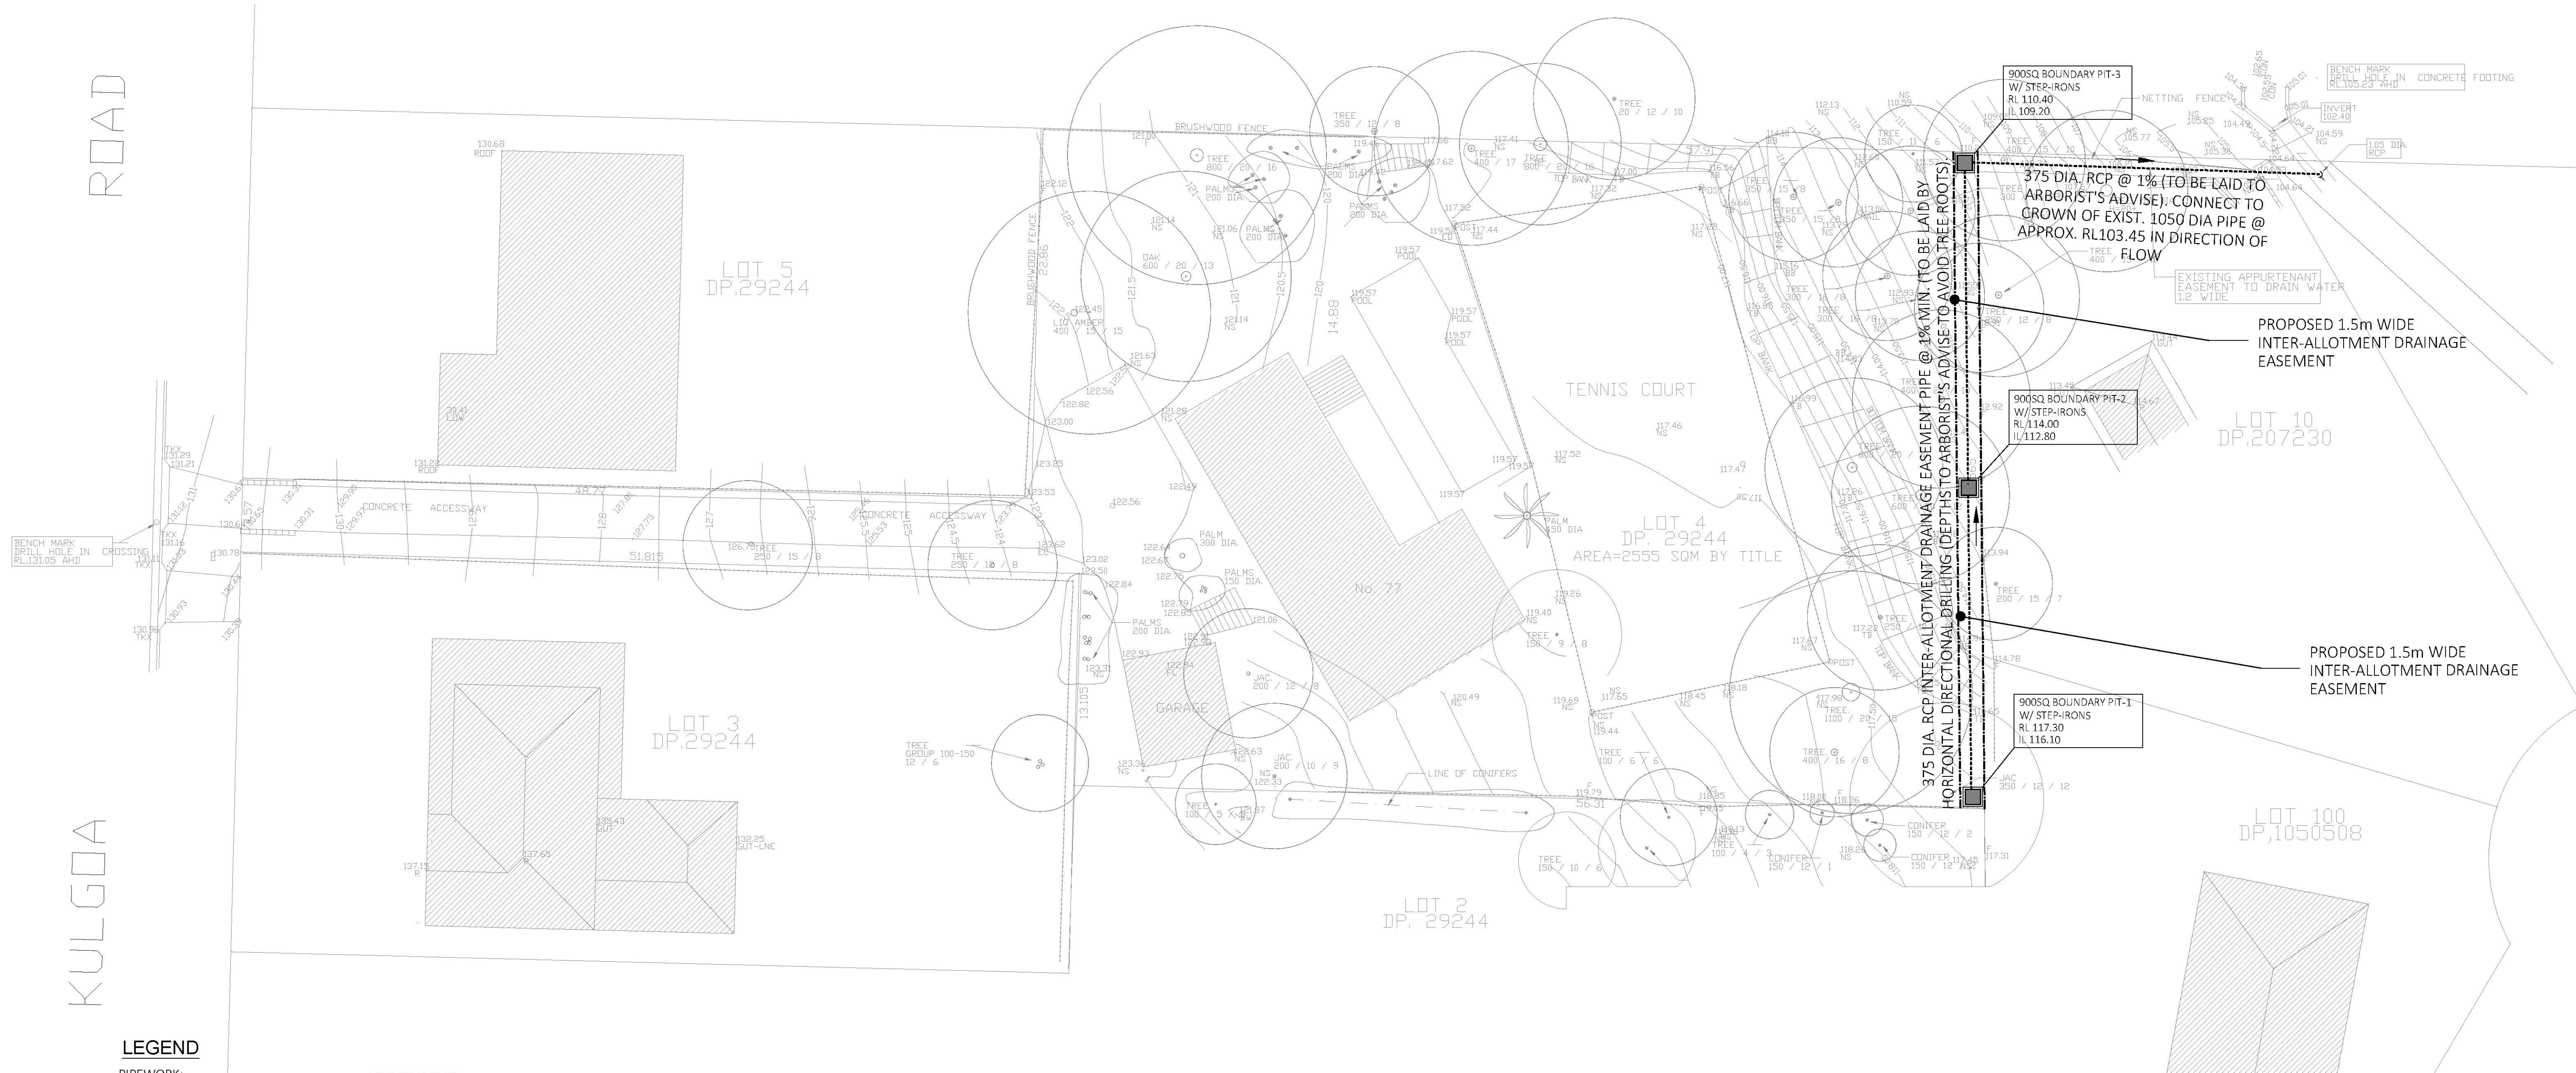

LEGEND

PIPEWORK:

- SUB-SOIL
- 100 DIA UPVC STORMWATER PIPE U.N.O. WITH 1% GRADE (MIN.)
- TRUNK MAIN
- SILT AND DUST FENCE
- EXISTING STORMWATER PIPE
- EXISTING STORMWATER TO BE REMOVED
- RISE IN SERVICE
- DROP IN SERVICE

SERVICE ACCESSORIES:

- DOWNPIPE 100 DIA. U.N.O.
- DOWNPIPE AND SPREADER
- PLANTER BOX DRAINAGE OUTLET 100 DIA. U.N.O.
- RAINWATER OUTLET (150 x 150 U.N.O.)
- BALCONY RAINWATER OUTLET (100 GRATE U.N.O.)
- OVERFLOW SPITTER (50 DIA. U.N.O.)
- GRATED INLET PIT (450SQ. MIN. U.N.O.)
- CONCRETE COVERED JUNCTION PIT
- GRATED TRENCH DRAIN (150 WIDE U.N.O.)
- KERB INLET PIT
- STORMWATER PUMP/WELL
- VEHICULAR CROSSING
- REVISION
- OVERLAND FLOW PATH
- CLEANING EYE

ABBREVIATIONS:

- UPVC UNPLASTICIZED POLYVINYL CHLORIDE
- PVC POLYVINYL CHLORIDE
- HDPE HIGH DENSITY POLYETHYLENE
- FRC FIBRE REINFORCED CONCRETE
- CI CAST IRON
- CU COPPER
- DP DOWNPIPE
- RM RISING MAIN
- SYDP SYNCHRONIC DOWNPIPE
- RWT RAINWATER TANK
- TUNOISH TUNOISH
- TTD TRAPPED TUNOISH
- DT U.A.A. DRAINAGE TURN-UP POINT
- GTD GRATED TRENCH DRAIN
- RWO RAINWATER OUTLET
- BRWO BALCONY RAINWATER OUTLET
- PBO PLANTER BOX OUTLET
- SPO SPOON DRAIN OUTLET
- RL REDUCED LEVEL
- IL INVERT LEVEL
- SL SURFACE LEVEL
- FFL FINISHED FLOOR LEVEL
- HL HIGH LEVEL
- LL LOW LEVEL
- TOW TOP OF WALL
- US UNDERSIDE
- M/H PRESSURE IN METRES/HEAD
- C/S CAST IN SUE
- C/C CAST IN COLUMN
- EX EXISTING
- DIA DIAMETER
- m METRE
- SQ SQUARE
- U.N.O. UNLESS NOTED OTHERWISE
- PSD PERMISSIBLE SITE DISCHARGE
- SSR SITE STORAGE REQUIREMENTS

NOT FOR CONSTRUCTION

Copyright This document is & shall remain the property of ING Consulting Engineers Pty Ltd. The document may only be used for the purpose for which it was commissioned. They must not be used, reproduced, or copied in whole or in part without prior written consent of that company.			Designed By ING CONSULTING ENGINEERS PTY LTD P O BOX 1543 BAULKHAM HILLS NSW 1755 T: (02) 8807 5656 M: 0433 778 109 E: ken@ingengineers.com.au		Project Concept Sub Division/Proposed Rezoning		Drawing Title Site Plan (Sub Division)	
			Drawn & Designed by: K Koh		At 77 Kulgoa Road Pymble NSW 2073		Date July 2024	Scale 1 : 200 @ A1
			Checked by: N. Evans		Client		Project No. 420082023FEAS	Drawing & Sheet No./ Issue 42008-01/1 / A
			Approved by: Kenneth T. NG ME Aust CP Eng NER APEC Engineer Int PE (Aus) (Reg. No. 2206352) RPEQ RPEV Registered Certifier (Hydraulic (stormwater), Road & Drainage and Stormwater) (Reg. No. 8008827) Registered Design Practitioner (Drainage & Civil Engineering) (Reg. No. DEP0000692) & Professional Engineer (Civil) (Reg. No. DEP0000630) NSW Fair Trading					
A	Issued for Development Application	10 July 2024						
Issue	Description	Date						