


@ B1 4:21:51 PM 20131017-(DD) Be

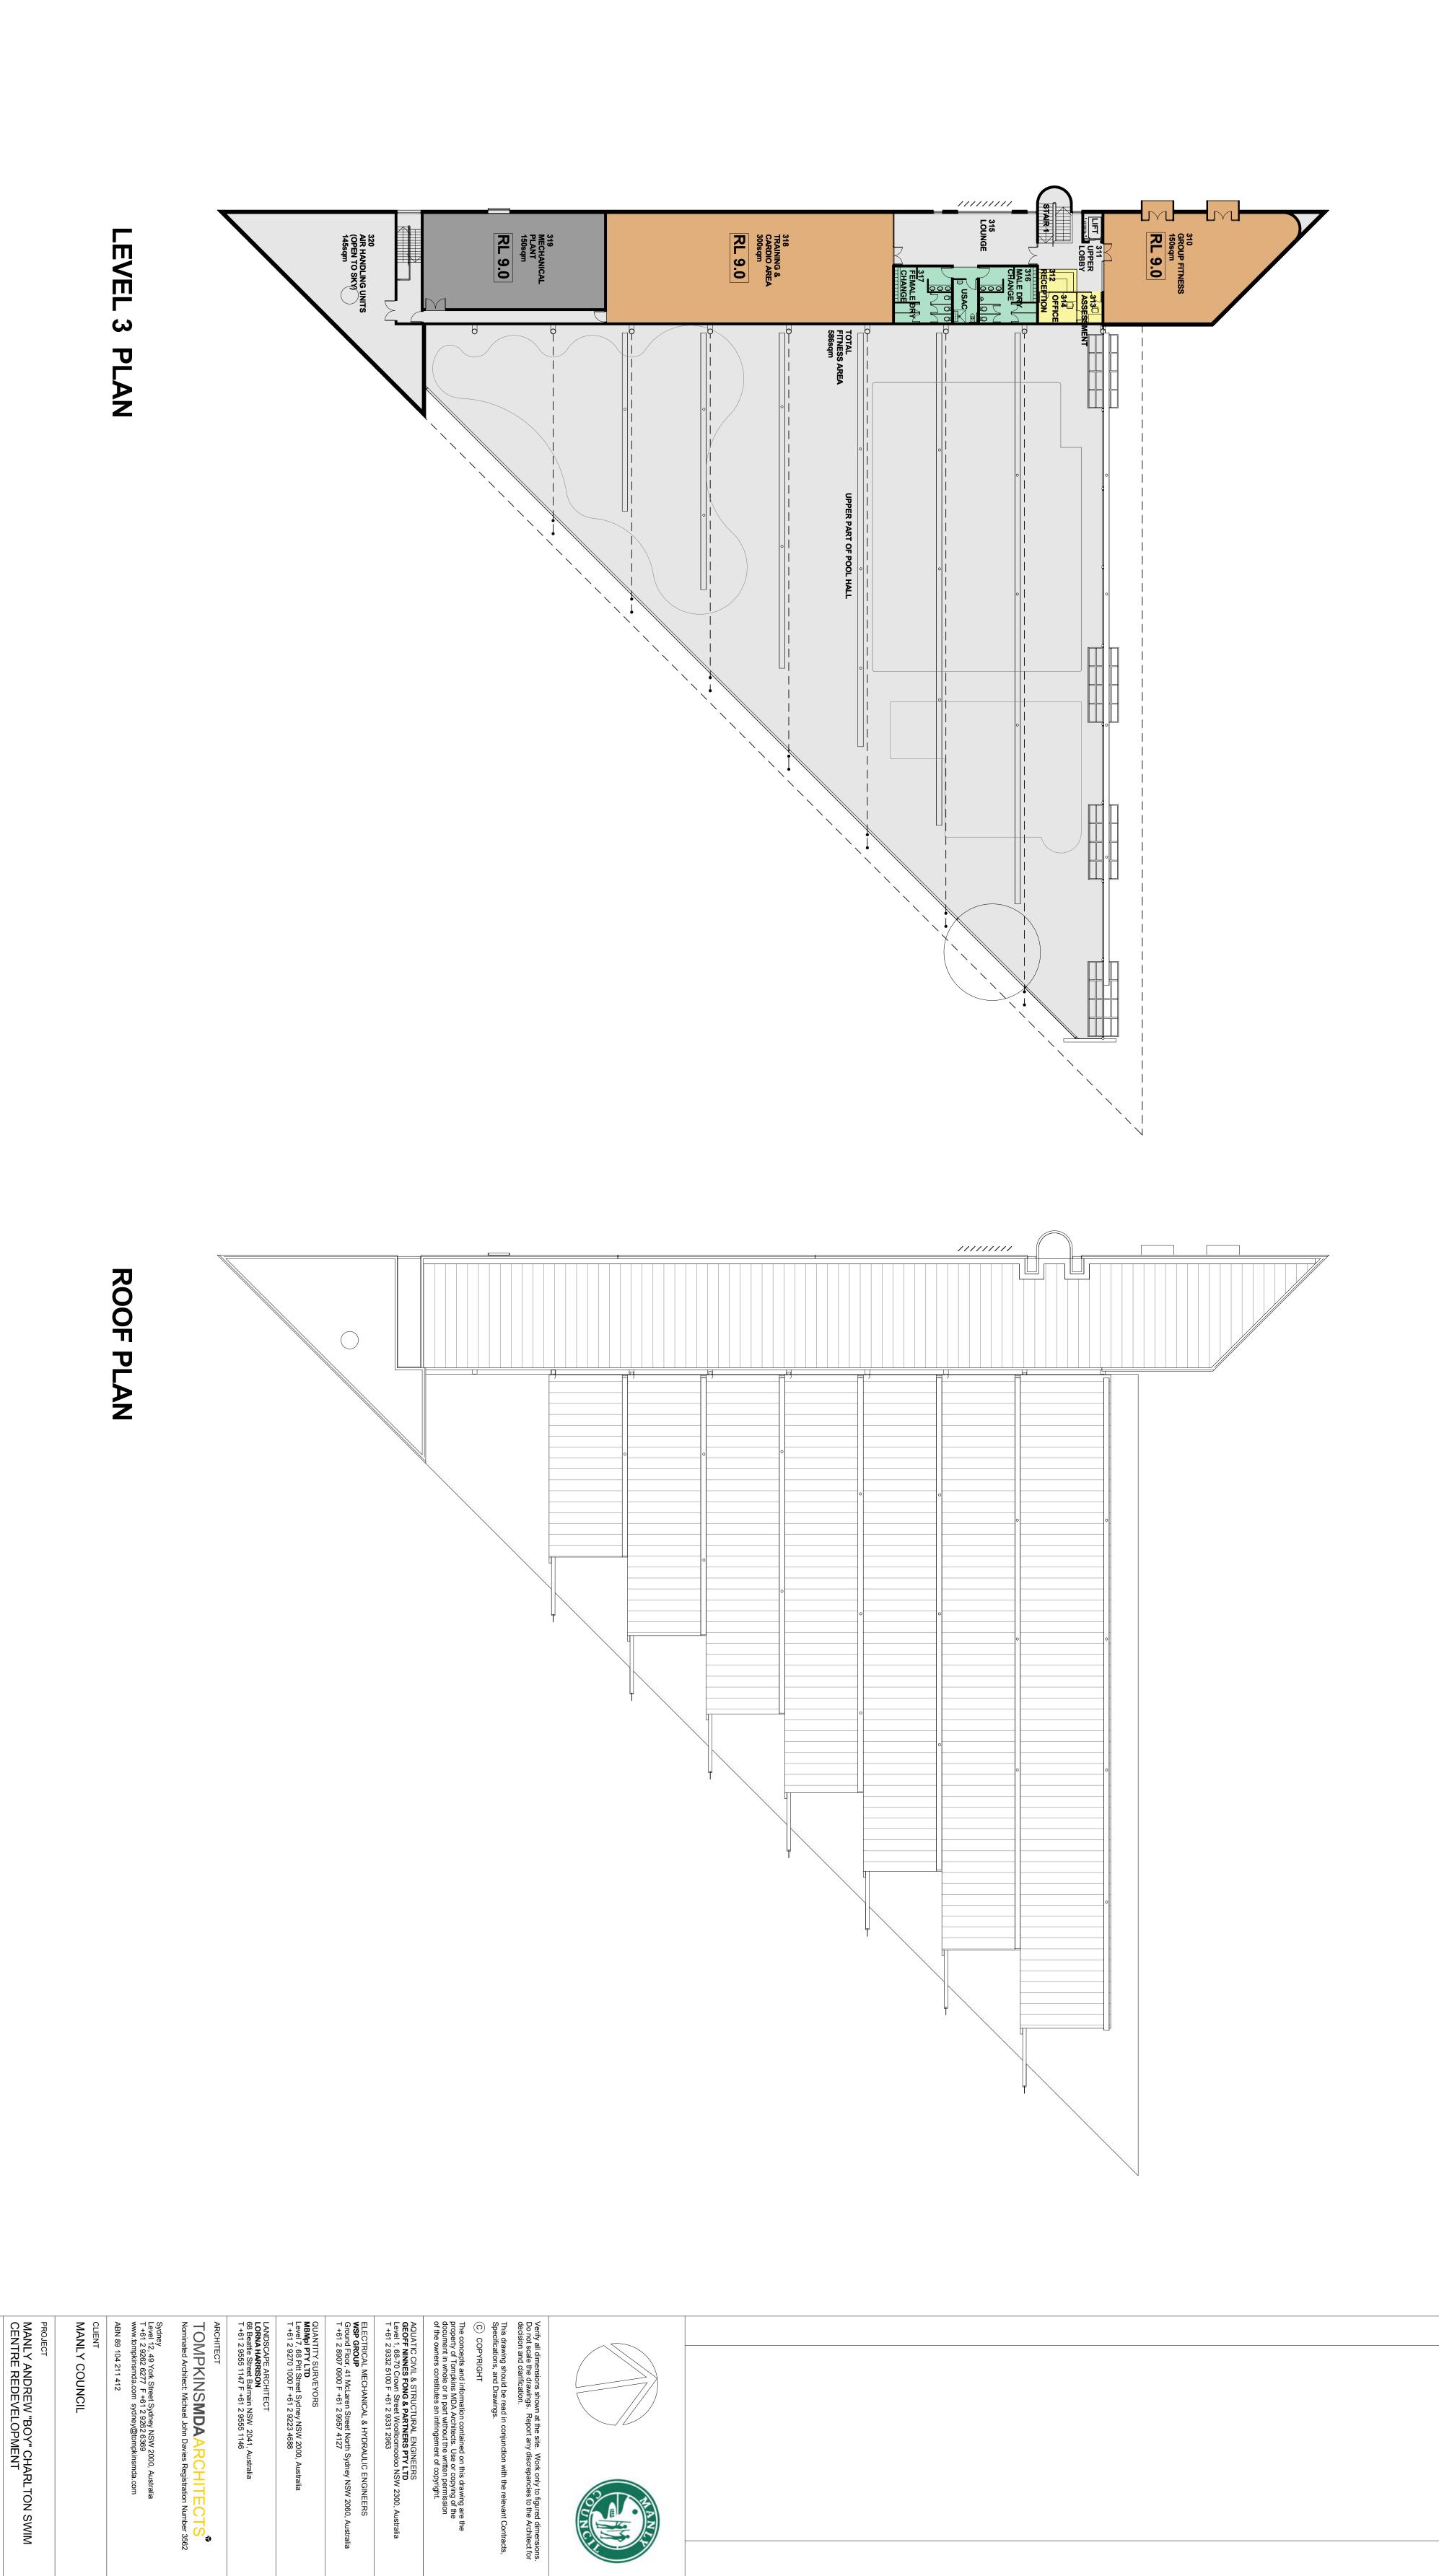

PROJECT/DRAWING NUMBER 1310 106

SCALE 1:250 @ B1

PLOT DATE 2013/11/08 4:21:53 PM

S:2013\1310 - Maniy ABC Swim Centre\Drawings\Current\1310-20131017-(DD) Befon Deletion\1310-(DD) Bidg Scheme 4 (R) (Access Commity Version 20131108).rvt

DRAWING TITLE
LEVEL 3 & ROOF PLAN

B Female and Male Change layout modified.

USAC added between change rooms.

Lounge area increased.

Date 08/11/20