## **MERRYLANDS PUBLIC SCHOOL**

Fowler Road Merrylands NSW, 2160


## **DEVELOPMENT APPLICATION**



DA DRAW	NG LIST	
DWG No.	DRAWING NAME	SCALE
DA		
DA00	COVER SHEET & LOCATION PLAN	
DA01	EXISTING SITE PLAN	1:500
DA02	DEMOLITION SITE PLAN	1:500
DA03	TREE MANAGEMENT PLAN	1:500
DA11	PROPOSED SITE PLAN	1:500
DA12	PROPOSED SITE ANALYSIS PLAN	1:500
DA13	WASTE MANAGEMENT PLAN	1:500
DA21	EXISTING GROUND FLOOR PLANS	1:200
DA22	EXISTING FIRST FLOOR PLANS	1:200
DA31	PROPOSED GROUND FLOOR PLAN	1:100
DA32	PROPOSED FIRST FLOOR PLAN	1:100
DA33	PROPOSED SECOND FLOOR PLAN	1:100
DA34	PROPOSED ROOF PLAN	1:100
DA41	PROPOSED ELEVATIONS - SHEET 1	1:200
DA42	PROPOSED ELEVATIONS - SHEET 2	1:200
DA51	PROPOSED SECTIONS	1:200
DA61	SHADOW DIAGRAMS	1:500
DA81	STREETSCAPE ELEVATION	1:200
DA82	COLOUR AND FINISHES SCHEDULE	
DA91	NOTIFICATION PLAN - FLOOR PLANS	
DA92	NOTIFICATION PLAN - ELEVATIONS	
DA100	3D PERSPECTIVE - SHEET 1	
DA101	3D PERSPECTIVE - SHEET 2	
DA102	3D PERSPECTIVE - SHEET 3	

THE AND USE DRA PUF	E CONTRACTO VERIFY ALL FIGURATIVE WINGS SHAL	DR SHAI ERROR DIMEN L NOT E L ISSUE	RCHITECTS PTY. LTD. L CHECK AND VERIFY ALL DI S AND OMISSIONS TO THE AR SIONS, DO NOT SCALE THE D BE USED FOR CONSTRUCTION D BY THE ARCHITECT FOR	CHITECT. RAWINGS.
Rev	Date	By	Issue Name	CK
А	08-Aug-17	AT	ISSUE FOR DA	AC
В	05-Sep-17	AT	ISSUE FOR DA	AC
		_		
İ				



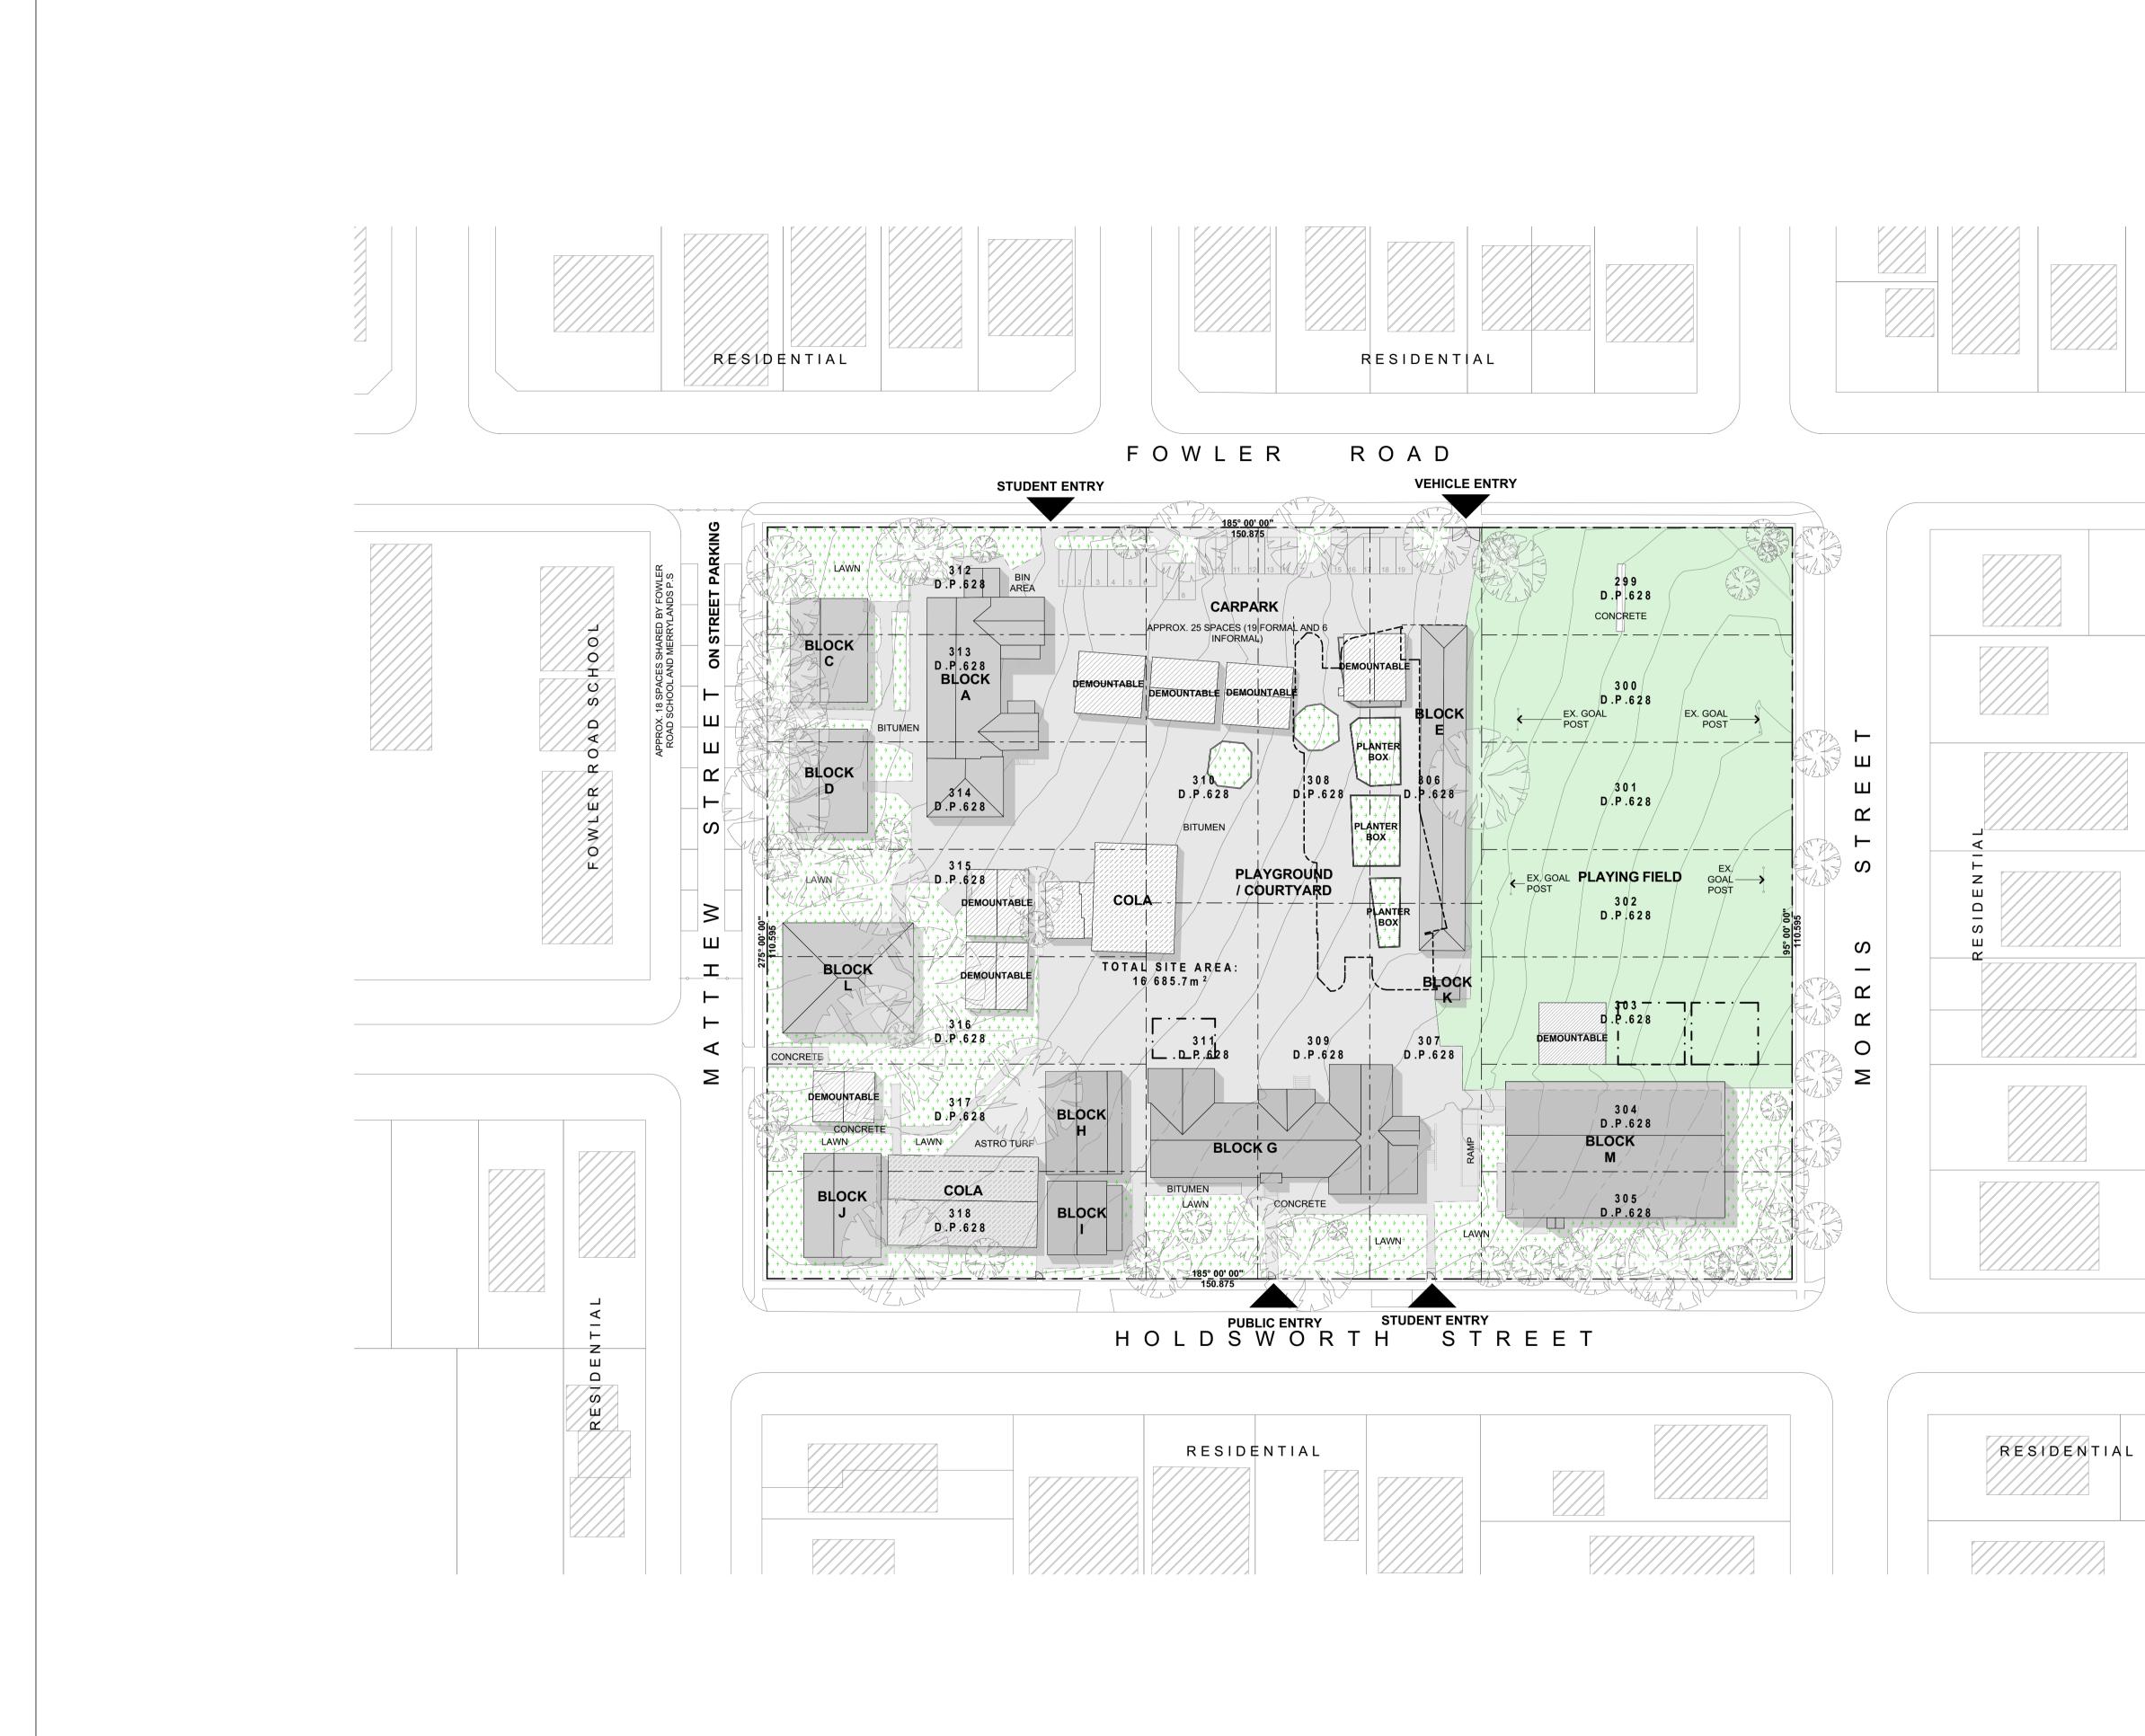


	Date 08-Aug-17	By	D BY THE ARCHITECT FOR Issue Name ISSUE FOR DA	CK AC
	05-Sep-17	AT	ISSUE FOR DA	AC
•		<b>Г</b>		
	SITE L	.E(	JENU	
			EXISTING NEIGHE BL	BOURING
			EXISTING BUILDING	S ON SITE
			В	UILDINGS
			FXIST	ING COLA
			EXIST	
	$\begin{array}{cccc} & \rightarrow & \rightarrow & \neg \\ & \rightarrow & \rightarrow & \rightarrow \\ & \rightarrow & \rightarrow & \rightarrow \\ & \rightarrow & \rightarrow &$		EXISTING LAWN	/ GARDEN
	$\xrightarrow{\rightarrow}\rightarrow\rightarrow\rightarrow$			
			EXISTING PLAY	ING FIELD
			- INTERNAL LOT B	OUNDARY OUNDARY
				IBOURING OUNDARY
_			– OL PROPOSED	JTLINE OF BUILDING
_				S DURING
ł				RUCTION
,	E.J.J.		EXIST	ING TREE
			Sľ	TE ENTRY
Pla	nning			dfp
_ar	ndscape		S P A	
Pro	ject Manage	ər	LANDSCAPE	
Bui	Iding Certifie			AFF
				DSMITH
Hyo Civ	chanical, Ele draulic, Struc il Engineerir nsultant	ctural &		HOLSON ENGINEERS
٩rc		Н	archite	ote
nfo(	ARCHITECTS	S PTY. L .com.au	TD. 44 Little Oxford	Street
	i 27 110 978 8 N 110 978 8 MINATED ARCI NE HARRISON	302 HITECT		
Clie	ent			
N N	ISW	Edi	ucation	
201	W Departme ridge Street	ent of E	Education	
	ject Name	_AN	DS PUBLIC	
5 B	ERRYI		K	
S B	CHOOI	-		
5 B Pro M S(			5 NSVV 2100	
5 B Pro M S( S( M Dra	CHOOI DWLER ERRYLA	AND		
5 B Pro M S C F C M D Tra E S Ca	CHOOI OWLER ERRYLA wing Title KISTING ale : 1:500	AND	E PLAN Date :	19-Apr-18
5 B Pro M S F M Dra Dra Dra	CHOOI DWLER ERRYLA awing Title KISTING ale : 1:500 awn : AT	AND 6 SIT	E PLAN Date : Checked	:AC

1			
1			
1			
1			
1			
1			
1			
1			

//	
//	

/			
/			
/			
/			
_			
//			
/			
		/	
	/		
		/	
/		11	
/		/	
	//		11
/			
			1
	/		
/		/	
			11
1	7		1
/			
1		//	
	_/_	e	/

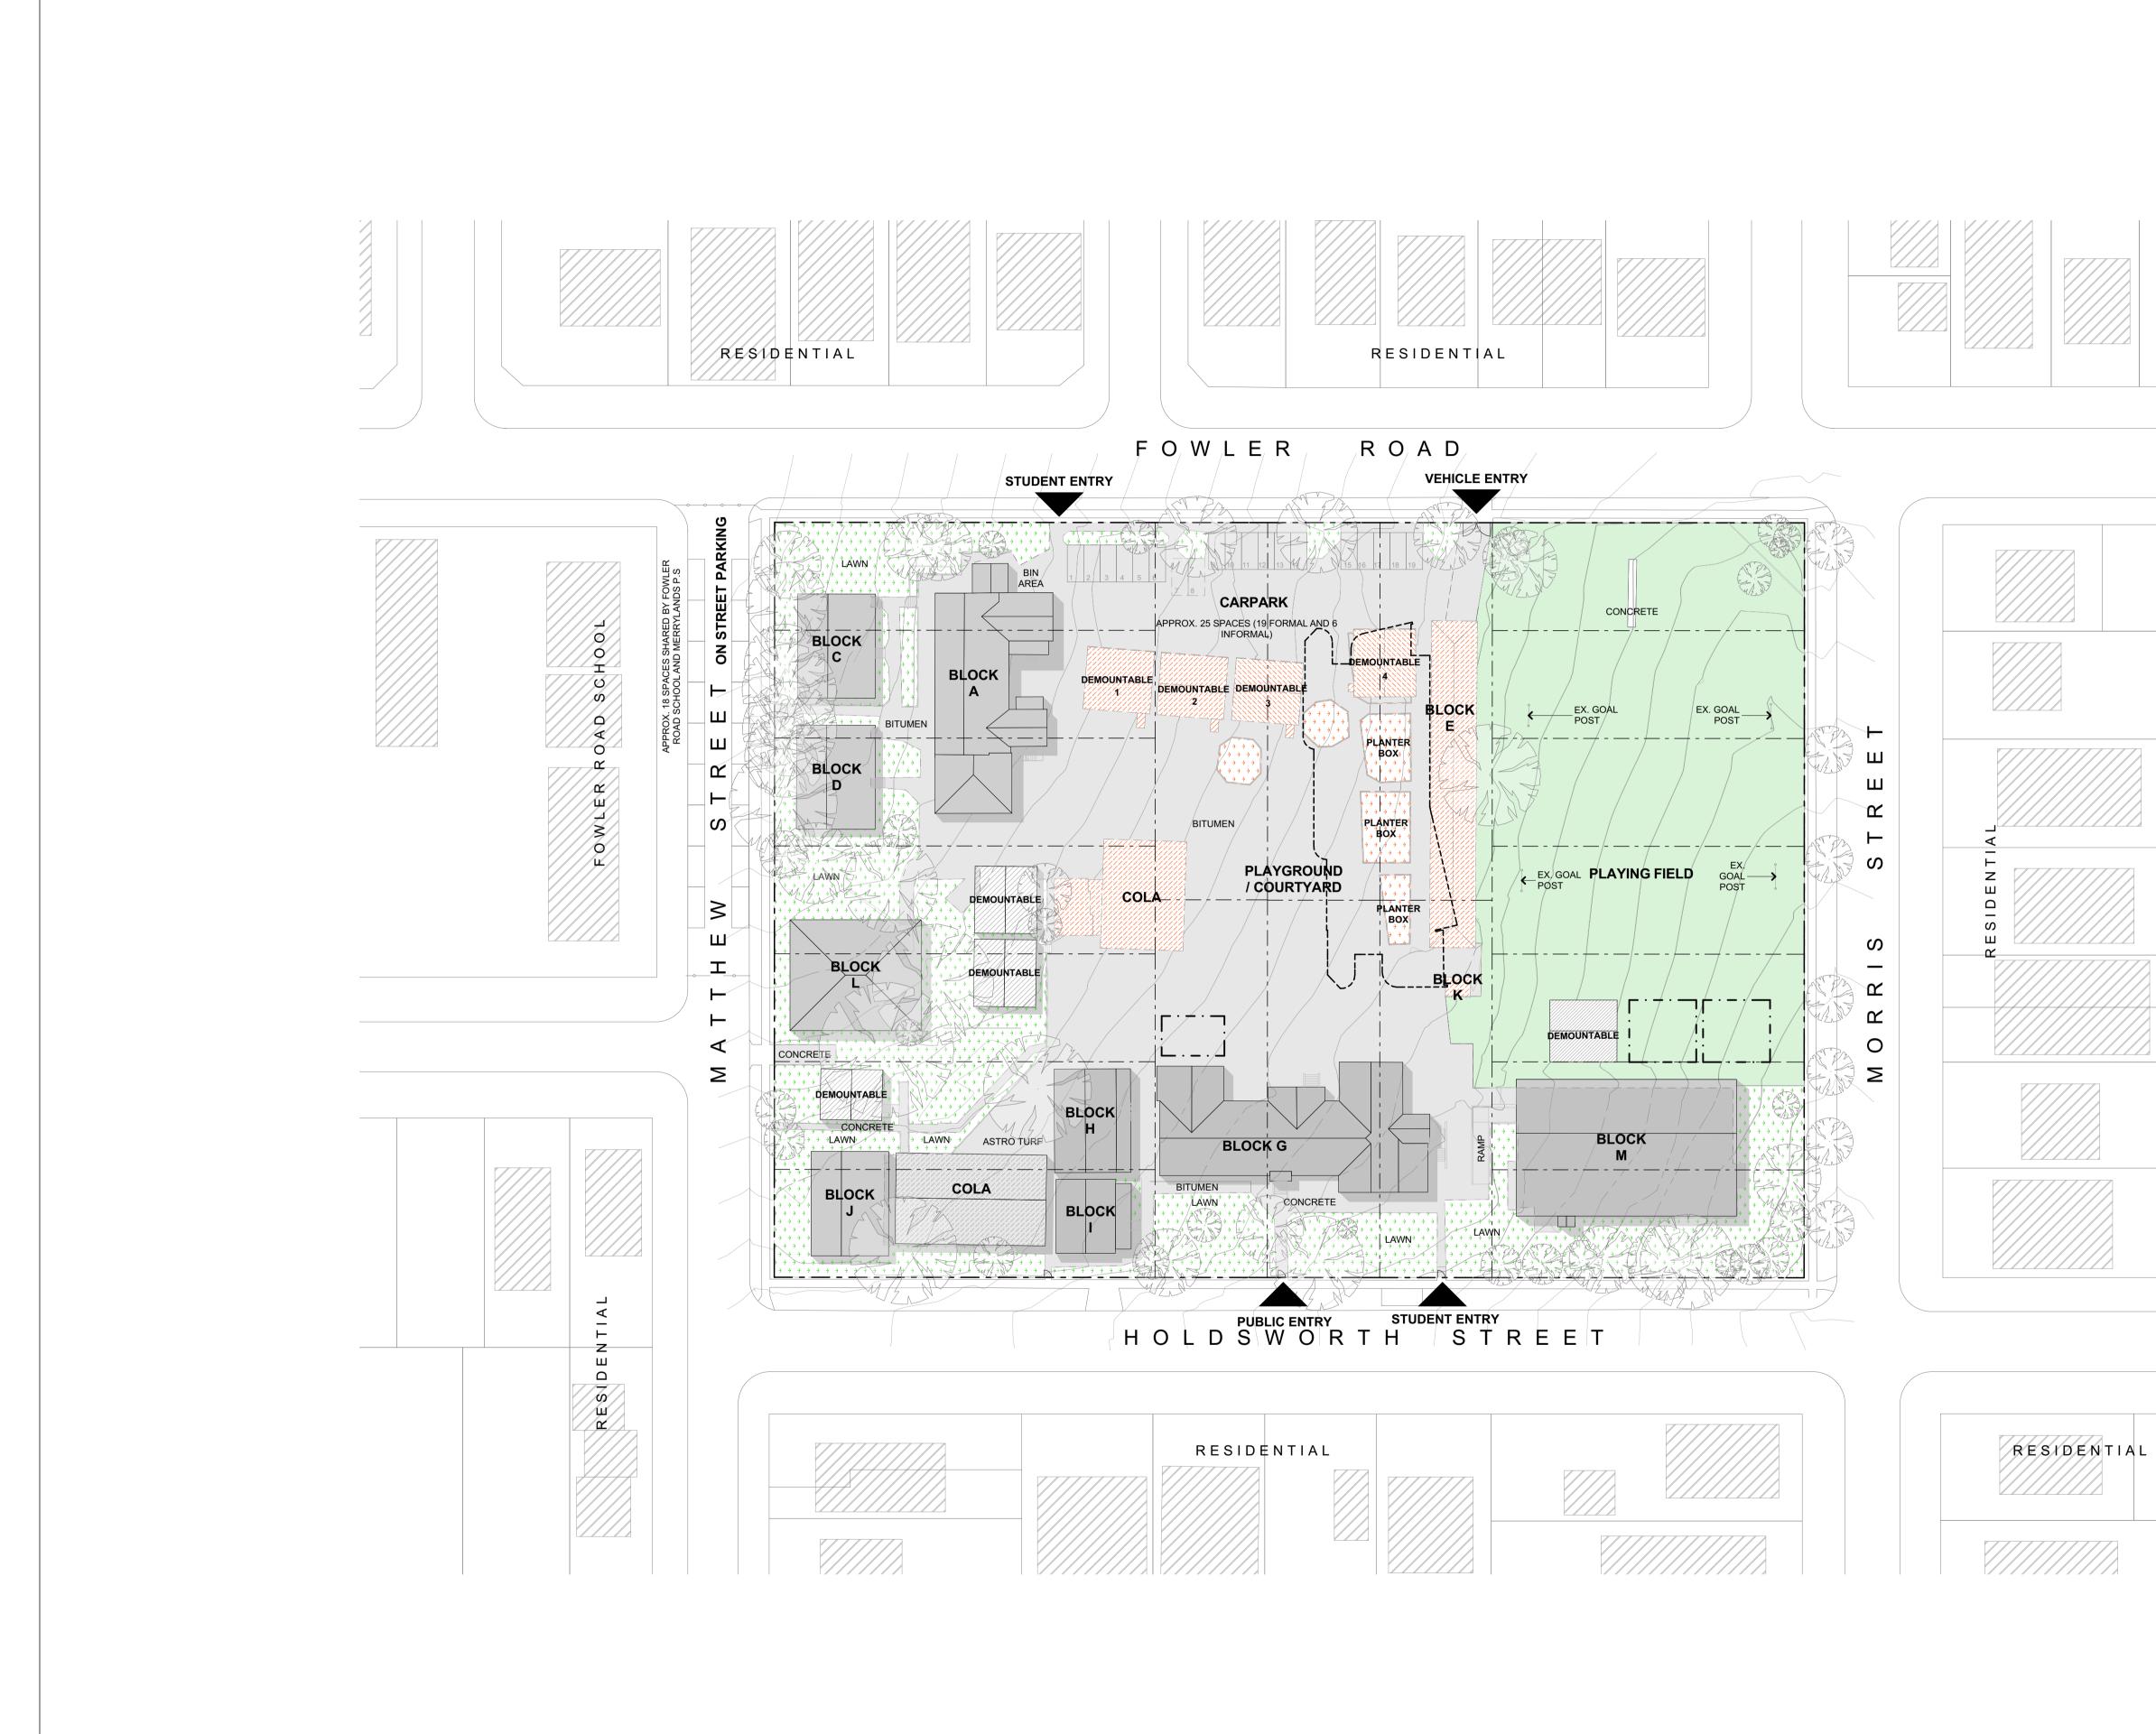

	STRUCTION. Date 08-Aug-17	By AT	D BY THE ARCHITECT FOR Issue Name ISSUE FOR DA	CK AC
	05-Sep-17	AT	ISSUE FOR DA	AC
D	EMO			ND
			EXISTING NEIGH	
			В	JILDINGS
			EXISTING BUILDING	S ON SITE
			BUILDINGS / STRUC BE REMOVED / DEM	
			DEMOUNTABLE BUIL BE TEMPORARILY RE DURING CONS <sup></sup>	LOCATED
+ +	$\begin{array}{c} \bullet \\ \bullet $		GARDEN / PLANT	TER TO BE REMOVED
<b>_</b> →	$\begin{array}{c} \bullet \\ \bullet $			KEMOVED
$\rightarrow$	$\rightarrow \rightarrow \rightarrow \rightarrow$		EXISTING LAWN	/ GARDEN
			EXISTING PLAY	ING FIELD
			- SITE BO	UNDARY
			- INTERNAL LOT BO	UNDARY
				BOURING UNDARY
			– Ol PROPOSED	JTLINE OF BUILDING
				S DURING
X LAN				TRUCTION
			SIT	E ENTRY
Plan	ining			dfp
Land	dscape		SPA	
Proj	ect Manage	ər	L A N D S C A P E	
Build	ding Certifie	er		CKETT SUIRE+ DSMITH
Hydi Civil	hanical, Ele raulic, Strue Engineerir sultant	ctural &		HOLSON ENGINEERS
Arch		Н	archite	cts
nfo@ ABN ACN NOM	ARCHITECTS 2jdharchitects 27 110 978 { 110 978 } INATED ARC IE HARRISON	.com.au 302 302 HITECT:	Darlinghurst, N Telephone: 02 9 www.jdharchite	SW 2010 9281 8697
Clie	nt			
NSV	<b>SW</b> SW V Departme	ent of E		RSEVERE
	idge Street ect Name	, Sydn	еу	
ME				$\frown$
	WLER ERRYLA		AD, S NSW 2160	
ME Drav	wing Title	ION	SITE PLAN	
Drav Drav DE Scal	MOLIT le : 1:500 wn : AT	ION @A1	Date : Checked	19-Apr-18 :AC

1			
1			
 Δ

/		
/		
/		
/		
/		
_		
_	//	
-	//	
_		
/		
/		
/	//	
/		
/		
			CHITECTS PTY. LTD.	
AND USE DRA	VERIFY ALL I FIGURATIVE WINGS SHAL	ERRORS DIMENS L NOT B	L CHECK AND VERIFY ALL D S AND OMISSIONS TO THE AI SIONS, DO NOT SCALE THE I E USED FOR CONSTRUCTIC D BY THE ARCHITECT FOR	RCHITECT. DRAWINGS.
CON Rev	STRUCTION.	Ву	Issue Name	СК
A B	08-Aug-17 05-Sep-17	AT AT	ISSUE FOR DA	AC AC
Т	REE I	REN	IOVAL LEGI	END
			EXISTING NEIGHE BL	JILDINGS
			- SITE BO	
			- INTERNAL LOT BO	
				OURING UNDARY
_			TREE PROTECT (TPZ) BOU	ION ZONE JNDARIES
_			PROTECTIVE AND TPZ ARE	
	15 m			
			EXISTIN	NG TREE
ŗ			TREE REMO	
1			MAINTENANCE JU	
			SITE	EENTRY
N				
F	REFER TO A	TREE	RIST REPORT BY S FOR TREE NUMBER:	S
	ND DETAIL		REMOVED AS PART OF	-
Т				
	HIS PROP	OSAL.		
	HIS PROP	OSAL.		
	'HIS PROP	OSAL.		
	HIS PROP	OSAL.		
	HIS PROP	OSAL.		
	HIS PROP	OSAL.		
	HIS PROP	OSAL.		
	HIS PROP	OSAL.		
	HIS PROP	OSAL.		
Plar	HIS PROP	OSAL.		
Plar		OSAL.		ſ
		OSAL.	SPA	
Lan	nning dscape			
Lan	nning			DESIGNS
Lan Proj	nning dscape	er	JOHNST	DESIGNS
Lan Proj Buil	nning dscape ject Manage ding Certifie	er		AFF CKETT
Lan Proj Buil Mec Hyd Civi	nning dscape ject Manage ding Certifie chanical, Ele raulic, Stru I Engineerir	er er ectrical, ctural &		AFF CKETT GUIRE+ DSMITH
Lan Proj Buil Mec Hyd Civi Cor	nning dscape ject Manage ding Certifie chanical, Ele	er er ectrical, ctural &		AFF CKETT GUIRE+ DSMITH
Lan Proj Buil Mec Hyd Civi Cor	nning dscape ject Manage ding Certifie raulic, Strue I Engineerir sultant hitect	er er ectrical, ctural &	JOHNST	AFF CKETT CKETT DSMITH HOLSON ENGINEERS
Lan Proj Buil Mee Hyd Civi Cor Arcl	anning dscape diect Manage ding Certifie chanical, Ele iraulic, Stru- l Engineerin sultant hitect	er er ectrical, ctural & ig	JOHNST	AFF CKETT CKETT CKETT CKETT CKETT CKETT CKETT CKETT CKETT CKETT CKETT CKETT SUIRE+ DSMITH
Lan Proj Buil Mec Civi Cor Arcl	anning dscape diect Manage ding Certifie chanical, Ele iraulic, Strut l Engineerir sultant hitect MARCHITECTS 20 110 978 6 110 978 6 21 110 978 6 30 ARCHITECTS	er ectrical, ctural & ig FTY. L1 scom.au 302 HITECT:	JOHNST	AFF CKETT CKETT DSMITH HOLSON ENGINEERS Street SW 2010 281 8697
Lan Proj Buil Mec Civi Cor Arcl	anning dscape diect Manage ding Certifie chanical, Ele iraulic, Stru- l Engineerir sultant hitect ARCHITECTS 20 dnarchitects. 27 110 978 6 UNATED ARC VE HARRISON	er ectrical, ctural & ig FTY. L1 scom.au 302 HITECT:	JOHNST	AFF CKETT CKETT DSMITH HOLSON ENGINEERS Street SW 2010 281 8697
Lan Proj Buil Mee Hyd Civi Cor Arcl JDH JDH JDH JDH NOM JAYI	anning dscape diect Manage ding Certifie chanical, Ele iraulic, Stru- l Engineerir sultant hitect ARCHITECTS 20 dnarchitects. 27 110 978 6 UNATED ARC VE HARRISON	er ectrical, ctural & ig FTY. L1 scom.au 302 HITECT:	JOHNST	AFF CKETT CKETT DSMITH HOLSON ENGINEERS Street SW 2010 281 8697
Lan Proj Buil Mee Hyd Civi Cor Arcl JDH JDH JDH JDH NOM JAYI	anning dscape diect Manage ding Certifie chanical, Ele iraulic, Stru- l Engineerir sultant hitect ARCHITECTS 20 dnarchitects. 27 110 978 6 UNATED ARC VE HARRISON	er er ectrical, ctural & ng PTY, L1 302 302 302 302 1 (7403)	JOHNST JOHNST MAC GOL NONES NICE CONSULTING A4 Little Oxford Darlinghurst, NS Telephone: 02 9 www.jdharchitee	AFF CKETT CKETT DSMITH HOLSON ENGINEERS Street SW 2010 281 8697
Lan Proj Buil Mec Hyd Civi Cor Civi Cor Arcl JDH info@ Acn NOM JAYf	anning dscape dict Manage ding Certifie chanical, Ele raulic, Strue I Engineerir isultant hitect DD ARCHITECTS 27 110 978 6 21 10 978 6 21	er er ectrical, ctural & ng ectrical, ctural & ng er er er er er er er er er er er er er	JOHNST	AFF CKETT CKETT DSMITH HOLSON ENGINEERS Street SW 2010 281 8697
Lan Proj Buil Mec Hyd Civi Cor Arcl JDH info@ Acn NOM JAYf Clie Clie Clie Clie Sov Sov Sov	anning dscape ding Certifie chanical, Ele raulic, Strue I Engineerir isultant hitect DD ARCHITECTS 27 110 978 6 110	er er ectrical, ctural & ng ectrical, ctural & ng er er er er er er er er er er er er er	JOHNST	AFF CKETT CKETT DSMITH HOLSON ENGINEERS Street SW 2010 281 8697
Lan Proj Buil Mec Hyd Civi Cor Arcu Joh Arcu Joh Clie Sov Sov Sov Sov	anning dscape direct Manage ding Certifie chanical, Ele raulic, Stru- l Engineerir sultant hitect D D A ARCHITECTS 20 dharchitects. 27 110 978 & 110 978 & Notecharchitects. 27 110 978 & 110 978 & 110 978 & 110 978 & Notecharchitects. 27 110 978 & 110 978 & 110 978 & 110 978 & Notecharchitects. 27 10 978 & Notecharchitects. 27 10 978 & Notecharchitects. 27 10 978 & Notecharchitects. 28 10 978 & 10	er er ectrical, ctural & ig PTY. L1 com.au 302 HITECT: 4 (7403) ECU ent of E , Sydne	JOHNST	AFF CKETT CKETT DSMITH HOLSON ENGINEERS Street SW 2010 281 8697
Lan Proj Buil Mec Hyd Civi Cor Arcl JJDH info@ ARN NOW JAYI Clie Clie Clie Clie NSV 5 BI	anning dscape direct Manage ding Certifie chanical, Ele raulic, Stru- l Engineerir sultant hitect D D A ARCHITECTS 20 dharchitects. 27 110 978 & 110 978 & Notecharchitects. 27 110 978 & 110 978 & 110 978 & 110 978 & Notecharchitects. 27 110 978 & 110 978 & 110 978 & 110 978 & Notecharchitects. 27 10 978 & Notecharchitects. 27 10 978 & Notecharchitects. 27 10 978 & Notecharchitects. 28 10 978 & 10	er er ectrical, ctural & ng BPTY. L1 com.au 302 HITECT: a (7403) EECL ent of E , Sydne Sydne	JOHNST JOHNST MCONES NICE CONSULTING ALLITTLE OXFORD DATINGHURST, NS Telephone: 02.9 www.jdharchited	AFF CKETT CKETT DSMITH HOLSON ENGINEERS Street SW 2010 281 8697
Lan Proj Buil Mec Hyd Civi Cor Civi Cor Civi Cor Arcl JJDH info@ Acc NOM JAYT Clie Sov Sov Sov Sov Sov Sov Sov	anning dscape ding Certifie chanical, Ele raulic, Strue l Engineerin sultant hitect DD ARCHITECTS 27 110 978 a 110 ATED ARC 27 110 978 a 110 ATED ARC 20 ATED ATED ARC 20 ATED ATED ATED ATED ATED ATED ATED ATED	er er ectrical, ctural & ng ectrical, ctural & ng ectrical ectrical ctural & ng ectrical ctural br>e ec	JOHNST	AFF CKETT CKETT DSMITH HOLSON ENGINEERS Street SW 2010 281 8697
Lan Proj Buil Mec Hyd Civi Cor Civi Cor Civi Cor Arcl JJDH info@ Acc NOM JAYT Clie Sov Sov Sov Sov Sov Sov Sov	anning dscape ding Certifie chanical, Ele raulic, Strue l Engineerin sultant hitect DD ARCHITECTS 27 110 978 a 110 ATED ARC 27 110 978 a 110 ATED ARC 20 ATED ATED ARC 20 ATED ATED ATED ATED ATED ATED ATED ATED	er er ectrical, ctural & ng ectrical, ctural & ng ectrical ectrical ctural & ng ectrical ctural br>e ec	JOHNST JOHNST Consulting Consulti	AFF CKETT CKETT DSMITH HOLSON ENGINEERS Street SW 2010 281 8697
Lan Proj Buil Mec Hyd Civi Cor Arcl JDH info@ Acn NOM JAYf Clie Clie Clie Clie Clie Clie Clie Clie	anning dscape ding Certifie chanical, Ele rect Manage ding Certifie chanical, Ele raulic, Strue lengineerir isultant hitect Digharchitects. 27 110 978 6 110 978 6 100	er er ectrical, ctural & ng ECU HITECT: 1 (7403) ECU Ent of E , Sydne ANDS	JOHNST	AFF CKETT CKETT DSMITH HOLSON ENGINEERS Street SW 2010 281 8697
Lan Proj Buil Mec Hyd Civi Cor Arcl JDH info@ Acn NOM JAYf Clie Clie Clie Clie Clie Clie Clie Clie	aning dscape ding Certifie chanical, Ele raulic, Stru- lect Manage ding Certifie chanical, Ele raulic, Stru- lengineerin sultant hitect Date Darc intarte Darc in	er er er BOTY. L1 Com.au 302 HITECT: 4 (7403) EECL ent of E 302 HITECT: 4 (7403) BECL ent of E Sydne ANDS NAG	JOHNST	AFF CKETT DSMITH HOLSON ENGINEERS Street SW 2010 281 8697 281 8697 285 com.au
Lan Proj Buil Mec Civi Cor Arcl JDH Hyd Civi Cor Arcl V Sov Sov Sov Sov Sov Sov Sov Sov Sov Sov	anning dscape ject Manage ding Certifie chanical, Ele raulic, Strud l Engineerir isultant hitect D D ARCHITECTS 27 110 978 6 110 978 7 110 97	er er er er er er er er er etrical, a02 302 BTY, L1 302 302 BTY, L1 302 302 302 BTY, L1 302 302 302 302 302 302 302 302 302 302	JOHNST	AFF CKETT DSMITH HOLSON ENGINEERS Street SW 2010 281 8697 tts.com.au
Lan Proj Buil Mec Civi Cor Arcl JDH Hyd Civi Cor Arcl V Sov Sov Sov Sov Sov Sov Sov Sov Sov Sov	anning dscape ject Manage ding Certifie chanical, Ele raulic, Struct l Engineerir isultant hitect Marchitects 27 110 978 g intarte J D ARCHITECTS 27 110 978 g 10 978 g 1	er er er er etrical, ctural & 302 302 BTY, L1 302 302 BTY, L1 302 302 BTY, L1 302 302 302 BTY, L1 302 302 BTY, L1 302 302 302 BTY, L1 302 302 BTY, L1 302 302 BTY, L1 Sydne ANDS ANDS ANDS ANDS ANDS ANDS ANDS ANDS	JOHNST	AFF CKETT DSMITH HOLSON ENGINEERS Street SW 2010 281 8697 tts.com.au
Lan Proj Buil Mec Hyd Civi Cor Arcl JDH info@ ARN NOM SO FC MI SC FC MI Dra TF Sca Dra Proje 93	anning dscape ding Certifie chanical, Ele raulic, Strue linated Reserved intect ARCHITECTS 2/10 78 a 10078  a 10078 a 10078 a 10078 a 100788 a 100788 a 10078 a	er er er er er BTY. LT corn.au 302 HITECT: (7403) BECL ent of E , Sydne ANDS NAG 0@A1 rawing DAO	JOHNST	AFF CKETT DSMITH HOLSON ENGINEERS Street SW 2010 281 8697 tts.com.au
Lan Proj Buil Mec Civi Cor Arcl Hyd Civi Cor Arcl Arcl Sov NSV 5 Bi Proj Sov NSV 5 Bi Proj Dra TF Sca Dra Proje Q	anning dscape ject Manage ding Certifie chanical, Ele raulic, Struct l Engineerir isultant hitect Marchitects 27 110 978 g intarte J D ARCHITECTS 27 110 978 g 10 978 g 1	er er er er ECtrical, ctural & 302 HITECT: 4 (7403) ECL AND AND NAG 0 @A1 rawing DAO INITIALL PREPAR	JOHNST	AFF CKETT DSMITH HOLSON ENGINEERS Street SW 2010 281 8697 tts.com.au

1			
1			
1			
1			
1			
1			
1			
1			

/ //

//	
/	
/	
//	
<pre></pre>	
/	
1	
/	
1	
/	
//	
/	
1	
_	
_	
	11
	//
11	· ,
//	
	//
	//
/	· //
7	//
	//
1	
//	· //

 	 	_

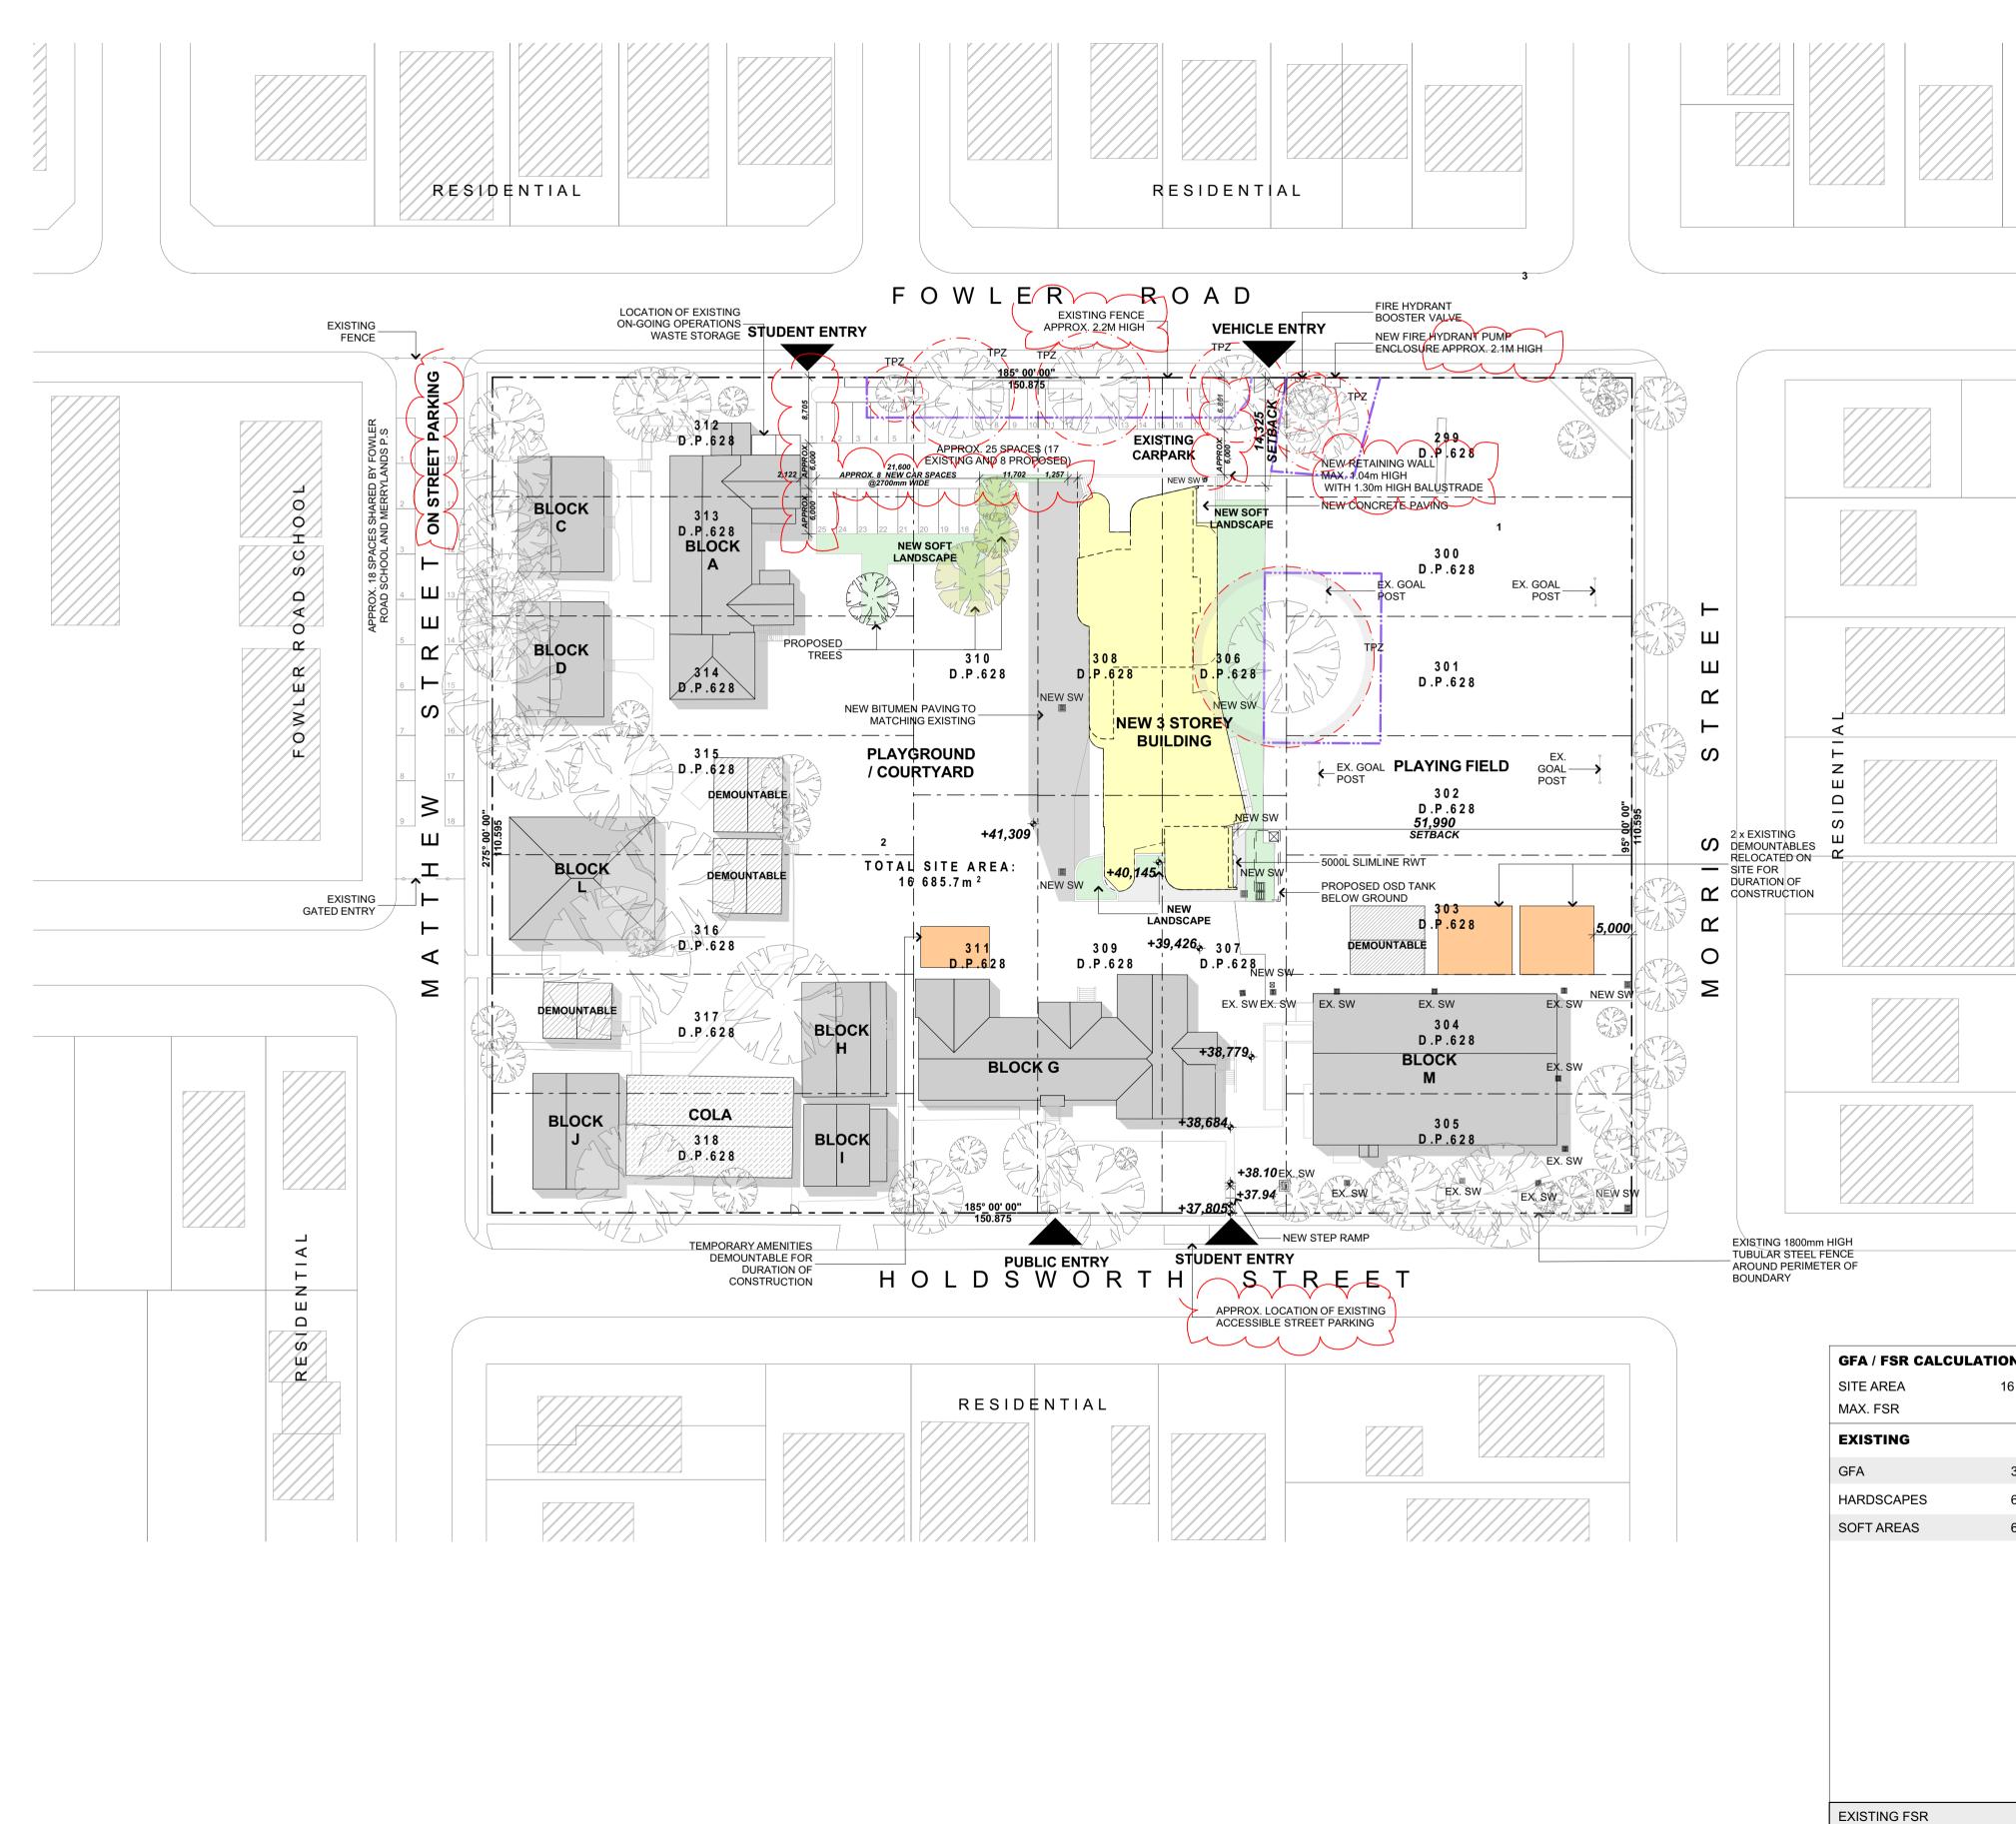

P' ''	VENDES UNTI	LISSUE		
COI ev	Date	Ву	Issue Name	СК
	08-Aug-17 05-Sep-17	AT AT	ISSUE FOR DA ISSUE FOR DA	AC AC
	18-Jan-18 03-Apr-18	AT AT	REISSUE FOR DA REISSUE FOR DA	AC AC
_				
_				
F	PROP	OSE	ED SITE LEGEN	ND
			EXISTING NEIGHBOU	RING
			BUILDI	
			EXISTING BUILDINGS ON	N SITE
			EXISTING DEMOUNT	TABLE
			BUILE	DINGS
			NEW BUIL	LDING
			SOFT LANDSC/	APING
			TEMPORARY BUILDI STRUCT	
-			- SITE BOUN	
_			- INTERNAL LOT BOUN	
_			NEIGHBOL BOUN	
_			TREE PROTECTION (TPZ) BOUND/	
_			PROTECTIVE FEN AND TPZ AREA W	
,	STA3			
ł	E IS		EXISTING	TREE
l	ST23			
1				
	and the second second		NEW	TREE
			NEW SITE E	
Pla	Inning			
	inning		SITE E	
Lar		er	SITE E	
Lar Prc	ndscape Dject Manag		SITE E S P A C LANDSCAPE DES	
Lar Prc	ndscape		SITE E	
Lar Prc Bui Me Hyo Civ	ndscape Dject Manag	er ectrica ctural &	SITE E SPAC LANDSCAPE DES JOHNSTAF	
Lar Prc Bui Me Hyu Civ Co	oject Manag oject Manag ilding Certifi chanical, El draulic, Stru ril Engineerii nsultant	er ectrica ctural 8	SITE E SPAC LANDSCAPE DES JOHNSTAF	
Lar Pro Bui Me Hyv Civ Co Arc	adscape oject Manag ilding Certifi chanical, El draulic, Stru il Engineeri nsultant chitect JDD	er ectrica ctural & ng S PTY. L S PTY. L .com.au	SITE E SITE E SPAC LANDSCAPE DES JOHNSTAFI SOHNSTAFI BLACK MAGUI GOLDSN I & NONES NICHOL GOLDSN I & NONES NICHOL SONSULTING ENGI	
Lar Pro Bui Me Hyu Civ Col Arco Arco ABD	adscape aject Manage aject Manage ilding Certific chanical, El draulic, Stru ril Engineerin nsultant chitect JDD ARCHITECTS @jdharchitects N 27 110 978 - N 10 978	er ectrica ctural a ng S PTY. L .com.au 802 802 HITECT	SITE E SITE E SPAC SPAC LANDSCAPE DES JOHNSTAF DOHNSTAF	
Lar Pro Bui Me Hyo Civ Co Arc	adscape aject Manage aject Manage ilding Certific chanical, El draulic, Stru ril Engineerin nsultant chitect JDD ARCHITECTS @jdharchitects N 27 110 978 - N 10 978	er ectrica ctural a ng S PTY. L .com.au 802 802 HITECT	SITE E SITE E SPAC SPAC LANDSCAPE DES JOHNSTAF DOHNSTAF	
Lar Pro Bui Med Hyd Cool Arc JDF Info Action JAY Clife NS	adscape aject Manag ilding Certific chanical, El draulic, Stru il Engineerin nsultant chitect JDD ARCHITECTS @jdharchitects ARCHITECTS @jdharchitects ARCHITECTS @jdharchitects ARCHITECTS @jdharchitects ARCHITECTS @jdharchitects ARCHITECTS @jdharchitects DDC HARCHITECTS @jdharchitects A	er ectrica ctural a ng SPTY. L com.au 802 802 HITECT N (7403) ECI ent of f	SITE E SITE E SPACE SPACE JOHNSTAFE JOHNSTAFE BLACK MAGUIN SOLDSN BLACK MAGUIN BLACK MAGUIN SOLDSN BLACK MAGUIN SOLDSN MAGUIN SOLDSN A SOL	
Lar Pro Bui Me Hyo Cive Arc JD-0 Arc JD-0 S B S B	adscape oject Manage ilding Certific chanical, El draulic, Stru il Engineerin nsultant chitect JDD ARCHITECTS @jdharchitects MINATED ARC NE HARRISOF MINATED ARC NE HARRISOF MINATED ARC NE HARRISOF WIDEPartmu Sridge Street	er ectrica ctural a ng SPTY. L com.au 802 802 HITECT N (7403) ECI ent of f	SITE E SITE E SPACE SPACE JOHNSTAFE JOHNSTAFE BLACK MAGUIN SOLDSN BLACK MAGUIN BLACK MAGUIN SOLDSN BLACK MAGUIN SOLDSN MAGUIN SOLDSN A SOL	
Lar Pro Bui Meyo Cline S B Pro NS S B Pro	adscape oject Manage ilding Certifie chanical, El draulic, Stru il Engineerie nsultant chitect J DD ARCHITECTS @jdharchitects MINATED ARCO NE HARRISOF NE HARRISOF with ATED ARCO NE HARRISOF WINATED ARCO NE HARRISOF WINATED ARCO NE HARRISOF STIDGES TREE STIDGES TREE STIDGES TREE Dject Name	er ectrica ctural & ng B S PTY. L .com.au 802 802 802 HITECT N (7403) ECI ent of E t, Sydn	SITE E SITE E SPACE SPACE JOHNSTAFE JOHNSTAFE BLACK MAGUIN SOLDSN BLACK MAGUIN BLACK MAGUIN SOLDSN BLACK MAGUIN SOLDSN MAGUIN SOLDSN A SOL	
Lar Pro Bui Meyo Cline S B Pro NS S B Pro	adscape oject Manage ilding Certific chanical, El draulic, Stru il Engineerin nsultant chitect JDD ARCHITECTS @jdharchitects N 110 978 MINATED ARC NE HARRISOF ent VERNMENT W Departmu- bridge Streed oject Name	er ectrica ctural & ng B S PTY. L .com.au 802 802 802 HITECT N (7403) ECI ent of E t, Sydn	SITE E SITE E SITE E SPACE SPA	
Lar Pro Bui Meyo Cive Arc Jhoo Arc Jhoo Arc S B Pro S B F C	adscape aject Manage ilding Certific chanical, El draulic, Stru il Engineerin nsultant chitect JDD ARCHITECTS @idharchitects A 27 110 978 MINATED ARC WINATED ARC N 110 978 MINATED ARC WINATED ARC WINATED ARC WINATED ARC WINATED ARC WINATED ARC WINATED ARC DOCULER	er ectrica ctural a ng SPTY. L 802 802 HITECT N (7403) Edu ent of fe t, Sydn LAN L ROA	SITE E SITE E SI	
Lar Pro Bui Meyo Civ Arc Jinfo Actor Jinfo Actor Arc S S B Pro Meyo S S B Pro Meyo S S S S S S S S S S S S S	adscape aject Manage ilding Certific chanical, El draulic, Stru il Engineerin nsultant chitect JDD ARCHITECTS @idharchitects A 27 110 978 MINATED ARC WINATED ARC N 110 978 MINATED ARC WINATED ARC WINATED ARC WINATED ARC WINATED ARC WINATED ARC WINATED ARC DOCULER	er ectrica ctural a ng SPTY. L 802 802 HITECT N (7403) Edu ent of fe t, Sydn LAN L ROA	SITE E SITE E SI	
Lar Pro Bui Meyo Co Arc Jinfothactory Jacob S B Pro S FC Meyo S B Pro S B S B Pro S B S B S B S B S B S B S B S B S B S B	adiscape aject Manage aject Manage ilding Certific chanical, El draulic, Stru il Engineerin nsultant thitect JDD ARCHITECTS @jdharchitects N 110 978 - MINATED ARC N 100 978 - MINATED ARC N 100 978 - MINATED ARC N 100 978 - MINATED ARC MINATED AR	er ectrica fng B-FT S-PTY. L S-PTY. L S-COM.au 802 802 802 802 802 802 802 802	SITE E SITE E SITE E SITE PLAN SITE PLAN SITE PLAN	
Lar Pro Bui MeyoCo Arc Jin66AC007 Jin66AC007 Arc Jin66AC007 Arc NS 5 Pro NS 5 Pro NS 5 Pro NS 5 Pro NS 5 Pro	adiscape aject Manage aject Manage ilding Certific chanical, El draulic, Stru il Engineerin nsultant thitect JDD ARCHITECTS @jdharchitects N 110 978 - MINATED ARC N 100 978 - MINATED ARC N 100 978 - MINATED ARC N 100 978 - MINATED ARC MINATED AR	er ectrica ctural a ng SPTY. L 802 802 HITECT N (7403) Edu ent of B t, Sydn LAN L ROA	SITE E SITE E SITE E SITE PLAN SITE PLAN SITE PLAN	
Lar Pro Bui Meyolo Arc JinfoBACO Arc JinfoBACO Arc S B Pro S C Me S C Dra Dra Dra Dra	addiscape  aject Managy  idding Certifit  chanical, El draulic, Stru  il Engineeria  chancal, El draulic, Stru  il Engineeria  chitect  DDD  ARCHITECTS  aject Name  ERRYI  bridge Streef  bridge Streef  choo  DWLER ERRYI  choo  DWLER ERRYI  choo	er ectrica fng B-FT S-PTY. L S-PTY. L S-COM.au 802 802 802 802 802 802 802 802	SITE E SITE E SITE E SITE PLAN SITE PLAN NO. Rev.	

TIONS		
16 685.7m <sup>2</sup>		
0.5:1		
	PROPOSED	
3215.1m <sup>2</sup>	GFA:	
6476.8m <sup>2</sup>	EXISTING	3215.1m <sup>2</sup>
6993.8m <sup>2</sup>	DEMOLISHED/REMOVED	563.8m <sup>2</sup>
	NEW	2471.6m <sup>2</sup>
	TOTAL GFA	5122.9m <sup>2</sup>
	NEW HARDSCAPES	63.7m <sup>2</sup>
	DEMOLISHED/REMOVED	651.4m <sup>2</sup>
	TOTAL HARDSCAPES	5889.1m <sup>2</sup>
	NEW SOFT AREAS / DEEP SOIL ZONES	461m <sup>2</sup>
	DEMOLISHED/REMOVED	242.3m <sup>2</sup>
	TOTAL SOFT AREAS / DEEP SOIL ZONES	7212.5m <sup>2</sup>
0.19:1	NEW FSR	0.3:1







1			


































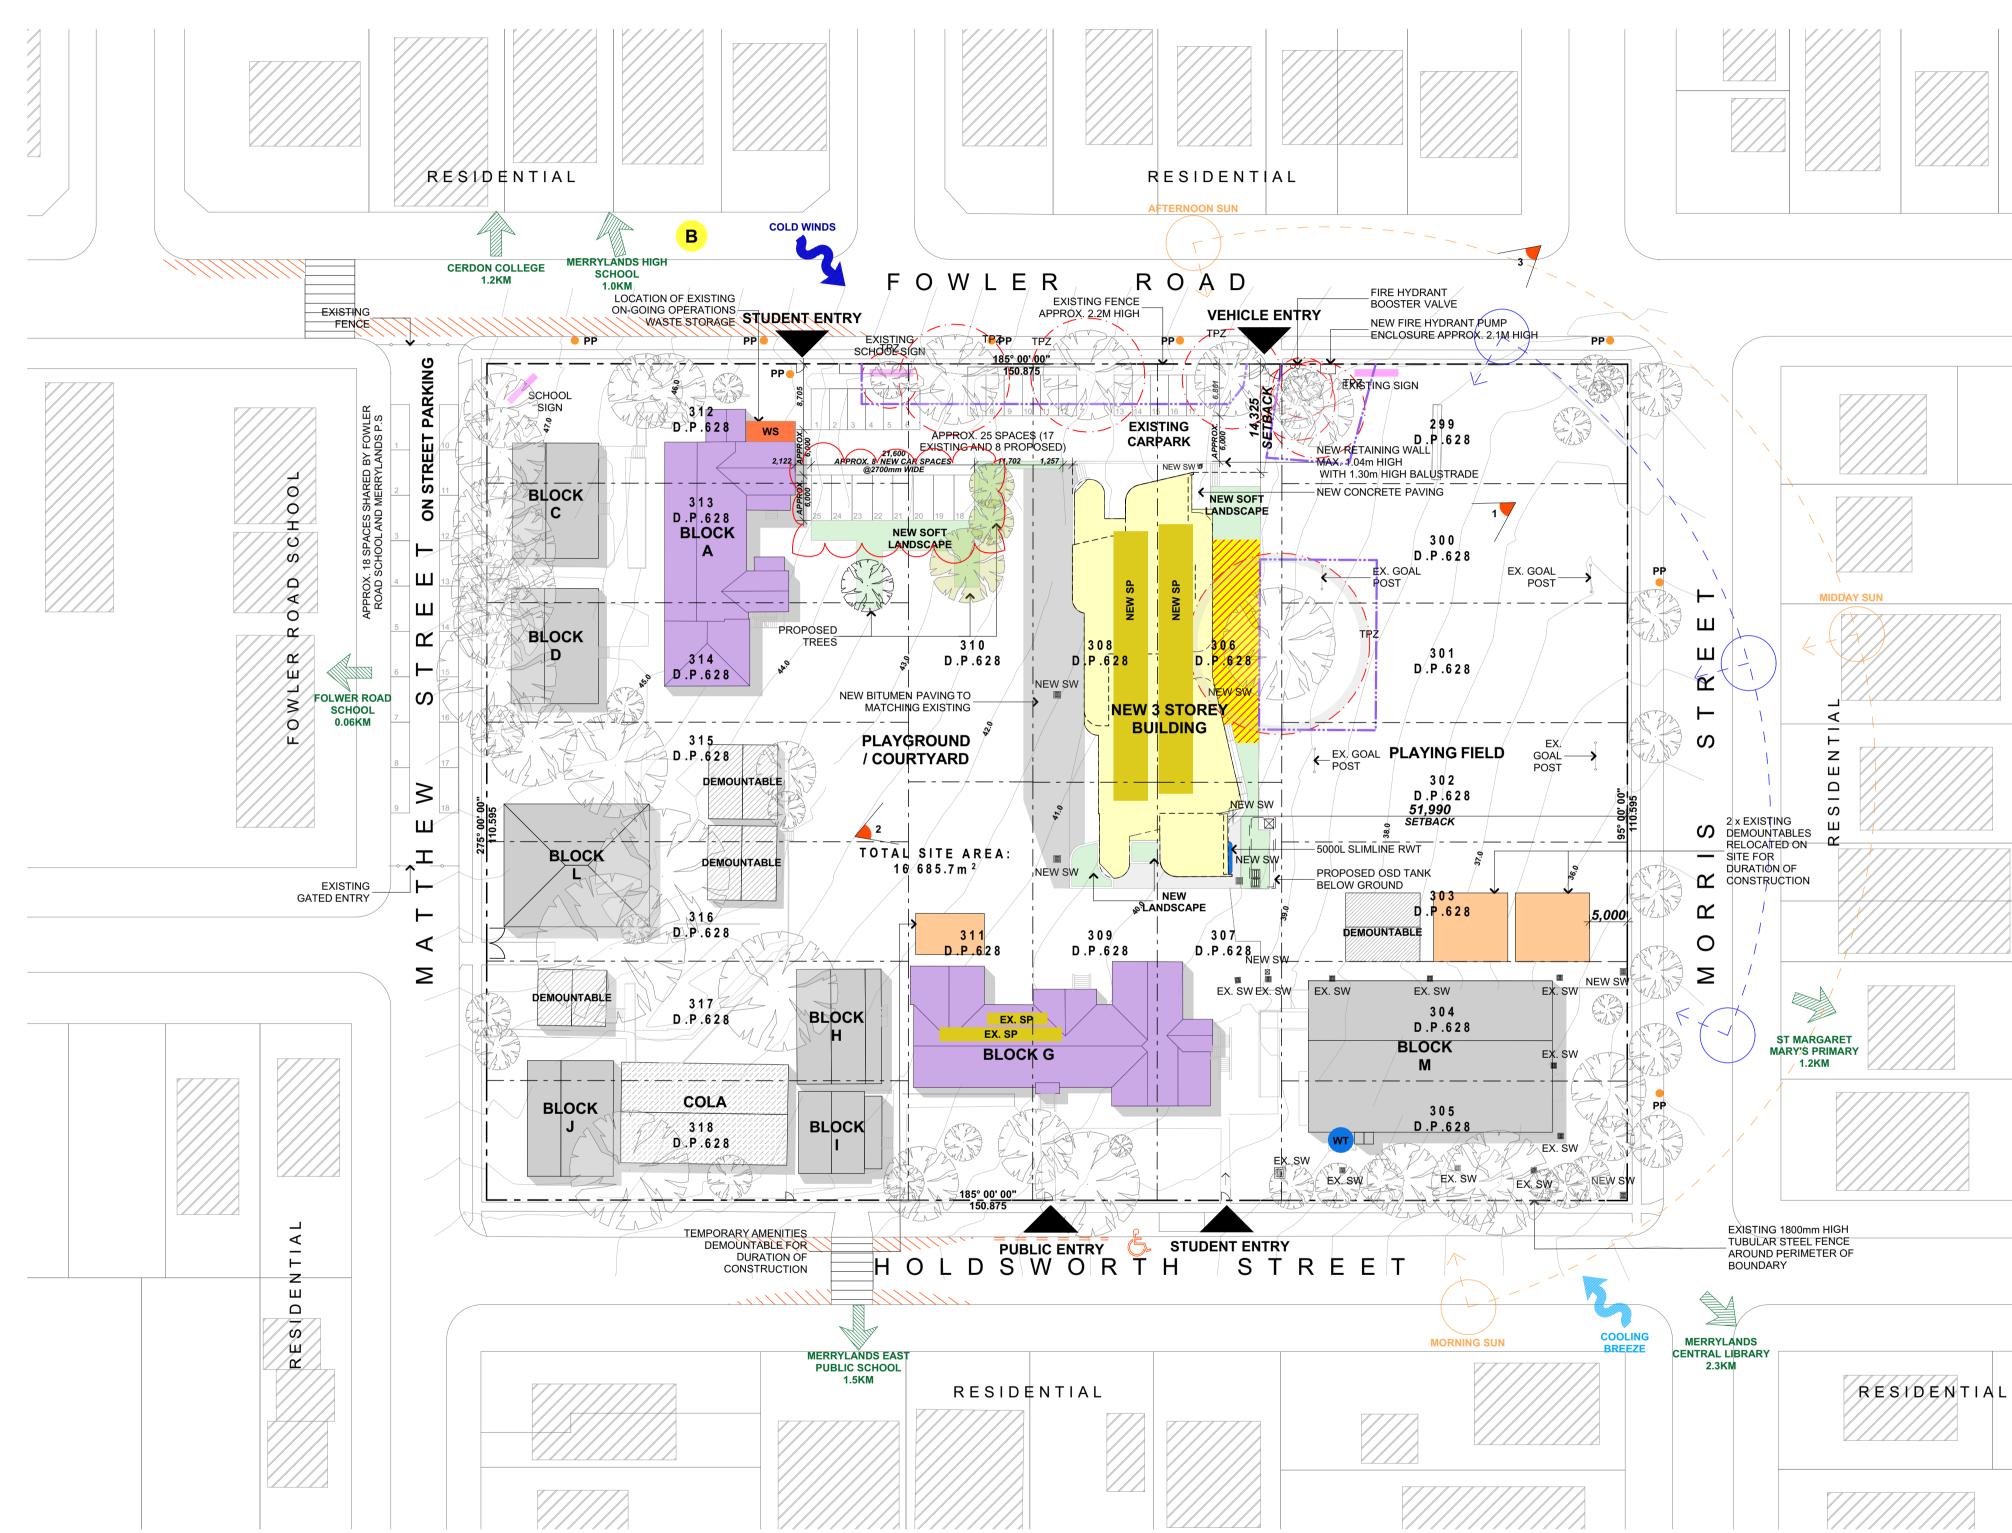


Rev A	NSTRUCTION Date 08-Aug-17		D BY THE ARCHITECT FOR Issue Name ISSUE FOR DA	
B C	05-Sep-17 18-Jan-18	AT AT	ISSUE FOR DA REISSUE FOR DA	
	LEGE	חא		
1			HERITAGE STRUCTURES	
		Т	PZ GROUND PROTECTION	
ACT THE			EXISTING TREE	
_			SITE BOUNDARY	
_			INTERNAL LOT BOUNDARY NEIGHBOURING	
_			BOUNDARY	
_			(TPZ) BOUNDARIES PROTECTIVE FENCING AND TPZ AREA WITHIN	
			NO STOPPING	
_	= = =	=	NO PARKING	
(	E		ACCESSIBLE PARKING	
			CROSSING	
			SITE ACCESS GATE ACCESS	
			SUMMER SUN PATH	
(		/	WINTER SUN PATH	
(			RAIN <b>WATER TANK</b>	
	SP		SOLAR PANELS	
			SIGNAGE	
	PP		POWER POLE	
	ws		WASTE STORAGE	
	SWP		STORM WATER PIT	
	в		BUS STOP	
<b></b>			LOCAL SCHOOLS	
			PERSPECTIVE VIEW	
/			LOCATIONS	
Arc		н	architec	ts
info	HARCHITECT @jdharchitects N 27 110 978	'S PTY. L' s.com.au	TD. 44 Little Oxford Stree Darlinghurst, NSW 2	et 010
ACI NO JAY	N 110 978 MINATED ARG (NE HARRISC	802 CHITECT:		869 <i>1</i> om.a
Cli	ent		MERSER	DS
NS	W Departm Bridge Stree	nent of E		TOT
	oject Name		DS PUBLIC	
	CHOO OWLER	L		
Μ	ERRYL		S NSW 2160	
	awing Title	ED S	BITE ANALYSIS PLA	٨N
Sc		0 @A1		vpr-1
		Drawing		
9	97   [	JAI	∠  U	


/		

/	/	/	1	
	/			
/	/			
/	/		J.	
,    	/			
/	/	_		



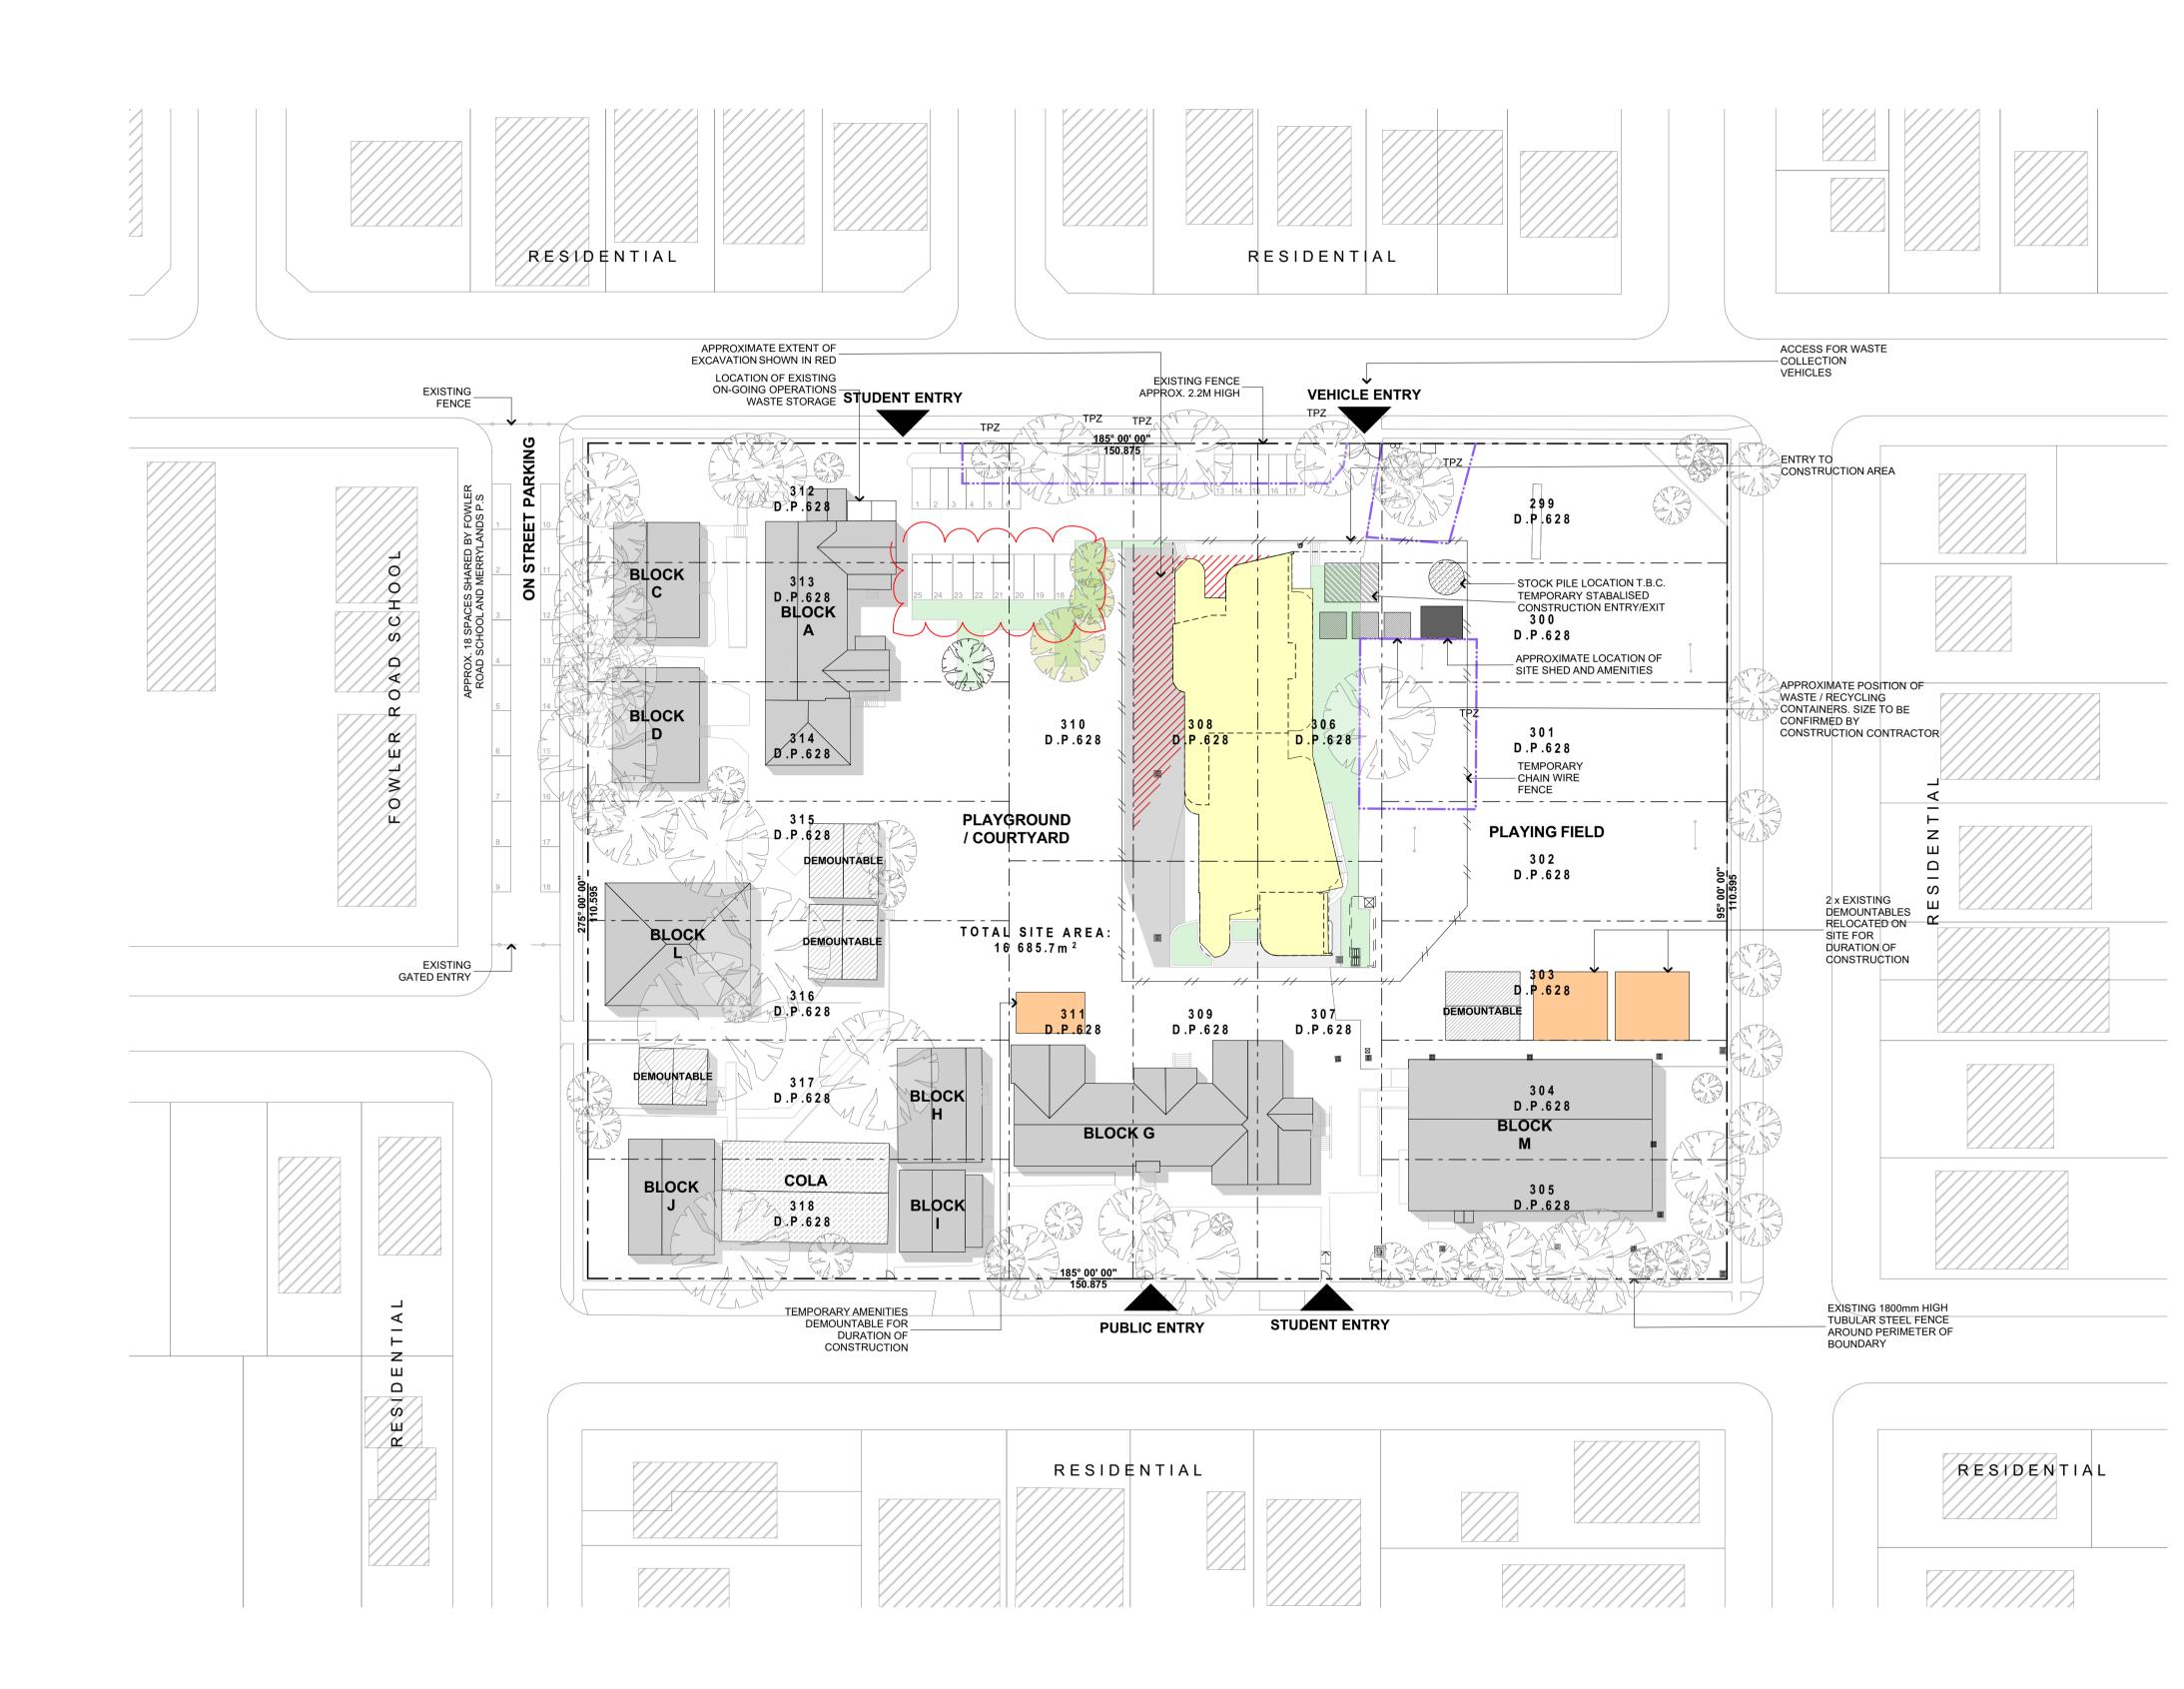


USE DR/ PUF COI	NSTRUCTION.			
ev	Date 08-Aug-17	By AT	Issue Name ISSUE FOR DA	CK AC
	05-Sep-17 18-Jan-18	AT AT	ISSUE FOR DA REISSUE FOR DA	AC AC
V	VASTE	E LI	EGEND	
			STOCK PIL	E
		ST	ABALISED CONSTRUCTIC ENTRY/EX	
			WASTE / RECYCLIN CONSTAINER	
2				
		RE	LOCATED DEMOUNTABLE DURING CONSTRUCTIC	
		ŝ	SITE SHED AND AMENITIE	S
1	//////			
	//////	A	PPROXIMATE EXCAVATIO	N
-		,	CONSTRUCTION SIT	
Dia				
	ınning			dfp
	nning		S P A C	
Lar		er		
Lar	ndscape Dject Manage		JOHNSTA	FF F
Lar	ndscape		LANDSCAPE DE	FF KETT JIRE+
Lar Pro Bui Me Hyd	ndscape oject Manage ilding Certifie chanical, Ele draulic, Struc ril Engineerir	ectrica	JOHNSTA JOHNSTA MAGL GOLDS	FF FF
Lar Pro Bui Me Hyu Civ Co	ndscape Dject Manage ilding Certifie cchanical, Ele draulic, Struc	ectrica	JOHNSTA JOHNSTA BLAC GOLDS	FF FF
Lar Pro Bui Me Hyu Civ Co	ndscape oject Manage ilding Certifie chanical, Ele draulic, Struc ril Engineerir nsultant	er ectrica ctural &	JOHNSTA JOHNSTA BLAC GOLDS	KETT JIRE+ SMITH DLSON GINEERS
Lar Prc Bui Me Hyu Civ Co Arc	bject Manage bject Manage ilding Certifie chanical, Ele draulic, Struc il Engineerir nsultant chitect	er ectrica ctural a ig	JOHNSTA JOHNSTA BLAC MAGL GOLDS I, & JONES NICHC CONSULTING EN ACCONSULTING EN ACCONSULTING EN ACCONSULTING EN ACCONSULTING EN ACCONSULTING EN ACCONSULTING EN ACCONSULTING EN	FF KETT JIREH DISON GINEERS CTS reet / 2010
Lar Pro Bui Me Hyu Civ Co Arc Arc	bject Manage bject Manage ilding Certifie chanical, Ele draulic, Struc il Engineerir nsultant chitect	er ectrica ttural a ig PTY. L com.au 02 HITECT	JOHNSTA JOHNSTA JOHNSTA BLAC MAGL GOLDS I, & JONES NICHC GOLDS I, & JONES NICHC GOLDS I, MAGL I, MAGL M	KETT JIRE+ SMITH DLSON GINEERS CtS reet / 2010 11 8697
Lar Pro Bui Me Hyv Civ Co Arc	bject Manage bject Manage ilding Certifie chanical, Ele draulic, Struc ril Engineerir nsultant chitect JDD HARCHITECTS @jdharchitects. N 27 110 978 8 NINATED ARCI	er ectrica ttural a ig PTY. L com.au 02 HITECT	JOHNSTA JOHNSTA JOHNSTA BLAC MAGL GOLDS I, & JONES NICHC GOLDS I, & JONES NICHC GOLDS I, MAGL I, MAGL M	KETT JIRE+ SMITH DLSON GINEERS CtS reet / 2010 11 8697
Lar Pro Bui Me Hyd Civ Civ Civ Civ Civ Civ Civ Civ Civ Civ	adscape bject Manage ilding Certifie ilding Certifie chanical, Ele draulic, Struc ril Engineerir nsultant chitect JDD ARCHITECTS @jdharchitects. N 27 110 978 8 MINATED ARCI NE HARRISON	er ectrica ttural a ig PTY. L com.au 02 HITECT	JOHNSTA JOHNSTA JOHNSTA BLAC MAGL GOLDS I, & JONES NICHC GOLDS I, & JONES NICHC GOLDS I, MAGL I, MAGL M	KETT JIRE+ SMITH DLSON GINEERS CtS reet / 2010 11 8697
	andscape bject Manage ilding Certifie chanical, Ele draulic, Struc il Engineerir nsultant chitect JDD ARCHITECTS @idharchitects N 110 978 8 MINATED ARCI YE HARRISON ent WDepartme	er ectrica ctural & ng FTY. L com.au 302 HITECT I (7403) ECI ent of E	JOHNSTA JOHNSTA BLAC MAGE GOLDS I A DONES NICHC CONSULTING EN A A Little Oxford St Darlinghurst, NSW Telephone: 02 926 www.jdharchitects	KETT JIRE+ SMITH DLSON GINEERS CtS reet / 2010 11 8697
Lai Pro Bui Me Hyt Civ Arc JDho Arc JDho Arc So S E	andscape bject Manage ilding Certifie chanical, Ele draulic, Struc il Engineerir nsultant chitect JDD ARCHITECTS @jdnarchitects. MINATED ARCI YE HARRISON ent WDepartme Bridge Street	er ectrica ctural & ng FTY. L com.au 302 HITECT I (7403) ECI ent of E	JOHNSTA JOHNSTA BLAC MAGE GOLDS I A DONES NICHC CONSULTING EN A A Little Oxford St Darlinghurst, NSW Telephone: 02 926 www.jdharchitects	KETT JIRE+ SMITH DLSON GINEERS CtS reet / 2010 11 8697
Lar Proc Bui Met Hyi Clivio Co NOI So So So So So So So So So So So So So	Dject Manage Dject Manage ilding Certifie chanical, Ele draulic, Strue il Engineerir nsultant chitect JDD ARCHITECTS @jdharchitects. MINATED ARCH MINATED ARCHITECTS @jdharchitects. N 27 110 978 8 MINATED ARCHITECTS WID ARCHITECTS @jdharchitects. W Departme Bridge Street Dject Name ERRYL	er ectrica ctural & ig PTY. L com.au 302 HITECT I (7403) Edu ent of E , Sydn	JOHNSTA JOHNSTA BLAC MAGE GOLDS I A DONES NICHC CONSULTING EN A A Little Oxford St Darlinghurst, NSW Telephone: 02 926 www.jdharchitects	KETT JIRE+ SMITH DLSON GINEERS CtS reet / 2010 11 8697
Laa Production Build Bui	adscape bject Manage ilding Certifie chanical, Ele draulic, Strue il Engineerir nsultant chitect DDD ARCHITECTS @jdharchitects. N 110 978 8 MINATED ARCI WID PARCISON ent WDepartme Bridge Street Digect Name ERRYL CHOOOI	er ectrica bg FPTY. L com.au 302 HITECT I (7403) ECI ent of E , Sydn _AN	JOHNSTA JOHNSTA JOHNSTA MAGE COLDS MAGE MA	KETT JIRE+ SMITH DLSON GINEERS CtS reet / 2010 11 8697
Lai Pro Bui Metyoco Arc JinfohActoory Clinic S 5 Pro S 6	adscape bject Manage ilding Certifie chanical, Ele draulic, Struc- il Engineerir nsultant chitect JDD ARCHITECTS @jdnarchitects. N 27 110 978 8 MINATED ARCI WE HARRISON ent WD Departme Bridge Street Dject Name ERRYL CHOOOI DWLER	er ectrica ctural & ig FTY. L com.au 302 HITECT i (7403) Edu ent of E , Sydn AN ROA	JOHNSTA JOHNSTA JOHNSTA MAGE COLDS MAGE MA	KETT JIRE+ SMITH DLSON GINEERS CtS reet / 2010 11 8697
Lai Pro Bui Meyoco Arc Jin66hCology Clinic S S F M S F M	adscape bject Manage ilding Certifie chanical, Ele draulic, Struc- il Engineerir nsultant chitect JDD ARCHITECTS @jdnarchitects. N 27 110 978 8 MINATED ARCI WE HARRISON ent WD Departme Bridge Street Dject Name ERRYL CHOOOI DWLER	er ectrica ctural & ig FTY. L com.au 302 HITECT i (7403) Edu ent of E , Sydn AN ROA	JOHNSTA JOHNSTA JOHNSTA JOHNSTA MAG BLAC MAG MAG MAG AD,	KETT JIRE+ SMITH DLSON GINEERS CtS reet / 2010 11 8697
Lai Pro Bui Meyoco Arc JinfohActoory Clinic S 5 Pro Dra	awing Title	er ectrica dig PTY. L com.au 302 HITECT 1 (7403) Edu ent of E , Sydn AND ROA	JOHNSTA JOHNSTA JOHNSTA JOHNSTA MAG BLAC MAG MAG MAG AD,	KETT JIRE+ SMITH DLSON GINEERS CtS reet / 2010 11 8697
Lai Pro Bui Meycico Arc Jingactoly Ci Co S S F M Dra Dra V S	aving Title	er ectrica dig PTY. L com.au 302 HITECT 1 (7403) Edu ent of E , Sydn AND ROA	JOHNSTA JOHNSTA JOHNSTA MAGEMENT PLAN	FF KETT JIREH DISON GINEERS CTS reet / 2010 11 8697 .com.au
Lai Pro Bui Meycico Arc JineBecco Arc JineBecco Arc JineBecco Arc JineBecco Arc JineBecco Arc S S S S S S S S S S S S S	Dject Manage Dject Manage ilding Certifie Chanical, Ele draulic, Strue illicharchitects DDD ARCHITECTS @jdharchitects MINATED ARCI NE HARRISON ent DDVLER Bridge Street Dject Name ERRYLA DOVLER ERRYLA DOVLER ERRYLA Awing Title ASTE M awing Title CHOOI	er ectrica ig FTY. L com.au 302 HITECT (7403) ECI ant of E , Sydn AND ROA AND	JOHNSTA JOHNSTA JOHNSTA MAGEMENT PLAN AGEMENT PLAN No. Rev.	FF KETT JIREH DISON GINEERS CTS reet / 2010 11 8697 .com.au

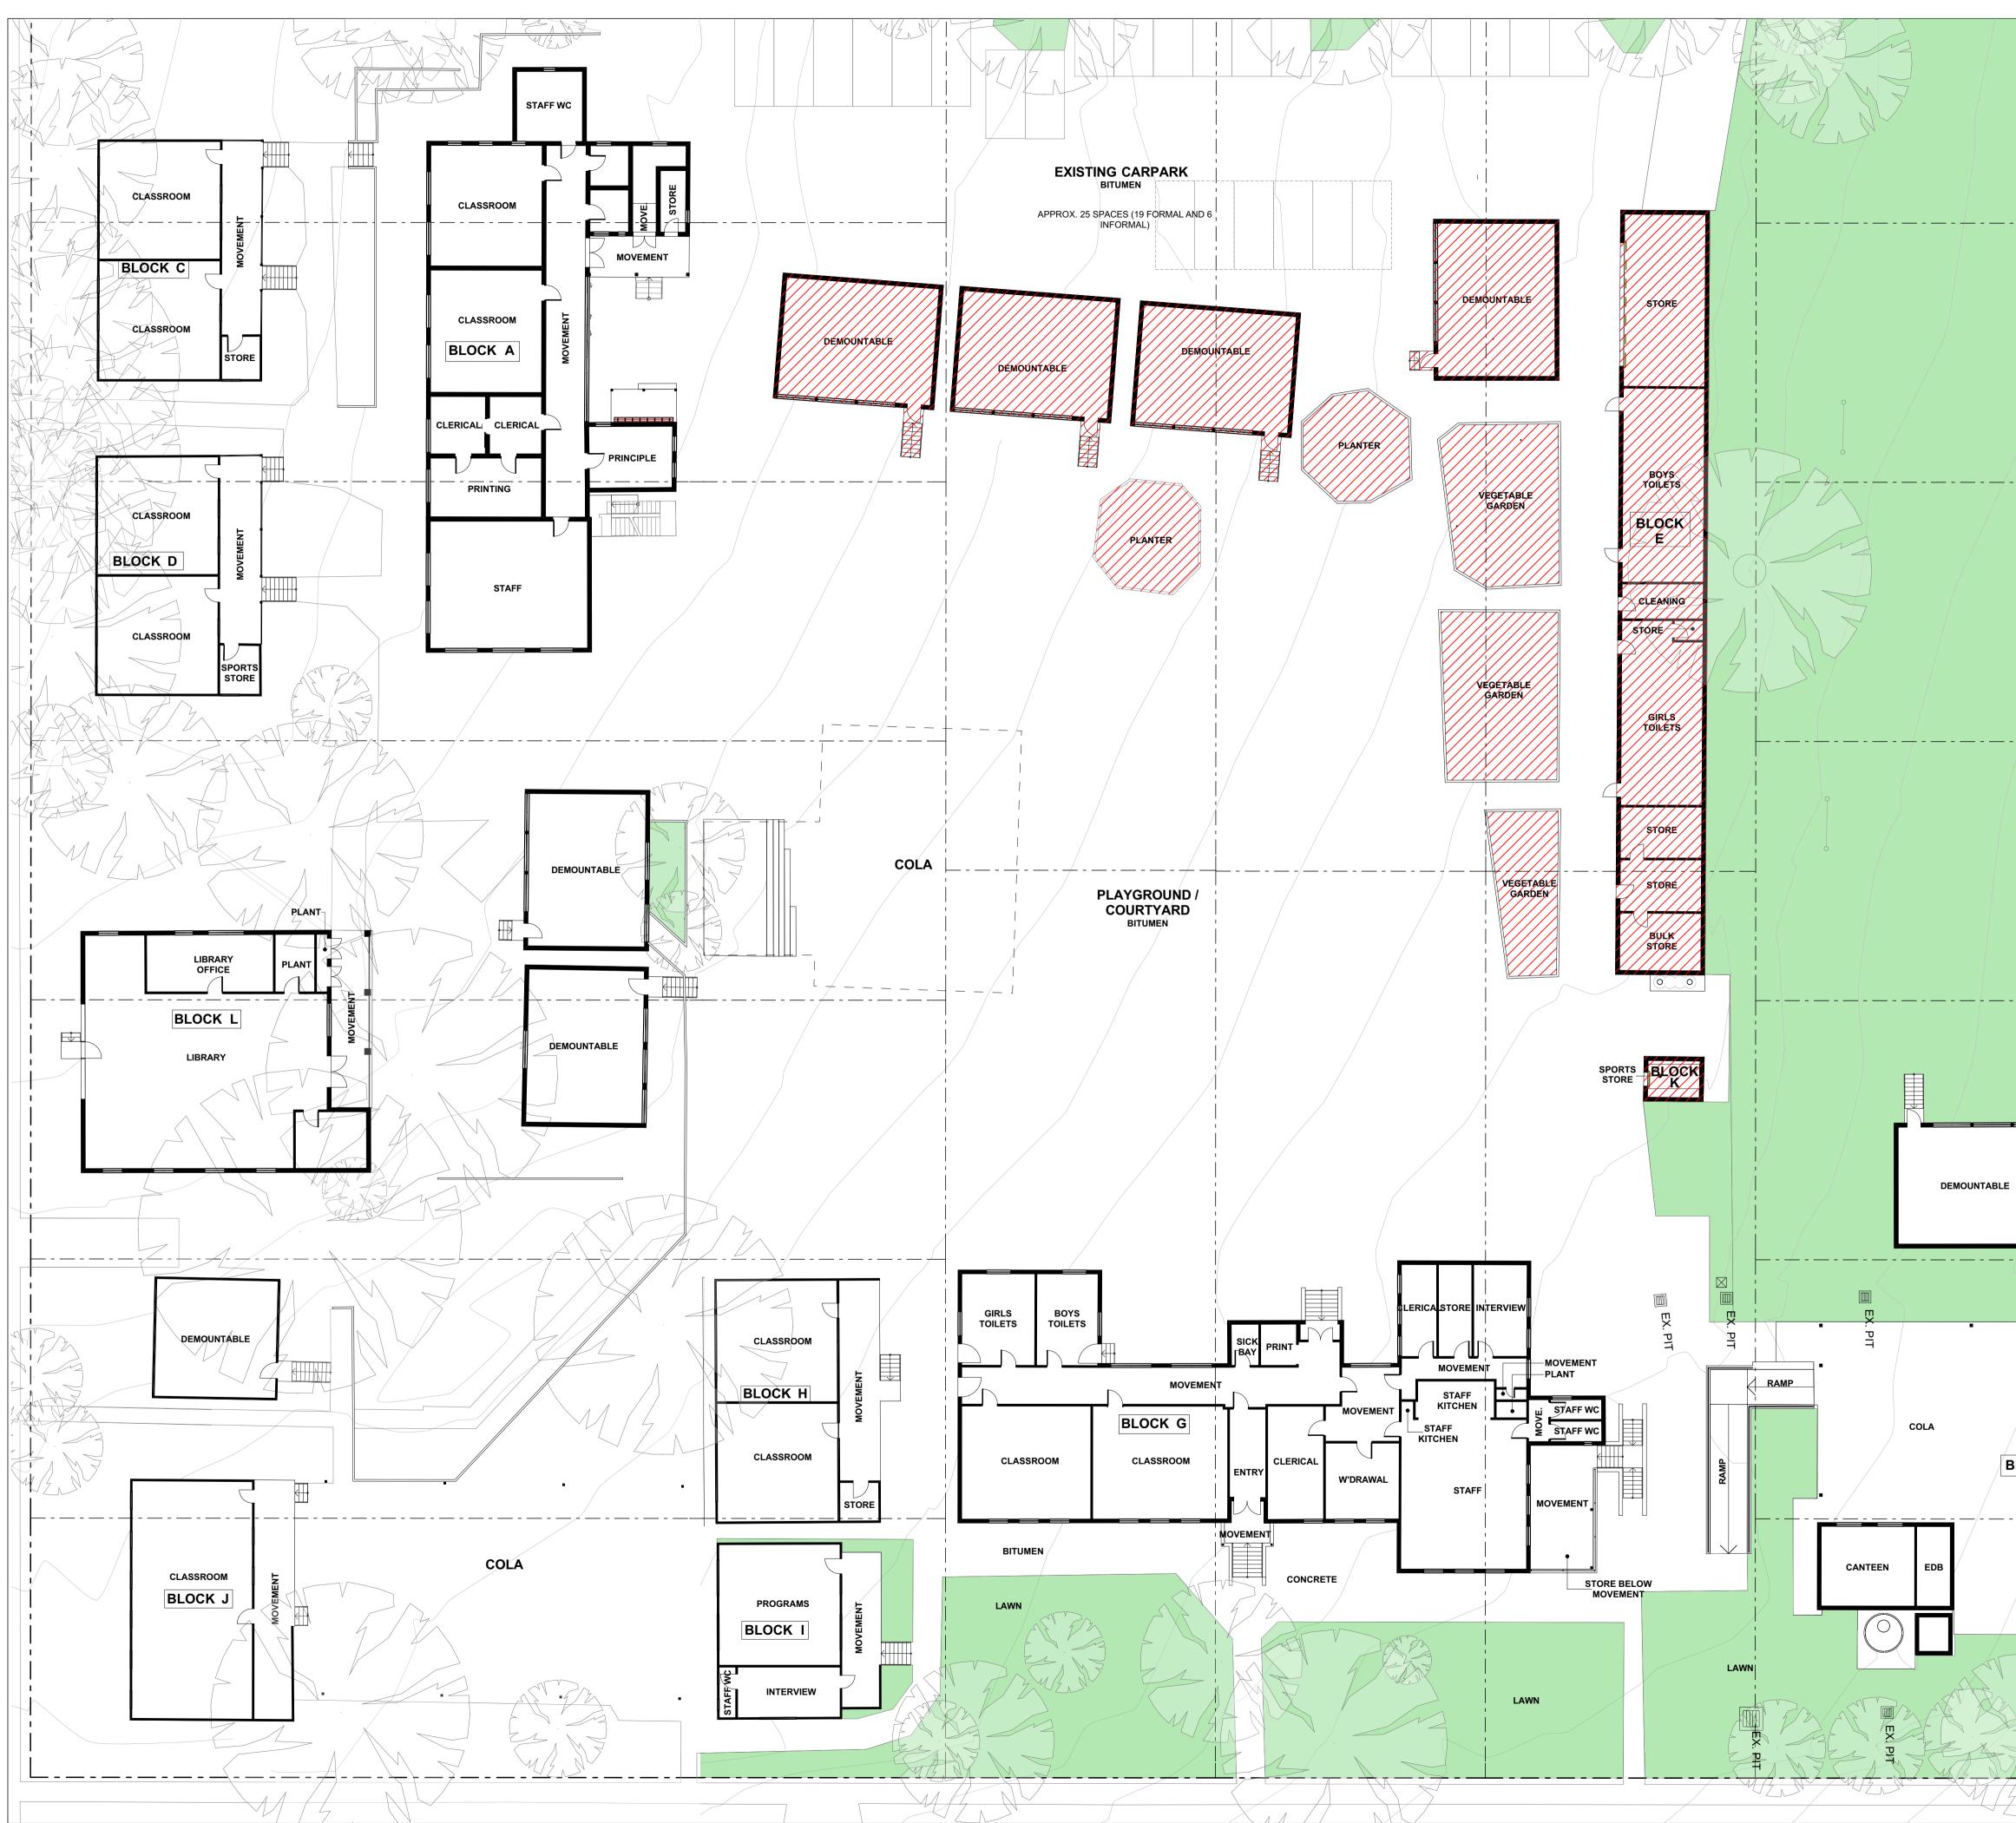


-17	© COPYRIGHT JDH ARCHITECTS PTY. LTD. THE CONTRACTOR SHALL CHECK AND VERIFY ALL DIMENSIONS AND VERIFY ALL ERRORS AND OMISSIONS TO THE ARCHITECT. USE FIGURATIVE DIMENSIONS, DO NOT SCALE THE DRAWINGS. DRAWINGS SHALL NOT BE USED FOR CONSTRUCTION PURPOSES UNTIL ISSUED BY THE ARCHITECT FOR CONSTRUCTION.
CONCRETE	Rev         Date         By         Issue Name         CK           A         08-Aug-17         AT         ISSUE FOR DA         AC           B         05-Sep-17         AT         ISSUE FOR DA         AC
	EXISTING LEGEND
	REMOVED / DEMOLISED
	EXISTING LAWN / PLAYING FIELD
	EXISTING WALLS
	EXISTING TREE
///	
SPORT/COURT	
	Planning
	Planning           Landscape         SPACE           LANDSCAPE DESIGNS
	Landscape SPACE LANDSCAPE DESIGNS Project Manager
	Landscape SPACE
	Landscape          Landscape       SPACE         Project Manager       JOHNSTAFF         Building Certifier       BLACKETT
	Landscape SPACE Landscape JOHNSTAFF Building Certifier JOHNSTAFF Building Certifier BLACKETT Mechanical, Electrical, Hydraulic, Structural & Civil Engineering Consultant Architect
	Landscape Project Manager Project Manager Building Certifier Building Certifier Mechanical, Electrical, Hydraulic, Structural & Civil Engineering Consultant Mechanical, Electrical, Hydraulic, Structural & Civil Engineering Consultant Architect JDH ARCHITECTS PTY. LTD. Info@jdharchitects.com.au ABN 27 110 978 802 ACN 110 978 802
PIT MOVEMENT FIT	Landscape  Landscape  Project Manager  Project Manager  JOHNSTAFF  Building Certifier  Mechanical, Electrical, Hydraulic, Structural & Civil Engineering Consultant  Mechanical, Electrical, Hydraulic, Structural & Civil Engineering Consultant  Architect  JDH ARCHITECTS PTY. LTD. Info@jdharchitects.com.au ABN 27 110 978 802  AND 110 978 802  Building Certifier  Building Certifier  And Consultant  And Con
	Landscape Landscape Project Manager Project Manager Building Certifier Mechanical, Electrical, Hydraulic, Structural & Civil Engineering Consultant Architect JDHARCHITECTS PTY. LTD. Info@jdharchitects.com.au ABM 27 110 978 802 ACM
	Landscape Project Manager Project Manager Building Certifier Mechanical, Electrical, Hydraulic, Structural & Civil Engineering Consultant Mechanical, Electrical, Hydraulic, Structural & Civil Engineering Consultant Architect JDHARCHITECTS PTY.LTD. Info@jdharchitects.com.au ARN 27 110 978 802 ACN 110 978 AD2 ACN 110 ACN 110 ACN 110 ACN 110 ACN 110 ACN 110 A
PT PT MOVEMENT Name OCK M COCK M COCK M COULET COBBY COBC COB COB COB CO	Landscape Landscape Landscape Project Manager JOHNSTAFF Building Certifier Mechanical, Electrical, Hydraulic, Structural & Civil Engineering Consultant Architect JDH ARCHITECTS PTY. LTD. INDER ARRISON (7403) INDER
PT PT MOVEMENT STAGE OCK M OCK M STAGE TOILET TOILET TOILET TOILET SHOWER/ TOILET SHOWER/ TOILET	<text><text><text><text><text><text><text><text><text><text><text><text><text></text></text></text></text></text></text></text></text></text></text></text></text></text>
OCK M OCK M OCK M TOILET LOBBY TOILET LOBBY TOILET SHOWER/ TOILET	Landscape Landscape Project Manager Project Manager Building Certifier Mechanical, Electrical, Hydraulic, Structural & Civil Engineering Consultant Architect JDH ARCHITECTS PTY. LTD. Info@diarchitects com.au ABN 27 110978 802 NOMINATED ARCHITECTS NOTION 110978 802 NOMINATED ARCHITECTS AND LARCHITECTS PTY. LTD. Info@diarchitects.com.au ABN 27 110978 802 NOMINATED ARCHITECTS NOMINATED ARCHITECTS NOMINATED ARCHITECTS NOMINATED ARCHITECTS SYNE HARRISON (7403) Client MERRYLANDS PUBLIC SCHOOL FOWLER ROAD, MERRYLANDS NSW 2160 Drawing Title
OCK M OCK M STAGE OCK M STAGE TOILET TOILET TOILET SHOWER/ TOILET	Landscape Landscape Landscape Project Manager Project Manager  Mechanical, Electrical, Hydraulic, Structural & Civil Engineering Consultant Architect  JDH ARCHITECTS PTY.LTD, MINATED ARCHITECTS JAYNE HARRISON (7403)  Client  Client  MERRYLANDS PUBLIC SCHOOL  FOWLER ROAD, MERRYLANDS NSW 2160  Drawing Title  EXISTING GROUIND ELOOOR PLANS
OCK M OCK M OCK M OCK M STAGE TOILET	Landscape Landscape Landscape Landscape Project Manager JOHNSTAFF Building Certifier Mechanical, Electrical, Hydraulic, Structural & Civil Engineering Consultant Architect JDH ARCHITECTS PTY. LTD. Info@idharchitects.com.au ARN 27 110 978 802 COMMINATED ARCHITECT: JAYNE HARRISON (7403) LICIEN Client Client Client DSW Department of Education S Bridge Street, Sydney Project Name MERRYLANDS PUBLIC SCHOOL FOWLER ROAD, MERRYLANDS NSW 2160 Drawing Title EXISTING GROUND FLOOR PLANS Scale : 1:200 @A1 Date : 19-Apr-18




		THE AND USE DRA PURI CON	CONTRAC VERIFY AL FIGURATIN WINGS SH POSES UN STRUCTIO	TOR SHA L ERROF /E DIMEN ALL NOT TIL ISSUI N.	RS AND OMISSIC ISIONS, DO NOT BE USED FOR C ED BY THE ARCI	VERIFY ALL DIME DNS TO THE ARCH SCALE THE DRA CONSTRUCTION	HITECT. WINGS.
	z n Vų	Rev A B	Date 08-Aug-17 05-Sep-17	AT AT	Issue Name ISSUE FOR D ISSUE FOR D		AC AC
		E	XIST	ING	LEGE	ND	
				BUI		RUCTURES TO VED / DEMOLI	
					EXIST	ING LAWN / PI	FIELD
· · · · · · · · _				2		EXISTING	
		Lan	dscape		2	<b>SPA</b>	SIGNS
			ect Mana				
·		Mec Hyd Civil	hanical, I raulic, Sti Enginee sultant	Electrica		ONES NICHC	SMITH
		Arch	nitect		LTD. 44 L		eet
		ABN ACN NOM	27 110 97 110 97 INATED AF IE HARRIS	8 802 8 802 RCHITEC <sup>-</sup>	Tele T: www	linghurst, NSW ephone: 02 928 w.jdharchitects.	1 8697
BLOCK M		NSV	SW ERNMENT V Departu idge Stre	nent of	UCation Education ney	n	
·		M	ect Name ERRY CHOC	'LAN	NDS PU		
		ME	WLEF ERRYL	AND	AD, 9S NSW 2	2160	
	<12)	EX Sca Drav	(ISTIN le : 1:2 wn : AT	G FII		Checked :AC	-Apr-18
		<b>9</b> 9			22		
	M,	CERI	FIFIED ISC 9001	ARCH	ARED IN CONFOR TECTS Q.M.S. PF		

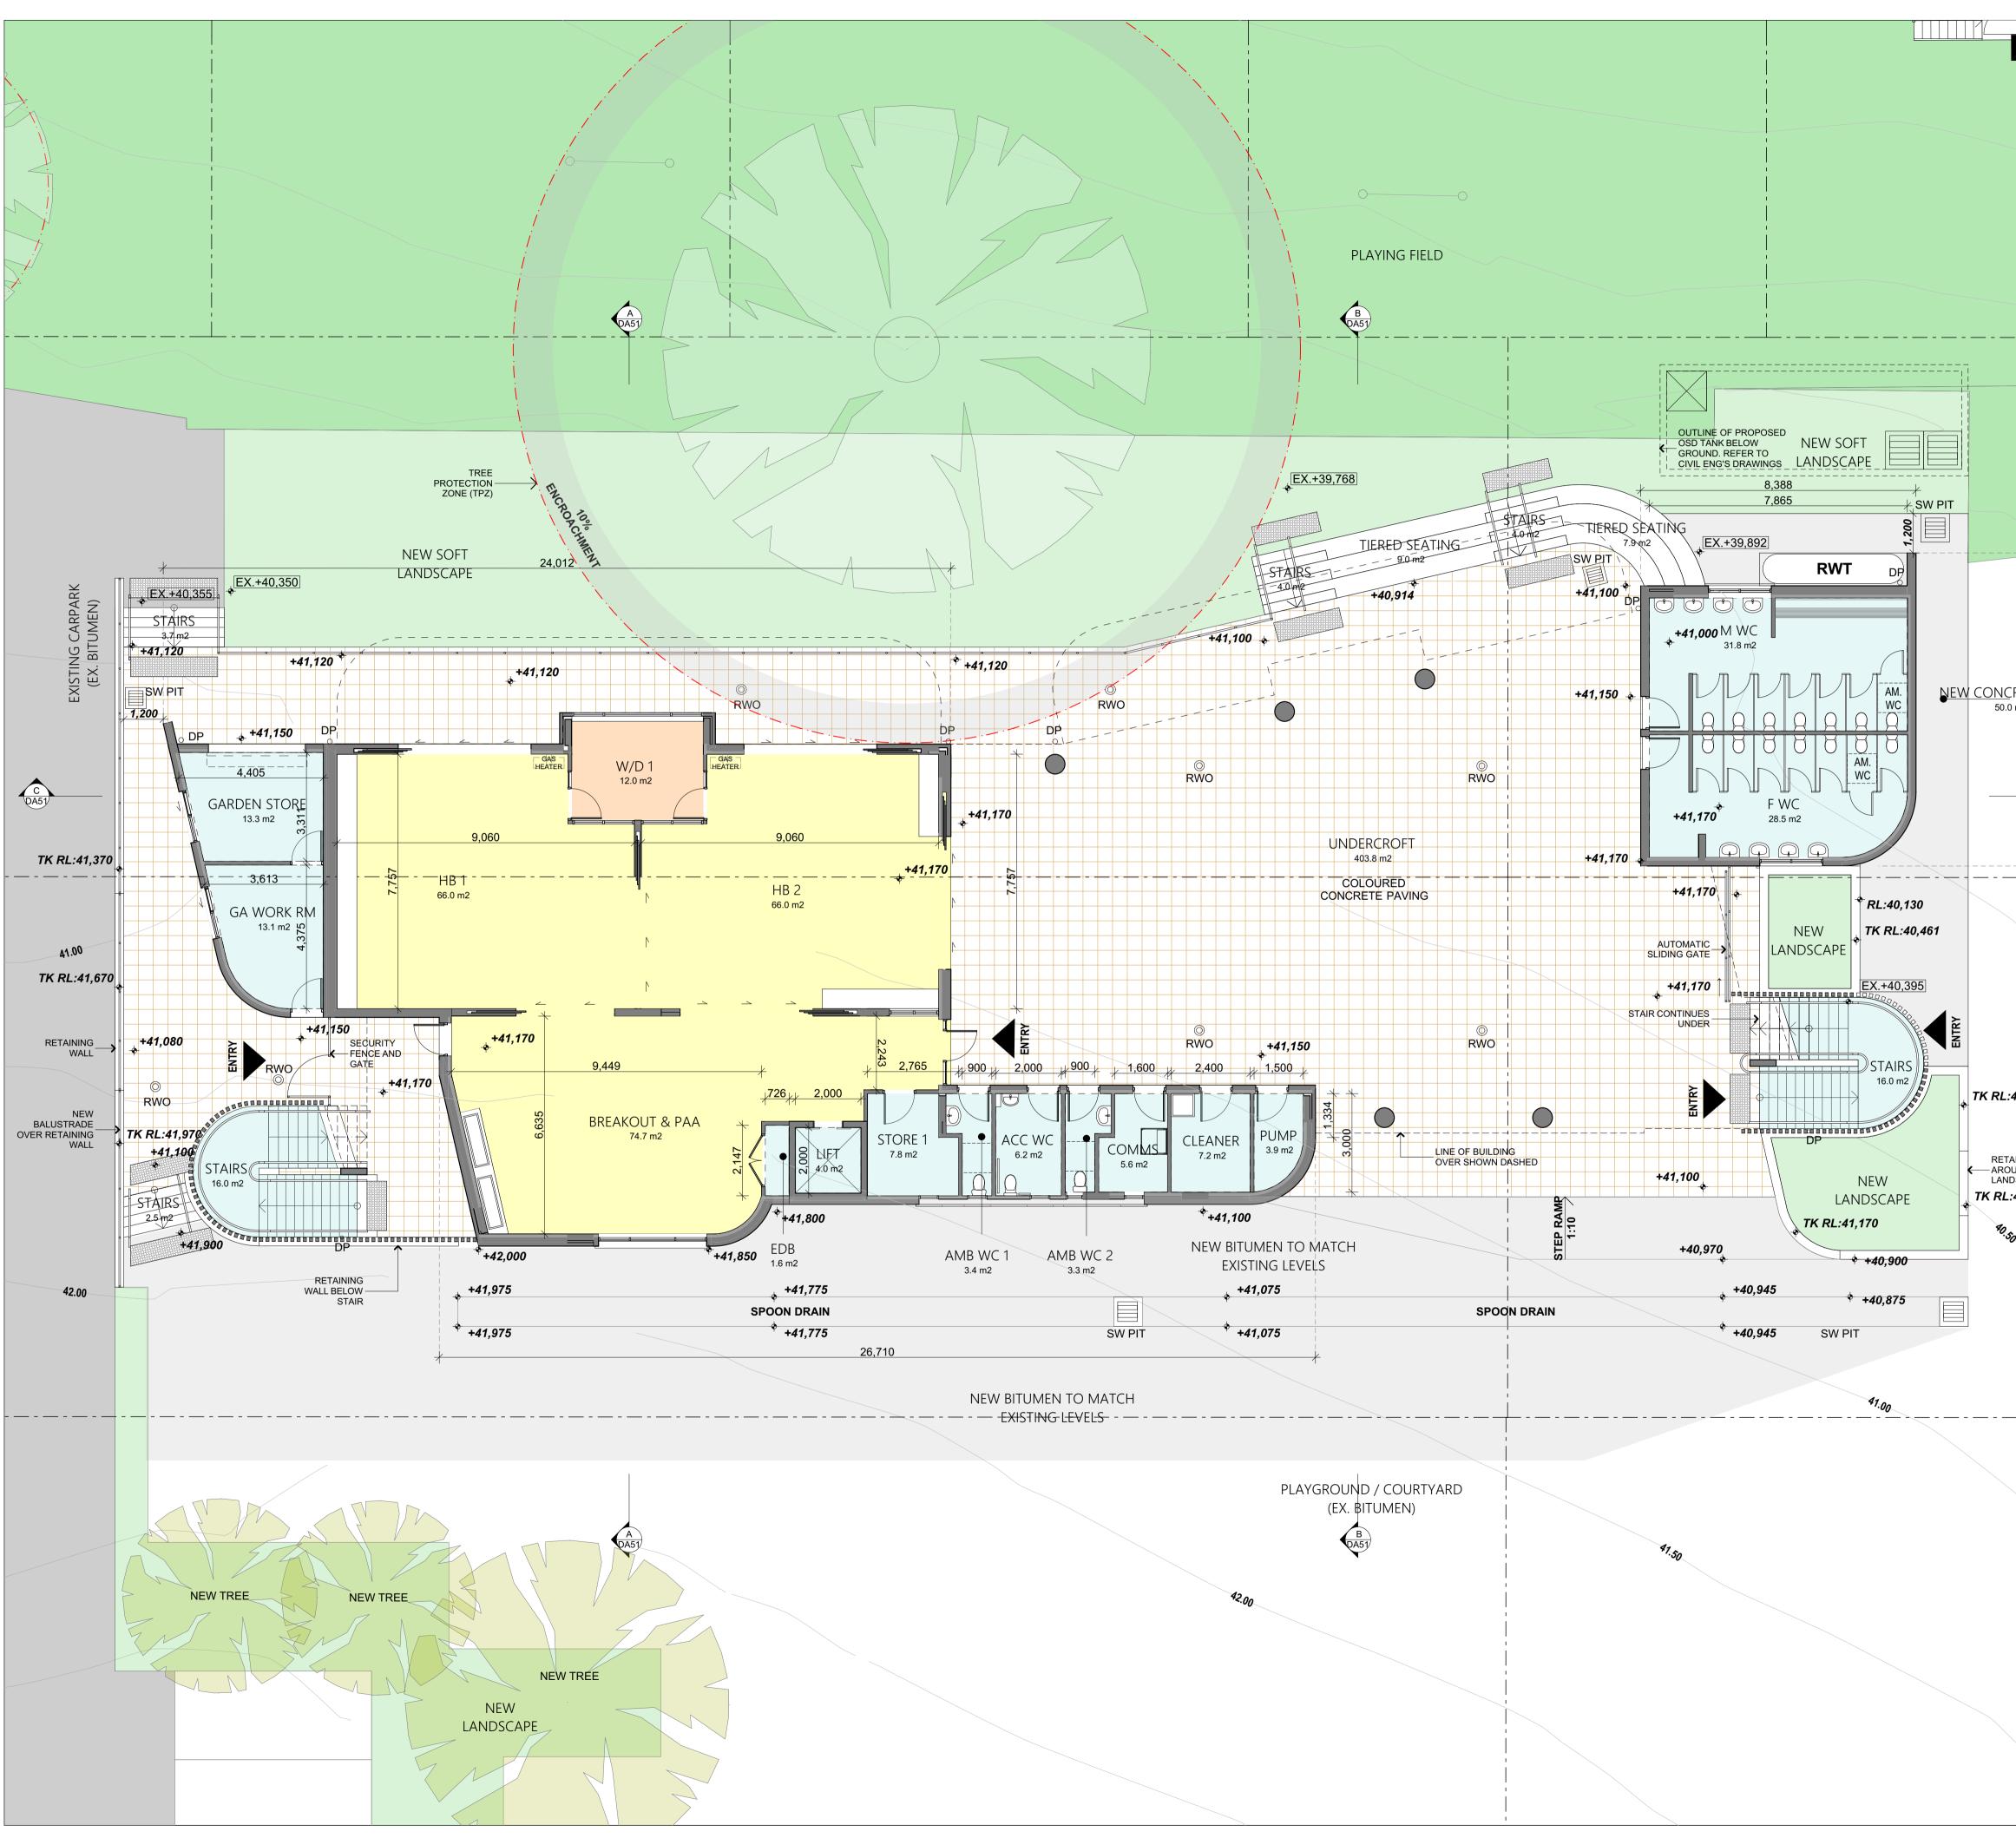


		THE CONTRACTO AND VERIFY ALL	OR SHAL	CHITECTS PTY. LTD. L CHECK AND VERIFY ALL S AND OMISSIONS TO THE	ARCHITECT.
		DRAWINGS SHAL	L NOT B	SIONS, DO NOT SCALE THE E USED FOR CONSTRUCT D BY THE ARCHITECT FOR Issue Name	ION
	E	A 08-Aug-17 B 05-Sep-17	AT AT	ISSUE FOR DA ISSUE FOR DA	AC AC
				AN LEGEN	
				EXISTING E	BUILDINGS
	E			LEAR	NING AREA
				WITHDRA	WAL ROOM
	E				SERVICES
1,000	E				BALCONY
			]	1	NEW WALL
373				- SITE	BOUNDARY
60 7				- INTERNAL LOT	
<sup>2</sup> 39.50 <sup>2</sup> 6		AFTER		TREE PROTEC	TION ZONE (TPZ)
120		W. N.		EXIS	STING TREE
					NEW TREE
C DA51 EE LE	E			BUILD	ING ENTRY
					XISTING RL
					OPOSED RL
		ACC ACCES A/C AIR CO AMB AMBU	SSIBLE ONDITIOI		
<sup>80,00</sup>		DP DOWN	IPIPE [RICAL D ING LE	ISTRIBUTION BOARD	
		M MALE PAA PRACT RWO RAIN V RWT RAIN V		ANK	
		TK TOP O WC WATE	F KERB R CLOSE RAWAL		
,870		Planning			dfp
		Landscape		S P A	
ING WALL D CAPE		Project Manage	er		
, <b>020</b>	<b>•</b>	Building Certifi	er		ACKETT
		Mechanical, El		,	GUIRE+ LDSMITH
		Hydraulic, Stru Civil Engineerii Consultant			CHOLSON G ENGINEERS
			Н	archite	ects
		JDH ARCHITECTS info@jdharchitects ABN 27 110 978 5	5 PTY. L .com.au 802		d Street NSW 2010
		ACN 110 978 NOMINATED ARC JAYNE HARRISON	HITECT		ects.com.au
		Client			ALC -
		<b>NSW</b> GOVERNMENT	Edu	ucation	PERSEVERE
		NSW Departme 5 Bridge Street	ent of E	Education	$\checkmark$
		Project Name	LAN	DS PUBLIC	
		SCHOO	L	(	
		FOWLER MERRYL/		AD, S NSW 2160	
		Drawing Title			
		Scale : 1:100	ED ( @A1	BROUND FLOC	19-Apr-18
		Drawn : AT Project No. D	rawing	No. Checker	
			DA3		
		QUALITY CERTIFIED ISO 9001	CONFIR PREPAR ARCHIT	LING THE 'DRAWN' AND THE MS THAT THIS DRAWING HA RED IN CONFORMITY WITH J ECTS Q.M.S. PROCEDURES	AS BEEN IDH
		Status: DEV	/ELC	PMENT APPLI	CATION

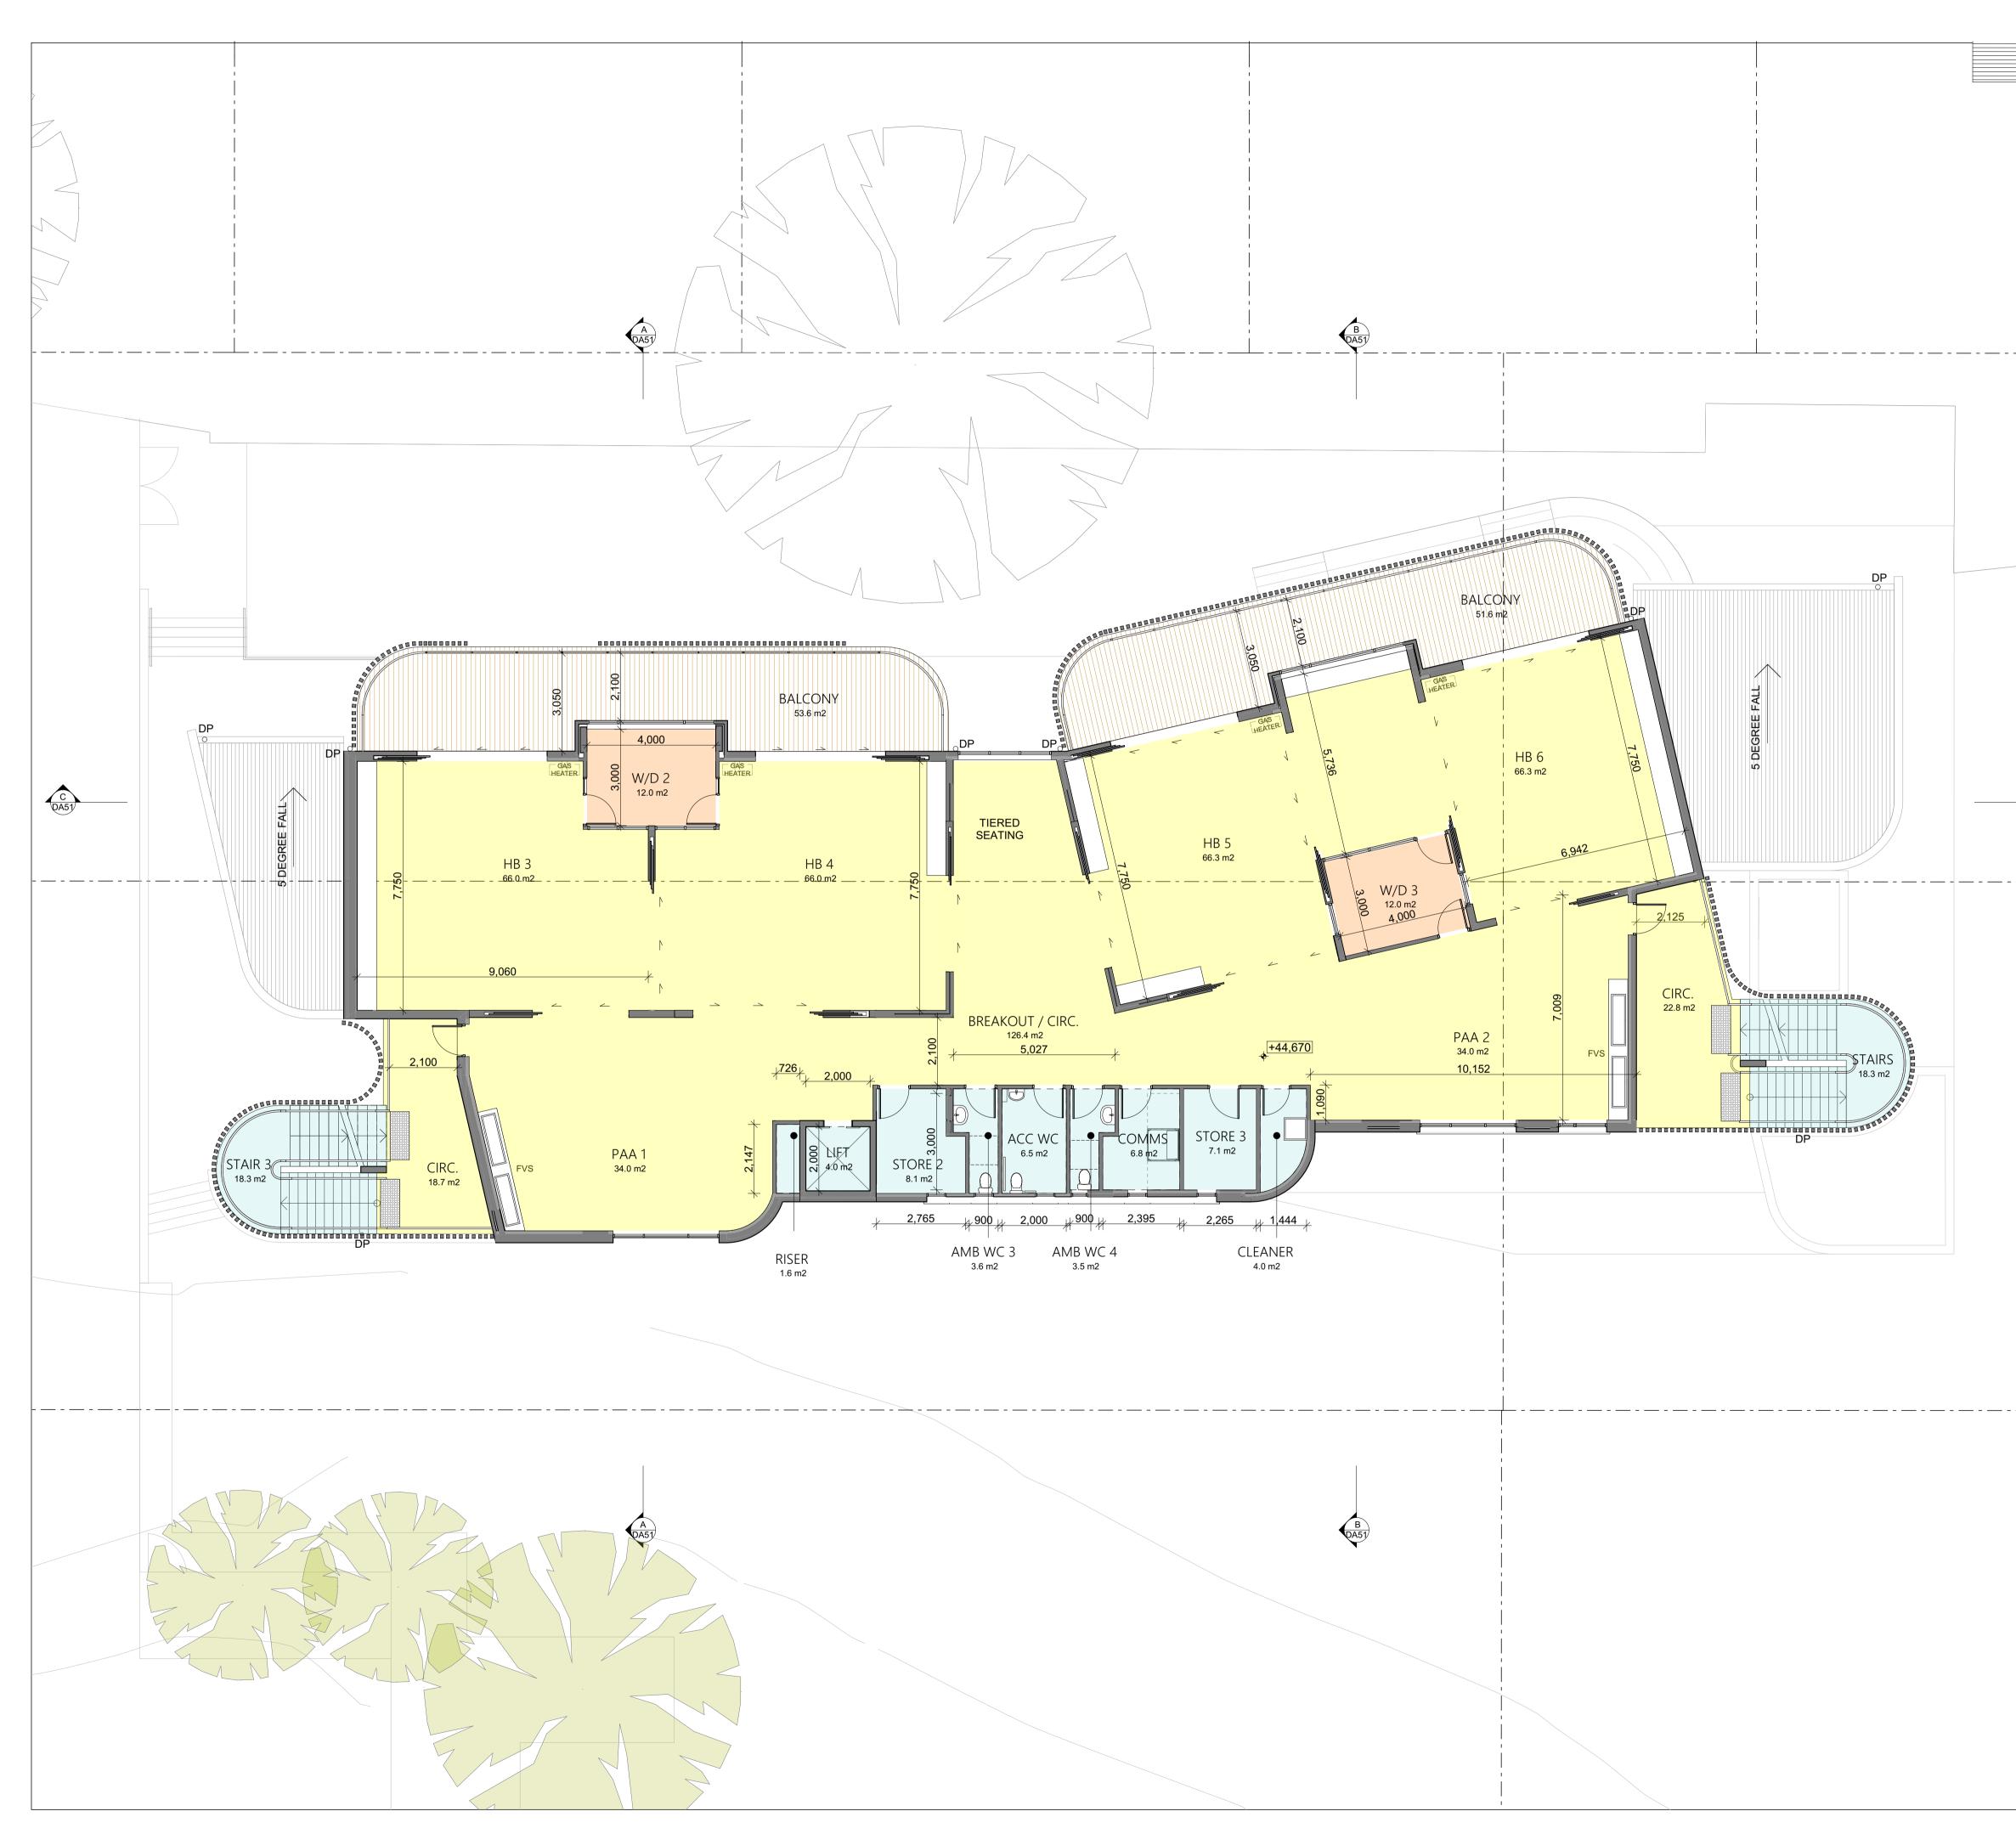


	6				
	THI AN US	E CONTRACT( D VERIFY ALL E FIGURATIVE	OR SHA ERROR DIMEN	RCHITECTS PTY. LTD. LL CHECK AND VERIFY A IS AND OMISSIONS TO TI SIONS, DO NOT SCALE T BE USED FOR CONSTRU	HE ARCHITECT. THE DRAWINGS.
	PU		IL ISSUE	D BY THE ARCHITECT F	
	A B	08-Aug-17 05-Sep-17	AT AT	ISSUE FOR DA	AC AC
	F	-LOOI	RP	LAN LEGE	ND
	 -			EXISTING	BUILDINGS
				LEA	ARNING AREA
				WITHDF	RAWAL ROOM
					SERVICES
			1		BALCONY
				- SIT	E BOUNDARY
	-			- INTERNAL LO	
					G BOUNDARY
	-	AFT BA			(TPZ)
		E NY		EX	(ISTING TREE
Ċ					NEW TREE
0451				BUII	LDING ENTRY
		- <b>∲</b> -	000		EXISTING RL
		₽L +1,0	000	Р	ROPOSED RL
	A	CC ACCE	SSIBLE	ATIONS	
	A C D	MB AMBU IRC CIRCU P DOWN	JLATION		
	E   F	X EXIST FEMA B HOME	'ING LE BASE	DISTRIBUTION BOARD	
	R	AA PRAC WO RAIN WT RAIN	TICAL AG	ΓΑΝΚ	
	T W	K TOP C /C WATE	M WATE DF KERB R CLOSI DRAWAL	ΞT	
	Pla	anning			
		ndscape			
	 	oject Manag	er	S P LANDSCA	A C E APE DESIGNS
	-	ilding Certifi		_	INSTAFF
		C			IAGUIRE <mark>+</mark> OLDSMITH
	Hy Civ Co	echanical, El draulic, Stru vil Engineeri onsultant chitect	ictural	I, JONES N CONSULTII	NICHOLSON NG ENGINEERS
		JD	Н	archit	ects
	JDH info ABI ACI NO	HARCHITECT: ) () ) ) ) ) ) ) ) ) ) ) ) ) ) ) ) ) )	S PTY. L s.com.au 802 802 CHITECT	TD. 44 Little Oxf Darlinghurst Telephone: www.jdharcl	
	 Cli	ent			
	NS	<b>SW</b> Departm Bridge Stree	ent of		PERSEVERE DESEVERE
	Pro M	oject Name	LAN	IDS PUBLIC	;
	F	CHOO OWLER ERRYL	RO	AD, S NSW 2160	
	Dra	awing Title			
	-			FIRST FLOOR	
	Dra	awn: AT	0 @A1	Check	: 19-Apr-18 ked :AC
					Rev.
				32	В
	CEF	9001	CONFII PREPA ARCHI	RMS THAT THIS DRAWING RED IN CONFORMITY WIT TECTS Q.M.S. PROCEDUR	HAS BEEN H JDH ES.
	Sta	atus: DE\	/FI C	<b>DPMENT APPL</b>	ICATION

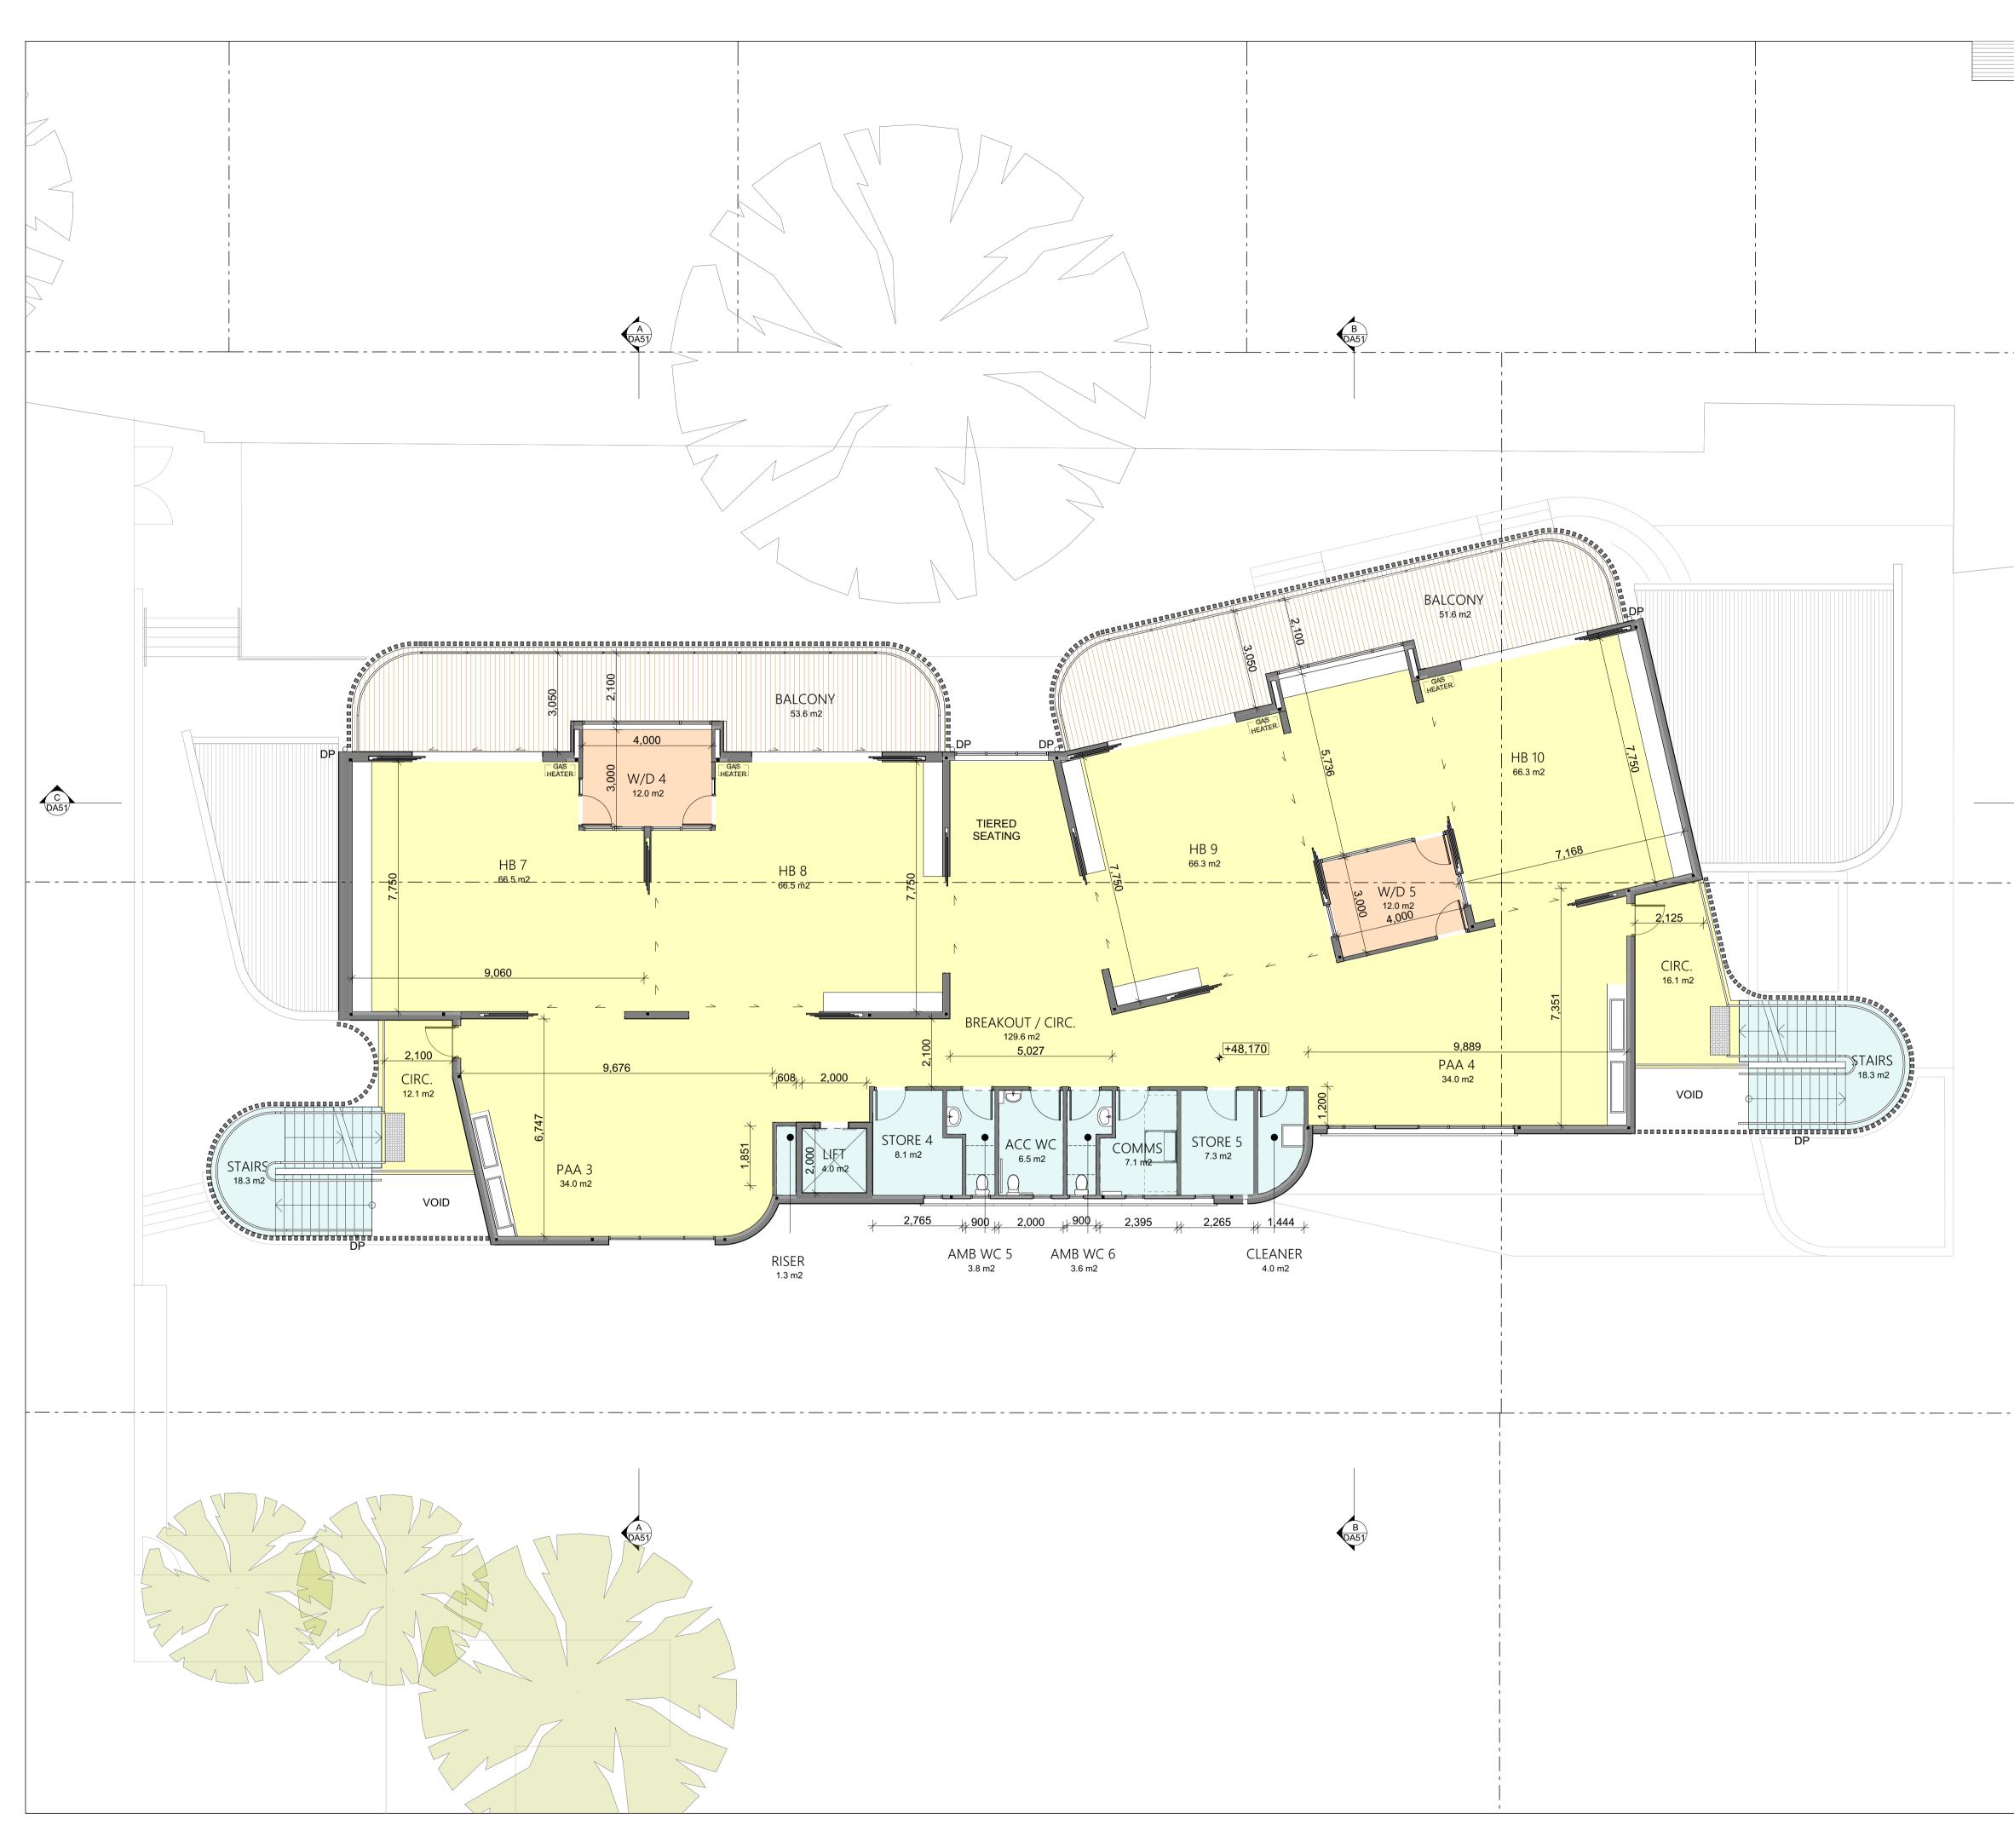

	r	1
		© COPYRIGHT JDH ARCHITECTS PTY. LTD. THE CONTRACTOR SHALL CHECK AND VERIFY ALL DIMENSIONS
		AND VERIFY ALL ERRORS AND OMISSIONS TO THE ARCHITECT. USE FIGURATIVE DIMENSIONS, DO NOT SCALE THE DRAWINGS. DRAWINGS SHALL NOT BE USED FOR CONSTRUCTION
		PURPOSES UNTIL ISSUED BY THE ARCHITECT FOR CONSTRUCTION.
		Rev         Date         By         Issue Name         C           A         08-Aug-17         AT         ISSUE FOR DA         A
		B 05-Sep-17 AT ISSUE FOR DA A
	Ì	
	1	
		FLOOR PLAN LEGEND
	· 	EXISTING BUILDINGS
		LEARNING ARE
		WITHDRAWAL ROOM
		SERVICE
		BALCON
		NEW WALL
		SITE BOUNDAR'
		NEIGHBOURING BOUNDAR
		TREE PROTECTION ZON
		EXISTING TRE
Ċ		NEW TRE
DA51		BUILDING ENTR
		EXISTING R
		RL +1,000 PROPOSED R
		AMB     AMBULANT       CIRC     CIRCULATION       DP     DOWNPIPE       EDB     ELECTRICAL DISTRIBUTION BOARD       EX     EXISTING       F     FEMALE       HB     HOMEBASE       M     MALE       PAA     PRACTICAL ACTIVITES AREA       RWO     RAIN WATER OUTLET       RWT     RIN WATER TANK       SW     STORM WATER       TK     TOP OF KERB       WC     WATER CLOSET       W/D     WITHDRAWAL
		Planning
		Landscape SPACE
		Project Manager
		Building Certifier
		Mechanical, Electrical, Hydraulic, Structural & Civil Engineering Consultant
		JDH ARCHITECTS PTY. LTD. info@jdharchitects.com.au ABN 27 110 978 802 ACN 110 978 802 NOMINATED ARCHITECT: JAYNE HARRISON (7403)
		Client
		Education SW Department of Education 5 Bridge Street, Sydney
		Project Name MERRYLANDS PUBLIC SCHOOL
		FOWLER ROAD, MERRYLANDS NSW 2160
		Drawing Title
		PROPOSED SECOND FLOOR PLAN
		Scale : 1:100 @A1 Date : 19-Apr-18
		Drawn : AT Checked :AC
		Project No. Drawing No. Rev.
		997 DA33 B
		QUALITY INITIALLING THE 'DRAWN' AND THE 'CHECK' BOXE CERTIFIED ISO 0001 PREPARED IN CONFORMITY WITH JDH
		9001 ARCHITECTS Q.M.S. PROCEDURES. Status: DEVELOPMENT APPLICATION

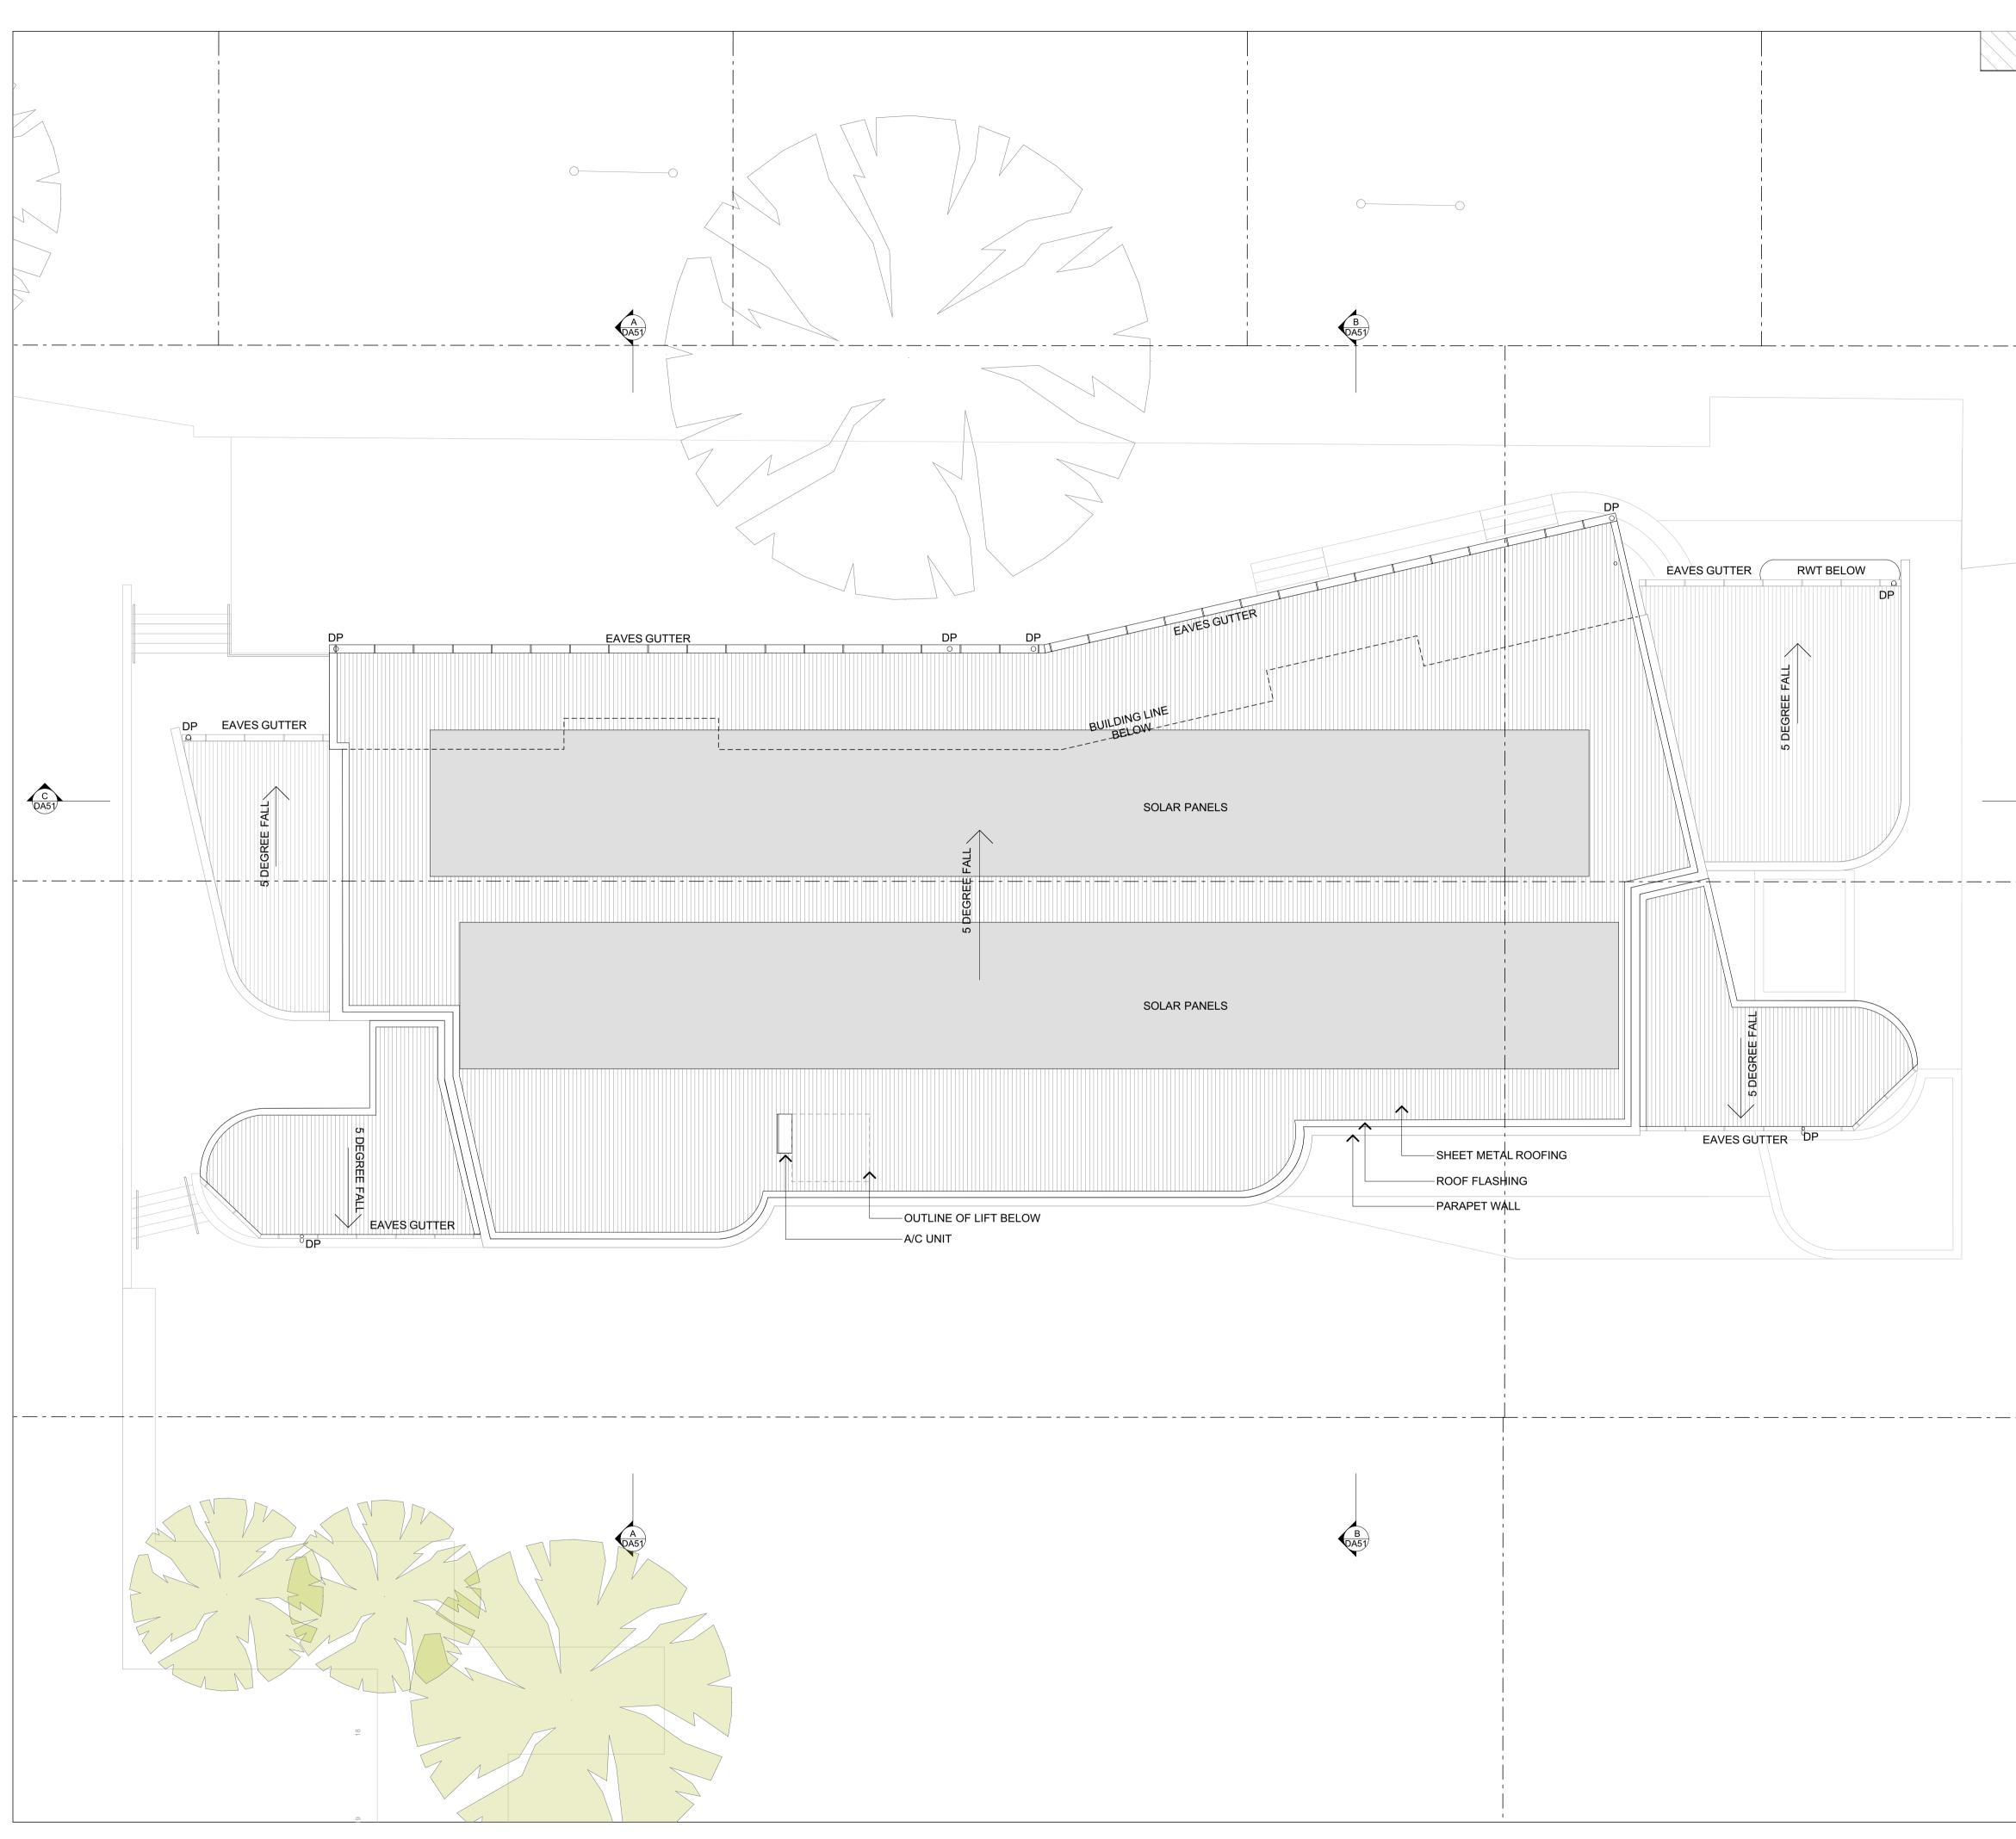



	AND VERIFY ALL ERRORS	L CHECK AND VERIFY ALL DIM S AND OMISSIONS TO THE ARC SIONS, DO NOT SCALE THE DF E USED FOR CONSTRUCTION	CHITECT. RAWINGS.
	PURPOSES UNTIL ISSUEI           CONSTRUCTION.           Rev         Date         By           A         08-Aug-17         AT	D BY THE ARCHITECT FOR Issue Name ISSUE FOR DA	CK AC
	B 05-Sep-17 AT	ISSUE FOR DA	AC
	ROOF LEC	GEND	
	 _	PROPOSED SOLAR F	PANELS
		METAL ROOF SHE	EETING
	 	- SITE BOU	NDARY
		- INTERNAL LOT BOU	
		EXISTIN	G TREE
		NEV	W TREE
	ABBREVIA ACC ACCESSIBLE A/C AIR CONDITION		
	AMB AMBULANT CIRC CIRCULATION DP DOWNPIPE	ISTRIBUTION BOARD	
	F FEMALE HB HOMEBASE M MALE PAA PRACTICALAC RWO RAIN WATER O		
	RWT RAIN WATER T/ SW STORM WATER TK TOP OF KERB WC WATER CLOSE W/D WITHDRAWAL	ANK R	
	 _		
C DA51			
	Planning		dfp
	Planning Landscape	S P A	
		LANDSCAPE D	ESIGNS
	Landscape		
	Landscape Project Manager Building Certifier Mechanical, Electrical Hydraulic, Structural 8	JOHNSTA	FF CKETT UIRE+ SMITH
	Landscape Project Manager Building Certifier Mechanical, Electrical Hydraulic, Structural & Civil Engineering Consultant Architect	JOHNSTA JOHNSTA DE BLAC GOLD N JONES NICH	FF CKETT UIRE+ SMITH
	Landscape Project Manager Building Certifier Mechanical, Electrical Hydraulic, Structural & Civil Engineering Consultant Architect JDH ARCHITECTS PTY, L	JOHNSTA JOHNSTA DONES NICH SOLD JONES NICH CONSULTING EN ALLITLE Oxford S	FF CKETT UIRE+ SMITH OLSON NGINEERS
	Landscape Project Manager Building Certifier Mechanical, Electrical Hydraulic, Structural & Civil Engineering Consultant Architect	JOHNSTA JOHNSTA DONES NICH CONSULTING EN CONSULTING EN AL Little Oxford S Darlinghurst, NSV Telephone: 02 92	FF CLSON GINEERS CLSON GINEERS CLSON GINEERS
	Landscape Project Manager Building Certifier Mechanical, Electrical Hydraulic, Structural & Civil Engineering Consultant Architect JDH ARCHITECTS PTY. LT info@jdharchitects.com.au ABN 27 110 978 802 ACN 110 978 802 NOMINATED ARCHITECT:	JOHNSTA JOHNSTA DONES NICH CONSULTING EN CONSULTING EN A4 Little Oxford S Darlinghurst, NSV Telephone: 02 92	FF CLSON GINEERS CLSON GINEERS CLSON GINEERS
	Landscape Project Manager Building Certifier Mechanical, Electrical Hydraulic, Structural & Civil Engineering Consultant Architect JDH ARCHITECTS PTY. LT info@jdharchitects.com.au ABN 27 110 978 802 NOMINATED ARCHITECT: JAYNE HARRISON (7403) Client Client	JOHNSTA JOHNSTA DONES NICH CONSULTING EN CONSULTING EN A4 Little Oxford S Darlinghurst, NSV Telephone: 02 92	FF CLSON GINEERS CLSON GINEERS CLSON GINEERS
	Landscape Project Manager Building Certifier Mechanical, Electrical Hydraulic, Structural & Civil Engineering Consultant Architect JDH ARCHITECTS PTY. LT info@jdharchitects.com.au ABN 27 110 978 802 ACN 110 978 802 NOMINATED ARCHITECT: JAYNE HARRISON (7403) Client Client NSW Department of E 5 Bridge Street, Sydne	JOHNSTA JOHNSTA DONES NICH NONES NICH CONSULTING EN ALLITLE OXFOR S Darlinghurst, NSV Telephone: 02 92 www.jdharchitects	FF CLSON GINEERS CLSON GINEERS CLSON GINEERS
	Landscape Project Manager Building Certifier Mechanical, Electrical Hydraulic, Structural & Civil Engineering Consultant Architect JDH ARCHITECTS PTY. LT info@idharchitects.com.au ABN 27 110 978 802 NOMINATED ARCHITECT: JAYNE HARRISON (7403) Client Client NSW Department of E 5 Bridge Street, Sydne Project Name MERRYLAN	IANDSCAPE D JOHNSTA DONES NICH CONSULTING EN ALLITTE OXFORD S Darlinghurst, NSV Telephone: 02 92 www.jdharchitects ICL ILL ILL ILL ILL ILL ILL ILL	FF CLSON GINEERS CLSON GINEERS CLSON GINEERS
	Landscape Project Manager Building Certifier Mechanical, Electrical Hydraulic, Structural & Civil Engineering Consultant Architect JDH ARCHITECTS PTY. LT info@jdharchitects.com.au ABN 27 110 978 802 ACN 110 978 802 NOMINATED ARCHITECT: JAYNE HARRISON (7403) Client Client NSW Department of E 5 Bridge Street, Sydne Project Name MERRYLAN SCHOOL	JOHNSTA JOHNSTA MAGE CONSULTING CONSUL	FF CLSON GINEERS CLSON GINEERS CLSON GINEERS
	Landscape Project Manager Building Certifier Mechanical, Electrical Hydraulic, Structural & Civil Engineering Consultant Architect JDH ARCHITECTS PTY. LT info@idharchitects.com.au ABN 27 110 978 802 ACN 110 978 802 NOMINATED ARCHITECT: JAYNE HARRISON (7403) Client Client NSW Department of E 5 Bridge Street, Sydne Project Name MERRYLAN SCHOOL FOWLER ROA MERRYLANDS	JOHNSTA JOHNSTA DIS PUBLIC LANDSCAPE D JOHNSTA MAGE MA	FF CLSON GINEERS CLSON GINEERS CLSON GINEERS
	Landscape Project Manager Building Certifier Mechanical, Electrical Hydraulic, Structural & Civil Engineering Consultant Architect JDH ARCHITECTS PTY. LT info@jdharchitects.com.au ABN 27 110 978 802 ACN 110 978 802 NOMINATED ARCHITECT: JAYNE HARRISON (7403) Client Client NSW Department of E 5 Bridge Street, Sydne Project Name MERRYLAN SCHOOL FOWLER ROA	JOHNSTA JOHNSTA MAGINE CONSULTING CONS	FF CLSON GINEERS CLSON GINEERS CLSON GINEERS
	Landscape Project Manager Building Certifier Mechanical, Electrical Hydraulic, Structural & Civil Engineering Consultant Architect JDH ARCHITECTS PTY. LT info@idharchitects.com.au ABN 27 110 978 802 NOMINATED ARCHITECT: JAYNE HARRISON (7403) Client Client NSW Department of E 5 Bridge Street, Sydne Project Name MERRYLAN SCHOOL FOWLER ROA MERRYLANDS Drawing Title PROPOSED F Scale : 1:100 @A1 Drawn : AT	JOHNSTA JOHNSTA DE BLAC MAGI GOLD MICONESNICH MAGI GOLD MICONESNICH MAGI GOLD MAGI MAGI GOLD MAGI M	FF CLSON CLSON CLSON CLSON CLSON CLSON CLSON SCON B18697 S.COM.AU
	Landscape Project Manager Building Certifier Mechanical, Electrical Hydraulic, Structural & Civil Engineering Consultant Architect JDH ARCHITECTS PTY, LI IDH AR	JOHNSTA JOHNSTA DE BLAC MAGI GOLD MICONES NICH CONSULTING EN ALLITTE OXFORDS DARINGHUSS, NSW Telephone: 02 92 www.jdharchitects DARING SOUCH CONSULTING CONSULTI	FF CLSON CLSON CLSON CLSON CLSON CLSON CLSON SCON B18697 S.COM.AU

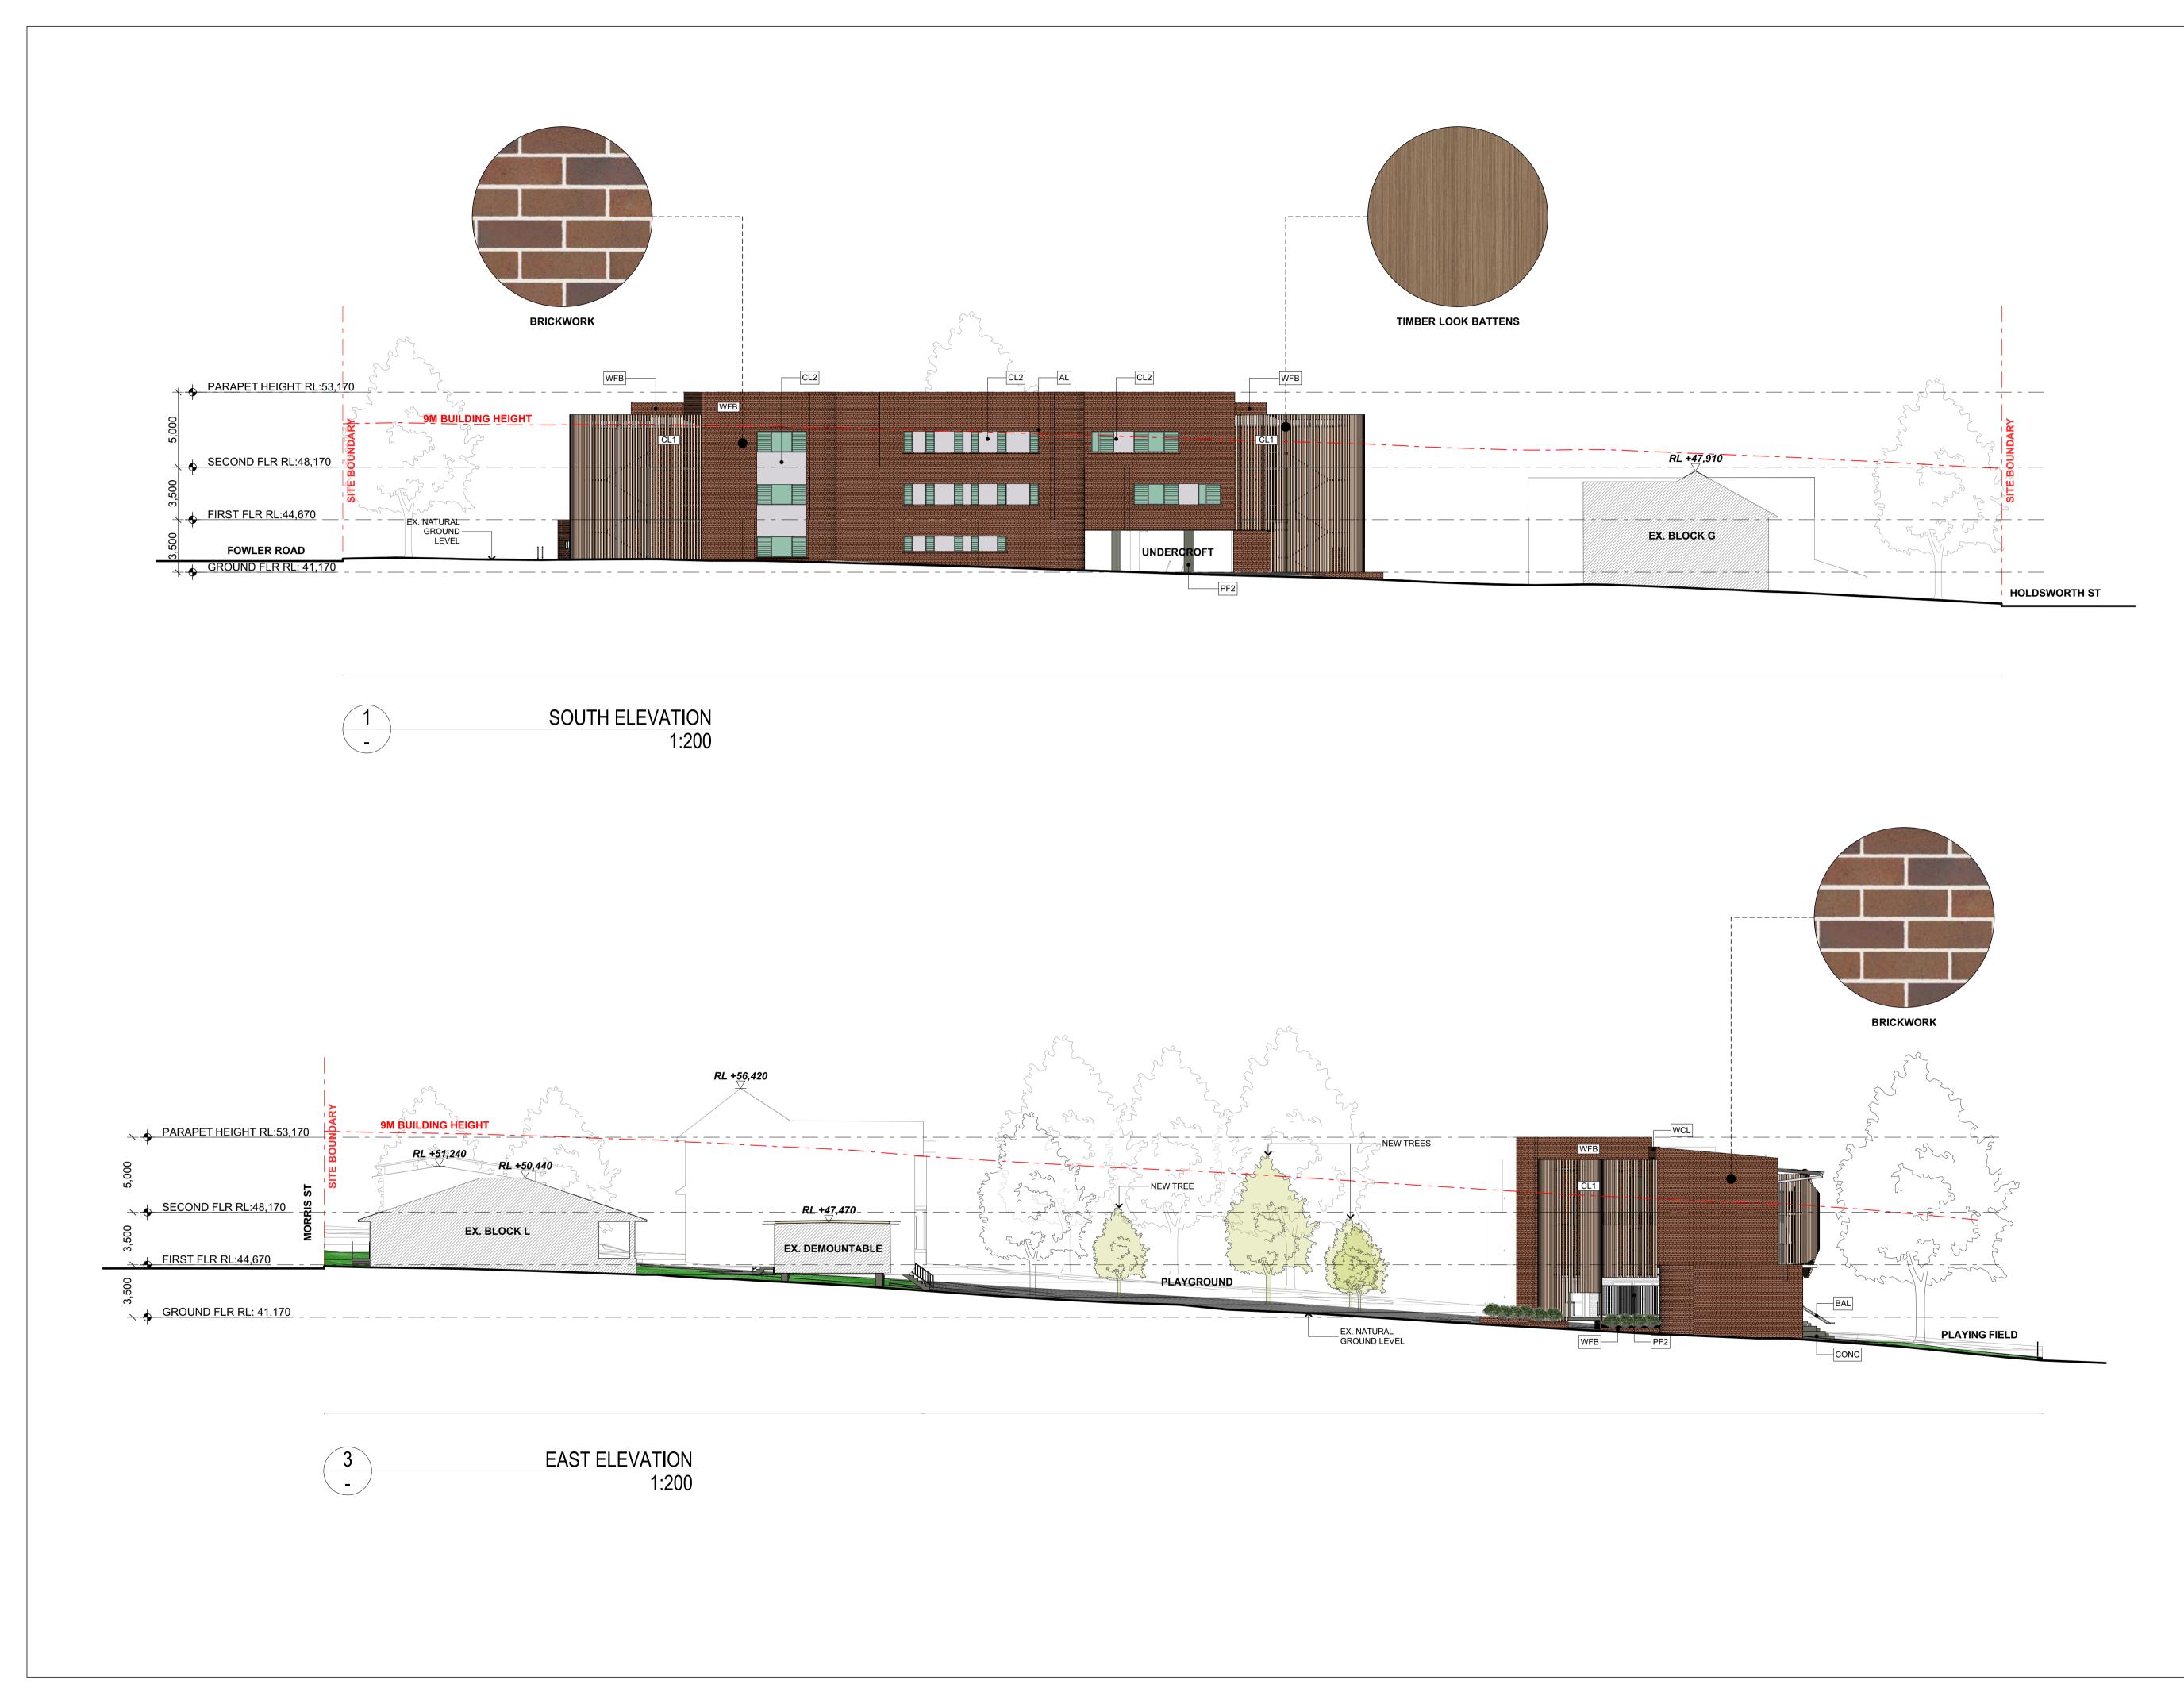

THE AND USE DRA PUR	CONTRACTO VERIFY ALL FIGURATIVE WINGS SHAL	R SHAL ERRORS DIMENS L NOT B	CHITECTS PTY. LTD. L CHECK AND VERIFY ALL DIMENS 3 AND OMISSIONS TO THE ARCHIT 30NS, DO NOT SCALE THE DRAWI E USED FOR CONSTRUCTION D BY THE ARCHITECT FOR	ECT.
Rev	Date	Ву	Issue Name	CK
А	08-Aug-17	AT	ISSUE FOR DA	AC
В	05-Sep-17	AT	ISSUE FOR DA	AC



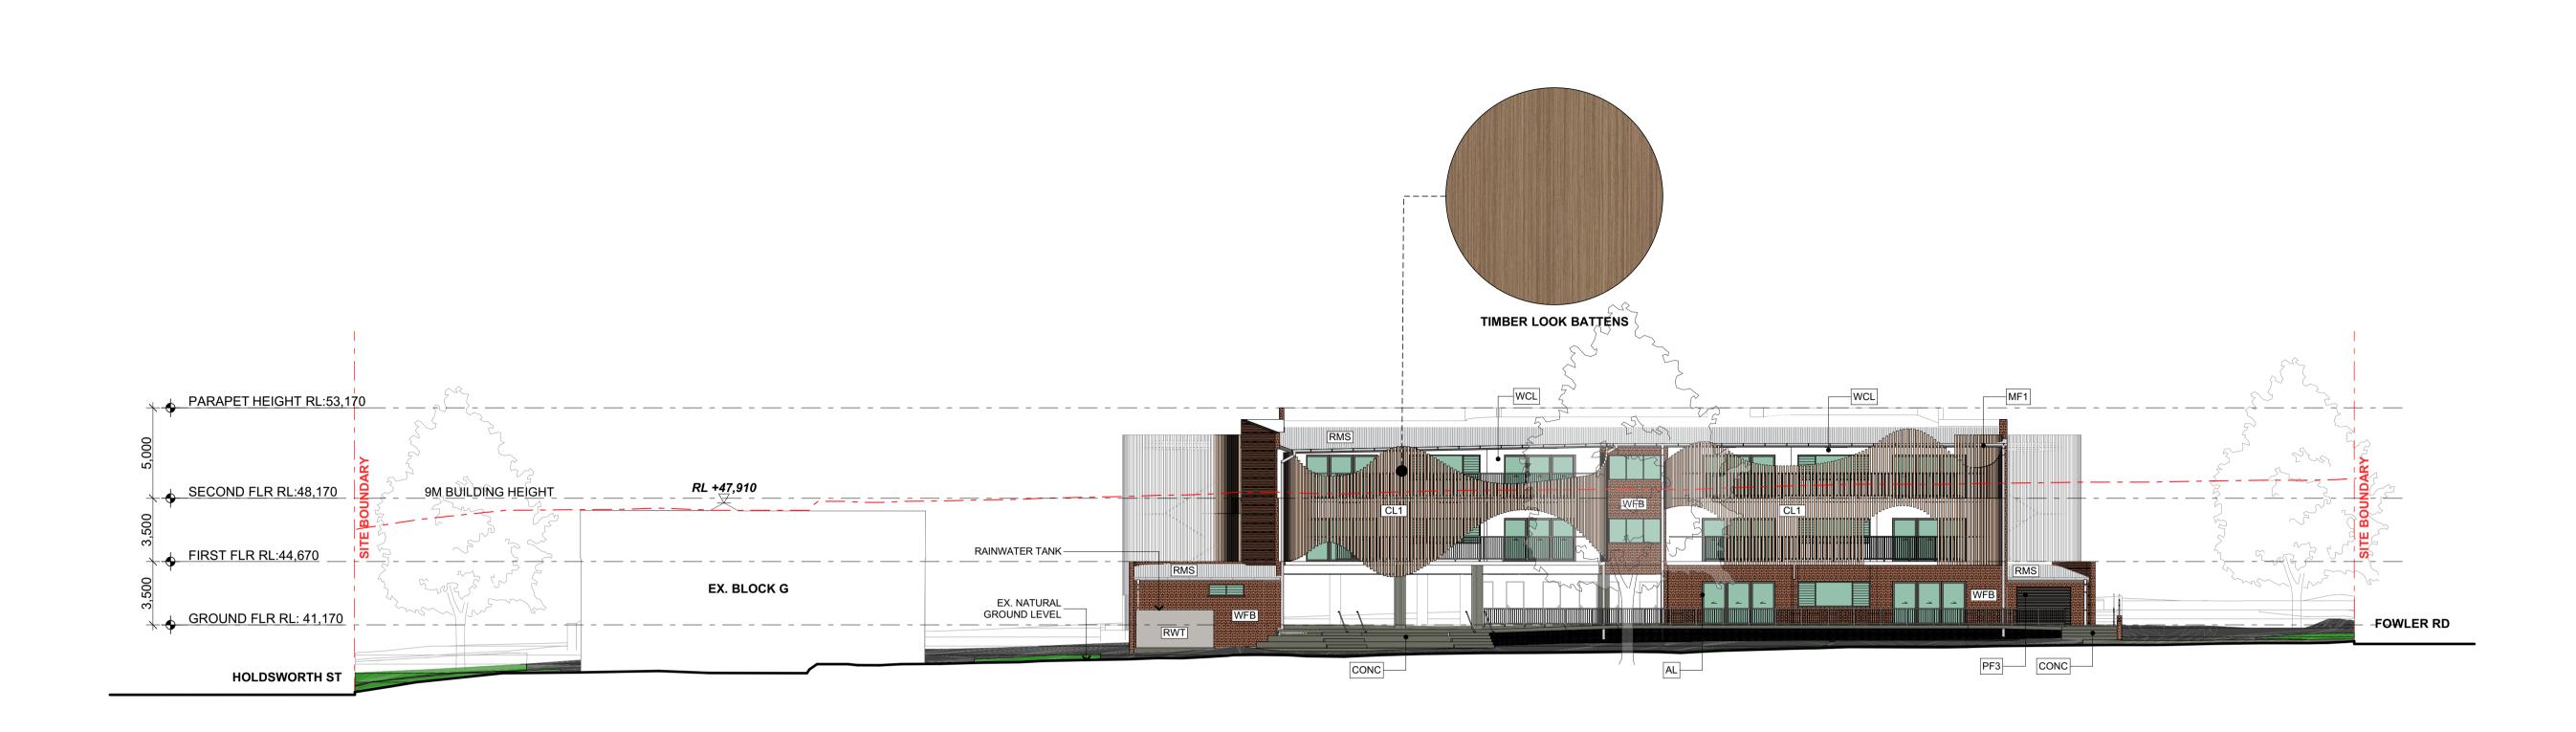

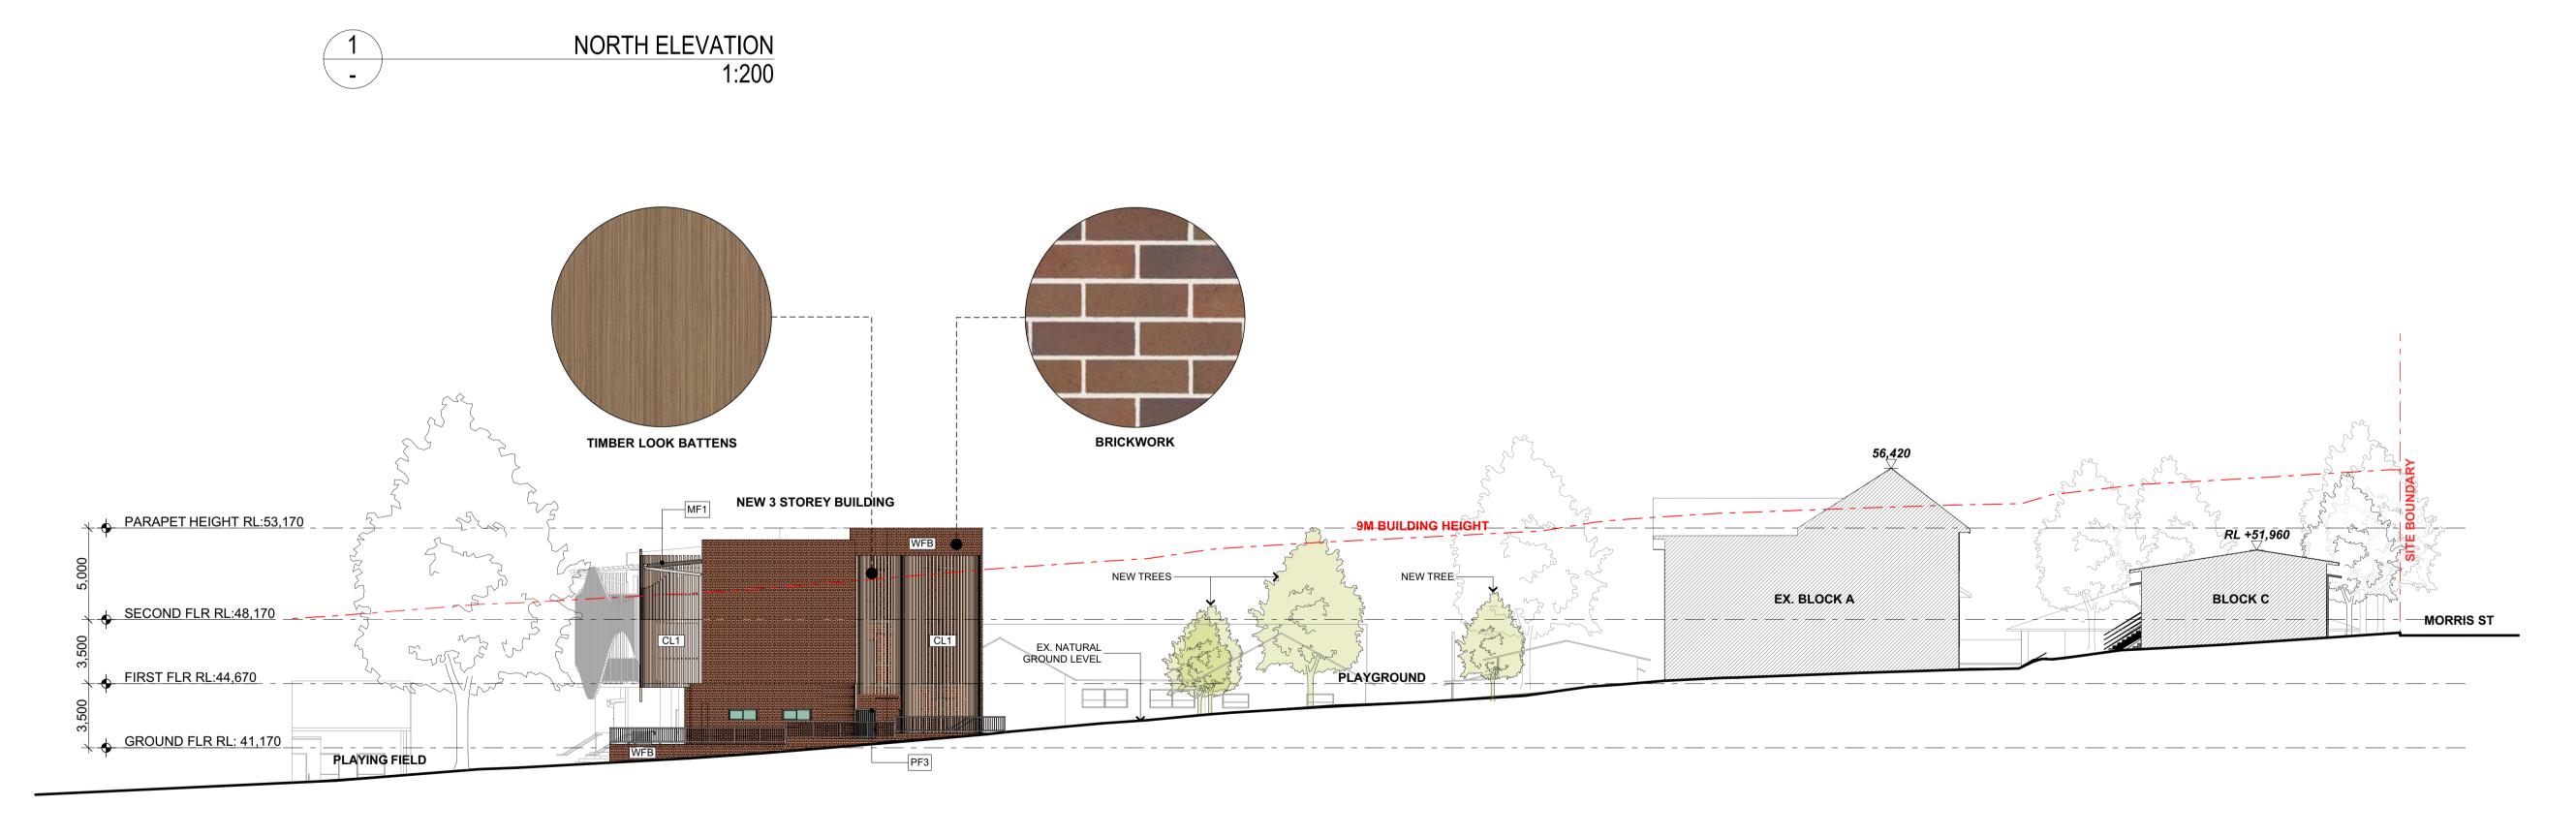


WEST ELEVATION 1:200


2

ANE USE DRA PUF	E CONTRACTO VERIFY ALL FIGURATIVE	DR SHAI ERROR DIMEN L NOT E L ISSUE	ACHITECTS PTY. LTD. L CHECK AND VERIFY ALL D S AND OMISSIONS TO THE A SIONS, DO NOT SCALE THE I SE USED FOR CONSTRUCTION D BY THE ARCHITECT FOR	RCHITECT. DRAWINGS.
Rev	Date	By	Issue Name	CK
А	08-Aug-17	AT	ISSUE FOR DA	AC
В	05-Sep-17	AT	ISSUE FOR DA	AC

Planning			dfp		
Landscape	•		A C E		
Project Ma	inager	JOH	INSTAFF		
Building C	ertifier		BLACKETT MAGUIRE+ GOLDSMITH		
			NICHOLSON TING ENGINEERS		
Architect					
JE	DHa	rchi	tects		
info@jdharch ABN 27 110 ACN 110 NOMINATED	ECTS PTY. LTD. itects.com.au 978 802 978 802 9ARCHITECT: RISON (7403)	Darlinghur Telephone	xford Street st, NSW 2010 : 02 9281 8697 chitects.com.au		
Client					
	Educa artment of Educat treet, Sydney		PERCEVERE PERCEVERE		
Project Na	me				
MERRYLANDS PUBLIC SCHOOL					
	ER ROAD, YLANDS N	SW 2160			
Drawing T PROP( 2	itle DSED ELE	/ATIONS	- SHEET		
	1:200 @A1 AT	Date	e : 19-Apr-18 cked :AC		
Project No.	Drawing No.		Rev.		
997	DA42		В		
QUALITY CERTIFIED 9001	ISO CONFIRMS TH	AT THIS DRAWIN CONFORMITY W	ITH JDH		
	EVELOPM	ENT APF			

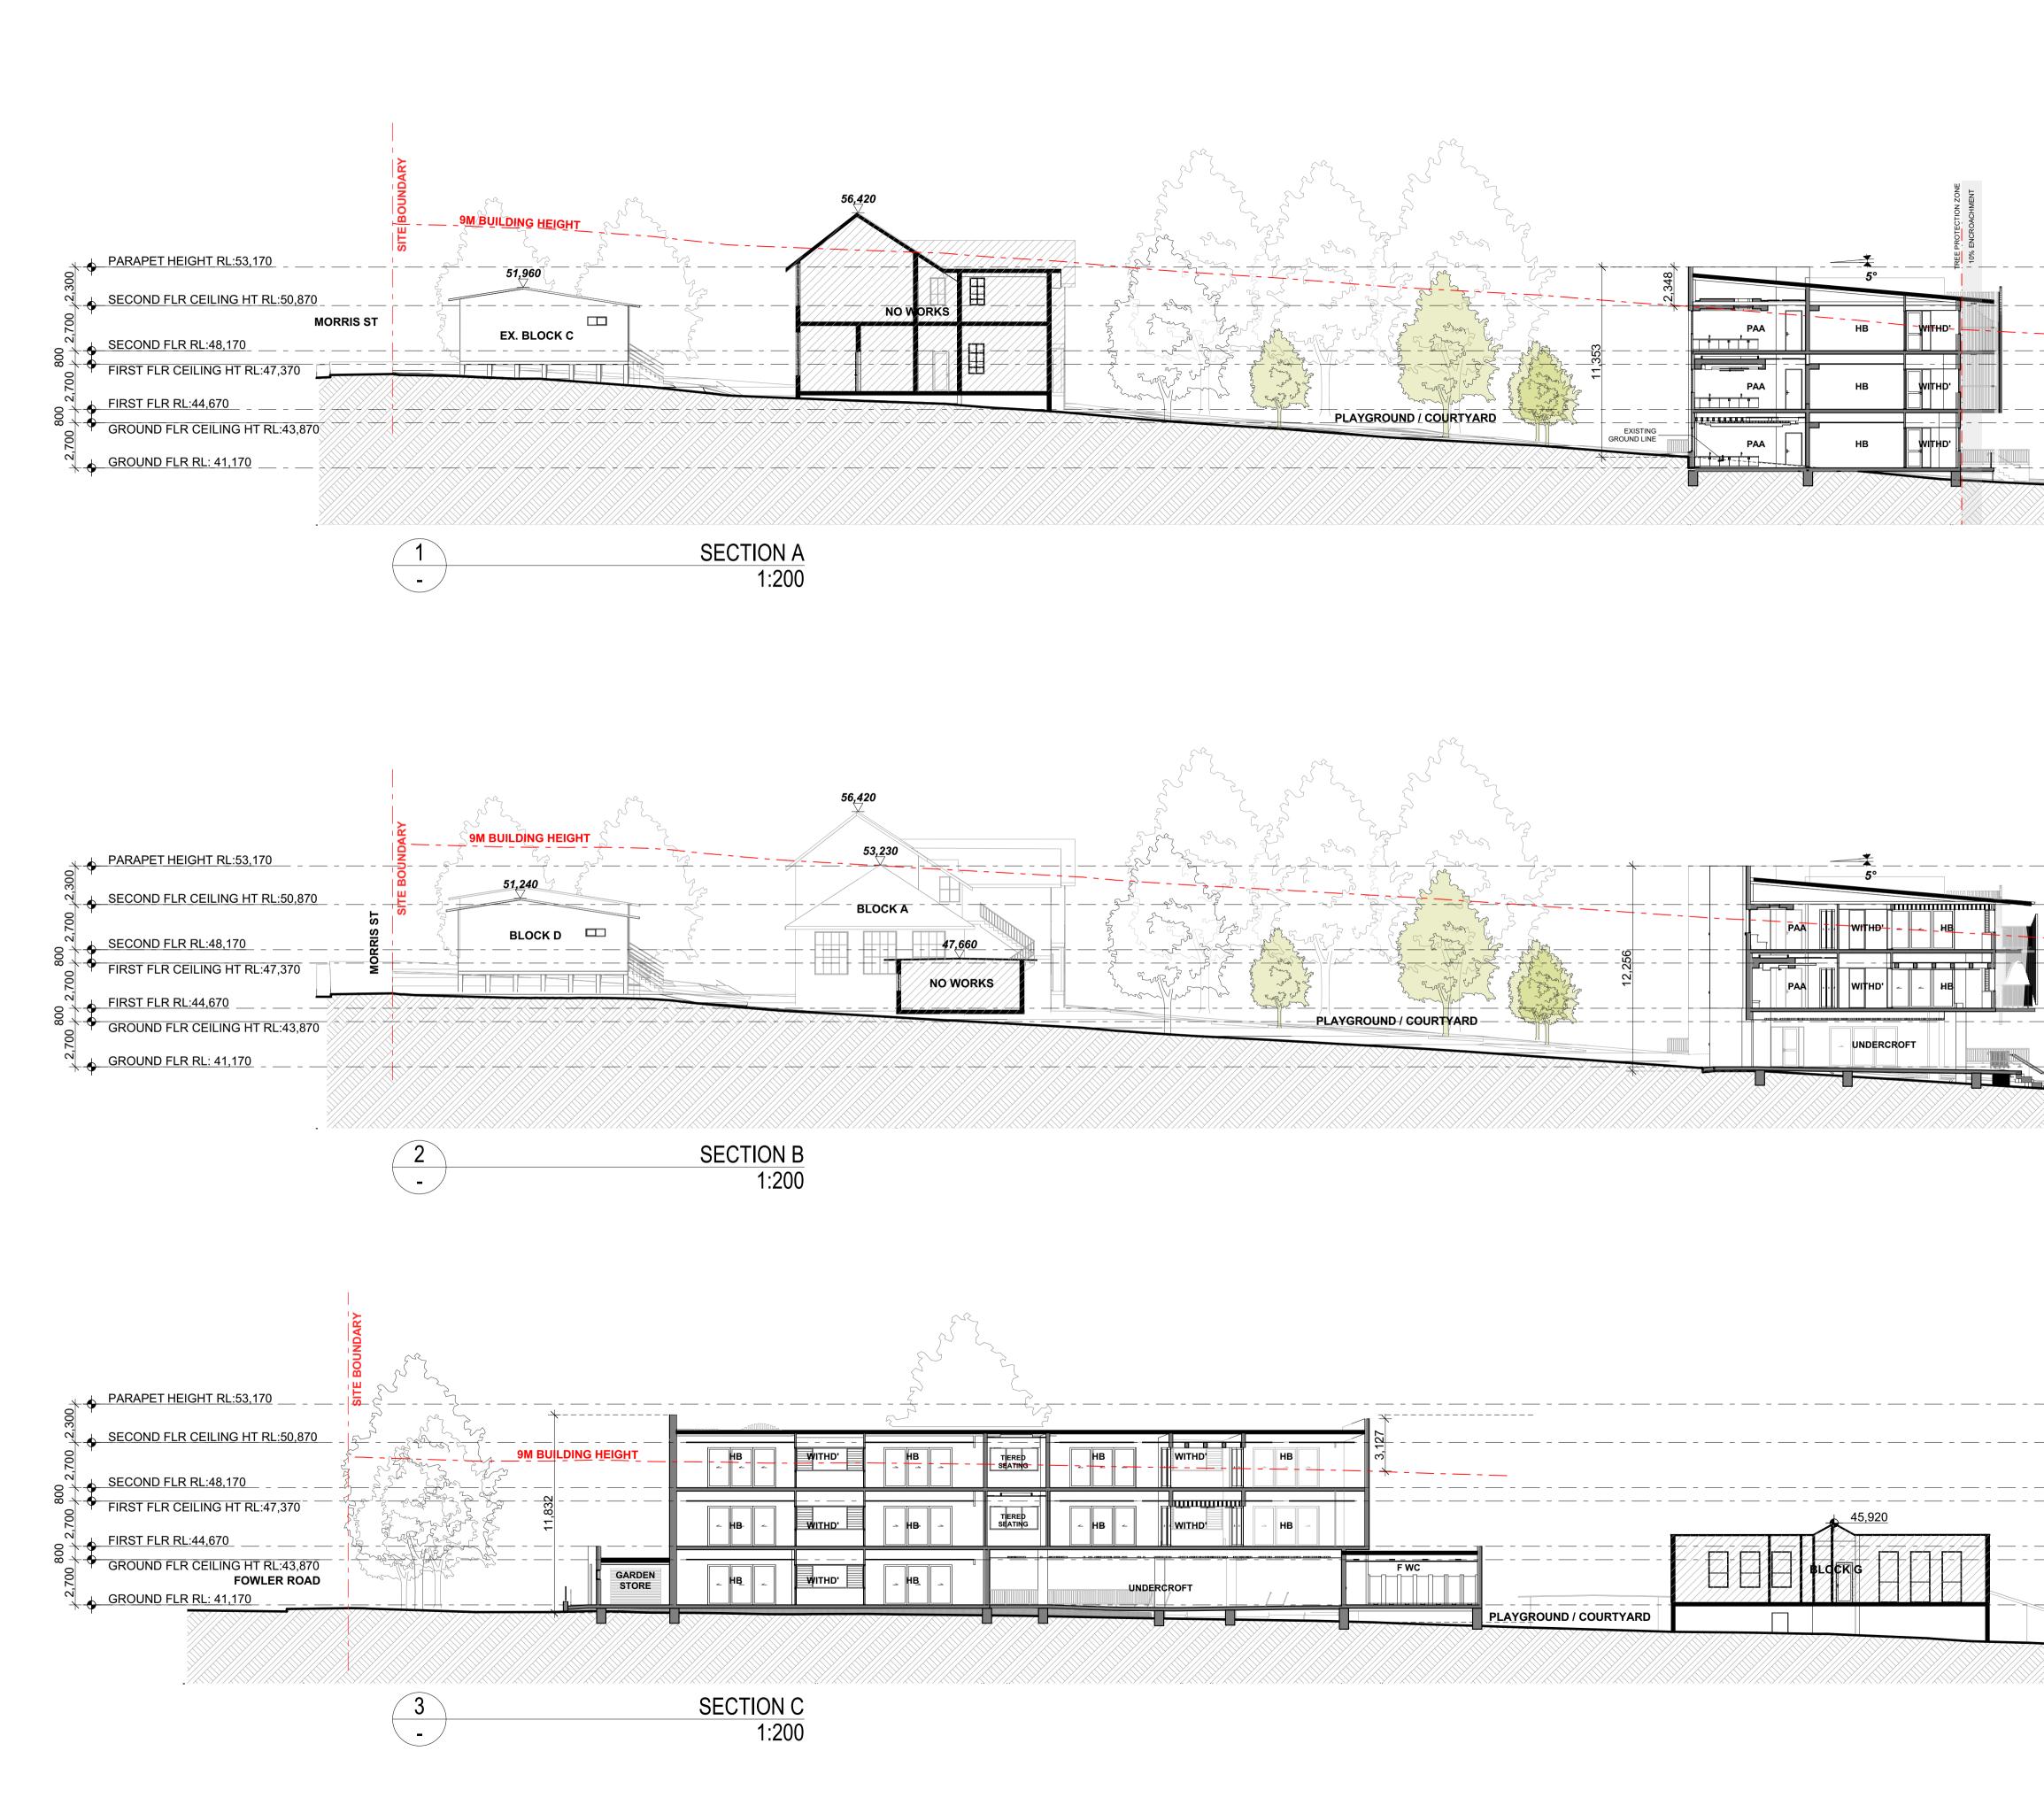


	THE ANI USE DR/ PUF	D VERIFY ALI E FIGURATIV AWINGS SHA RPOSES UNT	OR SHALI _ ERRORS E DIMENS .LL NOT BI TIL ISSUED	L CHECK AND VE AND OMISSION IONS, DO NOT S USED FOR COI D BY THE ARCHIT	ERIFY ALL DIM S TO THE ARC CALE THE DF NSTRUCTION	CHITECT. RAWINGS
	COI Rev A	Date 08-Aug-17	N. By AT	Issue Name ISSUE FOR DA		C
	В	05-Sep-17	AT	ISSUE FOR DA		A
5-52						
25203 [						
STAR & CAL						
5 5						
The second secon						
	Pla	Inning				
PLAYING FIELD	Pla	unning				dfp
PLAYING FIELD		nning		S	ΡΑ	dfp c ¤
PLAYING FIELD					P A N D S C A P E D	
PLAYING FIELD	La		ger			
PLAYING FIELD	Lar	ndscape Dject Manag		LA		ESIGNS
PLAYING FIELD	Lar	ndscape		LA		
PLAYING FIELD	Lar Pro Bu	ndscape bject Manag	fier			
PLAYING FIELD	Lar Pro Bu Me Hy	oject Manag ilding Certif	fier Electrical, uctural &		JOHNSTA BLAC GOLD	
Image: A marked of the second of the seco	Lar Pro Bui Me Hyy Civ Co	ndscape oject Manag ilding Certif ichanical, E draulic, Str ril Engineer nsultant	fier Electrical, uctural &			
	Lar Pro Bui Me Hyy Civ Co Arc	oject Manag oject Manag ilding Certif chanical, E draulic, Stri ril Engineer nsultant	ier ilectrical, uctural & ing		JOHNSTA BLAC GOLD NES NICH VSULTING EN	AFF UIRE DSMITH OLSON
	Lar Pro Bui Me Hyy Civ Co Arc	bject Manag bject Manag ilding Certif ichanical, E draulic, Stru- ril Engineer nsultant chitect	ier Electrical, uctural & ing			
	Lar Pro Bui Me Hy Civ Co Arc	bject Manag bject Manag ilding Certif ichanical, E draulic, Stru il Engineer nsultant chitect JDD	ier ilectrical, uctural & ing S PTY. LT S.com.au 802		JOHNSTA BLAC GOLD NES NICH VSULTING EN	
	Lar Pro Bu Bu Me Hyı Civ Co Arc Arc	bject Manag bject Manag ilding Certif chanical, E draulic, Stru- ril Engineer nsultant chitect	ier ilectrical, uctural & ing TS PTY. LT s.com.au 802 802 802		JOHNSTA BLAC BLAC MAG GOLD NES NICH VSULTING EN	
AT THE PLAYING FIELD	Lar Pro Bui Me Hyr Civ Co Arc Arc Arc NO JD+ info ABN ACT	adscape oject Manag ilding Certif ichanical, E draulic, Stri vil Engineer nsultant chitect JDD tARCHITECT @jdharchitect v 27 110 978 N 110 978 N 110 978	ier ilectrical, uctural & ing TS PTY. LT s.com.au 802 802 802		JOHNSTA BLAC GOLD NES NICH SULTING EN NES NICH SULTING EN LIE Oxford S ghurst, NSV hone: 02 92	
	Lar Pro Bui Me Hyr Civ Co Arc Arc Arc NO JD+ info ABN ACT	adscape bject Manag ilding Certif ichanical, E draulic, Stri ril Engineer nsultant bitect JDD i ARCHITECT @jdharchitect N 27 110 978 N 110 978	ier ilectrical, uctural & ing TS PTY. LT s.com.au 802 802 802		JOHNSTA BLAC GOLD NES NICH SULTING EN NES NICH SULTING EN LIE Oxford S ghurst, NSV hone: 02 92	
	Lar Pro Bui Me Hyr Civ Co Arc Arc Arc NO JDH	adscape bject Manag ilding Certif ichanical, E draulic, Stri ril Engineer nsultant bitect JDD i ARCHITECT @jdharchitect N 27 110 978 N 110 978	ier Electrical, uctural & ing Source 802 802 802 802 802 802 802 802 802 802	D. 44 Litt Telepi www.j	JOHNSTA BLAC GOLD NES NICH SULTING EN DITEC tle Oxford S ghurst, NSV hone: 02 92 ddharchitects	AFF CKETT UIRE SMITH OLSON NGINEER CTS Street W 2010 W 2010
	Lar Pro Bui Me Hyy Civ Co Arc Arc Afr Afr Afr Afr Afr Cliv NOI JAY	adscape bject Manage ilding Certif inchanical, E draulic, Stru- il Engineer nsultant chitect JDD ARCHITECT MINATEDAR MINATEDAR MINATEDAR MINATEDAR MINATEDAR MINATEDAR MINATEDAR MINATEDAR MINATEDAR MINATEDAR MINATEDAR	ier iectrical, uctural & ing ISSPTY.LT S.com.au 802 CHITECT: NO (7403) ECL	D. 44 Litt Darlin Telepi www.j	JOHNSTA BLAC GOLD NES NICH SULTING EN DITEC tle Oxford S ghurst, NSV hone: 02 92 ddharchitects	AFF CKETT UIRE SMITH OGINEER CLSON NGINEER
	Lar Pro Bui Me Hyu Civ Co Arc Arc Arc Arc NOI JDH info ABI NOI JAY	adscape bject Manage ilding Certif inchanical, E draulic, Stru- il Engineer nsultant chitect J D ARCHITECT MINATEDAR MINATEDAR MINATEDAR MINATEDAR MINATEDAR MINATEDAR MINATEDAR MINATEDAR	ier Electrical, uctural & ing TS PTY. LT s.com.au 802 CHITECT: NN (7403) ECLU hent of E	D. 44 Litt Darlin Telepi www.j	JOHNSTA BLAC GOLD NES NICH SULTING EN DITEC tle Oxford S ghurst, NSV hone: 02 92 ddharchitects	AFF CKETT UIRE SMITH OGINEER CLSON NGINEER
	Lar Pro Bui Me Hyy Civ Co Arc Arc Arc Arc NOI JDH info ABB ACC NOI JAY Cliu	Dject Manag ilding Certif ichanical, E draulic, Stri il Engineer nsultant chitect JDD ARCHITECT @jdharchitect N 27 110 976 MINATED AR N 110 9776 MINATED AR N 110 9776 MINATED AR N 110 9776 MINATED AR N 10 976 MINATED AR N 10 9776 MINATED AR N 10 9776	ier Electrical, uctural & ing SPTY. LT s.com.au 802 CHITECT: S00 CHITECT: NN (7403)	D. 44 Litt Darlin Telepi www.j	JOHNSTA BLAC GOLD NES NICH SULTING EN DITEC tle Oxford S ghurst, NSV hone: 02 92 ddharchitects	
	Lar Pro Bui Me Hyy Civ Co Arc Arc Arc Arc NOI JAY Cliu Co So NOI JAY Cliu Cliu NOI JAY Cliu Cliu Cliu Cliu Cliu Cliu Cliu Cliu	Dject Manage ilding Certif ichanical, E draulic, Stra il Engineer nsultant chitect JDD ARCHITECT MINATEDAR MINA	ier iectrical, uctural & ing I I I I s.com.au 802 CHITECT: 802 CHITECT: NN (7403) ECLU hent of E at, Sydne	D. 44 Litt Darlin Telepi www.j	JOHNSTA BLAC GOLD NES NICH SULTING EN DITEC the Oxford S ghurst, NSV hone: 02 92 dharchitect	
	Lar Pro Bui Me Hyy Civ Co Arc Arc Arc Arc NOI JAY Cliu Co So NOI JAY Cliu Cliu NOI JAY Cliu Cliu Cliu Cliu Cliu Cliu Cliu Cliu	adscape oject Manage ilding Certif ichanical, E draulic, Stru- ril Engineer nsultant chitect JDD ARCHITECT @jdharchitecl MINATED AR MINATED AR MINATE	ier iectrical, uctural & ing I I I I s.com.au 802 CHITECT: 802 CHITECT: NN (7403) ECLU hent of E at, Sydne	D. 44 Litti Darlin Telepi www.j	JOHNSTA BLAC GOLD NES NICH SULTING EN DITEC the Oxford S ghurst, NSV hone: 02 92 dharchitect	
	Lar Pro Bui Me Hyu Civ Co Arc Arc Arc Arc Arc Arc Noi JAY Cliu Co Noi JAY Cliu Co Noi S E Fro S C	Dject Manage ilding Certif inchanical, E draulic, Stra ilding Certif il Engineer nsultant chitect JDD ARCHITECT @jdharchitect MINATED AR N 27 110 976 MINATED AR N 21 110 976 MINATED AR N 21 110 976 MINATED AR N 210 976 MINATED AR MINATED AR	ier ilectrical, uctural & ing S PTY. LT s.com.au 802 CHITECT: 802 CHITECT: 100 CHITEC	LA NON Control Con	JOHNSTA BLAC MAG GOLD NES NICH SULTING EN DITEC	
	Lar Pro Bui Me Hyu Civ Co Arc Arc Arc Arc Arc Arc Noi JAY Cliu Co Noi JAY Cliu Co Noi S E Fro S C	Dject Manage ilding Certif inchanical, E draulic, Stra ilding Certif il Engineer nsultant chitect JDD ARCHITECT @jdharchitect MINATED AR N 27 110 976 MINATED AR N 21 110 976 MINATED AR N 21 110 976 MINATED AR N 210 976 MINATED AR MINATED AR	ier ilectrical, uctural & ing S PTY. LT s.com.au 802 CHITECT: 802 CHITECT: 100 CHITEC	LA NO A A A A A A A A A A A A A	JOHNSTA BLAC MAG GOLD NES NICH SULTING EN DITEC	AFF CKETT UIRE SMITH OGINEER OCLSON NGINEER
	Lar Pro Bui Bui Me Hyu Civ Co Arc Arc Arc Arc Arc Arc Arc Noi JDH Info Act Noi JAY Cliu Co Noi S 5 E Pro M S 5 FC M	Dject Manage ilding Certif inchanical, E draulic, Stra ilding Certif il Engineer nsultant chitect JDD ARCHITECT @jdharchitect MINATED AR N 27 110 976 MINATED AR N 21 110 976 MINATED AR N 21 110 976 MINATED AR N 210 976 MINATED AR MINATED AR	ier ilectrical, uctural & ing S PTY. LT s.com.au 802 CHITECT: 802 CHITECT: 100 CHITEC	LA NON Control Con	JOHNSTA BLAC MAG GOLD NES NICH SULTING EN DITEC	AFF CKETT UIRE SMITH OGINEER OCLSON NGINEER
	Lar Pro Bui Me Hy Civ Co Arc Arc Arc Arc Arc Arc NOI JAY Cliu Co NOI DAY Cliu Co NOI JAY Cliu Co NOI JAY Cliu Co NOI JAY Cliu Co NOI DAY Cliu CDI Cliu CDI Cliu CDI Cliu CDI Cliu CDI Cliu CDI Cliu CDI CDI CDI CDI CDI CDI CDI CDI CDI CDI	Dject Manage ilding Certif inchanical, E draulic, Strai ilding Certif il Engineer nsultant chitect JDD ARCHITECT @idharchitect MINATEDAR MINAT	ier Ectrical, uctural & ing S PTY. LT s.com.au 802 CHITECT: 802 CHITECT: 100 CHITECT:	LA NON Control Con	JOHNSTA BLAC MAG GOLD NES NICH SULTING EN DITEC	AFF CKETT UIRE SMITH OGINEER OCLSON NGINEER
	Lar Pro Bui Me Hyy Civ Co Arc Arc Arc Arc Arc Arc Arc Arc	Dject Manage Dject Manage ilding Certif ichanical, E draulic, Stri il Engineer nsultant chitect JDD ARCHITECT JDD ARCHITECT MINATEDAR NE HARRISC MINATEDAR NE HARRISC Diget Name Diget Name	ier Ectrical, uctural & ing S PTY. LT s.com.au 802 CHITECT: 802 CHITECT: 100 CHITECT:	LA NOR CONTRACTO	JOHNSTA OHNSTA BLAC MAG GOLD NES NICH NES NICH SULTING EN DITEC I I I I I I I I I I I I I	CTES CKETT UIRE SMITH OCLSON STREET V 2010 81 8697 S. com.au
	Lar Pro Bui Me Hy Civ Co Arc Arc Arc Arc So So FC M Sc Pro M Sc Pro	adiscape aject Manage ilding Certif inchanical, E draulic, Stra ilding Certif inchanical, E draulic, Stra ilding Certif inchanical, E draulic, Stra ilding Certif inchanchitect J DD ARCHITECT avitant intert	ier ilectrical, uctural & ing IIIII S PTY. LT S 202 CHITECT: N (7403) ECL CLANI CL	LA A A A A A A A A A A A A A	JOHNSTA Control of the output	CTES CKETT UIRE SMITH OCLSON STREET V 2010 81 8697 S. com.au
	Lar Pro Bui Me Hy Civ Co Arc Arc Arc Arc Arc Arc Arc Arc	adiscape aject Manage ilding Certif inchanical, E draulic, Stra ilding Certif inchanical, E draulic, Stra illicet JDD ARCHITECT MINATEDAR MINA	ier ilectrical, uctural & ing SPTY. LT S. COM. AU 1902 CHITECT: N (7403) ECL ANDS CLANI DL CLANI CLANI DL SED S 00 @A1 Drawing I	LA A A A A A A A A A C A A A A A A A A A A A A A	JOHNSTA Commentation Comment	CTES CKETT UIRE SMITH OCLSON STREET V 2010 81 8697 S. com.au
	Lar Pro Bui Me Hy Civ Co Arc Arc Arc Arc Arc Arc Arc Arc	adiscape aject Manage ilding Certif inchanical, E draulic, Stra ilding Certif inchanical, E draulic, Stra illicet JDD ARCHITECT MINATEDAR MINA	ier ilectrical, uctural & ing IIIII S PTY. LT S 202 CHITECT: N (7403) ECL CLANI CL	LA A A A A A A A A A C A A A A A A A A A A A A A	JOHNSTA Control of the output	CTES CKETT UIRE SMITH OCLSON STREET V 2010 81 8697 S. com.au

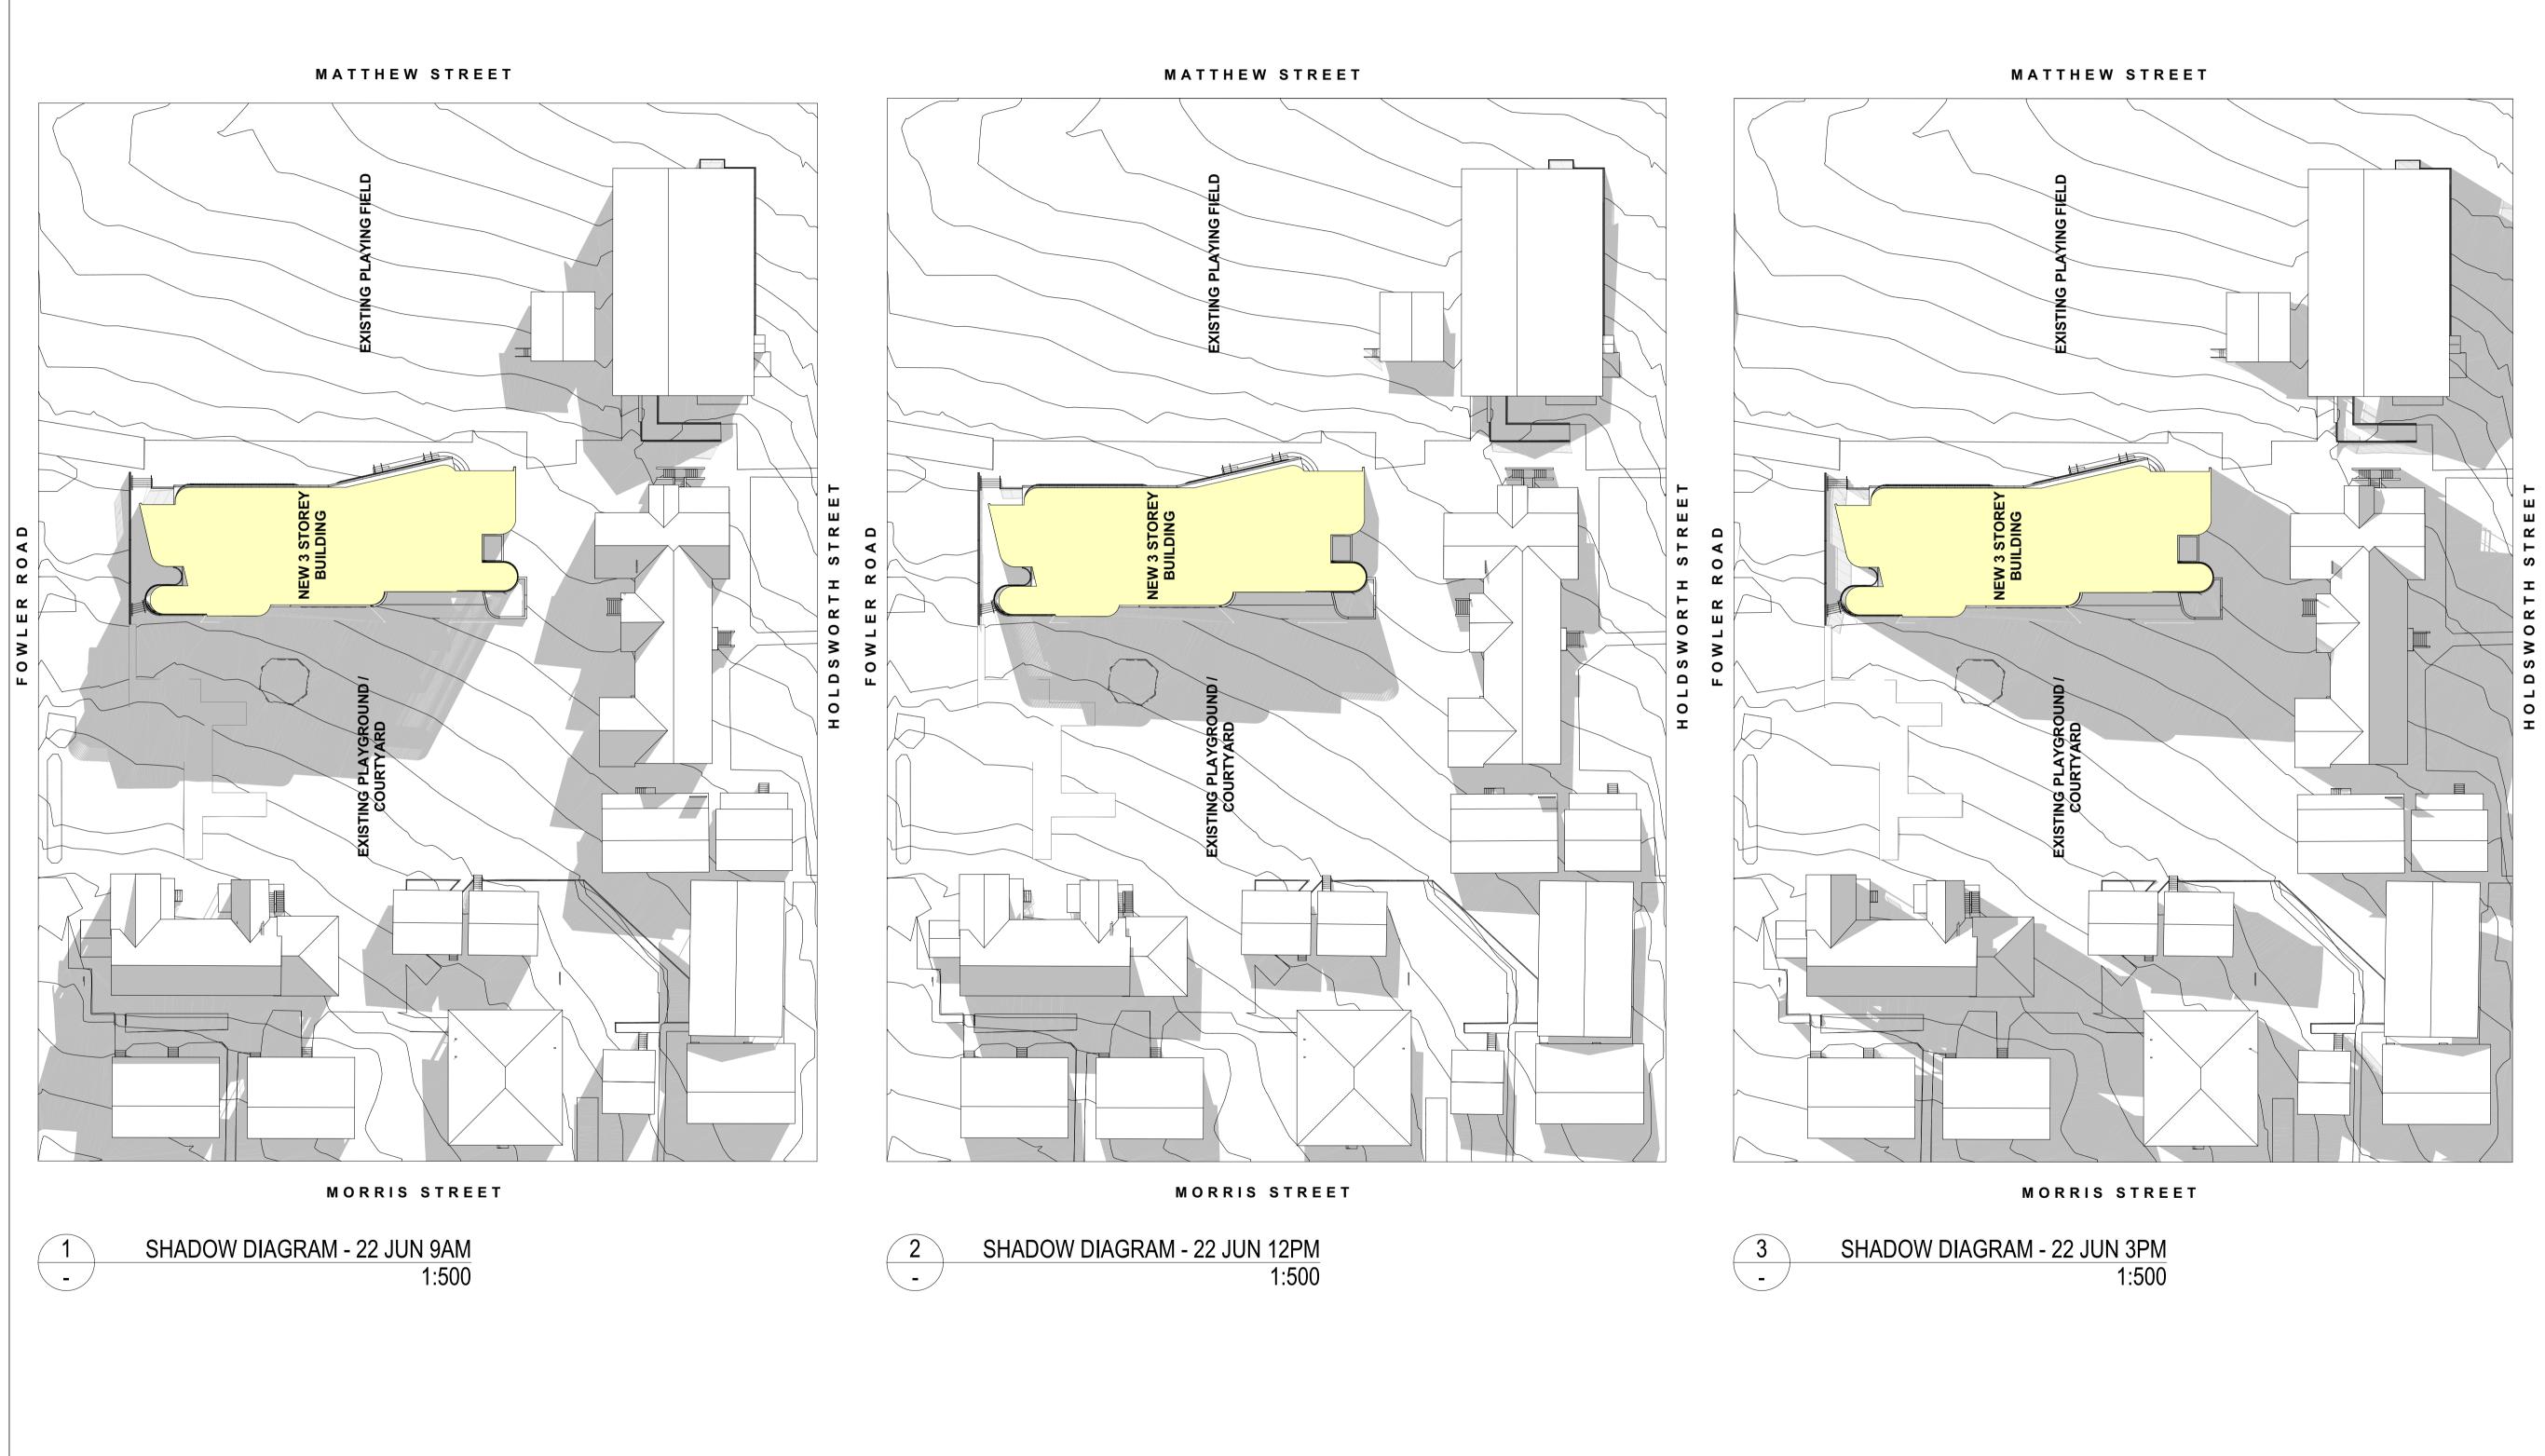

THE AND USE DRA PUF	CONTRACTO VERIFY ALL FIGURATIVE	DR SHAI ERROR DIMEN L NOT E L ISSUE	RCHITECTS PTY. LTD. LL CHECK AND VERIFY ALL DIMEN S AND OMISSIONS TO THE ARCHI SIONS, DO NOT SCALE THE DRAW BE USED FOR CONSTRUCTION D BY THE ARCHITECT FOR	TECT.
Rev	Date	Ву	Issue Name	СК
А	08-Aug-17	AT	ISSUE FOR DA	AC
в	05-Sep-17	AT	ISSUE FOR DA	AC
	1			




Planning	dfp
Landscape	SPACE LANDSCAPE DESIGNS
Project Manager	JOHNSTAFF
Building Certifier	BLACKETT MAGUIRE+ GOLDSMITH
Mechanical, Electrical, Hydraulic, Structural & Civil Engineering Consultant	ONES NICHOLSON
info@jdharchitects.com.au Dai ABN 27 110 978 802 Tel ACN 110 978 802 Tel	Little Oxford Street rlinghurst, NSW 2010 ephone: 02 9281 8697 w.jdharchitects.com.au
Client	n
Project Name MERRYLANDS PU SCHOOL FOWLER ROAD, MERRYLANDS NSW 2	
Drawing Title SHADOW DIAGRAMS	5
Scale :         1:500 @A1           Drawn :         AT	Date : 19-Apr-18 Checked :AC
Project No. Drawing No.	Rev.
997 DA61	В
QUALITY INITIALLING THE 'DRA' CERTIFIED ISO CONFIRMS THAT THIS 9001 PREPARED IN CONFOG ARCHITECTS Q.M.S. P	RMITY WITH JDH

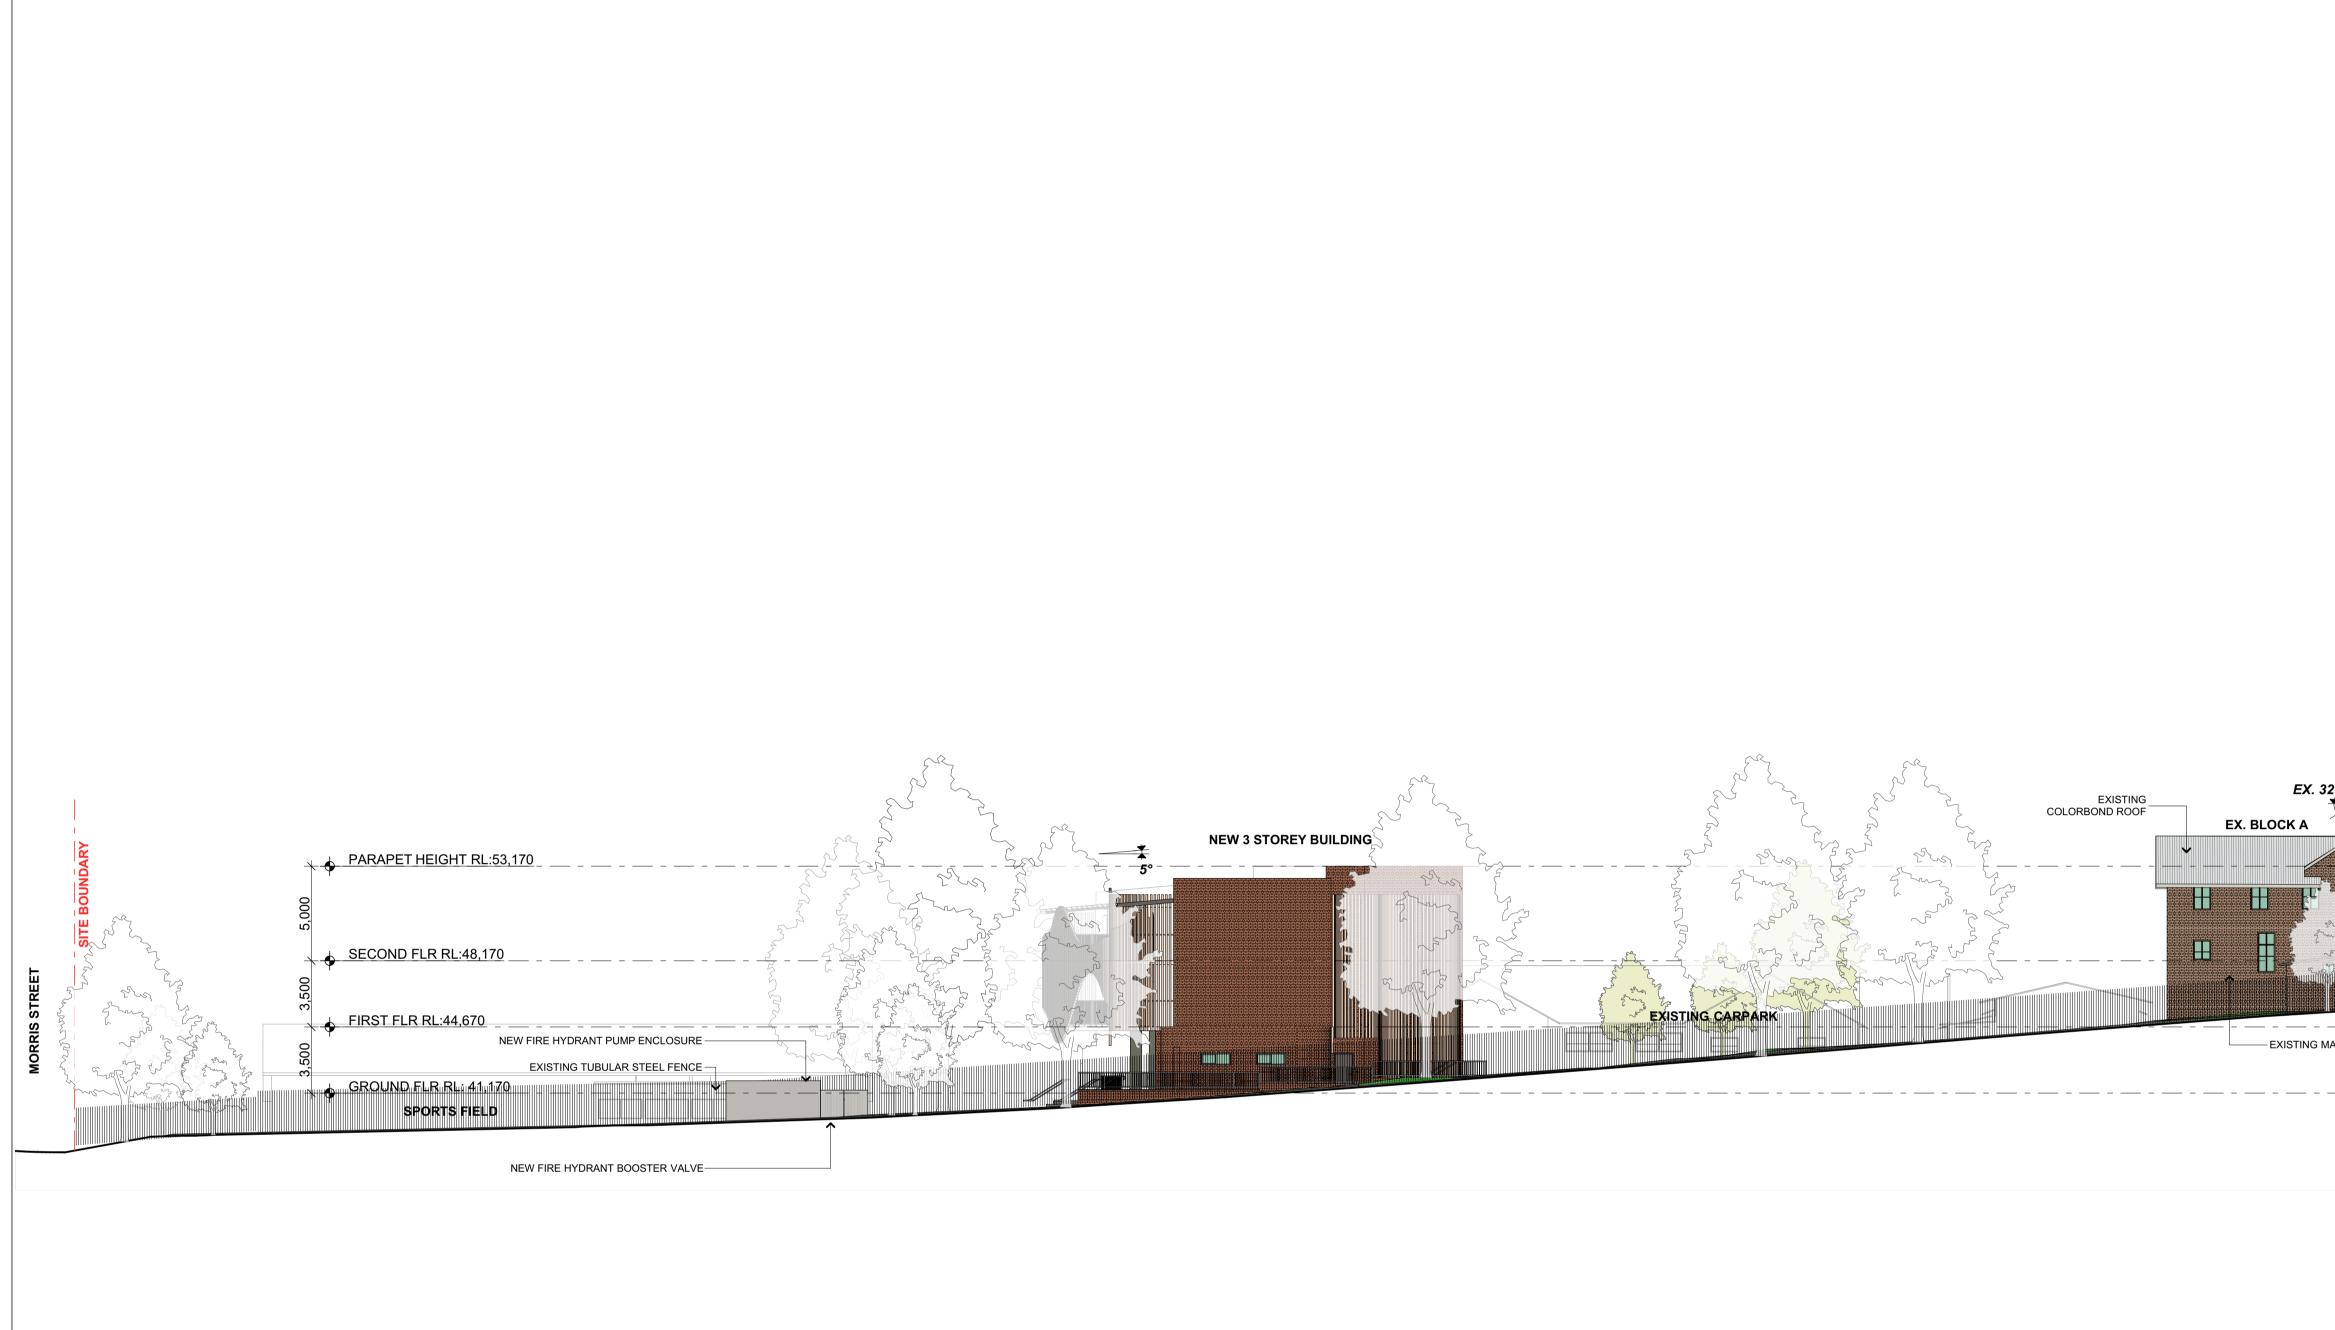

	THE C AND \ USE F DRAW PURP CONS	CONTRACT VERIFY ALL FIGURATIVE VINGS SHAL	DR SHALI ERRORS DIMENS L NOT BI L ISSUED	AND OMISSION	ERIFY ALL DIMEN NS TO THE ARCHI SCALE THE DRAW ONSTRUCTION	FECT.
		08-Aug-17 05-Sep-17	AT AT	ISSUE FOR DA		AC AC
			·			
			5		    >	
		<	2	~~~~~~~~~~~~~~~~~~~~~~~~~~~~~~~~~~~~~~~	BOUNDARY	
		53	r S	2 State		
2° RL 56,420		AND	A.A.	2 Cr		]
<b>EX. 9°</b>		2 JUL		5 25cm		
	СКС	RL 51	,960		MATTHEW STREE	
	- -			and the second	MATTH	
		— EXIS	TING F	C CLADDING	3	
MASONRY						
			·			
	Planı					lfp
	Land	lscape		S	ANDSCAPE DESI	G N S
	Proje	ect Manag	er		JOHNSTAF	
	Build	ling Certifi	er		BLACK MAGUII GOLDSN	ETT RE+ /ITH
	Hydr Civil	hanical, El aulic, Stru Engineeri	ctural &		NES NICHOL	
	Cons Archi	sultant itect				
	JDH A	RCHITECT	S PTY. LT	D. 44 Li	nitec'	et
	ACN NOMI	jdharchitects 27 110 978 110 978 NATED ARC E HARRISO	802 HITECT:	Telep	nghurst, NSW 2 bhone: 02 9281 .jdharchitects.co	8697
	Clien	nt				
	N.	SW	드신	ication	PERSEVERE PERSEVERE PERSEVERE	ns 100
	NSW	RNMENT I / Departm dge Stree	ent of E	ducation		v
		ect Name	LAN	DS PUE	BLIC	
	SC	ЮО	L		-	
		WLER RRYL	ROA ANDS	D, S NSW 2 <sup>-</sup>	160	
	Draw	ving Title		<b>-</b> -, -,		
	Draw STI Scale	REETS	SCAP 0 @A1			Apr-18
	Draw STI Scale Draw Projec	REETS           e :         1:200           vn :         AT           st No.         D	0 @A1 Prawing I	No.	Date : 19-A Checked :AC Rev.	\pr-18
	Draw STI Scale Draw Projec <b>99</b>	REETS           e :         1:200           vn :         AT           st No.         D	0 @A1 Prawing I DA8	NO. 1 NG THE 'DRAWN	Date : 19-A Checked :AC	' BOXES


	REVISION A					
CODE	LOCATION	MATERIAL	COLOUR	MANUFACTURER		
AL	ALUMINIUM WINDOWS AND DOORS	ALUMINIUM	NATURAL ANODISED	-		
CL1	TIMBER LOOK BATTENS	ALUMINIUM POWDERCOAT	SPOTTED GUM	URBANLINE		
CL2	CLADDING	ALUMINIUM COMPOSITE PANEL	SILVER METALLIC (G30)	ALPOLIC		
CONC	CONCRETE PAVING, STAIRS	INTEGRAL COLOURED CONCRETE	SMOKEY BLUE	CONCRETE COLOUR SYSTEMS		
CPP	UNDERCROFT	METAL	PROPRIETARY RAW FINISH	DECOR SYSTEMS		
MF1	ALL GUTTERS, PARAPET CAPPING, DOWNPIPES	STEEL	SURFMIST	COLORBOND		
PF1	PAINT FINISH - CEILINGS AND SOFFIT LININGS	FIBRE CEMENT - WASH AND WEAR FLAT FINISH	PUREST WHITE (CODE: 19.30)	WATTYL		
PF2	EXPOSED CONCRETE COLUMNS	CONCRETE	NATURAL - EXTERNAL SUN GUARD PAINT	-		

## EXTERNAL FINISHES SCHEDULE REVISION A

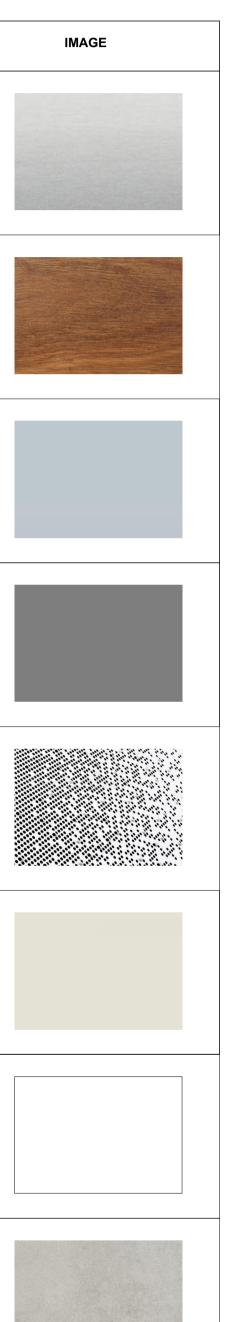

CODE	LOCATION	MATERIAL	COLOUR	MANUFACTURER
PF3	PAINT FINISH - EXTERNAL DOORS	OIL BASED PAINT GLOSS FINISH EQUAL TO DULUX PAINTS	COLOUR: JUVENILE CODE: SG5E7	DULUX
RMS	ROOF METAL SHEETING	ROOF METAL SHEETING SUITABLE FOR 5 DEGREE ROOF EQUAL TO LYSAGHT CUSTOM ORB	SURFMIST	LYSAGHT
RSF1	ROOF FLASHING	COLORBOND STEEL FLASHING TO MATCH ROOF SHEET	SURFMIST	LYSAGHT
RSF2	BARGE CAPPING & FASCIA	COLORBOND STEEL CAPPING & FASCIA	SURFMIST	LYSAGHT
RWT	RAINWATER TANK	STEEL	SHALE GREY	COLORBOND
WCL	CLADDING - NORTH, EAST AND WEST FACADES	ALUMINIUM COMPOSITE PANEL	PURE WHITE CODE: VC9902	VITRACORE G2
WFB	ALL MASONRY - PRIMARILY SOUTH FACADE	FACE BRICK	RENOVATION GERTRUDIS BROWN	AUSTRAL BRICKS

THE AND USE DRA PUR	CONTRACTO VERIFY ALL E FIGURATIVE I WINGS SHALL	R SHALL RRORS DIMENSI . NOT BE	CHITECTS PTY. LTD. CHECK AND VERIFY ALL DIMENSIO AND OMISSIONS TO THE ARCHITEC ONS, DO NOT SCALE THE DRAWING USED FOR CONSTRUCTION BY THE ARCHITECT FOR	T.			
Rev	Date	Ву	Issue Name	CK			
А	08-Aug-17	AT	ISSUE FOR DA	AC			
в	05-Sep-17	AT	ISSUE FOR DA	AC			

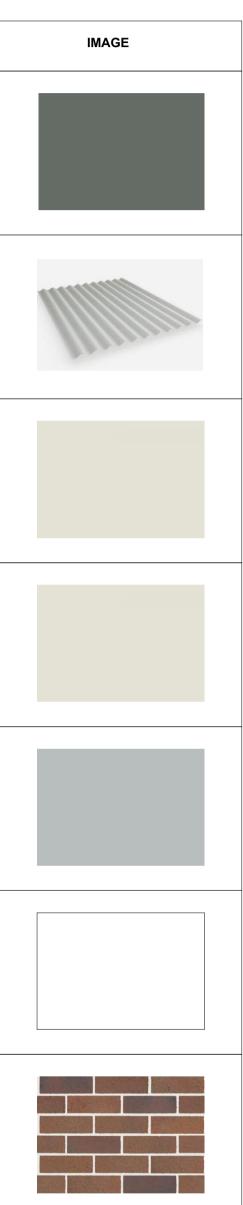

Planning	dfp
Landscape	SPACE
	LANDSCAPE DESIGNS
Project Manager	LANDSCAPE DESIGNS
Project Manager Building Certifier	JOHNSTAFF BLACKETT MAGUIRE+
Building Certifier Mechanical, Electrical, Hydraulic, Structural &	JOHNSTAFF BLACKETT MAGUIRE+ GOLDSMITH
Building Certifier Mechanical, Electrical, Hydraulic, Structural & Civil Engineering Consultant Architect	JOHNSTAFF JOHNSTAFF BLACKETT MAGUIRE+ GOLDSMITH
Building Certifier Mechanical, Electrical, Hydraulic, Structural & Civil Engineering Consultant Architect <b>JDHARCHITECTS PTY. LTD.</b>	JOHNSTAFF JOHNSTAFF BLACKETT MAGUIRE+ GOLDSMITH
Building Certifier Mechanical, Electrical, Hydraulic, Structural & Civil Engineering Consultant Architect JDHA	JOHNSTAFF JOHNSTAFF BLACKETT MAGUIRE+ GOLDSMITH NE JONES NICHOLSON CONSULTING ENGINEERS
Building Certifier Mechanical, Electrical, Hydraulic, Structural & Civil Engineering Consultant Architect JDH ARCHITECTS PTY. LTD. info@dharchitects.com.au ABN 27 110 978 802 ACN 110 978 802	JOHNSTAFF JOHNSTAFF BLACKETT MAGUIRE+ GOLDSMITH NECONSULTING ENGINEERS CONSULTING ENGINEERS
Building Certifier Mechanical, Electrical, Hydraulic, Structural & Civil Engineering Consultant Architect JDH ARCHITECTS PTY. LTD. info@jdharchitects.com.au ABN 27 110 978 802 ACN 110 978 802 NOMINATED ARCHITECT: JAYNE HARRISON (7403)	ANDSCAPE DESIGNS JOHNSTAFF JOHNSTAFF BLACKETT MAGUIRE+ GOLDSMITH NEONES NICHOLSON MICHOLSON SULTING ENGINEERS A4 Little Oxford Street Darlinghurst, NSW 2010 Telephone: 02 9281 8697 www.jdharchitects.com.au
Building Certifier Mechanical, Electrical, Hydraulic, Structural & Civil Engineering Consultant Architect JDH ARCHITECTS PTY, LTD. info@jdharchitects.com.au ABN 27 110 978 802 ACN 110	ACTION STAFF
Building Certifier Mechanical, Electrical, Hydraulic, Structural & Civil Engineering Consultant Architect JDH ARCHITECTS PTY, LTD. info@jdharchitects.com.au ABN 27 110 978 802 ACN 110	ALLINDSCAPE DESIGNS
Building Certifier Mechanical, Electrical, Hydraulic, Structural & Civil Engineering Consultant Architect JDH ARCHITECTS PTY. LTD. Info@idharchitects.com.au ABN 27 110 978 802 ACN 110	ALUTION CAPE DESIGNS
Building Certifier Mechanical, Electrical, Hydraulic, Structural & Civil Engineering Consultant Architect JDH ARCHITECTS PTY. LTD. Info@jdharchitects.com.au ABN 27 110 978 802 ACN 10 978 802	ALLINDSCAPE DESIGNS
Building Certifier Mechanical, Electrical, Hydraulic, Structural & Civil Engineering Consultant Architect JDH ARCHITECTS PTY, LTD. Info@jdharchitects.com.au ABN 27 110 978 802 ACN 110	LANDSCAPE DESIGNS JOHNSTAFF DELACKETT GOLDSMITH NECONSULTING ENGINEERS ALLITHE OXFORD STREET CONSULTING ENGINEERS ALLITHE OXFORD STREET Telephone: 02 9281 8697 www.jdharchitects.com.au ALLITHE OXFORD STREET Telephone: 02 9281 8697 www.jdharchitects.com.au ALLITHE OXFORD STREET SW 2160 NISHES Date : 19-Apr-18
Building Certifier Mechanical, Electrical, Hydraulic, Structural & Civil Engineering Consultant Architect JDD H ARCHITECTS PTY. LTD. info@idharchitects.com.au ABN 27 110 978 802 ACN 10 978 80 ACN	ALLINDSCAPE DESIGNS JOHNSTAFF DELACKETT GOLDSMITH NECONSULTING ENGINEERS ALLITHE OXFORD STREET ALLITHE OXFORD STREET THE OXFORD STREET STREET THE OXFORD STREET STREET THE OXFORD STREET STREET THE OXFORD STREET STREET STREET STREET STREET STREET STREET STREET
Building Certifier  Mechanical, Electrical, Hydraulic, Structural & Civil Engineering Consultant  Architect  JDH ARCHITECTS PTY. LTD. Info@idharchitects.com.au ABN 27 110 978 802 ACN 10 97 ACN 10 97 ACN 10 000	ALLINDSCAPE DESIGNS JOHNSTAFF DELACKETT GOLDSMITH INCONSULTING ENGINEERS INCONSULTING ENGINEERS ALLITE OXFORD Street Darlinghunst, NSW 2010 Telephone: 02 9281 8697 www.jdharchitects.com.au ALLITE OXFORD Street Darlinghunst, NSW 2010 Telephone: 02 9281 8697 www.jdharchitects.com.au



THE AND USE DRA PUR	CONTRACTO VERIFY ALL E FIGURATIVE	R SHALL RRORS DIMENSI NOT BE	CHITECTS PTY. LTD. CHECK AND VERIFY ALL DIMENSIO AND OMISSIONS TO THE ARCHITEC ONS, DO NOT SCALE THE DRAWING USED FOR CONSTRUCTION BY THE ARCHITECT FOR	CT.			
Rev	Rev Date By Issue Name CK						
A	08-Aug-17	AT	ISSUE FOR DA	AC			
в	05-Sep-17	AT	ISSUE FOR DA	AC			
	1	1	1				

Planning	dfp
Landscape	S P A C E LANDSCAPE DESIGNS
Project Manager	JOHNSTAFF
Building Certifier	BLACKETT MAGUIRE+ GOLDSMITH
Mechanical, Electrical, Hydraulic, Structural & Civil Engineering Consultant	
Architect	chitects
JDH ARCHITECTS PTY. LTD. info@jdharchitects.com.au ABN 27 110 978 802 ACN 110 978 802 NOMINATED ARCHITECT: JAYNE HARRISON (7403)	44 Little Oxford Street Darlinghurst, NSW 2010 Telephone: 02 9281 8697 www.jdharchitects.com.au
Client	â
SOVERNMENT NSW Department of Education	
5 Bridge Street, Sydney Project Name	
MERRYLANDS F	PUBLIC
FOWLER ROAD, MERRYLANDS NSV	W 2160
3D PERSPECTIVE	Date : 19-Apr-18
Drawn : AT Project No. Drawing No.	Checked :AC Rev.
997 DA100	B
CERTIFIED ISO CONFIRMS THAT	DRAWN' AND THE 'CHECK' BOXES THIS DRAWING HAS BEEN NFORMITY WITH JDH



THE AND USE DRA PUR	CONTRACTO VERIFY ALL E FIGURATIVE I WINGS SHALL	R SHALL RRORS DIMENSI NOT BE	CHITECTS PTY. LTD. CHECK AND VERIFY ALL DIMENSIO AND OMISSIONS TO THE ARCHITEC ONS, DO NOT SCALE THE DRAWING USED FOR CONSTRUCTION BY THE ARCHITECT FOR	ЭΤ.		
Rev	Date	Ву	Issue Name	CK		
A	08-Aug-17	AT	ISSUE FOR DA	AC		
в	05-Sep-17	AT	ISSUE FOR DA	AC		
	1		1			

Planning
Planning
Landscape S P A C C LANDSCAPE DESIGNS
Project Manager
Building Certifier
Mechanical, Electrical, Hydraulic, Structural & Civil Engineering Consultant
JDH architects
JDH ARCHITECTS PTY. LTD. info@jdharchitects.com.au ABN 27 110 978 802 ACN 110 978 802 NOMINATED ARCHITECT: JAYNE HARRISON (7403) 44 Little Oxford Street Darlinghurst, NSW 2010 Telephone: 02 9281 8697 www.jdharchitects.com.au
Education
NSW Department of Education 5 Bridge Street, Sydney
Project Name MERRYLANDS PUBLIC SCHOOL
FOWLER ROAD, MERRYLANDS NSW 2160
Drawing Title
3D PERSPECTIVE - SHEET 2 Scale : @A1 Date : 19-Apr-18
Drawn : AT Checked :AC
Project No. Drawing No. Rev. 997 DA101 B
QUALITY INITIALLING THE 'DRAWN' AND THE 'CHECK' BOXES

CONFIRMS THAT THIS DRAWING HAS BEEN PREPARED IN CONFORMITY WITH JDH ARCHITECTS Q.M.S. PROCEDURES. Status: DEVELOPMENT APPLICATION



THE AND USE DRA PUR	CONTRACTO VERIFY ALL E FIGURATIVE	R SHALL RRORS DIMENSI NOT BE	CHITECTS PTY. LTD. CHECK AND VERIFY ALL DIMENSIO AND OMISSIONS TO THE ARCHITEC ONS, DO NOT SCALE THE DRAWING USED FOR CONSTRUCTION BY THE ARCHITECT FOR	T.			
Rev	Date	Ву	Issue Name	CK			
А	08-Aug-17	AT	ISSUE FOR DA	AC			
в	05-Sep-17	AT	ISSUE FOR DA	AC			

Planning			
			atp
Landscape	•	SP	A C E
Project Ma	nager	JOH	INSTAFF
Building C	ertifier		BLACKETT MAGUIRE+ Goldsmith
			NICHOLSON
Architect			
JDH ARCHIT	DHar	44 Little O	xford Street
ABN 27 110 ACN 110 NOMINATED	itects.com.au 978 802 978 802 ARCHITECT: RISON (7403)	Telephone	st, NSW 2010 : 02 9281 8697 chitects.com.au
Client			
	k     Educat	tion	PERSEVERE
	artment of Education treet, Sydney	on	~
Project Na MERF SCHC	RYLANDS	PUBLIC	C
FOWLI	ER ROAD, YLANDS NS	W 2160	
Drawing T			
-	RSPECTIVE	- SHEE	Т 3
3D PEI			
Scale :	@A1 AT	Date Che	•
Scale :	@A1		e : 19-Apr-18 cked :AC Rev.
Scale : Drawn :	@A1 AT		cked :AC