

Α

(W3)

(A2) 3m/3

⊖^{A2} ⊖4m/3



_____ R1 INTEGRATED HANDRAIL LIGHTING LED 23 ASSYMETRIC OPTICS 4000K


 $^{\rm U1}$ INGROUND UPLIGHT LED 10W IP65 IK08 4000K

 $^{\circ}$ U2 ADJUSTABLE LED INGROUND SPIKE LUMINAIRE 12W IP65 4000K

- (W1) EXTERNAL RECESSED WALL LIGHT AT LOW LEVEL 10W IK08 IP65 4000K
- (W2) EXTERNAL SURFACE WALL MOUNTED UP/DOWN LIGHT

WALL MOUNTED BUNKER LIGHT 30W 4000K

SMALL WEATHERPROOF LED AREA LUMINAIRE C/W BLACK FINISH ON BLACK POWDER COATED GALVANISED POLE. POLE HEIGHT SHOWN 'Xm/' IN METRES & DISTRIBUTION TYPE SHOWN '/3' WM INDICATES WALL MOUNTED. LSI HAMILTON XAS TYPE-3 63W

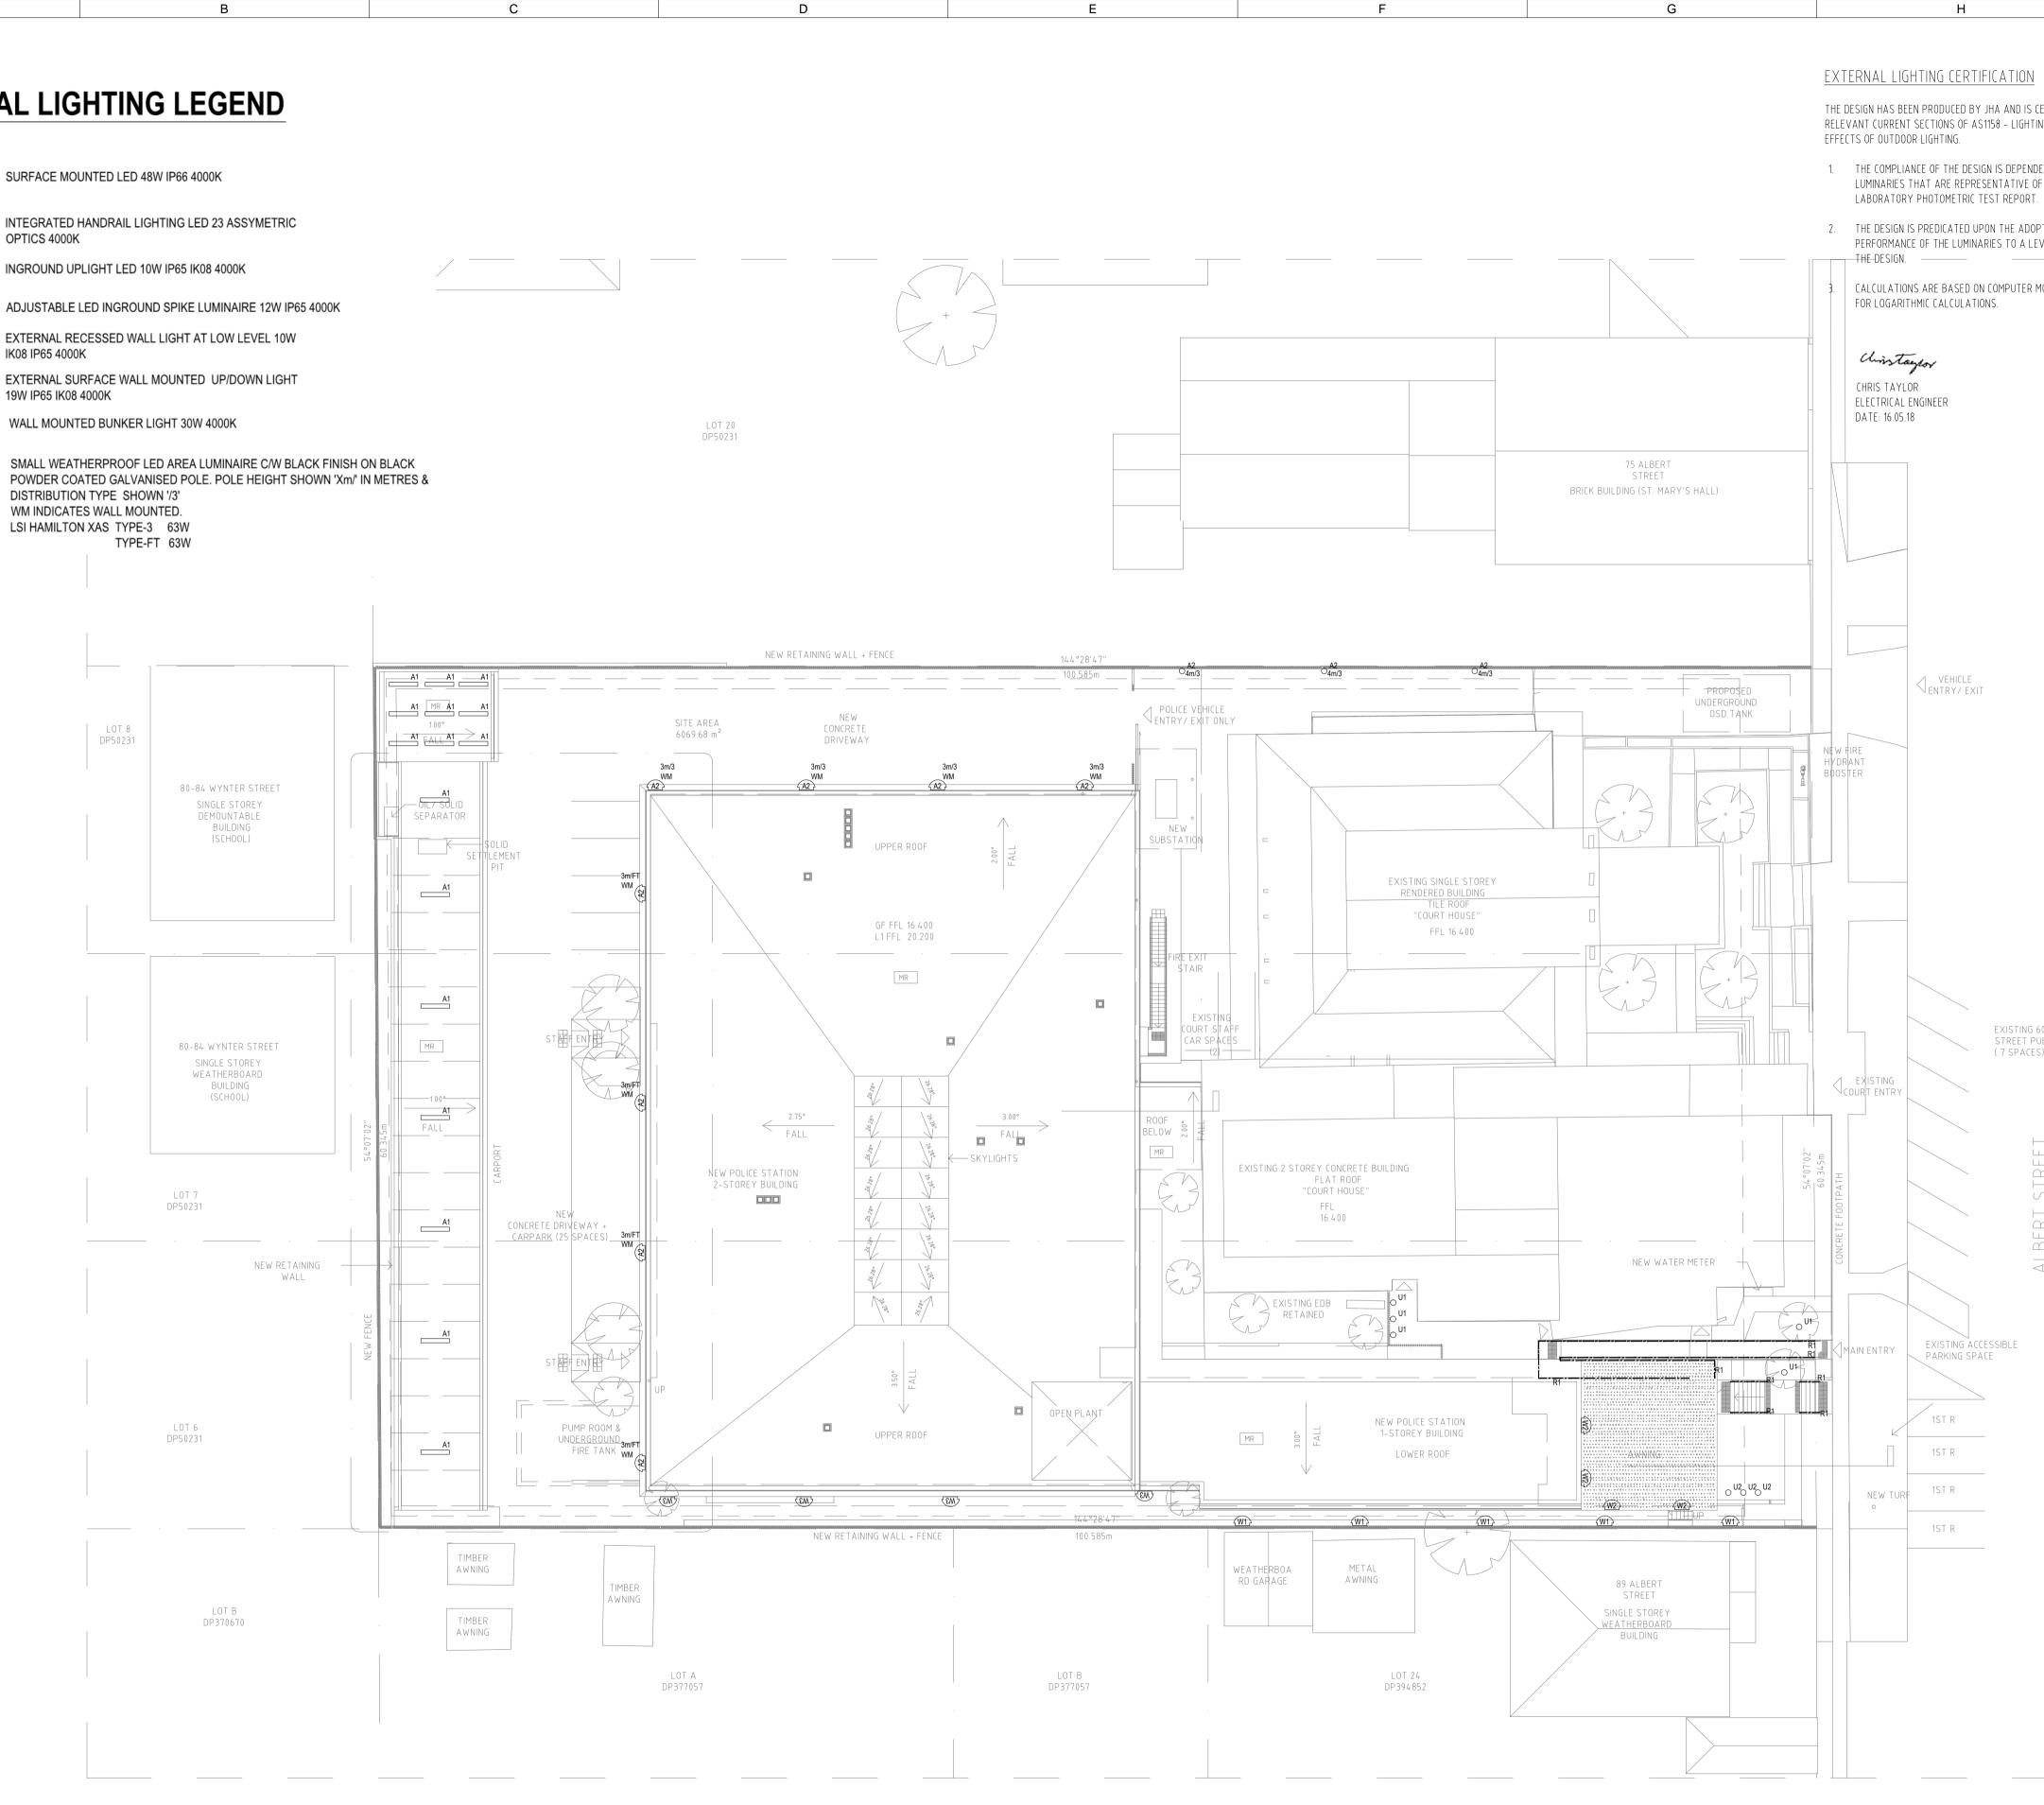

E

В

Α

С

10 5

Н

F

G

THE DESIGN HAS BEEN PRODUCED BY JHA AND IS CERTIFIED TO COMPLY WITH THE REQUIREMENTS OF THE RELEVANT CURRENT SECTIONS OF AS1158 – LIGHTING FOR ROADS AND PUBLIC SPACES AND AS4282 – OBTRUSIVE

1. THE COMPLIANCE OF THE DESIGN IS DEPENDENT UPON THE LUMINAIRE MANUFACTURER SUPPLYING LUMINARIES THAT ARE REPRESENTATIVE OF THE DATA CONTAINED WITHIN THE APPROPRIATE REGISTERED

2. THE DESIGN IS PREDICATED UPON THE ADOPTION OF A MAINTENANCE REGIME THAT WILL MAINTAIN THE PERFORMANCE OF THE LUMINARIES TO A LEVEL EQUAL TO OR ABOVE THE MAINTENANCE FACTORS USED IN

CALCULATIONS ARE BASED ON COMPUTER MODELING PROGRAM AGI32. JHA CANNOT BE HELD RESPONSIBLE



REVISIONS / AMENDMENTS

Rev Date Description

P1 03.05.18 FOR REVIEW

P2 16.05.18 FOR REVIEW

All dimensions to be verified on site/s prior to commencement of on-site work and/ or off-site prefabrication. Figured dimension to be taken in preference to scaled dimensions. This drawing is copyright and remains the property of JHA Consulting Engineers. Reproduction in whole or part of these drawings without written consent

Verified

C.T.

C.T.

constitutes an infringement of copyright.



ARCHITECT

CLIENT



CONSULTANT

20 m

10

- I

1 : 250-A1 1 : 500-A3



+61 (02) 9437 1000

PROJECT TAREE POLICE STATION 83 ALBERT STREET, TAREE

TITLE ELECTRICAL SERVICES SITE PLAN LIGHTING LAYOUT

PRELIMINARY ISSUE				7
DRAWN	J.M.	SCALE @ A1		'
CHECKED	C.S.			
APPROVED	C.S.	1:250		
CREATED	MAY 2018			
JOB No.	DRAWING No.		REV	
180035	E1001		P2	

J

EXISTING 60 DEG ANGLE STREET PUBLIC PARKING (7 SPACES)