

Scale= 1: 238.10

Luminaire Schedule						
Symbol	Qty	Description	Tag	LLF	Luminaire	
					Watts	
—-EIO	6	PO29-GP061-T2-W40 LIGMAN	P2 - T2	0.800	53	
—-E	15	PO29-GP061-T3-W40 - LIGMAN	P3-T3	0.800	53	
—-EID	3	PO29-GP061-T4-W40 - LIGMAN	P3-T4	0.800	53	
+	21	VK-30003-T4-W40 - LIGMAN	W1	0.800	36.5	

THE THIRD PARTIES.

1 - W1 LIGHTS ARE UNDER THE CANOPY. 2 - ALL THE POLES HAVE AN ARM LENGTH OF 0.5m

REV	DESCRIPTION	DATE
1	ISSUE 1	08/07/2024
2	ISSUE 2	02/08/2024

THE FOLLOWING VALUES ARE BASED ON EXACT CALCULATIONS ON CALIBRATED LAMPS, LUMINAIRES AND THEIR ARRANGEMENT. IN PRACTICE, GRADUAL DIVERGENCES CAN OCCUR. GUARANTEE CLAIMS FOR LUMINAIRE DATA ARE EXCLUDED.

NORTHROP CONSULTING ENGINEERS AND THE LUMINAIRE

MANUFACTURERS ACCEPT NO LIABILITY FOR THE CONSEQUENTIAL


DAMAGE AND DAMAGE WHICH IS OCCASSIONED TO THE USER OF

ALL DIMENSIONS MUST BE VERIFIED ON SITE. THIS DRAWING SHALL COMPLY WITH RELEVANT LOCAL AUTHORITY REGULATIONS. ANY VARIATIONS TO SPECIFICATIONS AND DRAWINGS MUST BE AUTHORISED BY THE DESIGNER, THESE DESIGNS, DRAWINGS AND SPECIFICATIONS ARE COPYRIGHT AND REMAIN THE PROPERTY OF NORTHROP CONSULTING ENGINEERS PTY LTD. THEY MUST NOT BE USED, REPRODUCED OR COPIED WHOLLY OR IN PART WITHOUT THE WRITTEN PERMISSION OF NORTHROP CONSULTING ENGINEERS PTY LTD.

CLIENT	
	NORTHROP

Sydney					
Level 11, 345 George Street, Sydney NSW 2000					
Ph (02) 9241 4188 Fax (02) 9241 4324					
Email: sydney@northrop.com.au ABN 81 094 433 100					

	PROJECT	PROJECT NO			
)	BAESA	NL223031			
	DRAWING TITLE	SCALE @ A1			
	AREA SUB-CATEGORY	IG CALCULATIONS	AS PER DWG		
	DRAWN	CHECKED	ISSUED	DWG No.	REV
	HK			LM01-XX.XX	

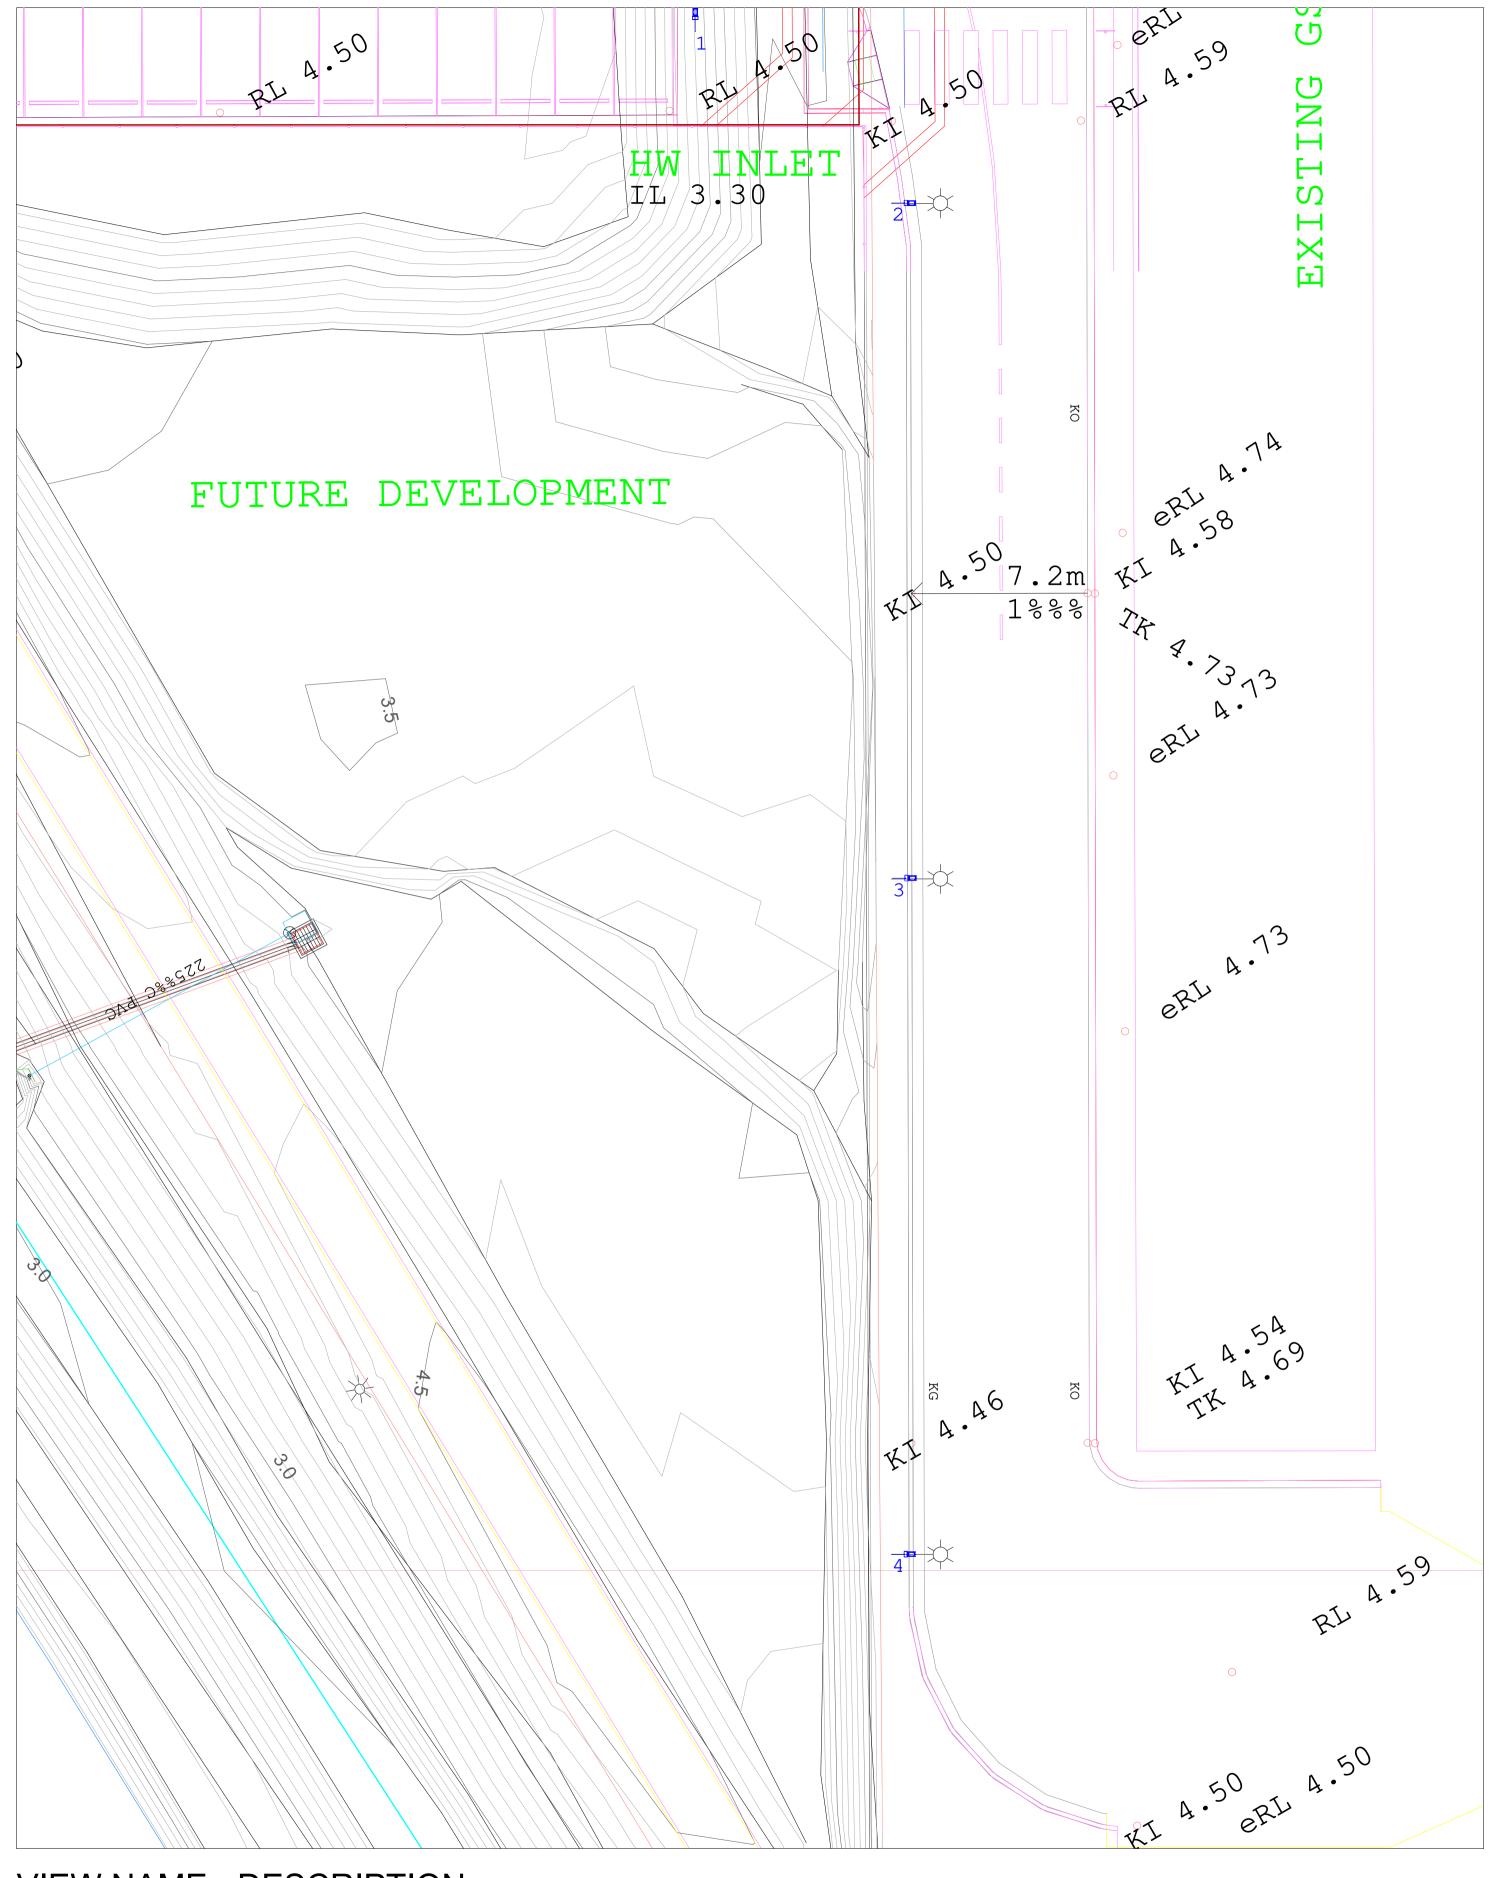

Symbol	Qty	Label	Description	Tag	LLF	Mounting Height	Arm
—— [[4	PO29- GP061-T3- W40	PO29-GP061-T3-W40 LIGMAN LIGHTING		0.800	8	0.5

VIEW NAME - DESCRIPTION Scale= 1: 153.85

REV	DESCRIPTION	DATE
1	ISSUE 1	04.09.2024

THE FOLLOWING VALUES ARE BASED ON EXACT CALCULATIONS ON CALIBRATED LAMPS, LUMINAIRES AND THEIR ARRANGEMENT. IN PRACTICE, GRADUAL DIVERGENCES CAN OCCUR. GUARANTEE

GUARANTEE
CLAIMS FOR LUMINAIRE DATA ARE EXCLUDED.
NORTHROP CONSULTING ENGINEERS AND THE LUMINAIRE
MANUFACTURERS ACCEPT NO LIABILITY FOR THE CONSEQUENTIAL
DAMAGE AND DAMAGE WHICH IS OCCASSIONED TO THE USER OF
THE THIRD PARTIES.

ALL DIMENSIONS MUST BE VERIFIED ON SITE. THIS DRAWING SHALL COMPLY WITH RELEVANT LOCAL AUTHORITY REGULATIONS. ANY VARIATIONS TO SPECIFICATIONS AND DRAWINGS MUST BE AUTHORISED BY THE DESIGNER. THESE DESIGNS, DRAWINGS AND SPECIFICATIONS ARE COPYRIGHT AND REMAIN THE PROPERTY OF NORTHROP CONSULTING ENGINEERS PTY LTD. THEY MUST NOT BE USED, REPRODUCED OR COPIED WHOLLY OR IN PART WITHOUT THE WRITTEN PERMISSION OF NORTHROP CONSULTING ENGINEERS PTY LTD.

DesignInc





Sydney

DRAWING TITLE
CONCEPT LIGHTING LAYOUT
SHEET 2

DRAWN CHECKED ISSUED

NL223031

AS PER DWG

PEW-L01.02 **1**

Level 11, 345 George Street, Sydney NSW 2000 Ph (02) 9241 4188 Fax (02) 9241 4324 Email: sydney@northrop.com.au ABN 81 094 433 100