
NOTES:

- 1. REFER TO DRAWING E-001 FOR LEGEND AND NOTES.
- 2. THIS DRAWING SHALL BE READ IN CONJUNCTION WITH ELECTRICAL SERVICES SECTION OF SPECIFICATION, ARCHITECTURAL DRAWINGS AND ALL OTHER RELEVANT SERVICES DRAWINGS.
- 3. ALL EQUIPMENT AND ACCESSORIES SHALL BE NEW UNLESS NOTED OTHERWISE.
- 4. FINAL POSITION OF ALL EQUIPMENT TO BE DETERMINED ON SITE PRIOR TO INSTALLATION. REFER TO ARCHITECTURAL DRAWINGS FOR CO-ORDINATION.
- 5. CONTRACTOR TO CONFIRM COMPLIANCE TO SUPPLIER/MANUFACTURER'S RECOMENDATIONS PRIOR TO INSTALLATION.

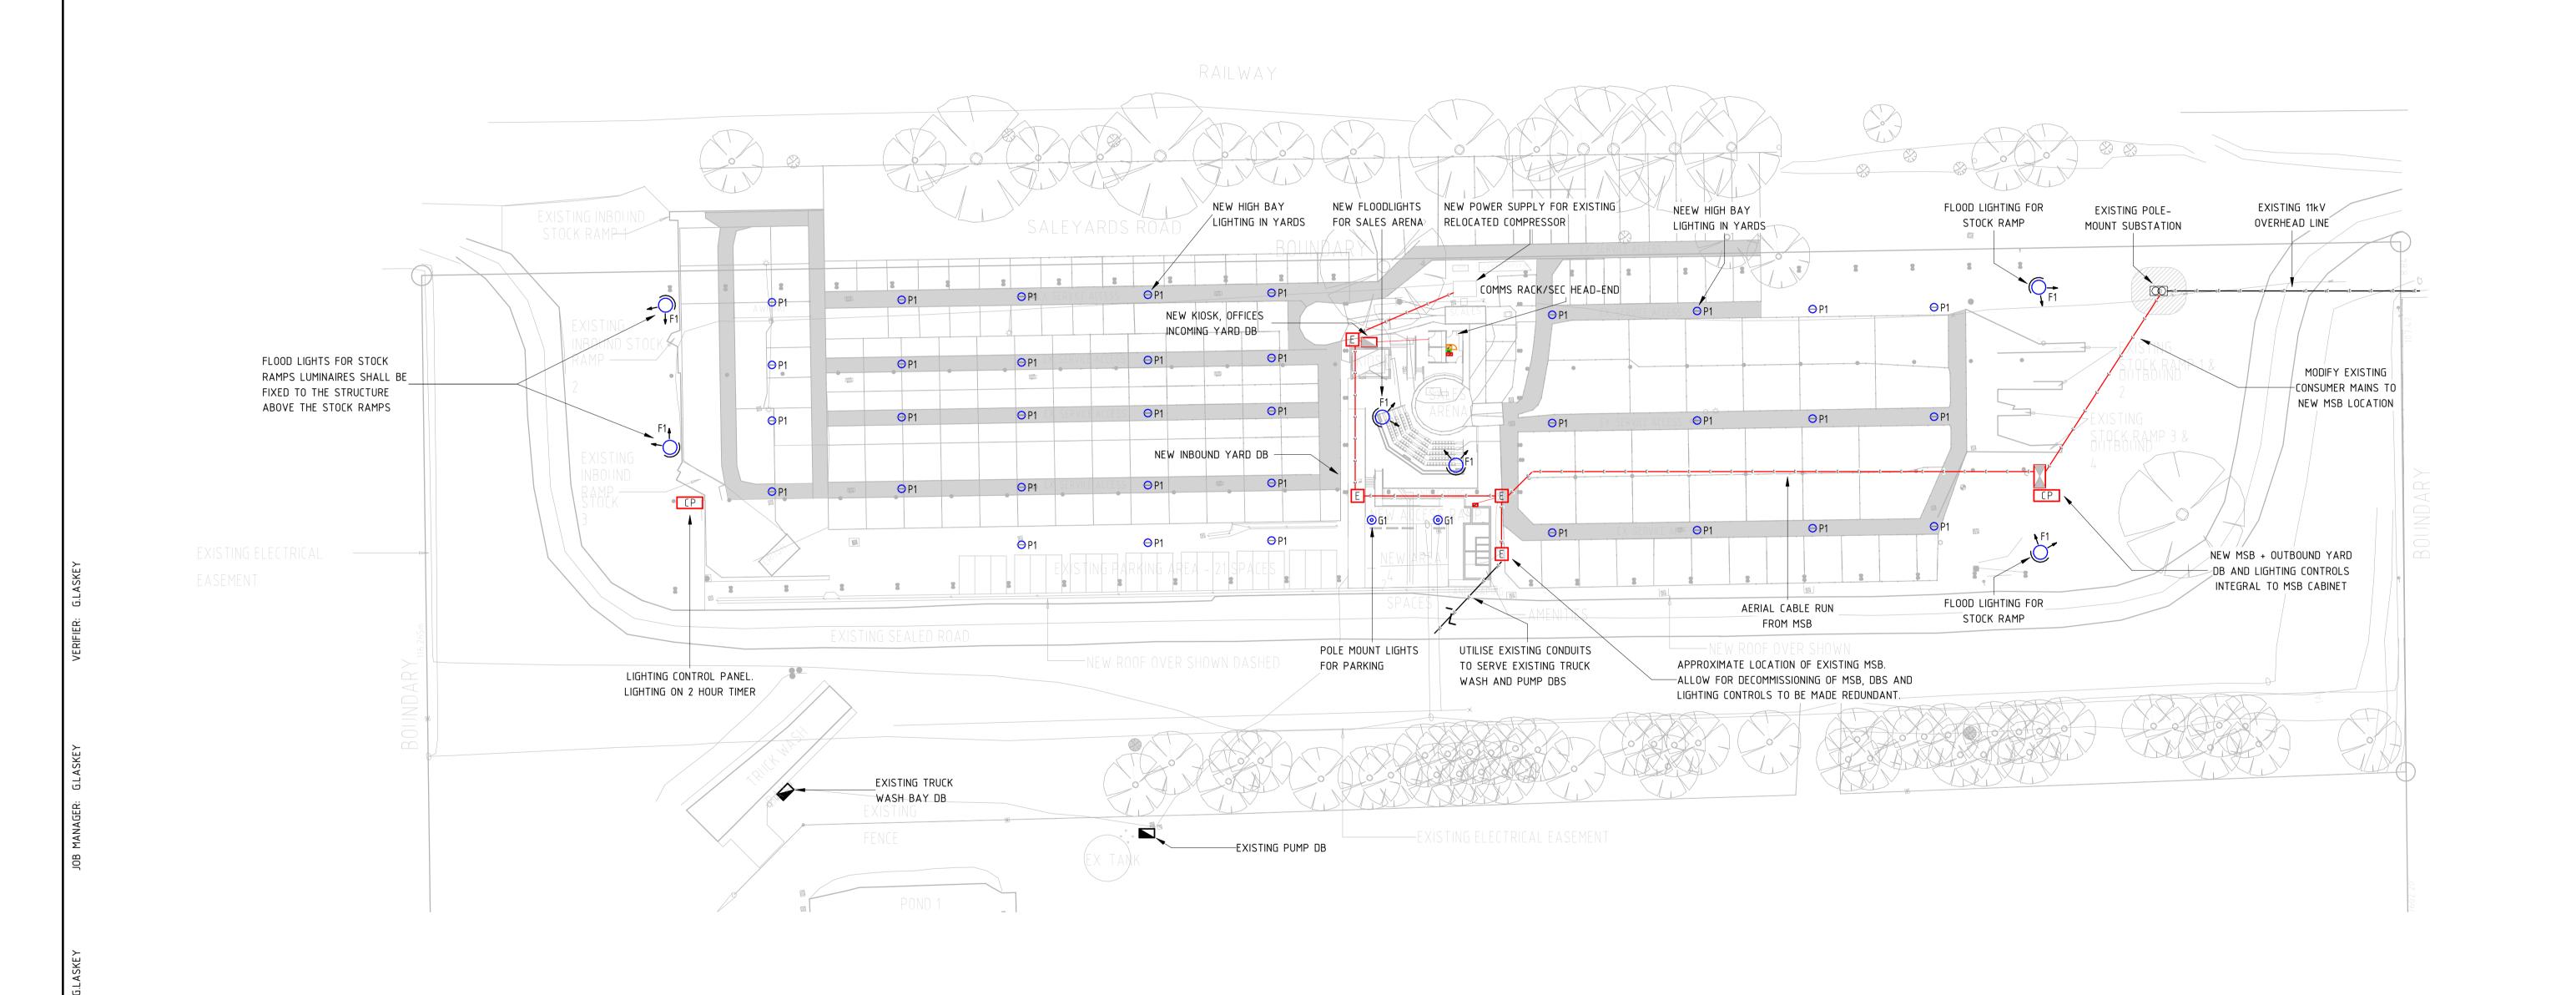


NOT FOR CONSTRUCTION

DESCRIPTION ISSUED VER'D APP'D DATE CLIENT TC | GL | GL | 30.01.23 1 D&C TENDER TC GL GL 25.07.23 2 D&C TENDER

KEMPSEY DRAWINGS NOT TO BE USED FOR CONSTRUCTION UNLESS

VERIFICATION SIGNATURE HAS BEEN ADDED

ARCHITECT DRAARCHITECTS THE COPYRIGHT OF THIS DRAWING REMAINS WITH NORTHROP CONSULTING ENGINEERS PTY LTD

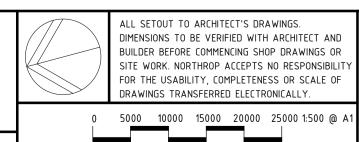



KEMPSEY REGIONAL SALEYARDS 42 SALEYARDS ROAD KEMPSEY **NSW 2440** Level 1, 215 Pacific Highway , Charlestown N.S.W. 2290 Ph (02) 4943 1777 Email: newcastle@northrop.com.au ABN 81 094 433 100

DRAWING TITLE **ELECTRICAL SERVICES** SITE PLAN CONCEPT

NL223940 DRAWING NUMBER REVISION

ESK01 DRAWING SHEET SIZE = A1