


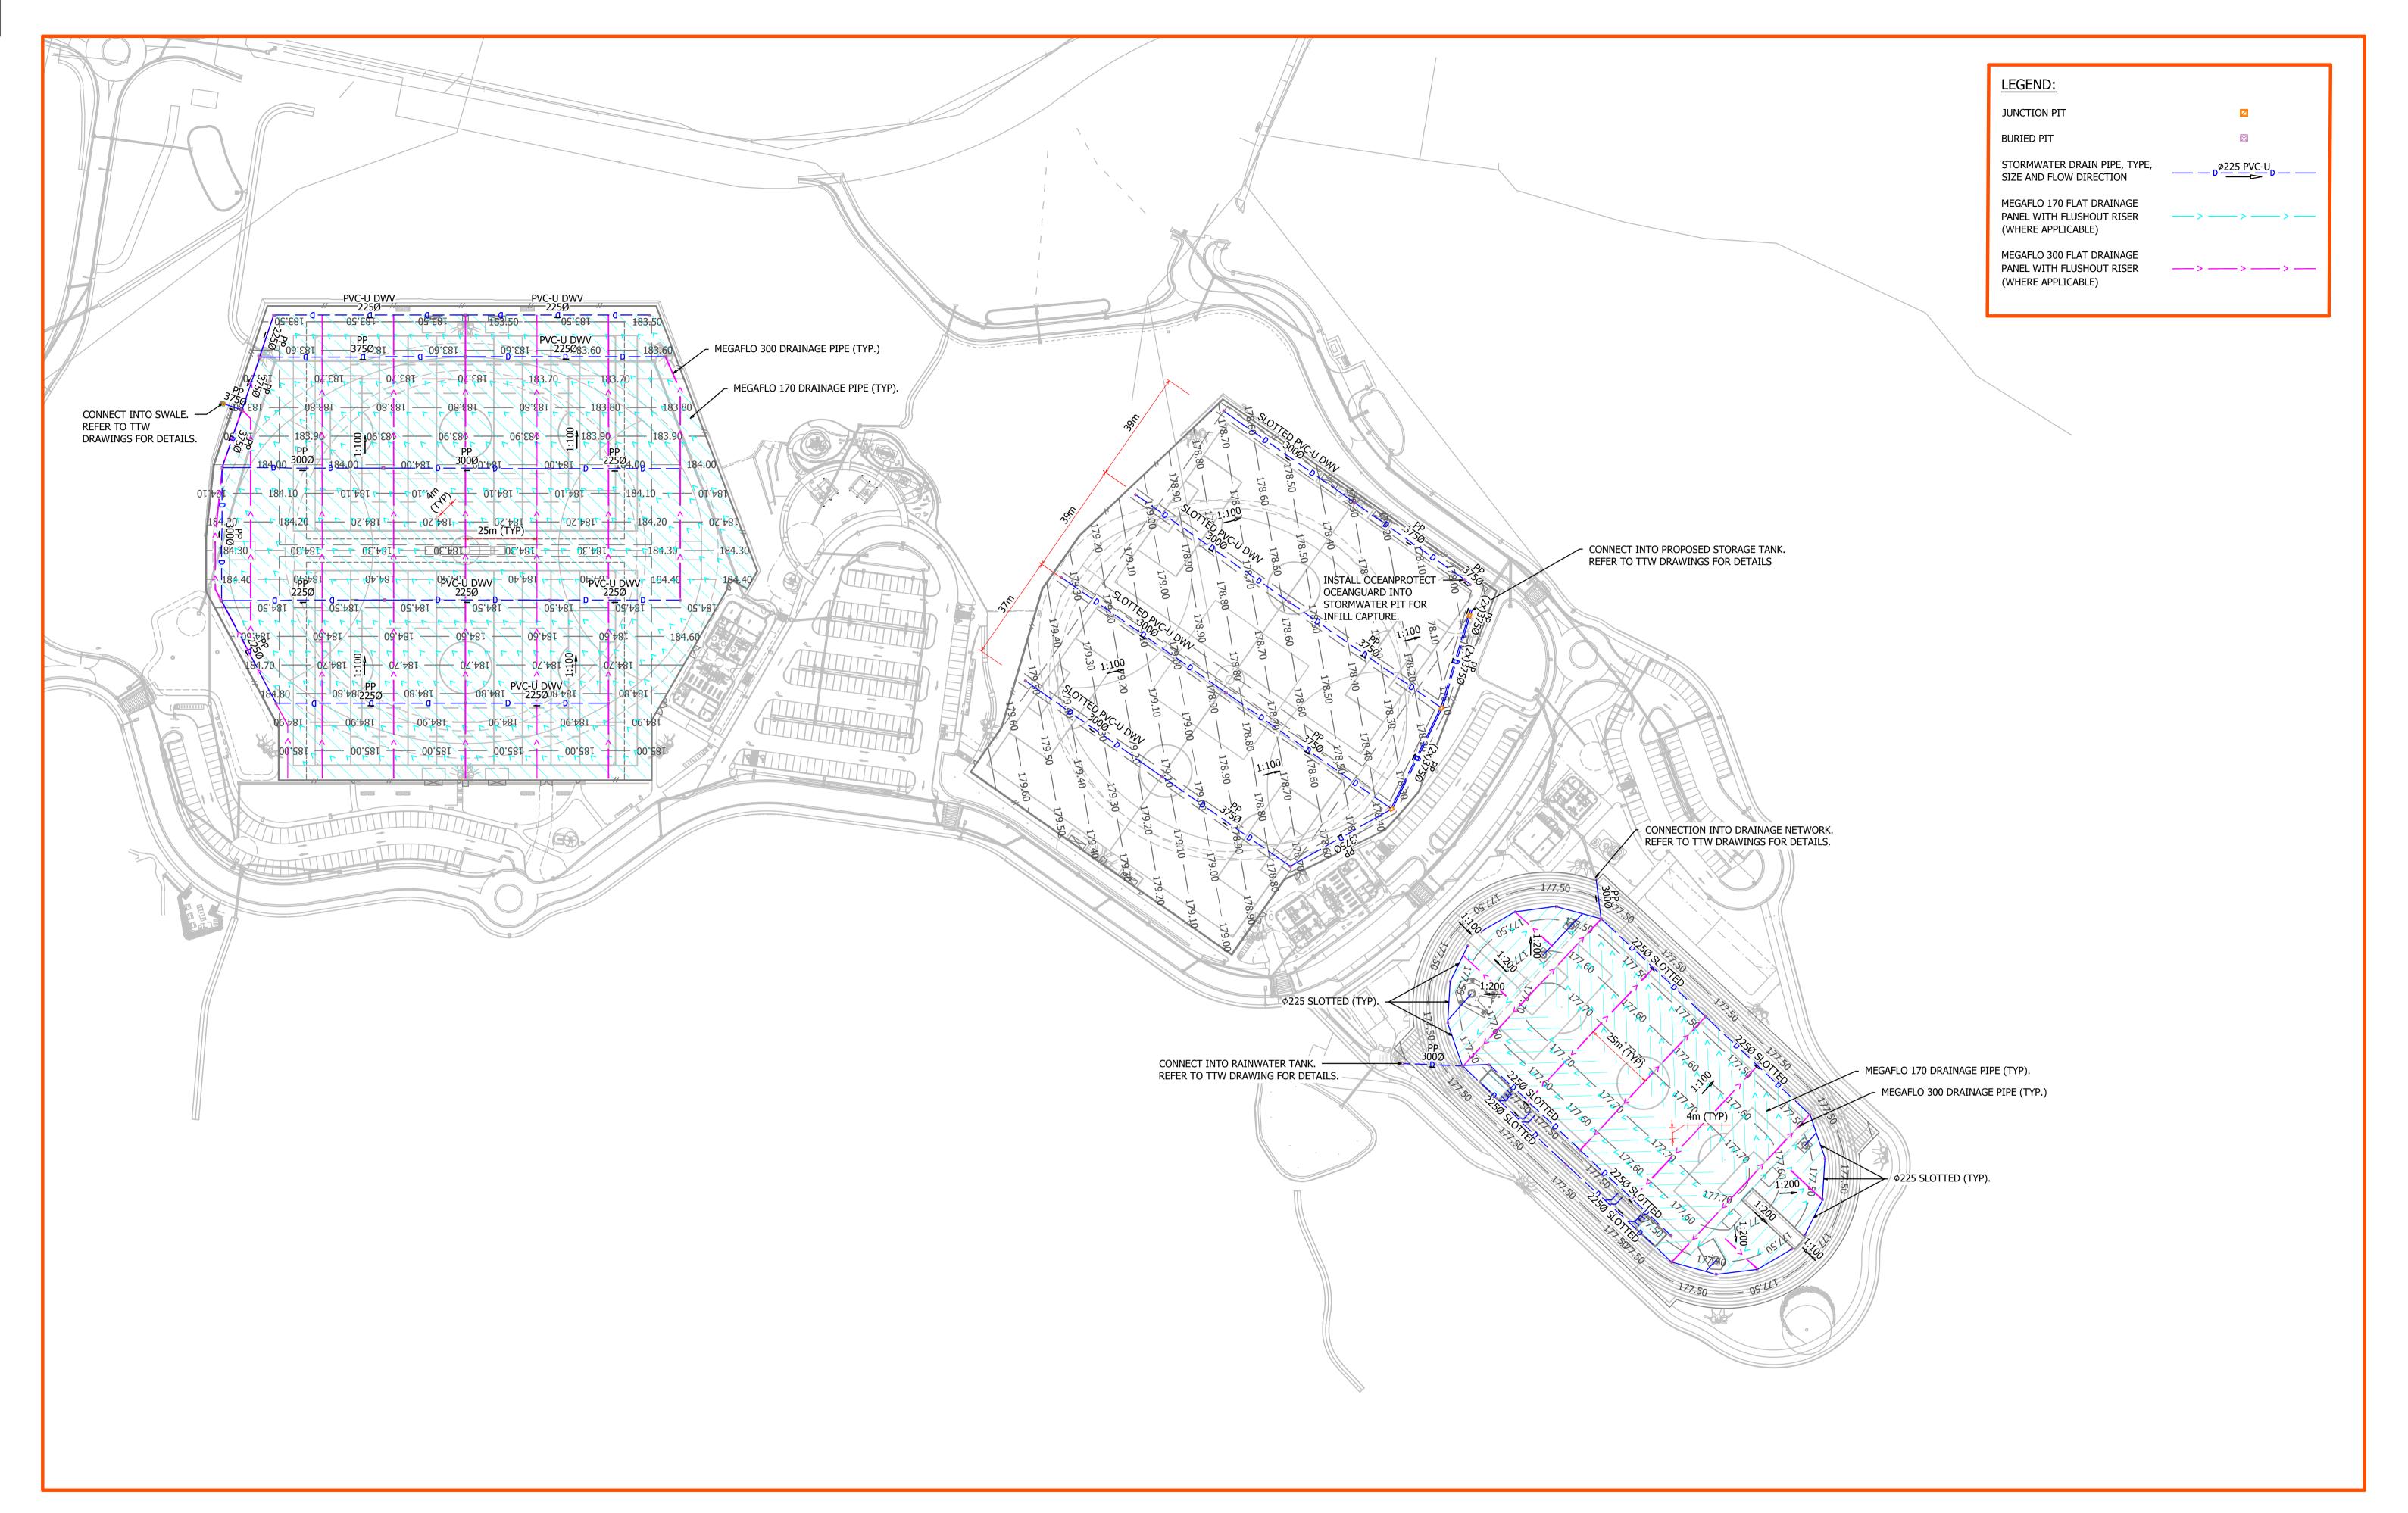



03/07/24 DRAWN BY: PJE | SCALE: 1:1000 @ A1 REV: I SKETCH NO: SE_10681_SKT_001




SPORTENGTM PROJECT: WESTLEIGH PARK


PROJECT NO: 10681-00 SKETCH TITLE: STORMWATER DRAINAGE LAYOUT PLAN



SKETCH NO: SE_10681_SKT_002 REV: L DATE: 26/06/24 DRAWN BY: PJE

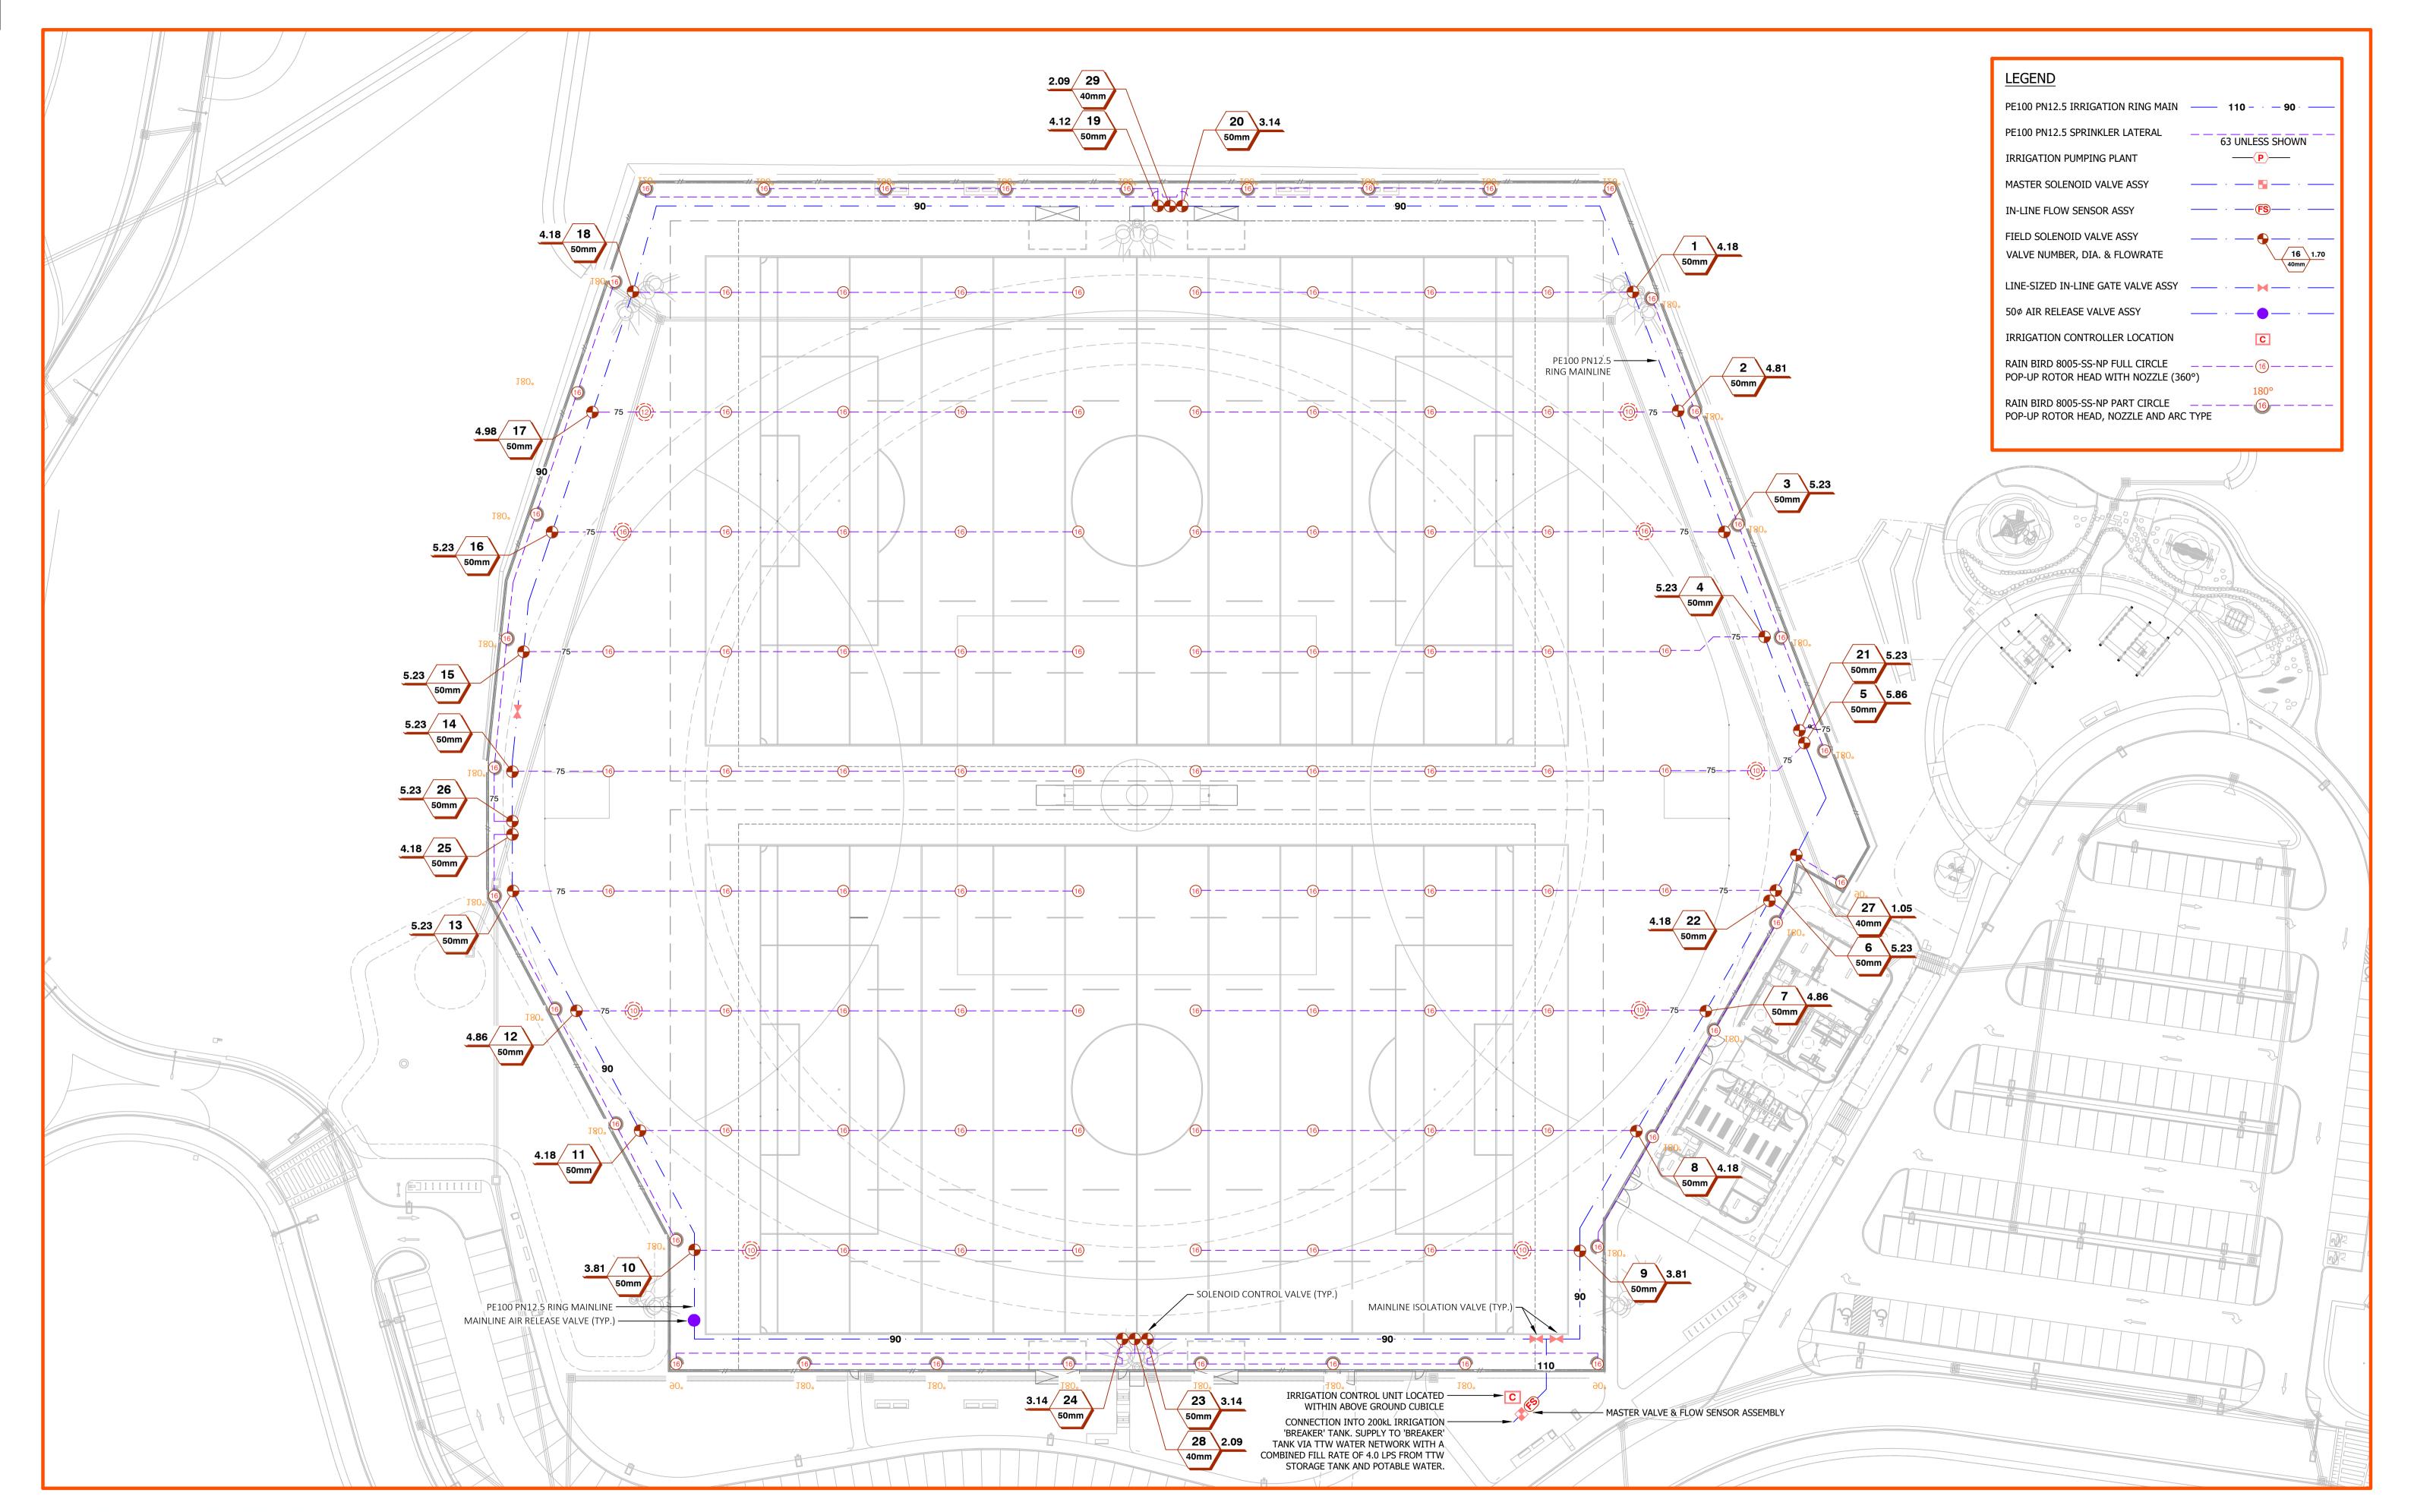

SPORTENGTM PROJECT: WESTLEIGH PARK

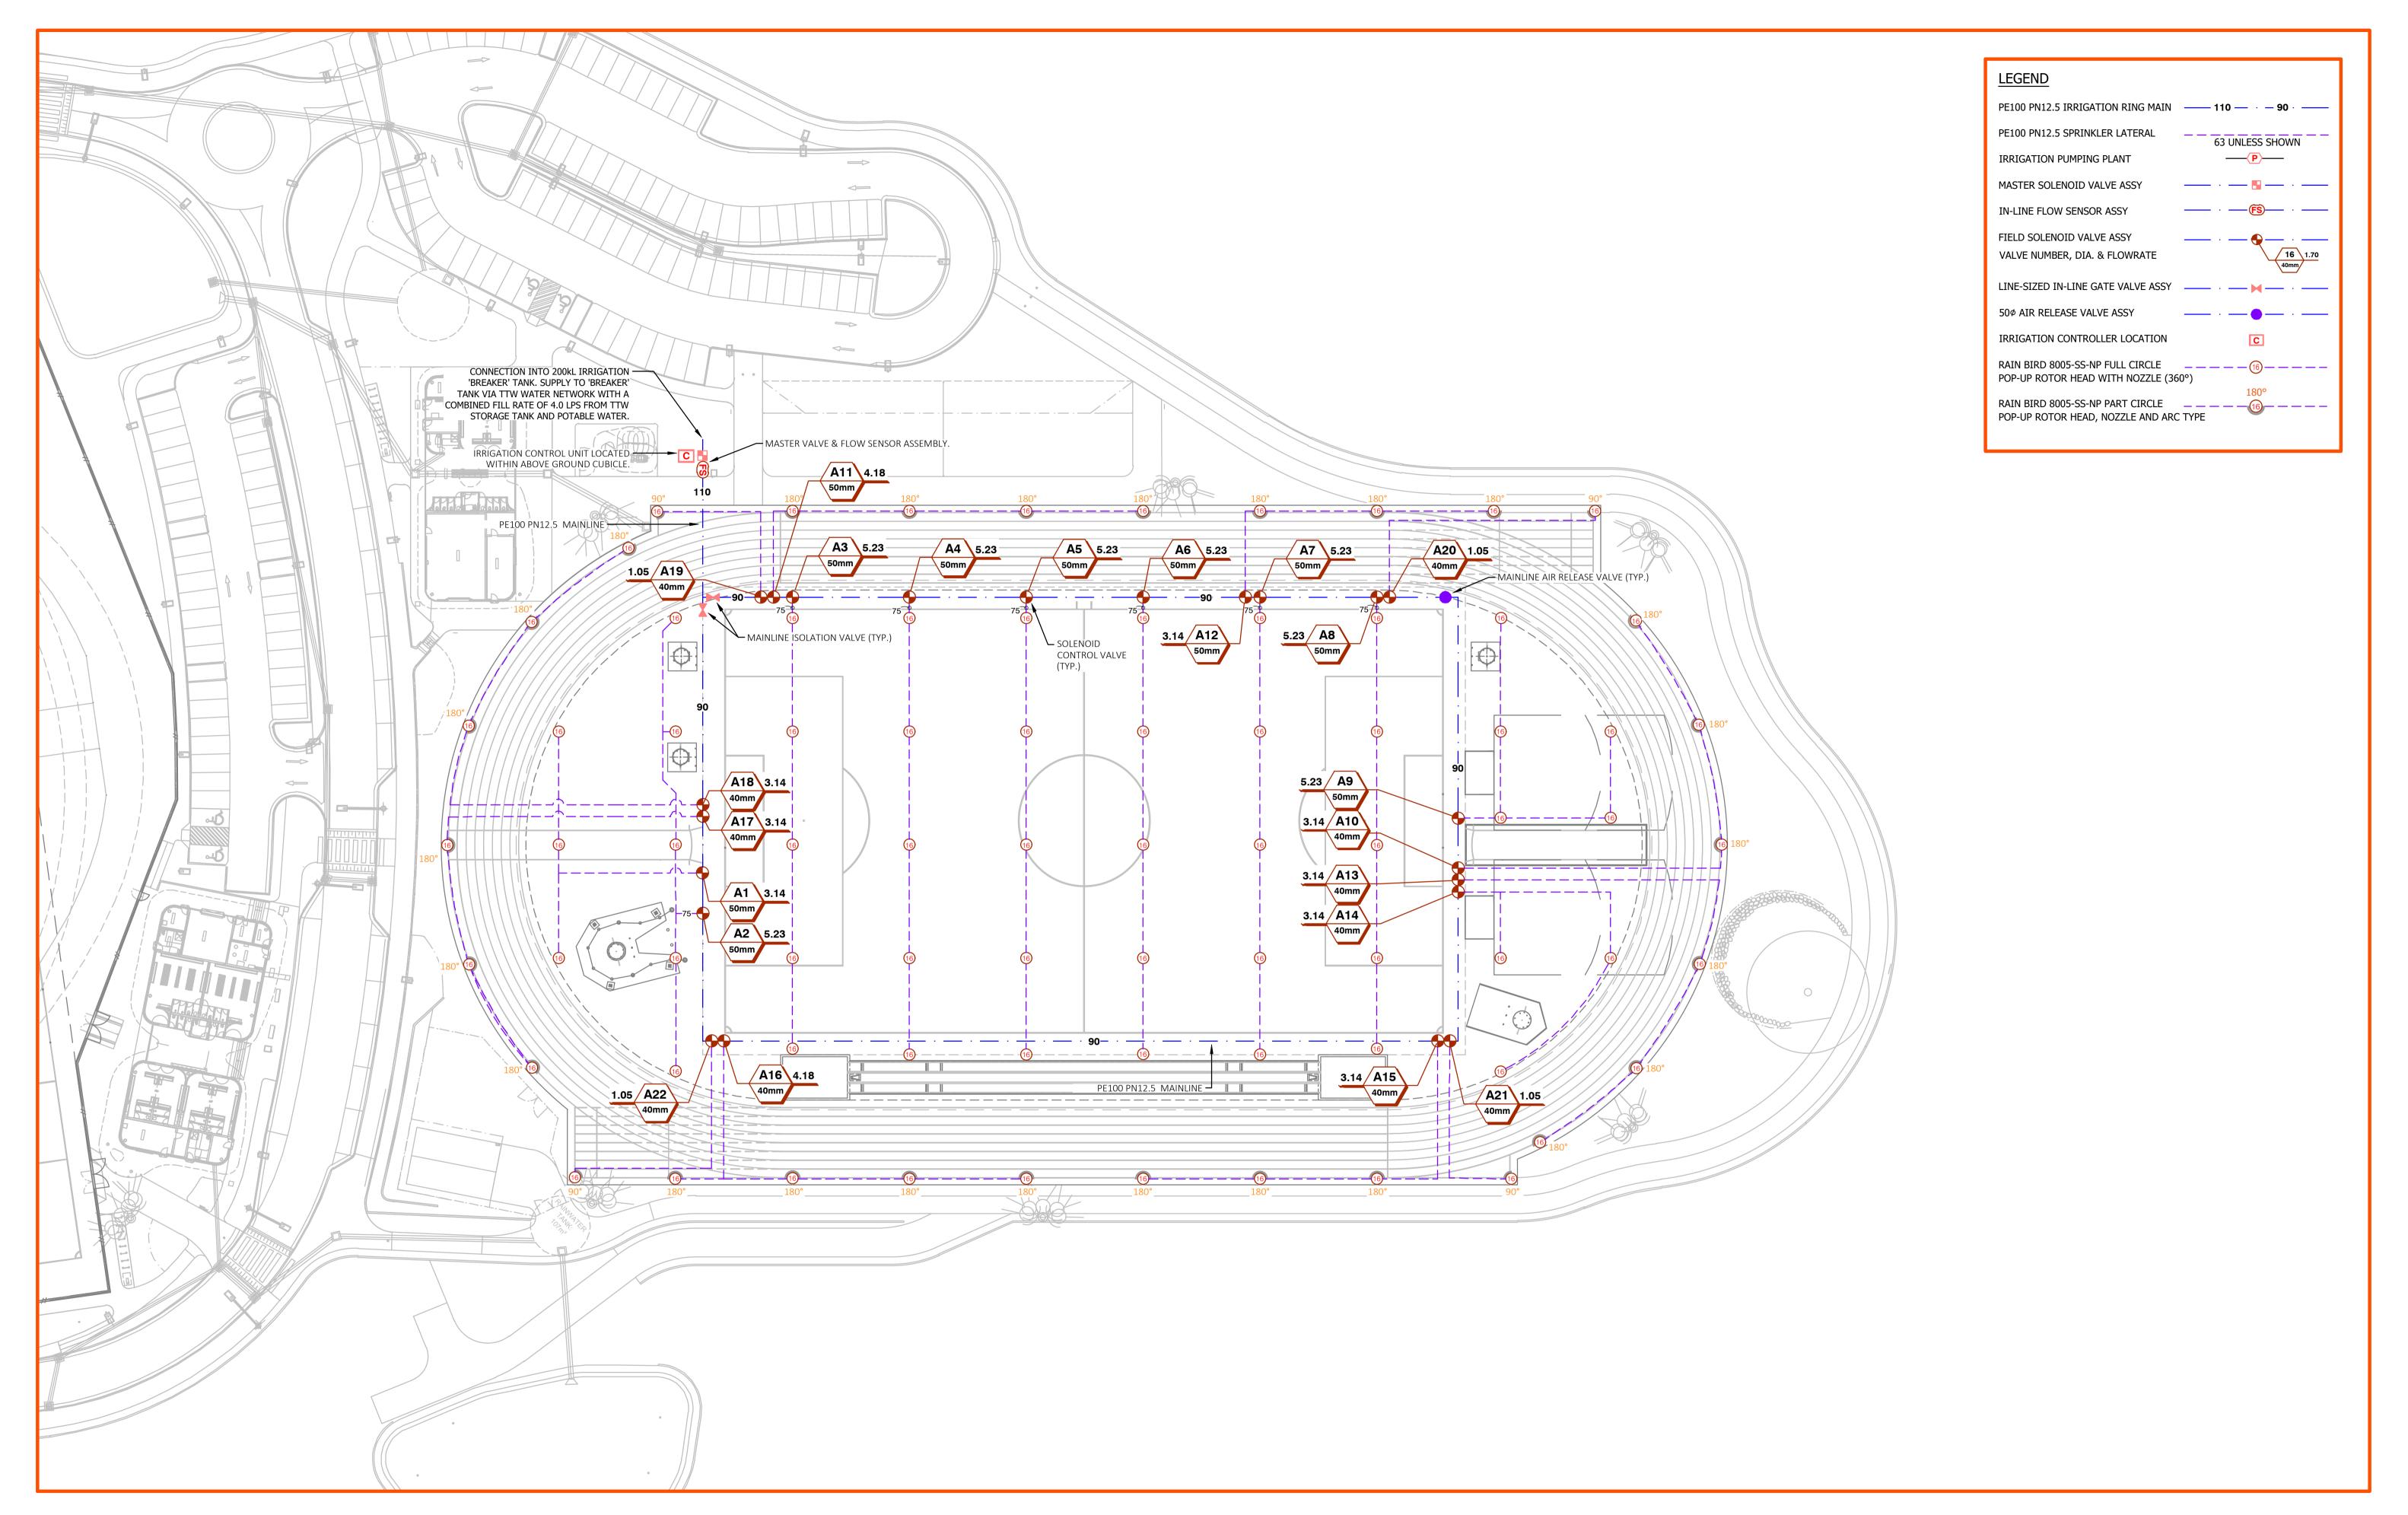

SPORTENGTM PROJECT: WESTLEIGH PARK

PROJECT NO: 10681-00 | SKETCH TITLE: IRRIGATION SKETCH - ATHLETICS FIELD