

CLIENT



STRUCTURAL, CIVIL AND SERVICES ENGINEER

aurecon

ARCADIA

PARTNERSHIP

DISCLAIMER

USE FIGURED DIMENSIONS ONLY DO NOT SCALE FROM DRAWING CHECK & VERIFY ALL DIMENSIONS ON SITE BEFORE FABRICATION OR SET OUT.

This drawing is diagrammatic and shows general arrangements.
Any information involving measurement of the works shall be taken from documented dimensions on the architectural and structural drawings, workshop drawings by others and conditions on site. The works shall comply with the contract conditions and Statutory Regulations.

All rights reserved. This work is copyright and cannot be reproduced or copied in any form or by any means graphic, permission of Populous architects in association. Any licence, expressed or implied, to use this document for any purpose whatsoever is restricted to the terms of the agreement or implied agreement between Populous and the instructing party.

THIS DRAWING IS AN UNCONTROLLED COPY. UNLESS NOTED OTHERWISE

EV	DESCRIPTION	DATE
1	80% SCHEMATIC DESIGN	23/12/2021
2	100% SCHEMATIC DESIGN	11/02/2022
3	100% SD ISSUE - REVISION D	11/04/2022
4	DA SUBMISSION	24/06/2022
5	DA AMENDMENT SUBMISSION	11/08/2023

POPULOUS

ABN 55 072 891 993 **BRISBANE**469 Adelaide St
GPO Box 5290
Brisbane QLD 4000
AUSTRALIA
t: +61(0) 7 3838 7900
f: +61(0) 7 3839 9188

www.populous.com E-mail: sport.au@populous.com

PROJECT
ST. GEORGE ILLAWARRA DRAGONS COMMUNITY
& HIGH PERFORMANCE TRAINING CENTRE

Fairy Meadow, Wollongong NSW

SHEET TITLE

SITE PLAN

EXISTING CONDITION / DEMOLITION

	PROJECT NI 7762	JMBER	REVIEWED GH	
	COORDINATED POP		APPROVED AB	
	1:750	5 @ A1	NORTH POINT	
	PHASE SD	AD-18-000	-	REVISION 5



CLIENT



STRUCTURAL, CIVIL AND SERVICES ENGINEER

aurecon

LANDSCAPE ARCHITECT

ARCADIA

COST CONSULTANT



DISCLAIMER

USE FIGURED DIMENSIONS ONLY DO NOT SCALE FROM DRAWING CHECK & VERIFY ALL DIMENSIONS ON SITE BEFORE FABRICATION OR SET OUT.

This drawing is diagrammatic and shows general arrangements.
Any information involving measurement of the works shall be taken from documented dimensions on the architectural and structural drawings, workshop drawings by others and conditions on site. The works shall comply with the contract conditions and Statutory Regulations.

All rights reserved. This work is copyright and cannot be reproduced or copied in any form or by any means graphic, permission of Populous architects in association. Any licence, expressed or implied, to use this document for any purpose whatsoever is restricted to the terms of the agreement or implied agreement between Populous and the instructing party.

THIS DRAWING IS AN UNCONTROLLED COPY. UNLESS NOTED OTHERWISE

REV	DESCRIPTION	DATE			
1	80% SCHEMATIC DESIGN	23/12/2021			
2	100% SCHEMATIC DESIGN	11/02/2022			
3	100% SD ISSUE - REVISION B	18/02/2022			
4	100% SD ISSUE - REVISION C	22/02/2022			
5	100% SD ISSUE - REVISION D	11/04/2022			
6	DA SUBMISSION	24/06/2022			
7	DA AMENDMENT SUBMISSION	11/08/2023			
8	DA AMENDMENT SUBMISSION	21/02/2024			
9	DA UPDATE	19/04/2024			

POPULOUS

ABN 55 072 891 993 **BRISBANE**469 Adelaide St
GPO Box 5290
Brisbane QLD 4000
AUSTRALIA
t: +61(0) 7 3838 7900
f: +61(0) 7 3839 9188

www.populous.com E-mail: sport.au@populous.com


PROJECT
ST. GEORGE ILLAWARRA DRAGONS COMMUNITY
& HIGH PERFORMANCE TRAINING CENTRE


Fairy Meadow, Wollongong NSW


SHEET TITLE


SITE PLAN PROPOSED

	PROJECT NUMBER 7762		REVIEWED GH	
COORDINATED POP		ED	APPROVED AB	
	SCALE 100% 1:750	5 @ A1	NORTH POINT	(
	PHASE DD	AD-16-010	· · ·	REVISION 9

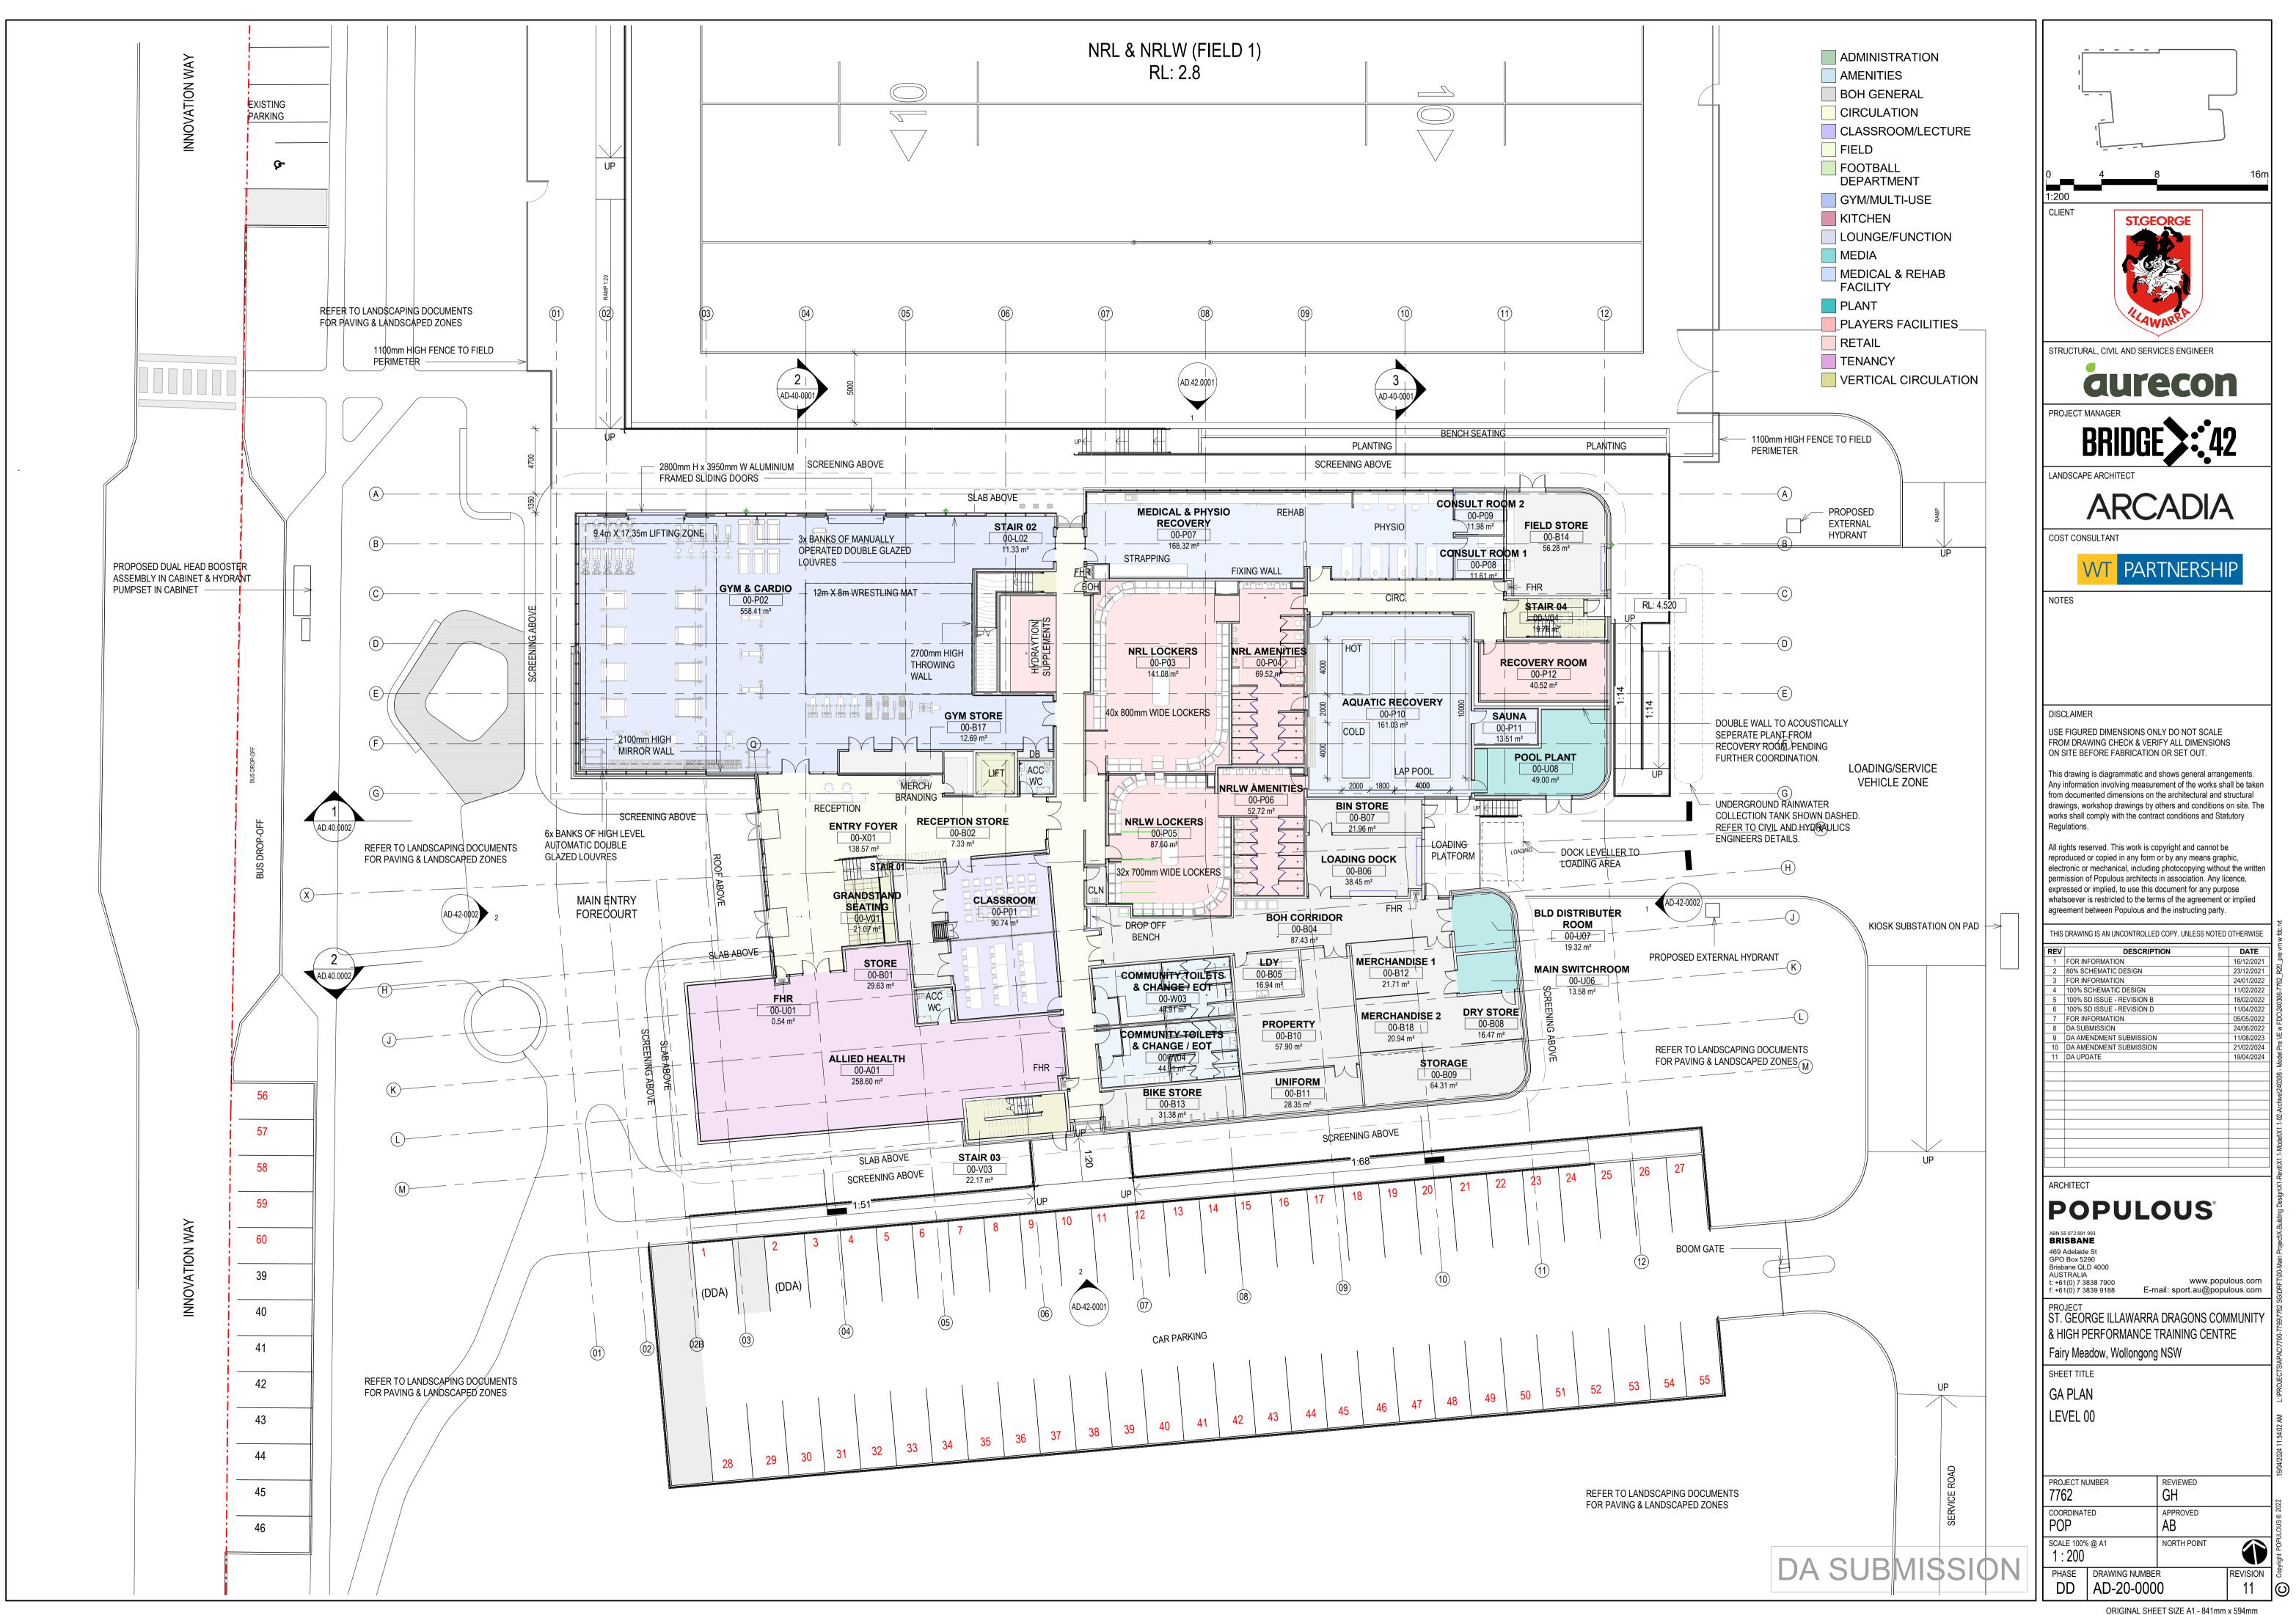

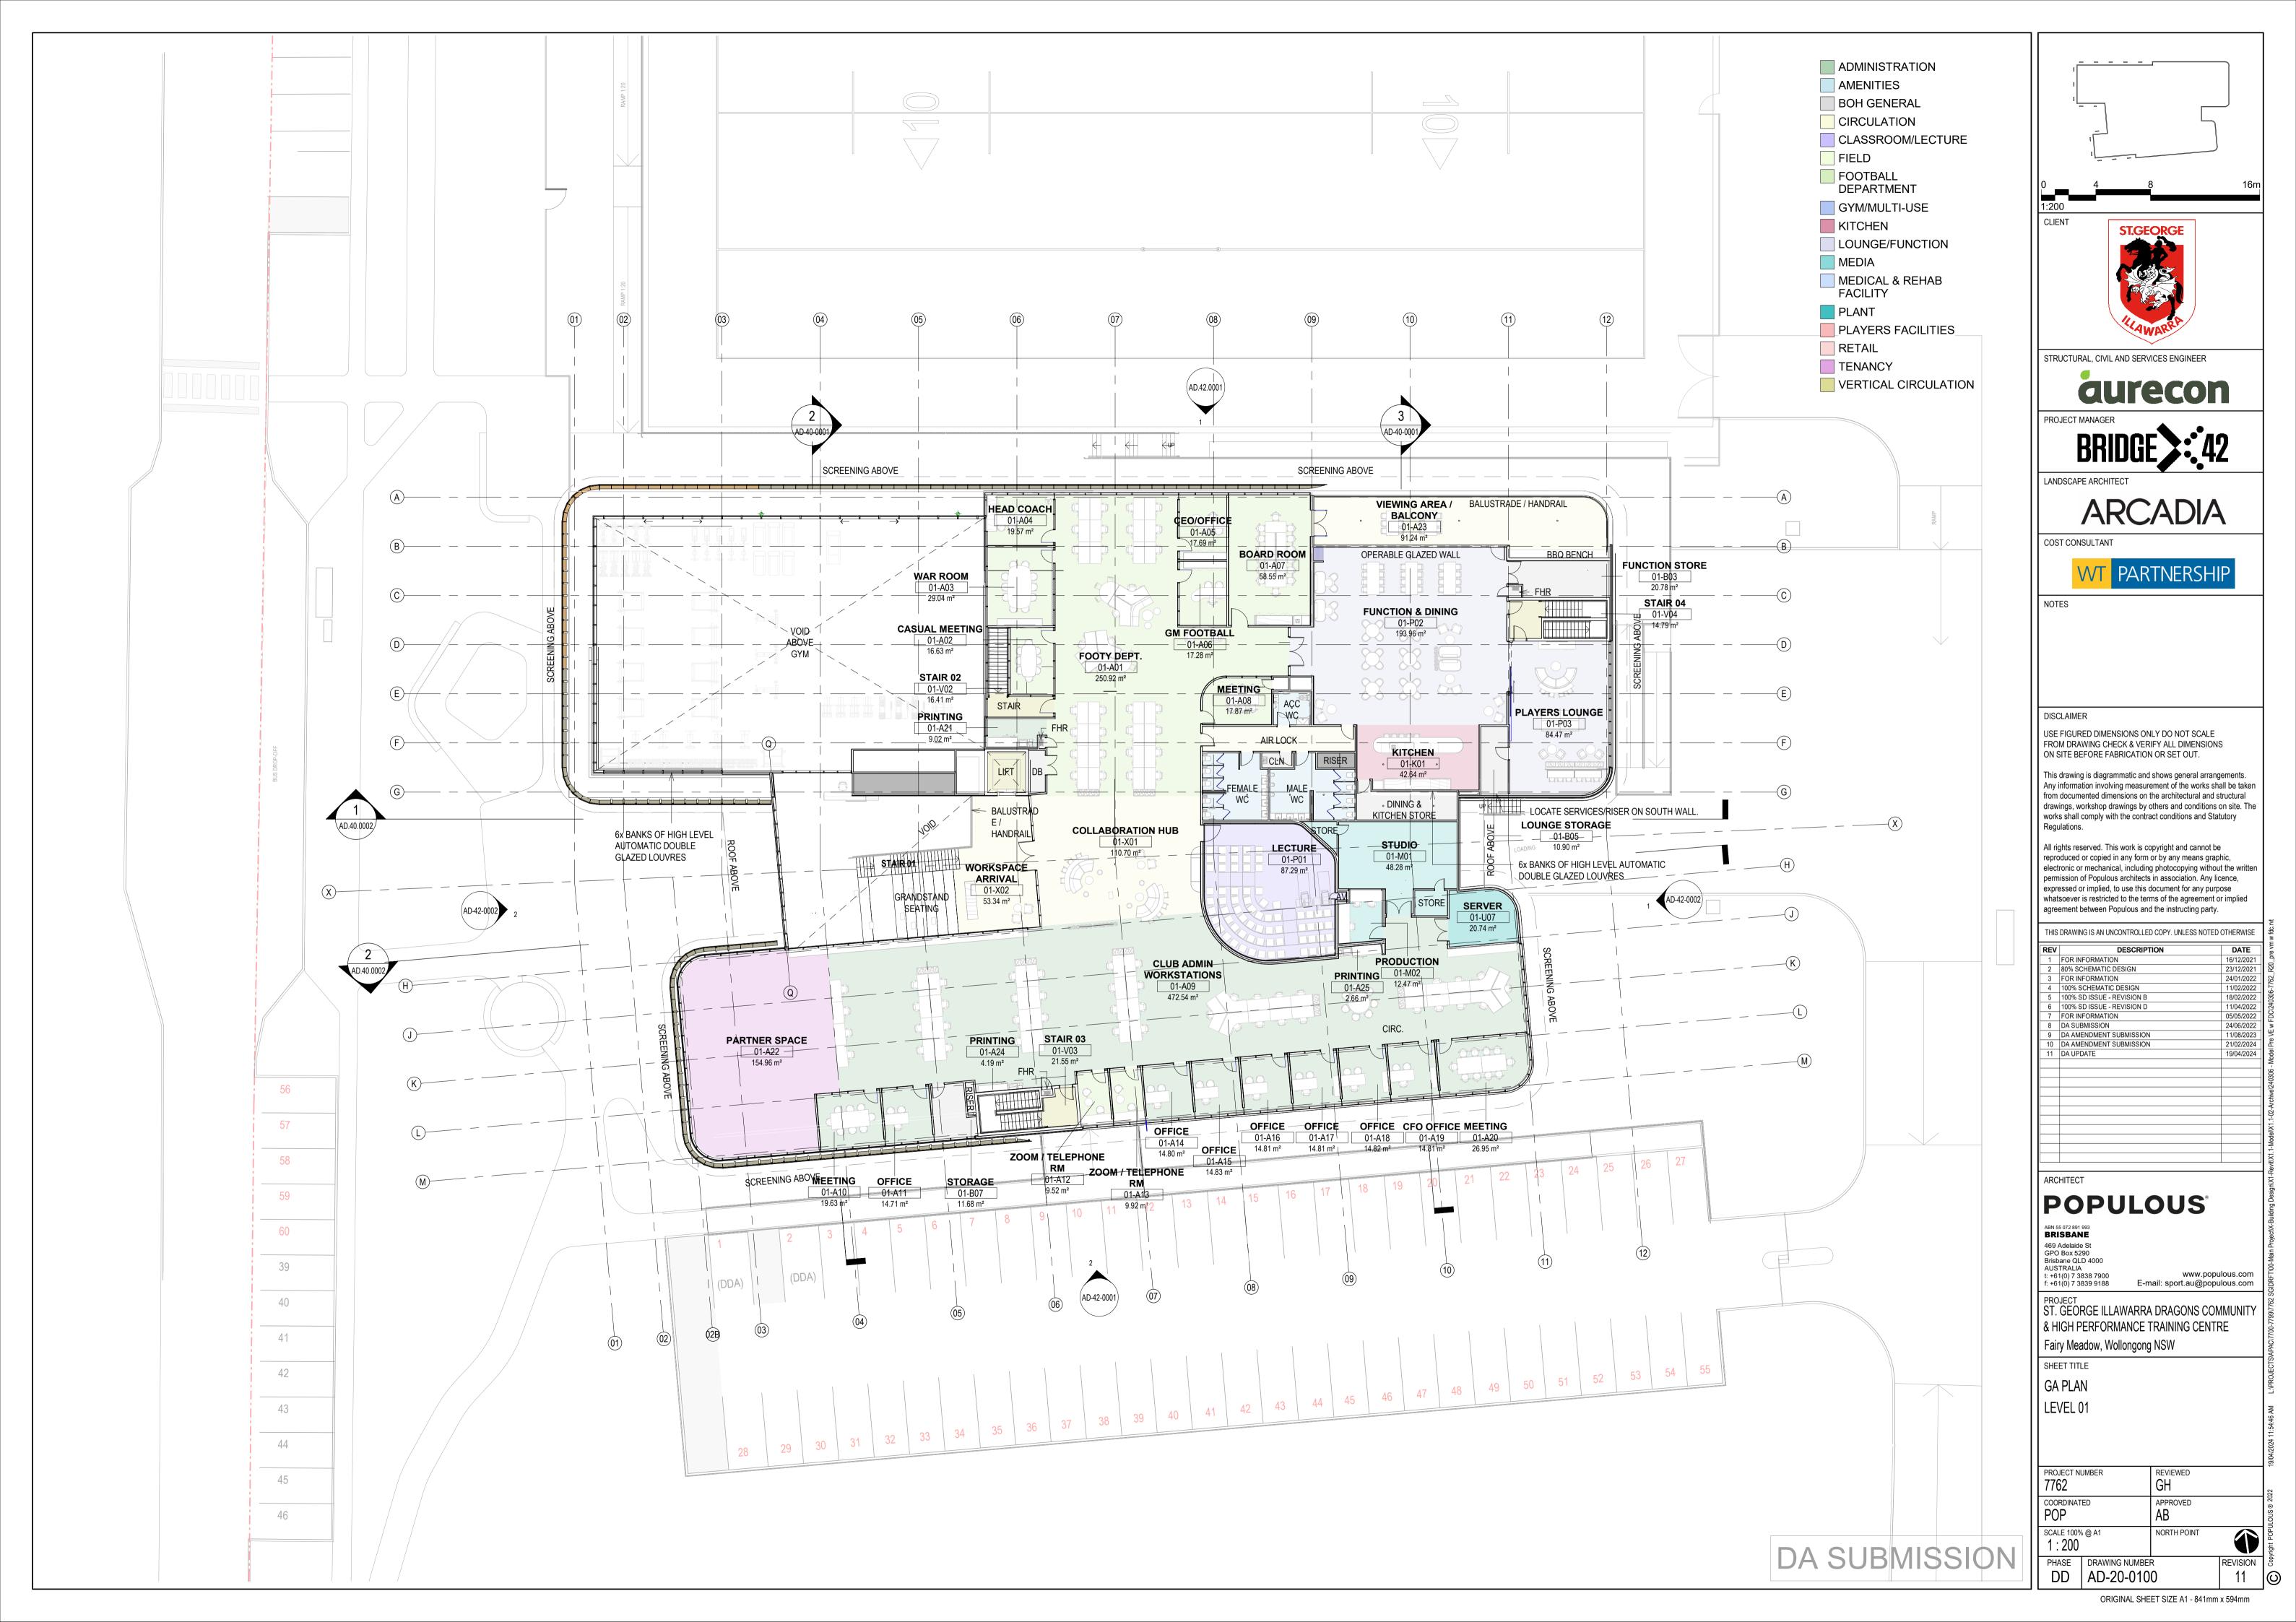

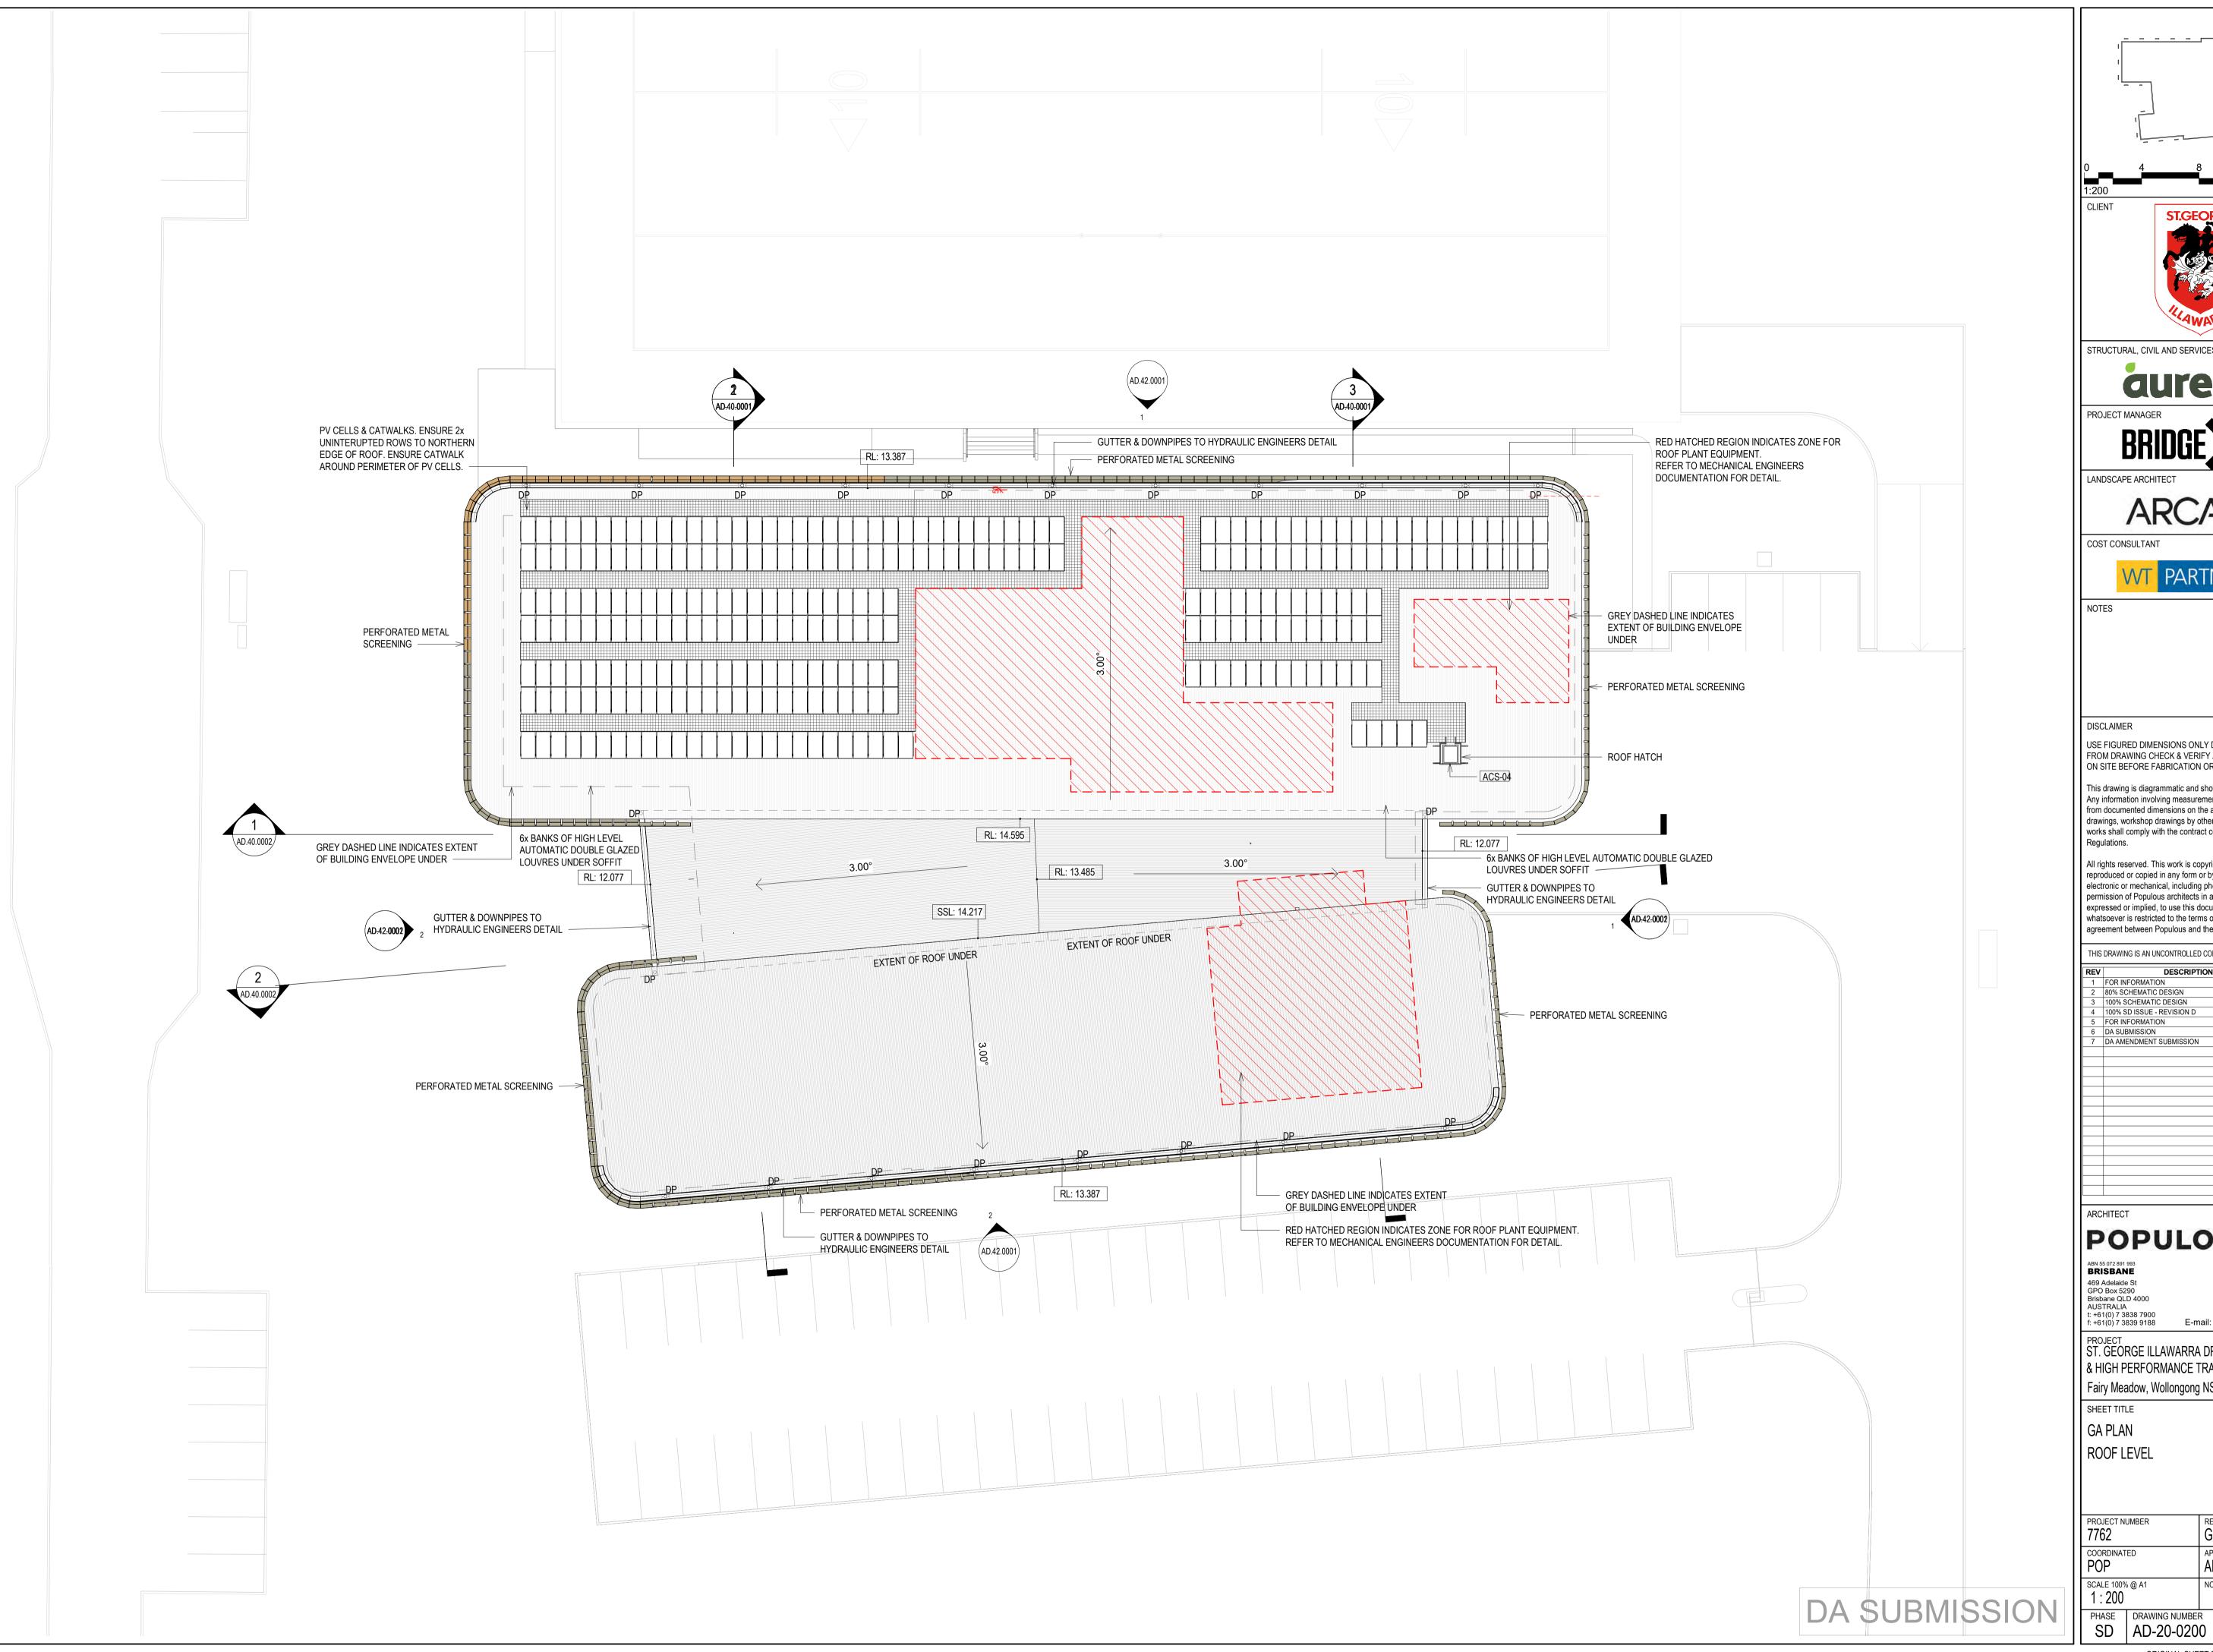

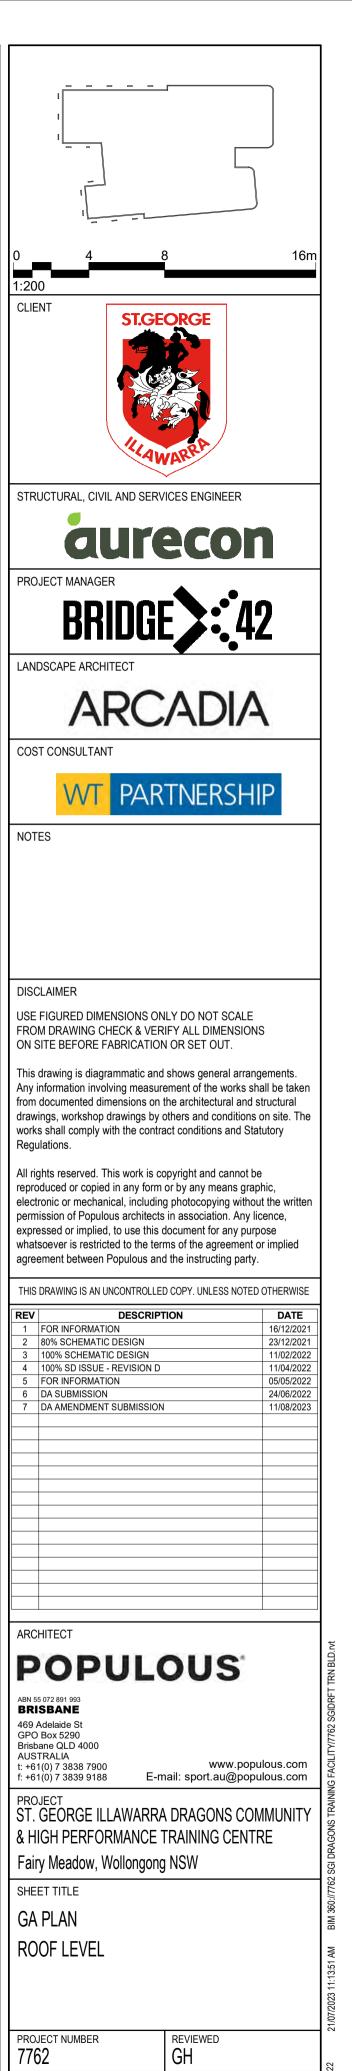


REVISION


APPROVED

NORTH POINT

COORDINATED


3 BUILDING SECTION - GRIDS 10-11

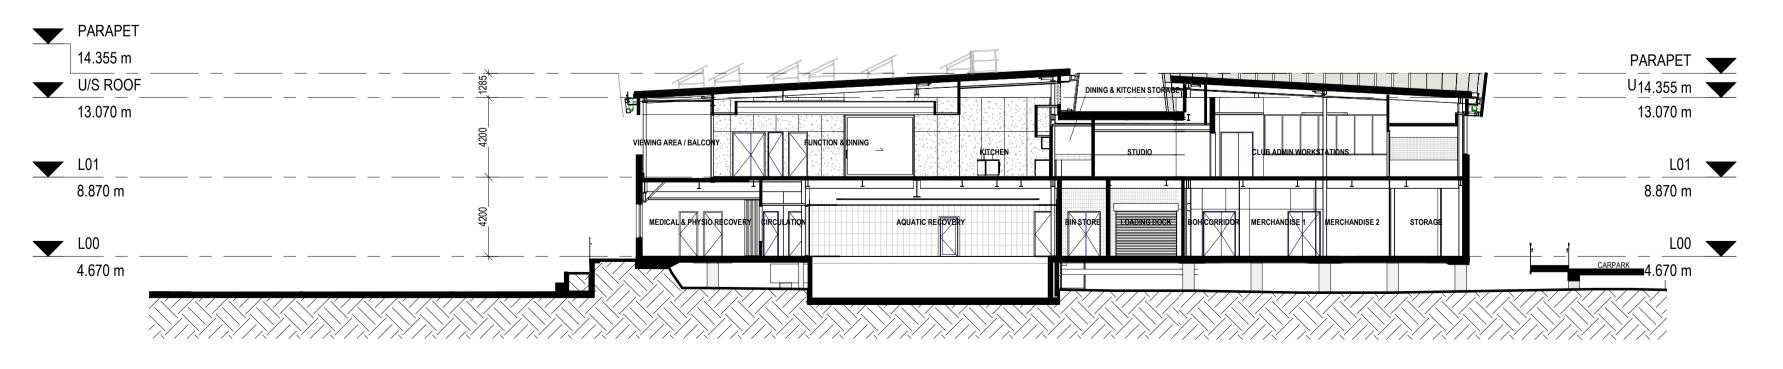

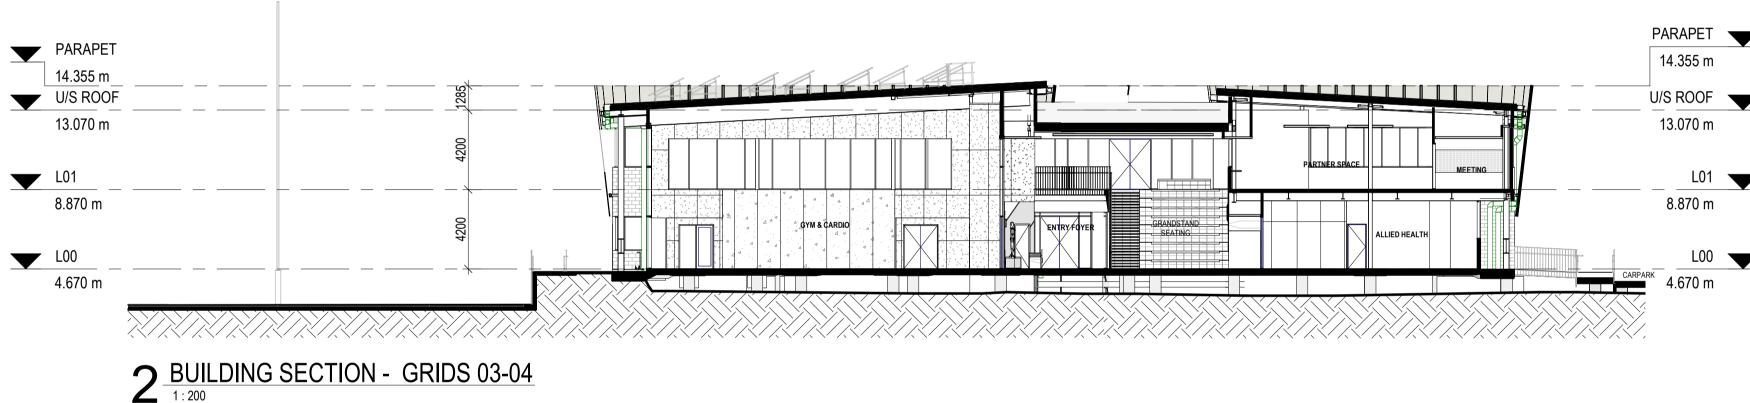

PARAPET ___ PARAPET U/S ROOF U/S ROOF L00

1 BUILDING SECTION - GRID X

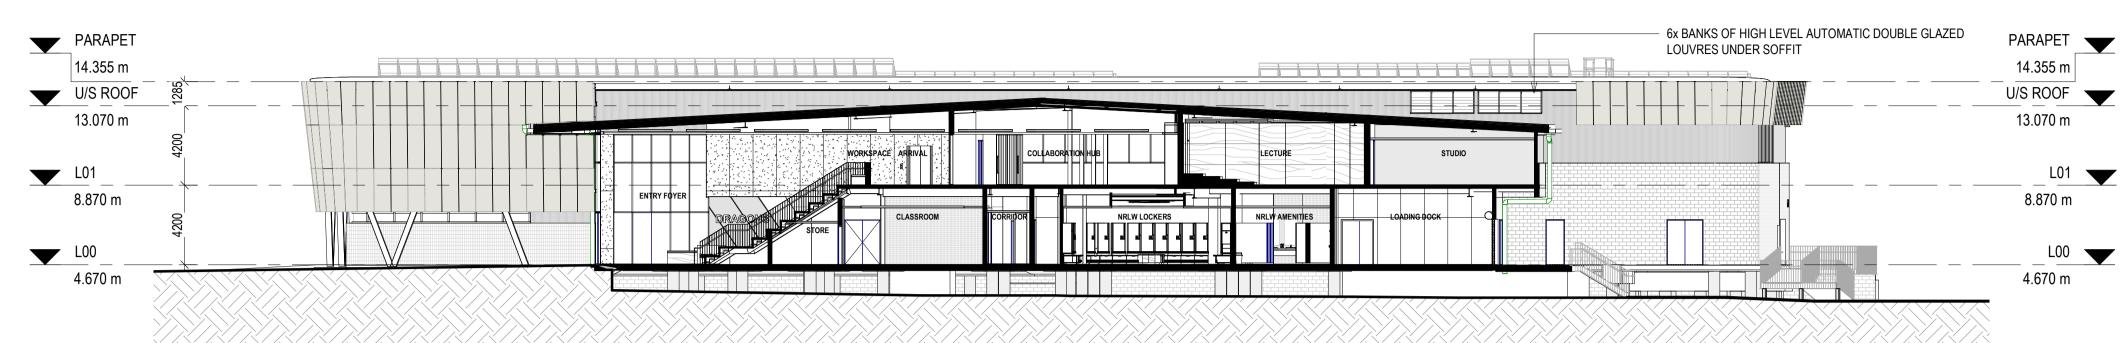


electronic or mechanical, including photocopying without the writte permission of Populous architects in association. Any licence, expressed or implied, to use this document for any purpose whatsoever is restricted to the terms of the agreement or implied agreement between Populous and the instructing party. THIS DRAWING IS AN UNCONTROLLED COPY. UNLESS NOTED OTHERWISE DESCRIPTION 80% SCHEMATIC DESIGN 2 FOR INFORMATION 100% SCHEMATIC DESIGN 4 100% SD ISSUE - REVISION D 5 DA SUBMISSION DA AMENDMENT SUBMISSION DA AMENDMENT SUBMISSION **POPULOUS** ABN 55 072 891 993 BRISBANE 469 Adelaide St GPO Box 5290 Brisbane QLD 4000 AUSTRALIA t: +61(0) 7 3838 7900 f: +61(0) 7 3839 9188 www.populous.com E-mail: sport.au@populous.com PROJECT ST. GEORGE ILLAWARRA DRAGONS COMMUNITY & HIGH PERFORMANCE TRAINING CENTRE Fairy Meadow, Wollongong NSW SHEET TITLE GA SECTIONS GRID X, GRIDS 03-04 & GRIDS 07-08 PROJECT NUMBER REVIEWED 7762 GH COORDINATED APPROVED SCALE 100% @ A1 NORTH POINT 1:200 DA SUBMISSION PHASE DRAWING NUMBER REVISION 8 DD AD-40-0001


STRUCTURAL, CIVIL AND SERVICES ENGINEER aurecon LANDSCAPE ARCHITECT ARCADIA COST CONSULTANT PARTNERSHIP DISCLAIMER USE FIGURED DIMENSIONS ONLY DO NOT SCALE FROM DRAWING CHECK & VERIFY ALL DIMENSIONS ON SITE BEFORE FABRICATION OR SET OUT. This drawing is diagrammatic and shows general arrangements. Any information involving measurement of the works shall be taken from documented dimensions on the architectural and structural drawings, workshop drawings by others and conditions on site. The works shall comply with the contract conditions and Statutory All rights reserved. This work is copyright and cannot be reproduced or copied in any form or by any means graphic, 23/12/2021 24/01/2022 11/02/2022 11/04/2022 24/06/2022 11/08/2023 21/02/2024

CLIENT

NOTES

Regulations.

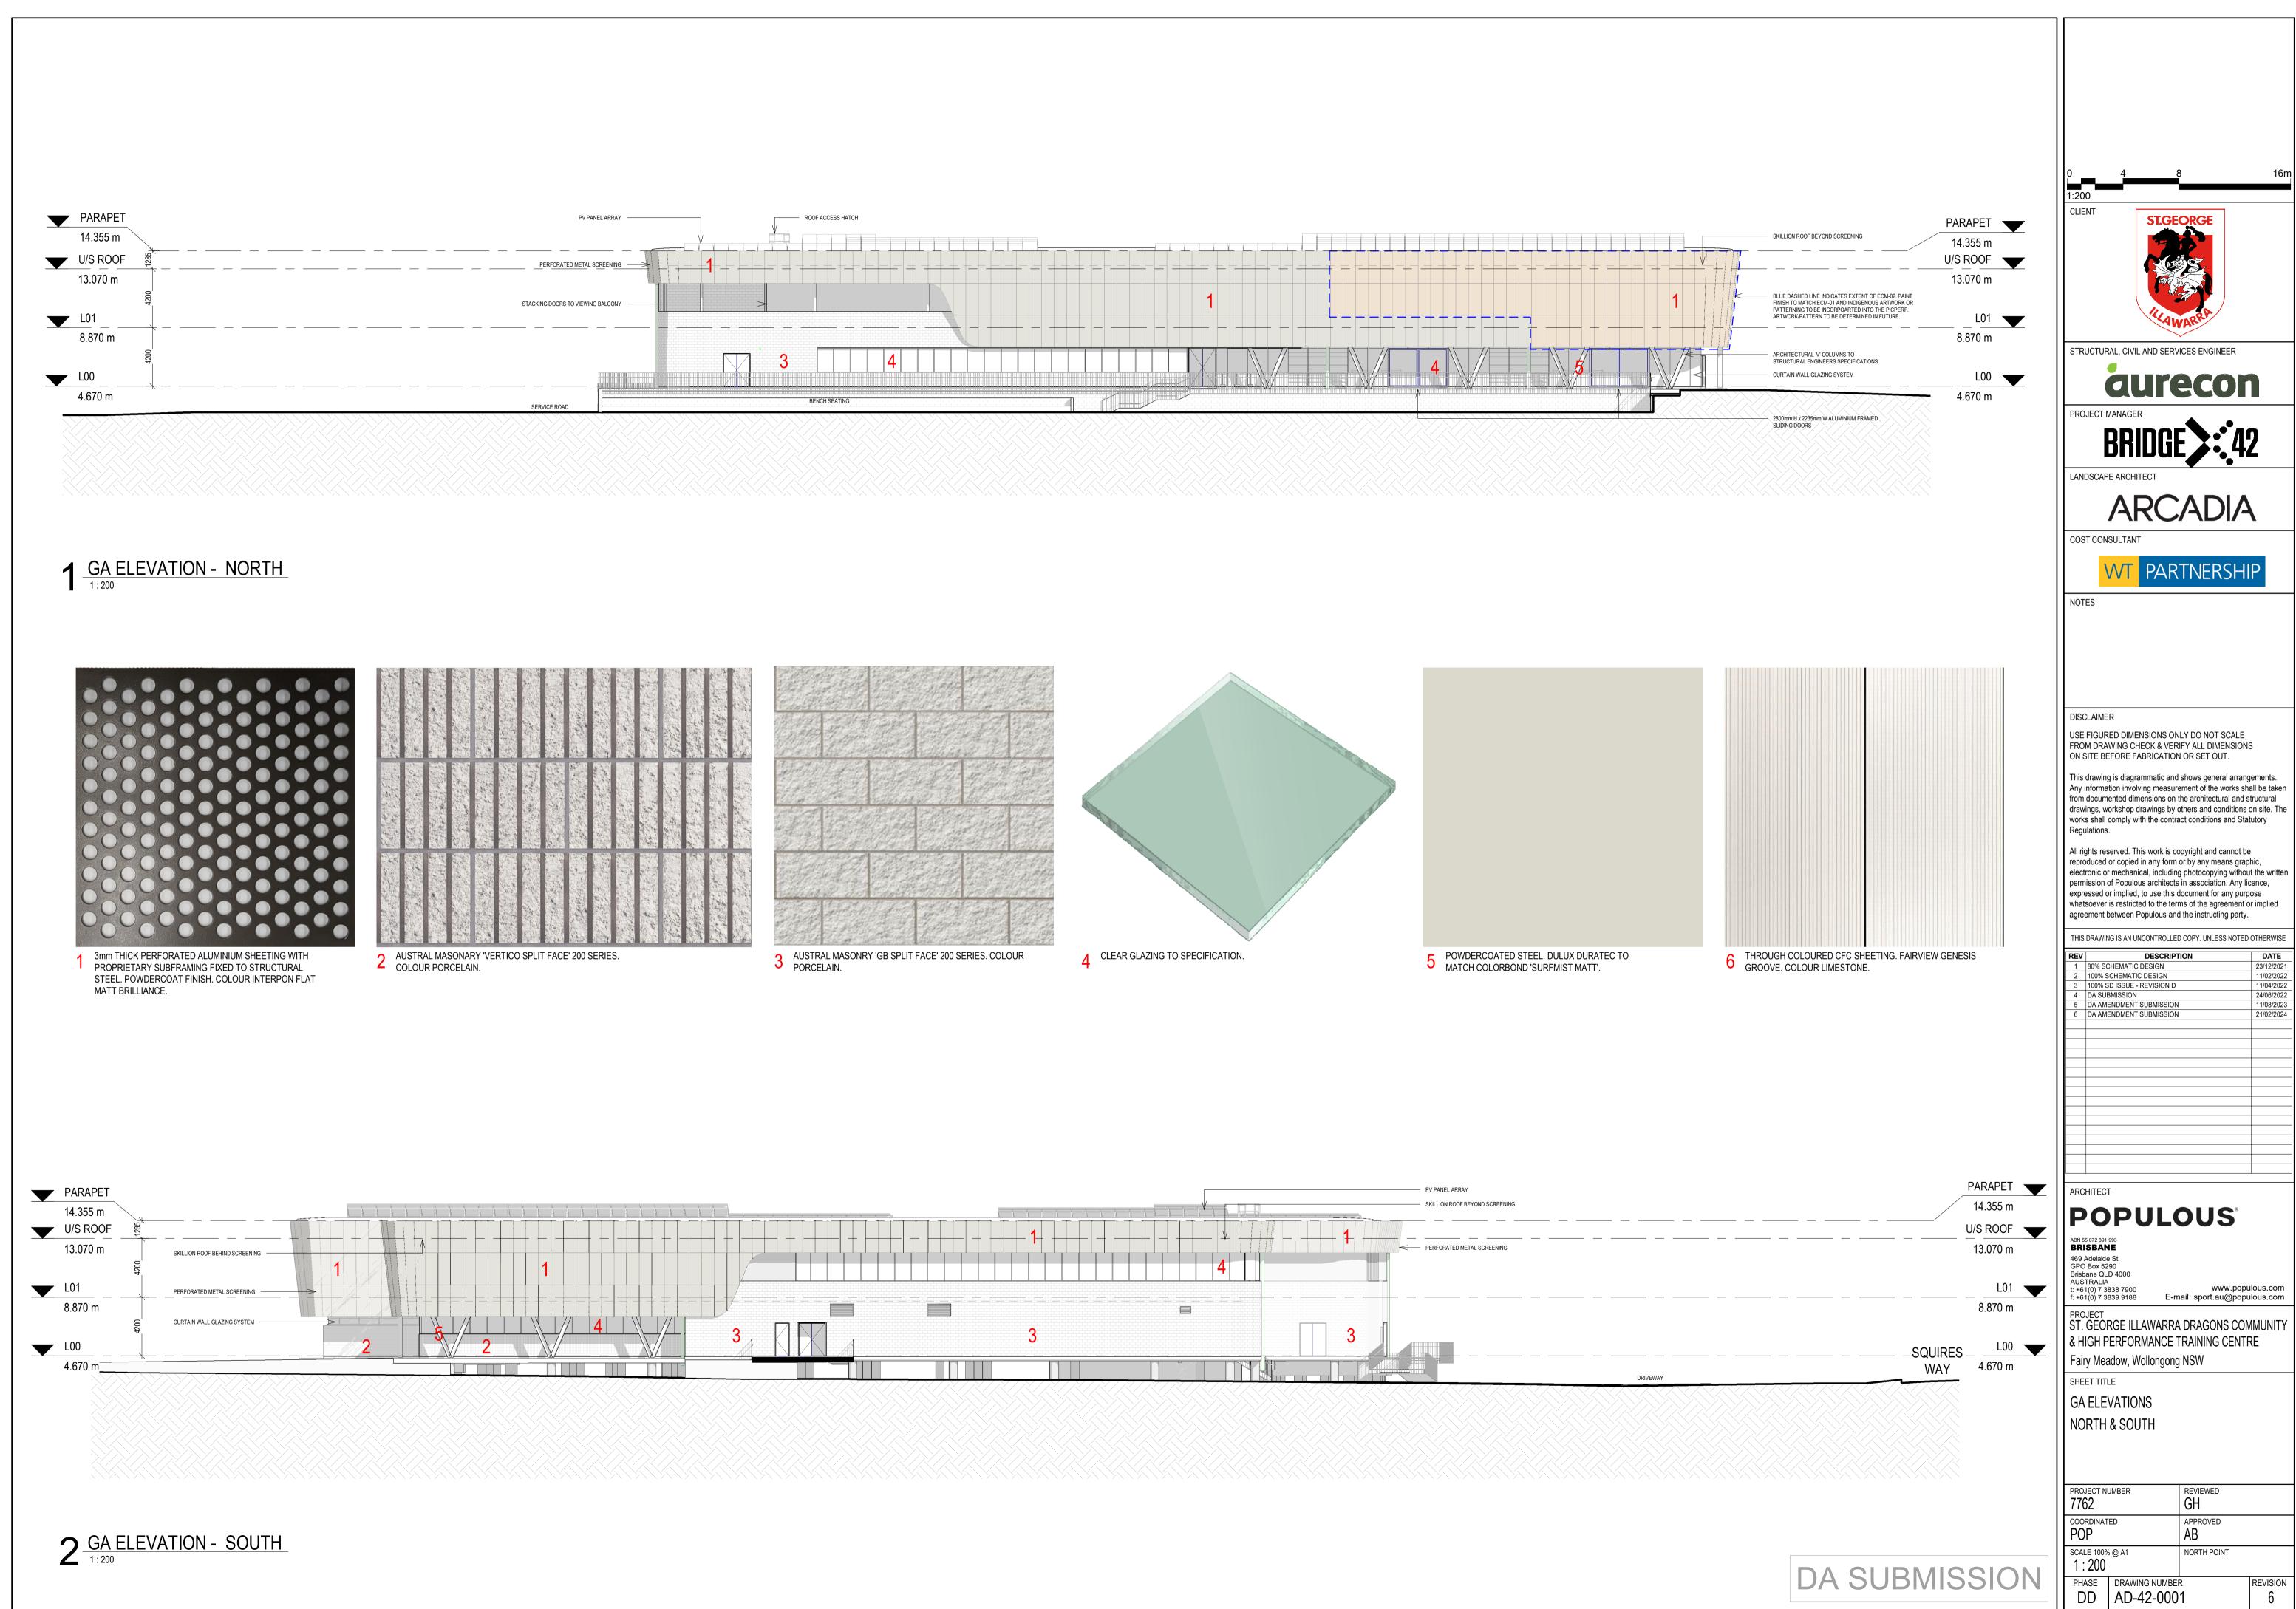


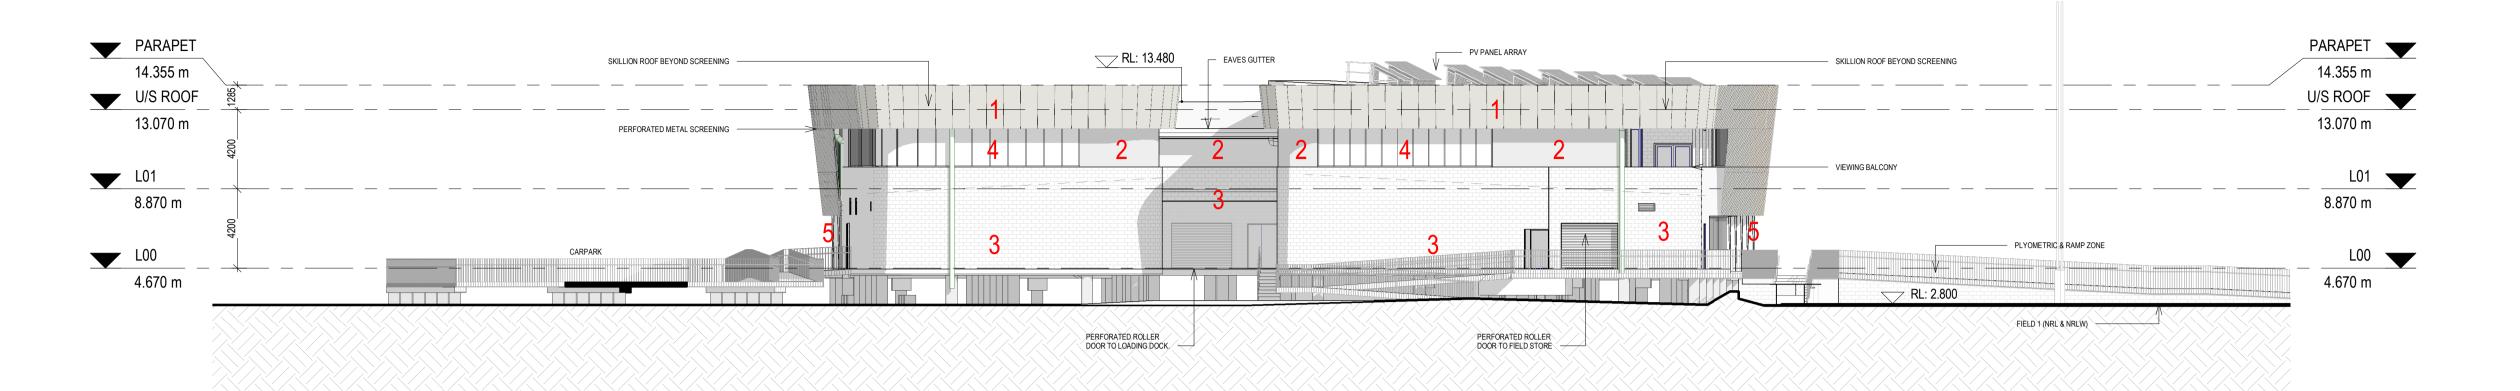

1 GA ELEVATION - EAST


MATT BRILLIANCE.



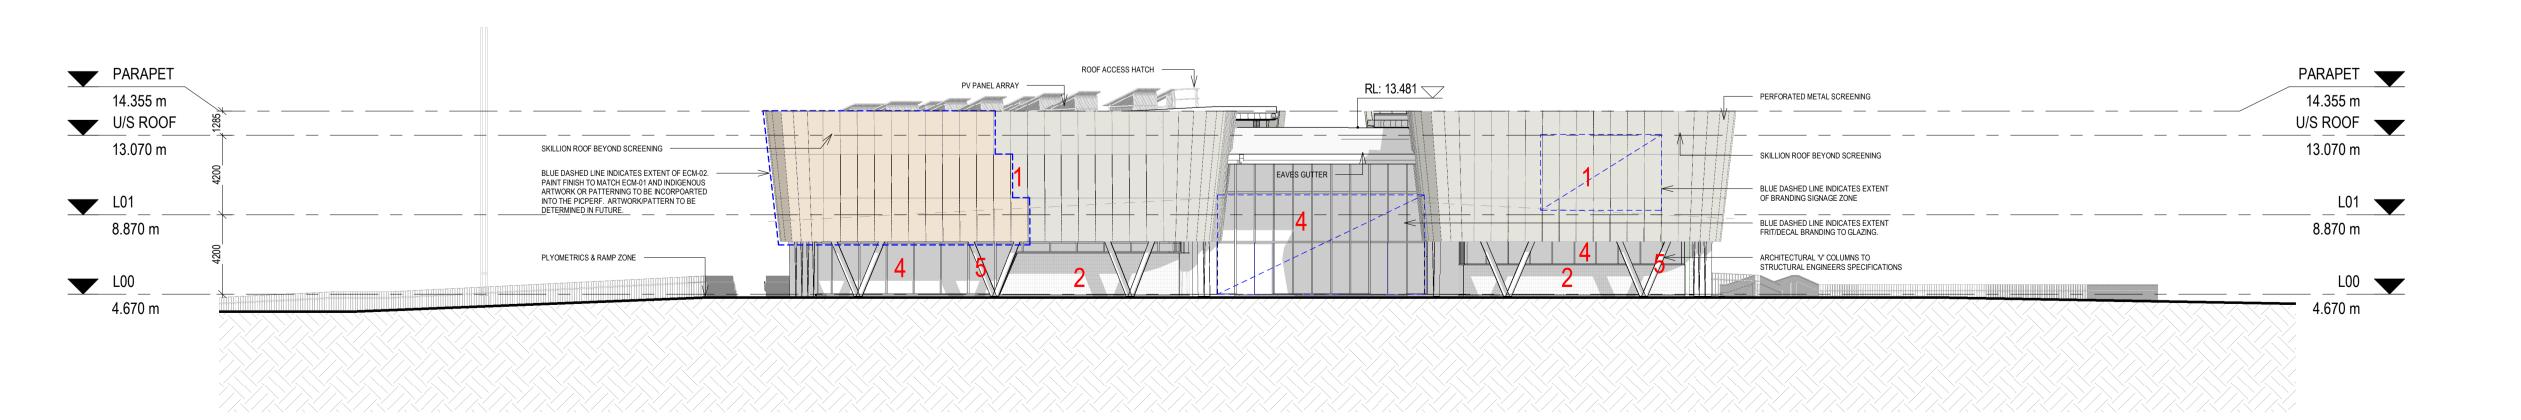

 $2^{\frac{\text{GA ELEVATION - WEST}}{1:200}}$

DA SUBMISSION

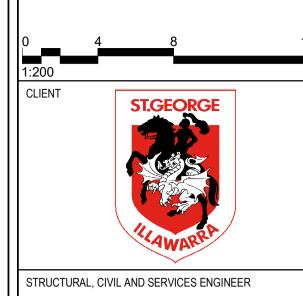

aurecon

BRIDGE 42

LANDSCAPE ARCHITECT

ARCADIA

COST CONSULTANT



NOTES

DISCLAIMER

USE FIGURED DIMENSIONS ONLY DO NOT SCALE FROM DRAWING CHECK & VERIFY ALL DIMENSIONS ON SITE BEFORE FABRICATION OR SET OUT.

This drawing is diagrammatic and shows general arrangements. Any information involving measurement of the works shall be taken from documented dimensions on the architectural and structural drawings, workshop drawings by others and conditions on site. The works shall comply with the contract conditions and Statutory Regulations.

All rights reserved. This work is copyright and cannot be reproduced or copied in any form or by any means graphic, electronic or mechanical, including photocopying without the writte permission of Populous architects in association. Any licence, expressed or implied, to use this document for any purpose whatsoever is restricted to the terms of the agreement or implied agreement between Populous and the instructing party.

THIS DRAWING IS AN UNCONTROLLED COPY. UNLESS NOTED OTHERWISE

REV	DESCRIPTION	DATE
1	80% SCHEMATIC DESIGN	23/12/202
2	100% SCHEMATIC DESIGN	11/02/202
3	100% SD ISSUE - REVISION D	11/04/202
4	DA SUBMISSION	24/06/202
5	DA AMENDMENT SUBMISSION	11/08/202
6	DA AMENDMENT SUBMISSION	21/02/202

ARCHITECT

POPULOUS[®]

ABN 55 072 891 993 **BRISBANE**469 Adelaide St
GPO Box 5290
Brisbane QLD 4000
AUSTRALIA
t: +61(0) 7 3838 7900
f: +61(0) 7 3839 9188

7900 www.populous.com 9188 E-mail: sport.au@populous.com

PROJECT ST. GEORGE ILLAWARRA DRAGONS COMMUNITY & HIGH PERFORMANCE TRAINING CENTRE

Fairy Meadow, Wollongong NSW

SHEET TITLE

GA ELEVATIONS

EAST & WEST

PROJECT NUMBER 7762 GH

COORDINATED APPROVED AB

SCALE 100% @ A1 NORTH POINT

1:200

PHASE DRAWING NUMBER REVISION AD-42-0002 6

AURECON GROUP ST GEORGE ILLAWARRA DRAGONS

NORTH WOLLONGONG NSW 2500, AUSTRALIA

CIVIL SERVICES



CIVIL SERVICES DRAWING INDEX			
DRG NO.	DRAWING TITLE		
520547-SGID-CI-00001	DRAWING INDEX AND LOCALITY PLAN		
520547-SGID-CI-00002	GENERAL NOTES - SHEET 1		
520547-SGID-CI-00010	EROSION AND SEDIMENT CONTROL DETAILS - SHEET 1		
520547-SGID-CI-00040	PAVEMENT DETAILS		
520547-SGID-CI-00041	ROAD FURNITURE AND LINEMARKING DETAILS		
520547-SGID-CI-00060	DRAINAGE DETAILS - SHEET 1		
520547-SGID-CI-00061	DRAINAGE DETAILS - SHEET 2		
520547-SGID-CI-00062	DRAINAGE DETAILS - SHEET 3		
520547-SGID-CI-01000	OVERALL GENERAL ARRANGEMENT LAYOUT		
520547-SGID-CI-01001	GENERAL ARRANGEMENT LAYOUT - SHEET 1		
520547-SGID-CI-01002	GENERAL ARRANGEMENT LAYOUT - SHEET 2		
520547-SGID-CI-01003	GENERAL ARRANGEMENT LAYOUT - SHEET 3		
520547-SGID-CI-01100	SEDIMENT AND EROSION CONTROL PLAN		
520547-SGID-CI-01110	DEMOLITION PLAN		
520547-SGID-CI-01120	BULK EARTHWORKS		
520547-SGID-CI-01131	SITE SECTIONS - SHEET 1		
520547-SGID-CI-01132	SITE SECTIONS - SHEET 2		
520547-SGID-CI-01133	SITE SECTIONS - SHEET 3		
520547-SGID-CI-01200	OVERALL ALIGNMENTS LAYOUT PLAN		
520547-SGID-CI-01201	ROAD AND KERB ALIGNMENT LAYOUT PLAN - SHEET 1		
520547-SGID-CI-01202	ROAD AND KERB ALIGNMENT LAYOUT PLAN - SHEET 2		
520547-SGID-CI-01211	FOOTPATH ALIGNMENT LAYOUT PLAN - SHEET 1		
520547-SGID-CI-01212	FOOTPATH ALIGNMENT LAYOUT PLAN - SHEET 2		
520547-SGID-CI-01221	SPORTS FIELD AND BUILDING ALIGNMENT LAYOUT PLAN		

CIVIL SERVICES DRAWING INDEX		
DRG NO.	DRAWING TITLE	
520547-SGID-CI-01231	SWALE DRAIN ALIGNMENT LAYOUT PLAN - SHEET 1	
520547-SGID-CI-01251	ALIGNMENT SETOUT TABLES - SHEET 1	
520547-SGID-CI-01252	ALIGNMENT SETOUT TABLES - SHEET 2	
520547-SGID-CI-01253	ALIGNMENT SETOUT TABLES - SHEET 3	
520547-SGID-CI-01270	RETAINING WALL SECTIONS	
520547-SGID-CI-01300	ROAD PAVEMENT PLAN	
520547-SGID-CI-01351	LINEMARKING AND SIGNAGE LAYOUT PLAN	
520547-SGID-CI-01400	OVERALL STORMWATER DRAINAGE LAYOUT PLAN	
520547-SGID-CI-01401	STORMWATER DRAINAGE LAYOUT PLAN - SHEET 1	
520547-SGID-CI-01402	STORMWATER DRAINAGE LAYOUT PLAN - SHEET 2	
520547-SGID-CI-01403	STORMWATER DRAINAGE LAYOUT PLAN - SHEET 3	
520547-SGID-CI-01411	STORMWATER DRAINAGE LONGITUDINAL SECTIONS - SHEET	
520547-SGID-CI-01412	STORMWATER DRAINAGE LONGITUDINAL SECTIONS - SHEET	
520547-SGID-CI-01413	STORMWATER DRAINAGE LONGITUDINAL SECTIONS - SHEET	
520547-SGID-CI-01414	STORMWATER DRAINAGE LONGITUDINAL SECTIONS - SHEET	
520547-SGID-CI-01450	STORMWATER DRAINAGE PIT SCHEDULE	
520547-SGID-CS-01200	OVERALL SEWERAGE LAYOUT PLAN	
520547-SGID-CS-01350	OVERALL COMBINED SERVICES LAYOUT PLAN	



www.aurecongroup.com

ABN: 54 005 139 873

A person using the Aurecon drawings and other data accepts the risk of: 1. Using the drawings and other data in electronic form without requesting and checking them for accuracy against the original hard copy

2. Using the drawing or other data for any purpose not agreed to in writing by Aurecon.

Wherever a discrepancy in the contract documents is found and unless directed otherwise by the Principal/Engineer, the contractor shall adopt, at their own cost the greater quantum, class of finish, grade, or specification where applicable.

NOTE: ALL DRAWINGS ARE BASED ON FROZEN ARCHITECTURAL MODEL V177 ISSUED ON THE 30/06/2023



POPULOUS°







DISCLAIMER

FROM DRAWING CHECK & VERIFY ALL DIMENSIONS ON SITE BEFORE FABRICATION OR SET OUT.

from documented dimensions on the architectural and structural drawings, workshop drawings by others and conditions on site. The works shall comply with the contract conditions and Statutory

All rights reserved. This work is copyright and cannot be reproduced or copied in any form or by any means graphic, electronic or mechanical, including photocopying without the written permission of Populous architects in association. Any licence, expressed or implied, to use this document for any purpose whatsoever is restricted to the terms of the agreement or implied agreement between Populous and the instructing party.

THIS DRAWING IS AN UNCONTROLLED COPY. UNLESS NOTED OTHERWISE

REV	DESCRIPTION	DATE
1	DA AMENDMENT SUBMISSION	14/07/202
2	70% DD TENDER ISSUE	18/08/202
3	REVISED DA SUBMISSION	16/02/202

STRUCTURAL, CIVIL AND SERVICES ENGINEER

aurecon

LEVEL 11 73 Miller Street North Sydney, NSW 2060 AUSTRALIA t: +61(0) 2 9465 5599 f: +61(0) 2 9465 5598

www.aurecongroup.com

COMMUNITY & HIGH PERFORMANCE TRAINING CENTRE

CIVIL WORKS DRAWING INDEX AND LOCALITY PLAN

PROJECT NUMBER E.WILLIAMS E.SELL G.CHRISTIE SCALE 100% @ A1 NORTH POINT W 00.00 DEG

520547-SGID-CI-00001





- 4. REFER TO LANDSCAPE ARCHITECTURE FINISHES FOR GREEN HATCHES FINISHES.
- 5. REFER TO SPORTS ENG DOCUMENTATION FOR FIELDS AND RUNNING TRACK DETAILS.

adopt, at their own cost the greater quantum, class of finish, grade, or specification where applicable.

NOTE: ALL DRAWINGS ARE BASED ON FROZEN ARCHITECTURAL MODEL V177 ISSUED ON THE 30/06/2023

PRINT IN COLOUR NOT FOR CONSTRUCTION

electronic or mechanical, including photocopying without the written permission of Populous architects in association. Any licence, expressed or implied, to use this document for any purpose whatsoever is restricted to the terms of the agreement or implied agreement between Populous and the instructing party. THIS DRAWING IS AN UNCONTROLLED COPY. UNLESS NOTED OTHERWISE

ARCADIA

2 70% DD TENDER ISSUE 3 REVISED DA SUBMISSION

STRUCTURAL, CIVIL AND SERVICES ENGINEER

aurecon

LEVEL 11 73 Miller Street North Sydney, NSW 2060 AUSTRALIA t: +61(0) 2 9465 5599 f: +61(0) 2 9465 5598

www.aurecongroup.com

ST. GEORGE ILLAWARRA DRAGONS COMMUNITY & HIGH PERFORMANCE TRAINING CENTRE


SHEET TITLE CIVIL WORKS OVERALL

GENERAL ARRANGEMENT

PROJECT NUMBER 520547 E.WILLIAMS E.SELL G.CHRISTIE SCALE 100% @ A1 NORTH POINT 1:750 W 00.00 DEG PHASE DD DRAWING NUMBER





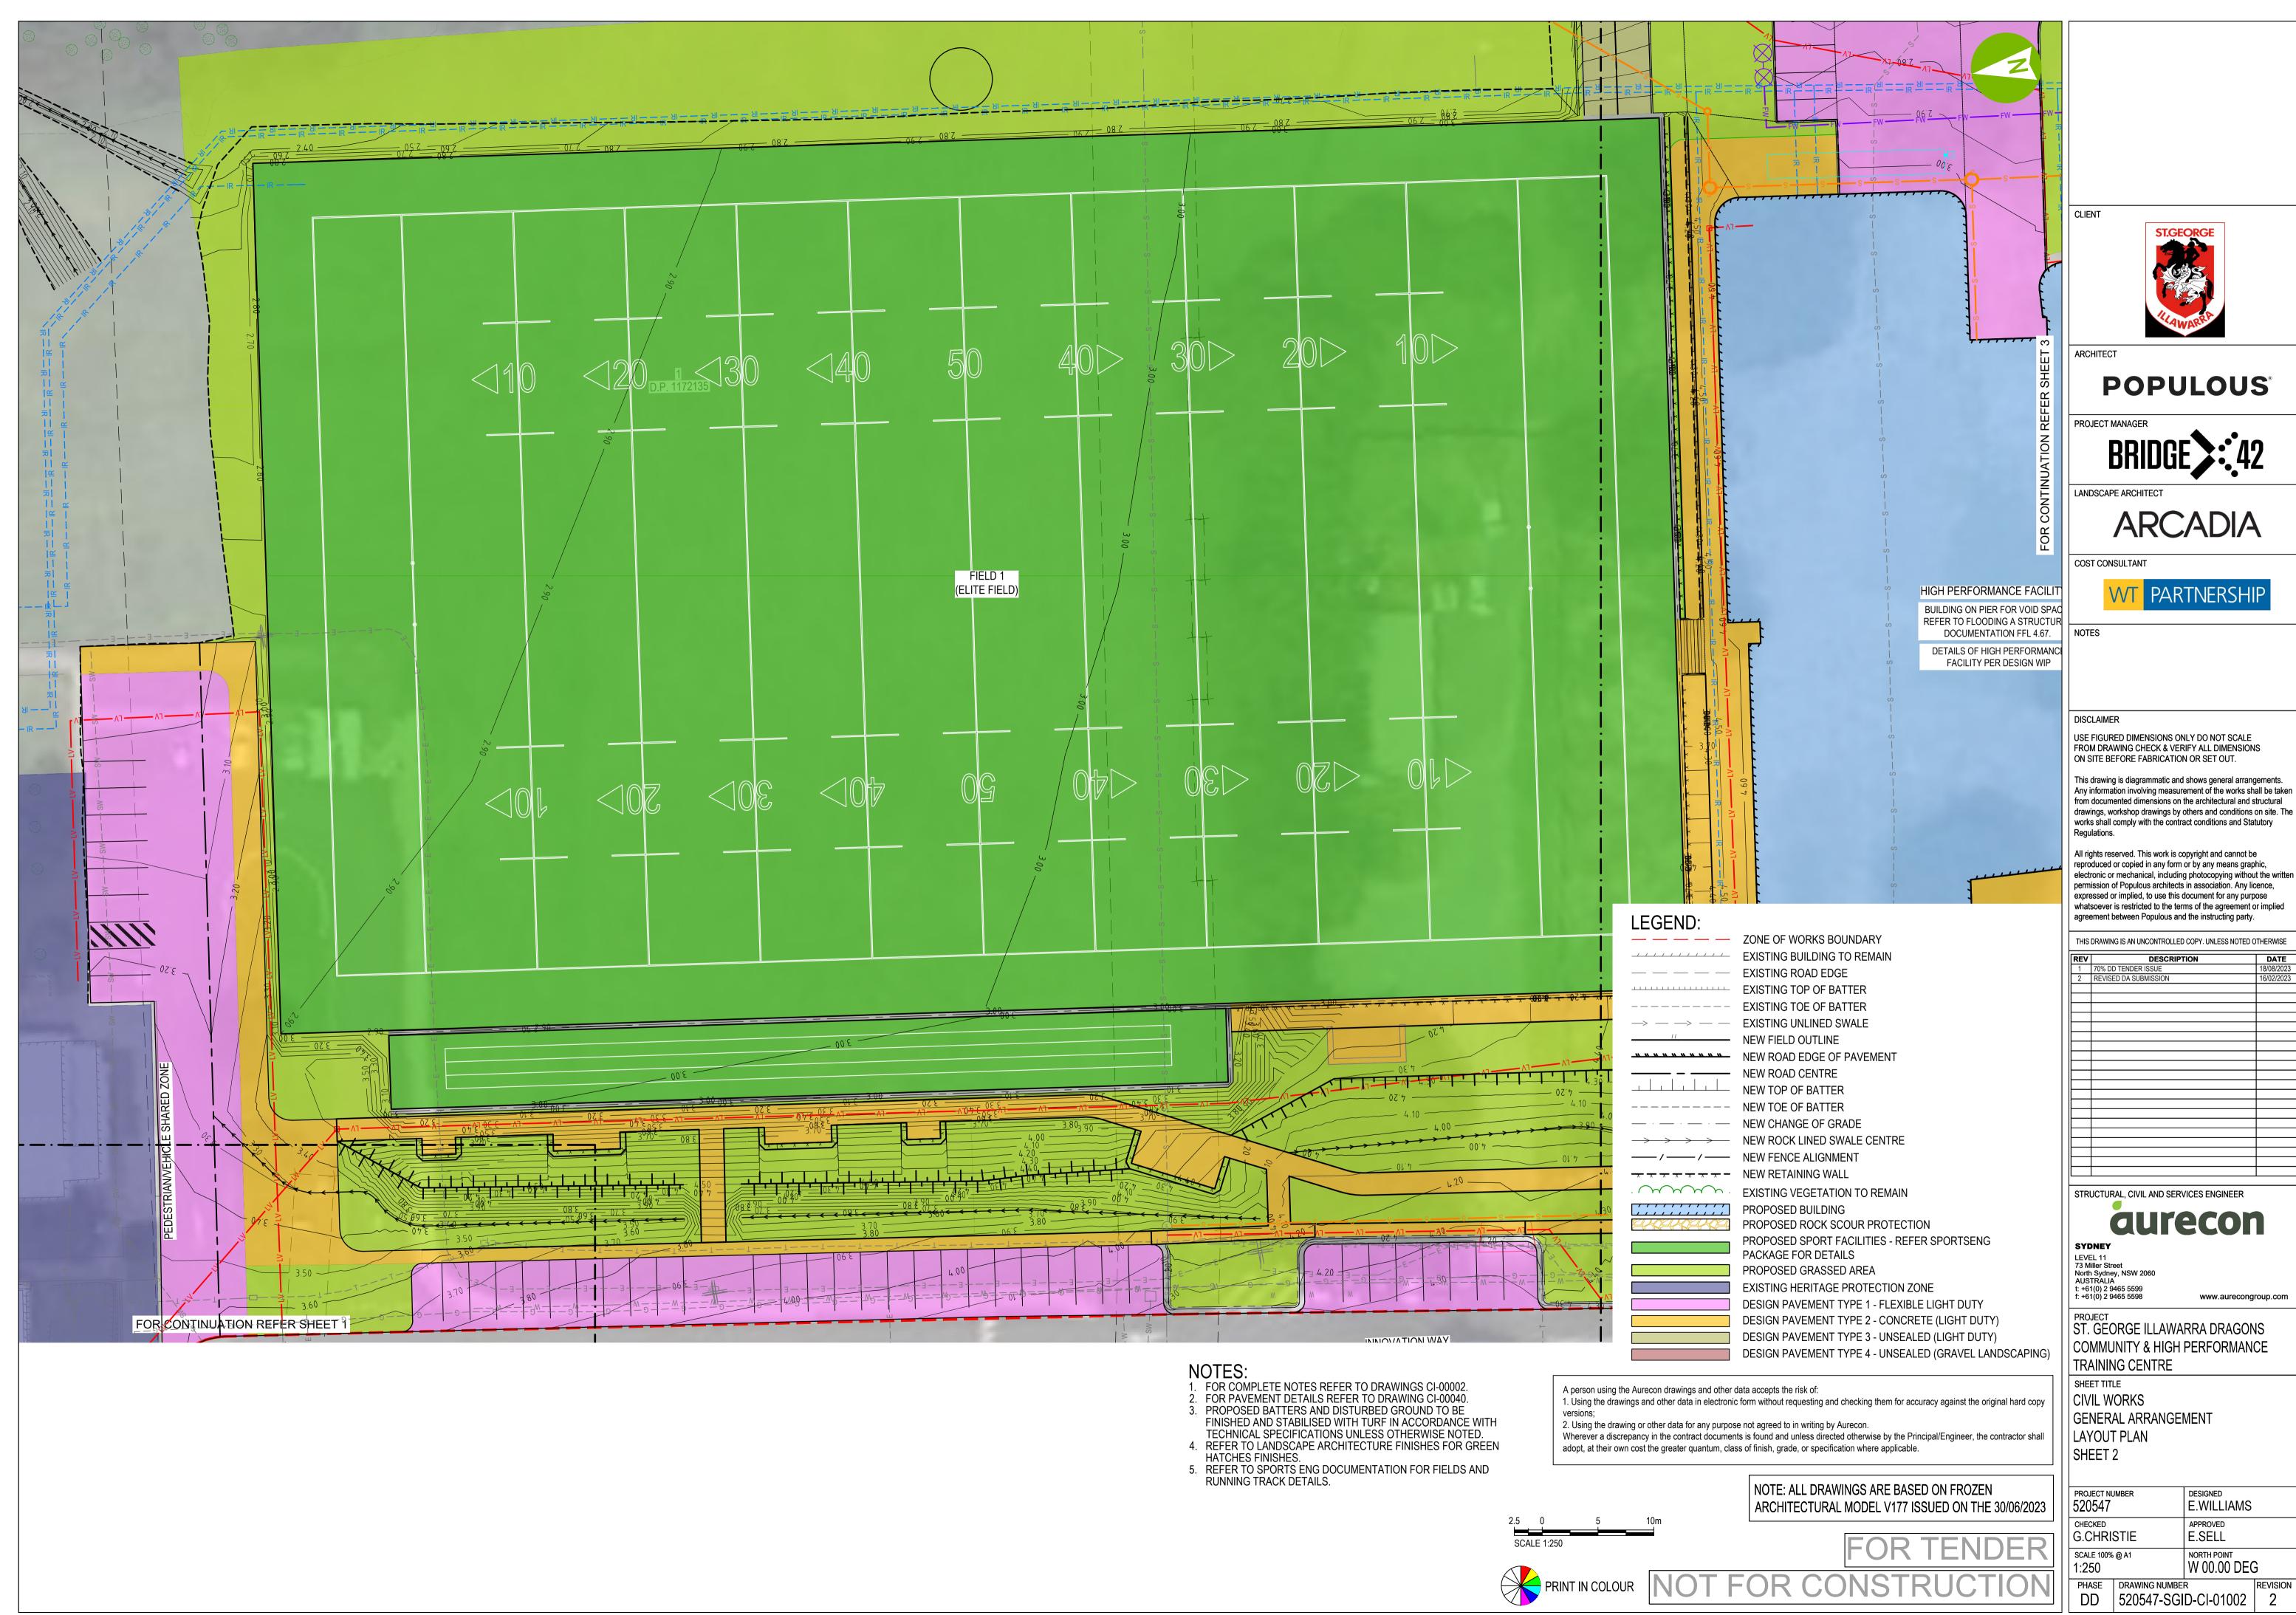





POPULOUS°

ARCADIA

COST CONSULTANT



DISCLAIMER

USE FIGURED DIMENSIONS ONLY DO NOT SCALE FROM DRAWING CHECK & VERIFY ALL DIMENSIONS ON SITE BEFORE FABRICATION OR SET OUT.

This drawing is diagrammatic and shows general arrangements. Any information involving measurement of the works shall be taken from documented dimensions on the architectural and structural drawings, workshop drawings by others and conditions on site. The works shall comply with the contract conditions and Statutory

All rights reserved. This work is copyright and cannot be reproduced or copied in any form or by any means graphic, electronic or mechanical, including photocopying without the written permission of Populous architects in association. Any licence, expressed or implied, to use this document for any purpose whatsoever is restricted to the terms of the agreement or implied

agreement between Populous and the instructing party.

THIS DRAWING IS AN UNCONTROLLED COPY. UNLESS NOTED OTHERWISE DESCRIPTION

1	70% DD TENDER ISSUE		08/20
2	REVISED DA SUBMISSION	16/	02/20

STRUCTURAL, CIVIL AND SERVICES ENGINEER

aurecon


LEVEL 11 73 Miller Street North Sydney, NSW 2060 AUSTRALIA t: +61(0) 2 9465 5599 f: +61(0) 2 9465 5598

www.aurecongroup.com

ST. GEORGE ILLAWARRA DRAGONS COMMUNITY & HIGH PERFORMANCE TRAINING CENTRE

SHEET TITLE CIVIL WORKS GENERAL ARRANGEMENT LAYOUT PLAN SHEET 3

PROJECT NUMBER 520547 E.WILLIAMS E.SELL G.CHRISTIE SCALE 100% @ A1 NORTH POINT W 00.00 DEG 1:250 PHASE DRAWING NUMBER DD 520547-SGID 520547-SGID-CI-01003

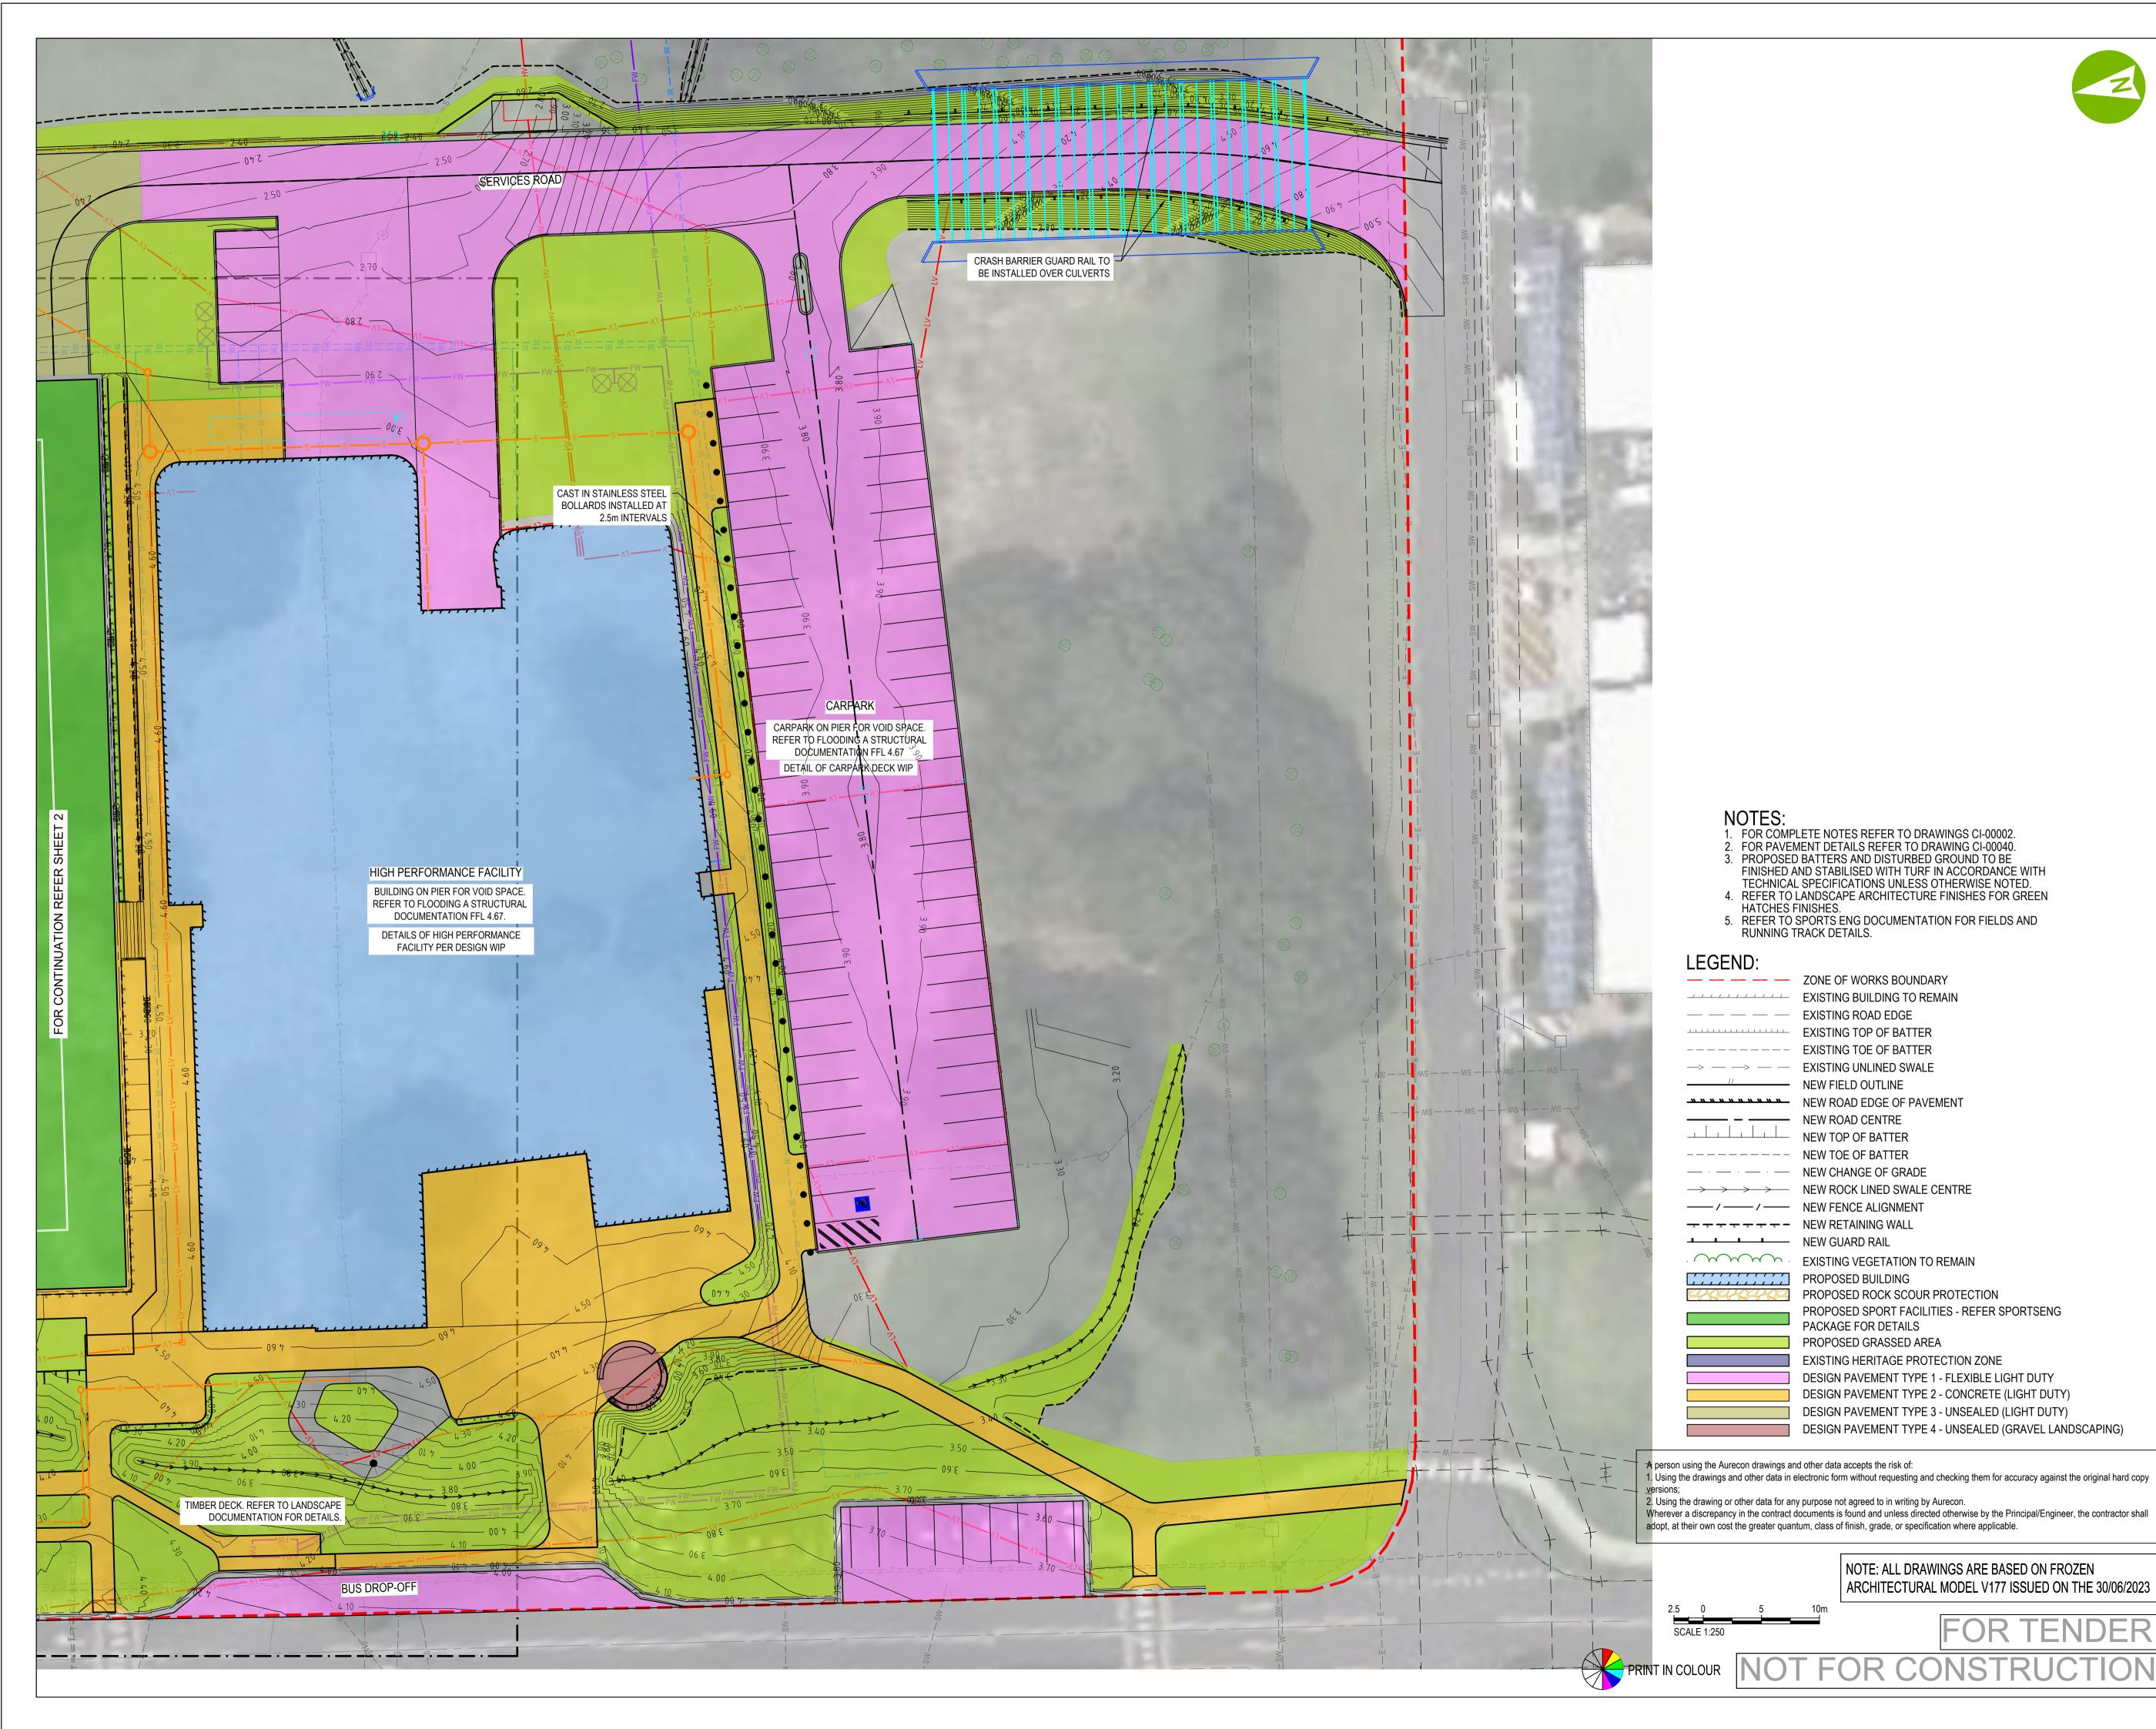



2. REFER DRAWINGS CI-0230 AND CI-0231 FOR BULK

EARTHWORKS SECTIONS.

POPULOUS

ARCADIA

COST CONSULTANT



DISCLAIMER

USE FIGURED DIMENSIONS ONLY DO NOT SCALE FROM DRAWING CHECK & VERIFY ALL DIMENSIONS ON SITE BEFORE FABRICATION OR SET OUT.

This drawing is diagrammatic and shows general arrangements. Any information involving measurement of the works shall be taken from documented dimensions on the architectural and structural drawings, workshop drawings by others and conditions on site. The works shall comply with the contract conditions and Statutory

All rights reserved. This work is copyright and cannot be electronic or mechanical, including photocopying without the written permission of Populous architects in association. Any licence, expressed or implied, to use this document for any purpose whatsoever is restricted to the terms of the agreement or implied agreement between Populous and the instructing party.

THIS DRAWING IS AN UNCONTROLLED COPY. UNLESS NOTED OTHERWISE

REV	DESCRIPTION	DATE
1	DA AMENDMENT SUBMISSION	14/07/2023
2	70% DD TENDER ISSUE	18/08/202
3	REVISED DA SUBMISSION	16/02/202

STRUCTURAL, CIVIL AND SERVICES ENGINEER

aurecon

LEVEL 11 73 Miller Street North Sydney, NSW 2060 AUSTRALIA t: +61(0) 2 9465 5599 f: +61(0) 2 9465 5598

www.aurecongroup.com

ST. GEORGE ILLAWARRA DRAGONS COMMUNITY & HIGH PERFORMANCE TRAINING CENTRE

SHEET TITLE CIVIL WORKS OVERALL

BULK EARTHWORKS

PROJECT NUMBER 520547 E.WILLIAMS E.SELL **G.CHRISTIE** SCALE 100% @ A1 NORTH POINT 1:750 W 00.00 DEG PHASE DD

DRAWING NUMBER

PRINT IN COLOUR NOT FOR CONSTRUCTION

NOTES: 1. EDGE OF WORKS TO JOIN NEATLY TO EXISTING SURFACES FIELD 2 BULK EARTHWORKS LEVEL REFER SPROTSENG DRAWINGS FOR PAVEMENT DETAIL ABOVE BULK EARTHWORKS LEVELS FOR FIELDS. 0.50% EXISTING SURFACE -0.20%/ DATUM R.L. 2.0 FINISHED SURFACE EXISTING SURFACE OFFSETS SECTION C COST CONSULTANT FIELD 1 - BULK EARTHWORKS LEVEL - REFER SPROTSENG DRAWINGS FOR -2.18% PAVEMENT DETAIL ABOVE BULK EARTHWORKS LEVELS FOR FIELDS. FINISHED SURFACE EXISTING SURFACE DISCLAIMER -2.27% - _ -0.24% DATUM R.L. 2.0 FINISHED SURFACE EXISTING SURFACE -39.450 OFFSETS FIELD 1 - BULK EARTHWORKS LEVEL 0.76% REFER SPROTSENG DRAWINGS FOR PAVEMENT DETAIL ABOVE BULK EARTHWORKS LEVELS FOR FIELDS. FINISHED SURFACE EXISTING SURFACE 0.01% DATUM R.L. 2.0 LEVEL 11 73 Miller Street North Sydney, NSW 2060 AUSTRALIA t: +61(0) 2 9465 5599 f: +61(0) 2 9465 5598 FINISHED SURFACE 4.361 4.361 3.084 EXISTING SURFACE SHEET TITLE -41.552 -39.452 -39.000 OFFSETS A person using the Aurecon drawings and other data accepts the risk of: NOTE: ALL DRAWINGS ARE BASED ON FROZEN 1. Using the drawings and other data in electronic form without requesting and checking them for accuracy against the original hard copy 520547 ARCHITECTURAL MODEL V177 ISSUED ON THE 30/06/2023 2. Using the drawing or other data for any purpose not agreed to in writing by Aurecon. Wherever a discrepancy in the contract documents is found and unless directed otherwise by the Principal/Engineer, the contractor shall adopt, at their own cost the greater quantum, class of finish, grade, or specification where applicable.

POPULOUS



USE FIGURED DIMENSIONS ONLY DO NOT SCALE FROM DRAWING CHECK & VERIFY ALL DIMENSIONS ON SITE BEFORE FABRICATION OR SET OUT.

This drawing is diagrammatic and shows general arrangements. Any information involving measurement of the works shall be taken from documented dimensions on the architectural and structural drawings, workshop drawings by others and conditions on site. The works shall comply with the contract conditions and Statutory

All rights reserved. This work is copyright and cannot be reproduced or copied in any form or by any means graphic, electronic or mechanical, including photocopying without the written permission of Populous architects in association. Any licence, expressed or implied, to use this document for any purpose whatsoever is restricted to the terms of the agreement or implied agreement between Populous and the instructing party.

THIS DRAWING IS AN UNCONTROLLED COPY. UNLESS NOTED OTHERWISE

	DEGGINI HON	0011
1	DA AMENDMENT SUBMISSION	14/07/202
2	70% DD TENDER ISSUE	18/08/20
3	REVISED DA SUBMISSION	16/02/202

STRUCTURAL, CIVIL AND SERVICES ENGINEER

aurecon

www.aurecongroup.com ST. GEORGE ILLAWARRA DRAGONS


COMMUNITY & HIGH PERFORMANCE TRAINING CENTRE

CIVIL WORKS SITE SECTIONS


PRINT IN COLOUR NOT FOR CONSTRUCTION


PROJECT NUMBER E.WILLIAMS E.SELL G.CHRISTIE SCALE 100% @ A1 NORTH POINT W 00.00 DEG NTS PHASE DRAWING NUMBER DD 520547-SGID

NOTES: 1. EDGE OF WORKS TO JOIN NEATLY

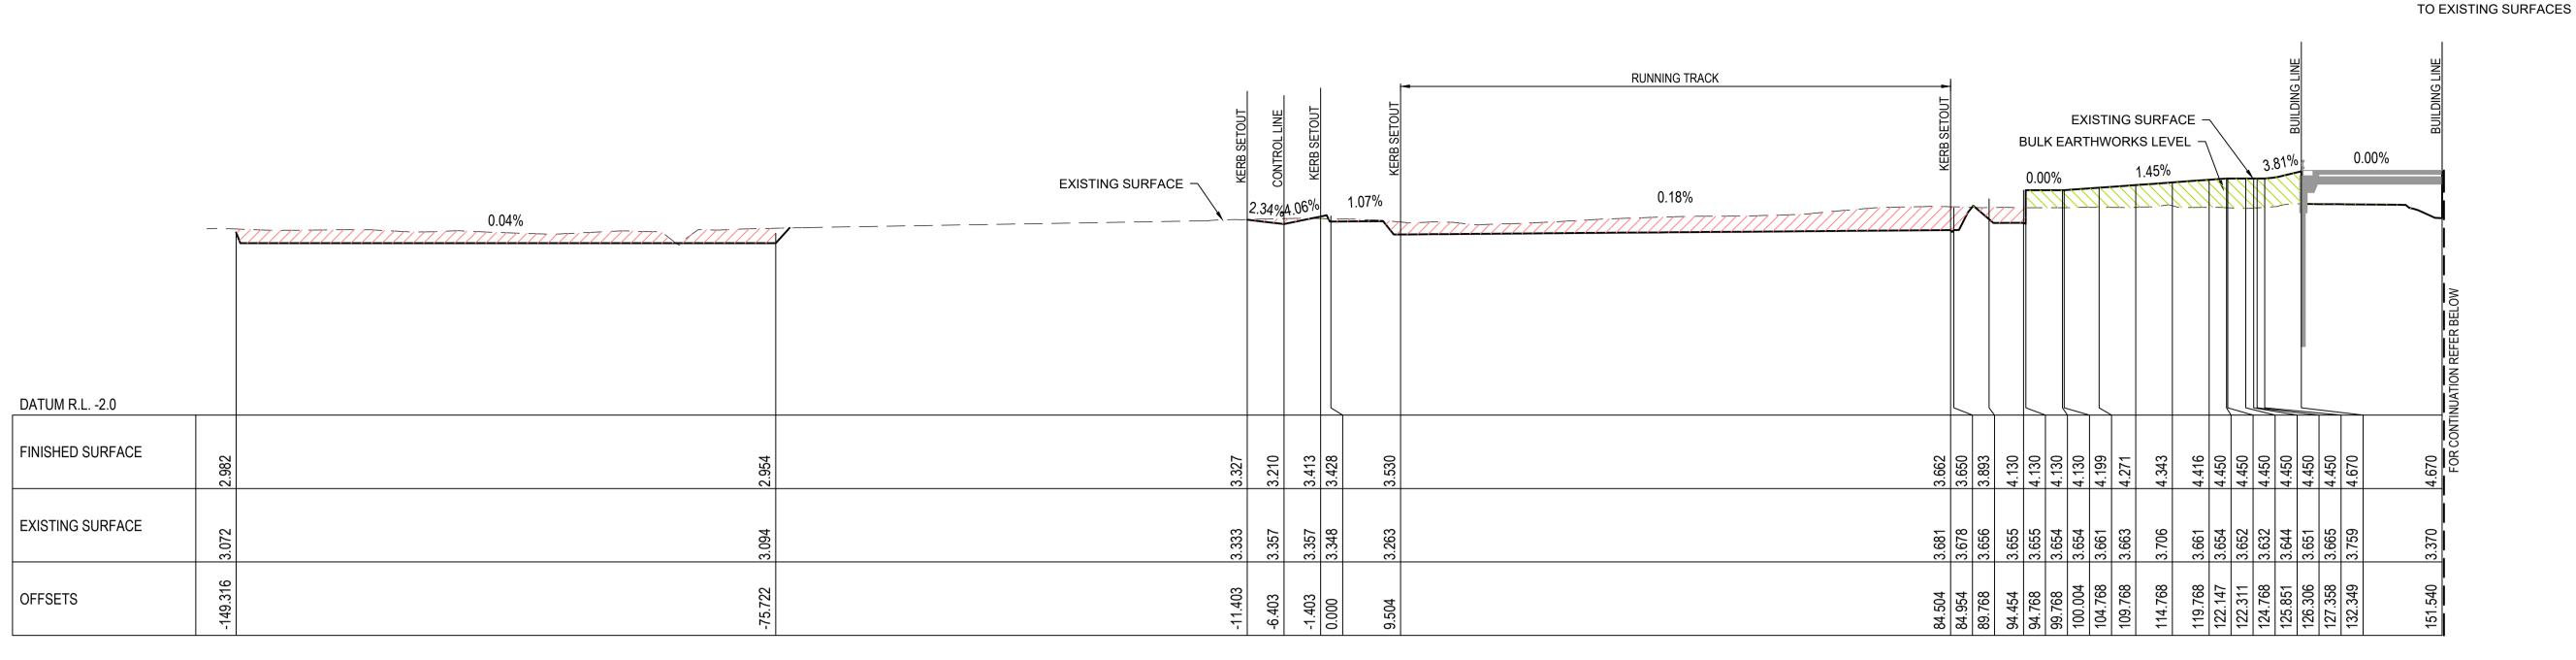

SECTION E 1:250H; 1:50V

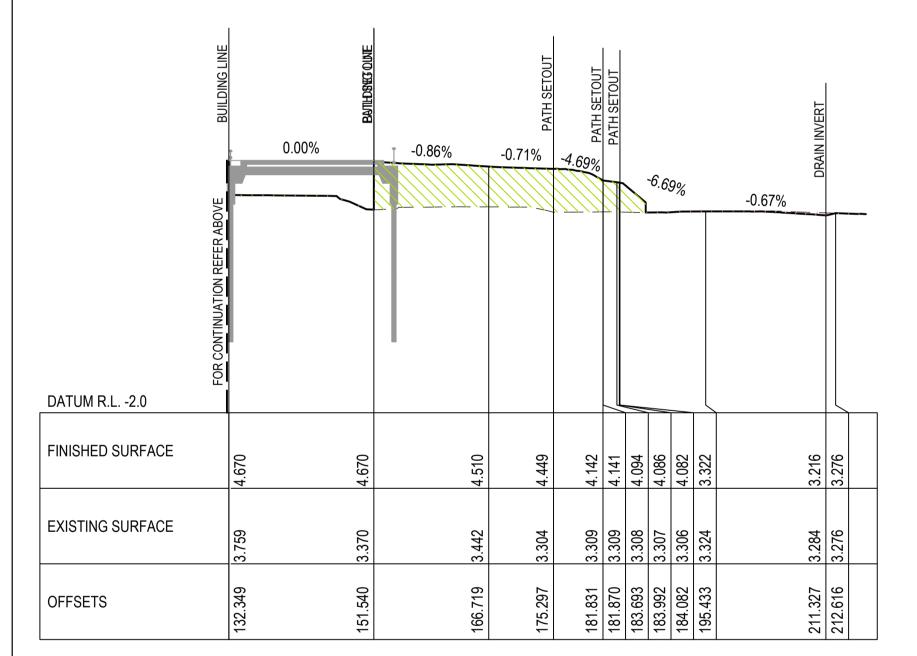

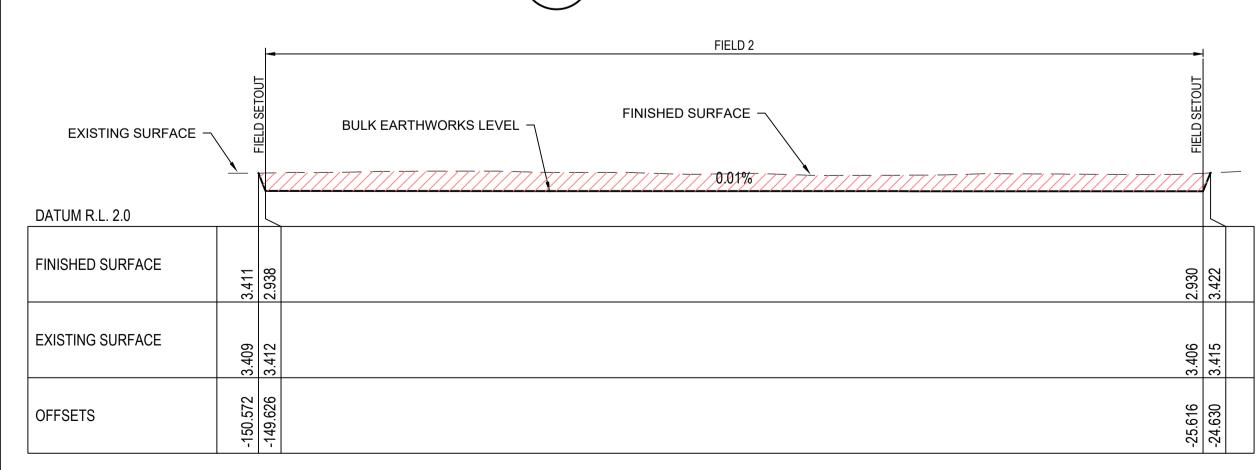

A person using the Aurecon drawings and other data accepts the risk of:

1. Using the drawings and other data in electronic form without requesting and checking them for accuracy against the original hard copy

2. Using the drawing or other data for any purpose not agreed to in writing by Aurecon.

Wherever a discrepancy in the contract documents is found and unless directed otherwise by the Principal/Engineer, the contractor shall adopt, at their own cost the greater quantum, class of finish, grade, or specification where applicable.

> NOTE: ALL DRAWINGS ARE BASED ON FROZEN ARCHITECTURAL MODEL V177 ISSUED ON THE 30/06/2023





POPULOUS°

PROJECT MANAGER



COST CONSULTANT



DISCLAIMER

USE FIGURED DIMENSIONS ONLY DO NOT SCALE FROM DRAWING CHECK & VERIFY ALL DIMENSIONS ON SITE BEFORE FABRICATION OR SET OUT.

This drawing is diagrammatic and shows general arrangements. Any information involving measurement of the works shall be taken from documented dimensions on the architectural and structural drawings, workshop drawings by others and conditions on site. The works shall comply with the contract conditions and Statutory

All rights reserved. This work is copyright and cannot be reproduced or copied in any form or by any means graphic, electronic or mechanical, including photocopying without the written permission of Populous architects in association. Any licence, expressed or implied, to use this document for any purpose whatsoever is restricted to the terms of the agreement or implied agreement between Populous and the instructing party.

THIS DRAWING IS AN UNCONTROLLED COPY. UNLESS NOTED OTHERWISE

REV	DESCRIPTION	DATE			
1	DA AMENDMENT SUBMISSION	14/07/2023			
2	70% DD TENDER ISSUE	18/08/2023			
3	REVISED DA SUBMISSION	16/02/2023			

STRUCTURAL, CIVIL AND SERVICES ENGINEER

aurecon

LEVEL 11 73 Miller Street North Sydney, NSW 2060 AUSTRALIA t: +61(0) 2 9465 5599 f: +61(0) 2 9465 5598

ST. GEORGE ILLAWARRA DRAGONS


www.aurecongroup.com

COMMUNITY & HIGH PERFORMANCE TRAINING CENTRE

SHEET TITLE CIVIL WORKS SITE SECTIONS

SHEET 2

PROJECT NUMBER 520547 E.WILLIAMS E.SELL G.CHRISTIE SCALE 100% @ A1 NORTH POINT W 00.00 DEG NTS PHASE DRAWING NUMBER
DD 520547-SGID 520547-SGID-CI-01132

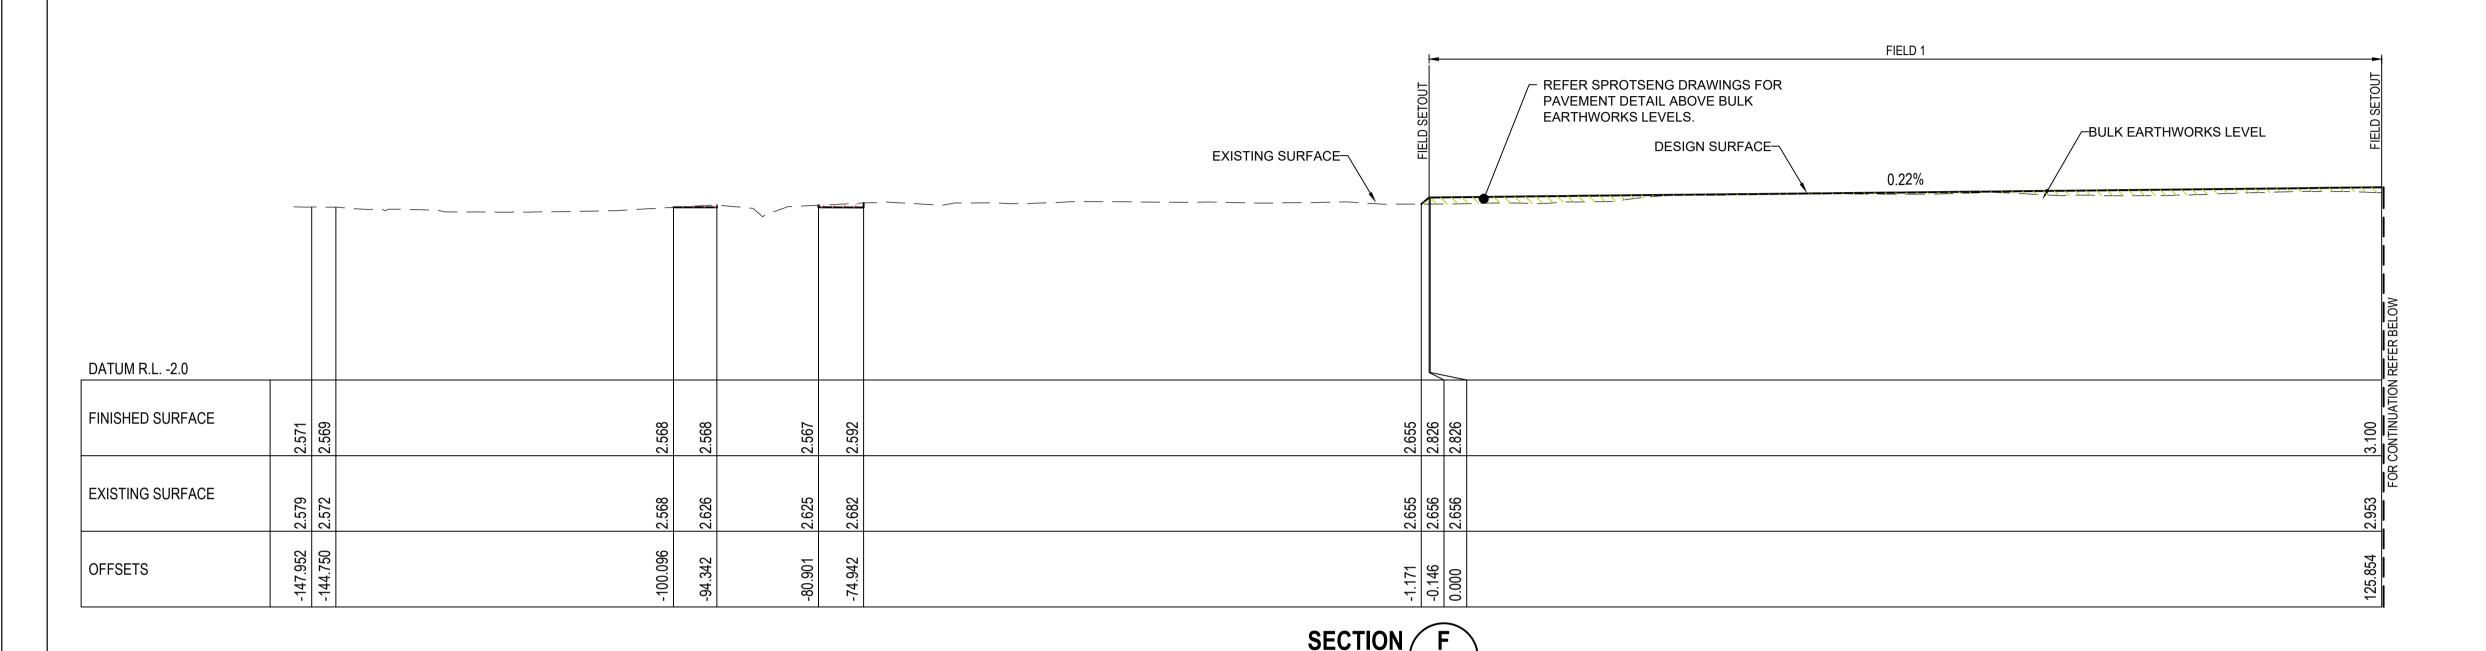

1:250H; 1:50V

BUILDING CARPARK 0.00% -2.02% 2.02% DATUM R.L. -2.0 FINISHED SURFACE 4.670 4.205 4.158 4.000 3.999 3.999 4.000 4.000 3.100 3.100 4.150 4.450 4.670 EXISTING SURFACE 2.953 2.946 2.946 2.935 2.933 2.992 2.884 2.865 2.863 2.863 2.863 2.863 2.808 2.808 2.808

125.854 126.304 126.756 128.106 128.406 130.550

OFFSETS

SECTION F 1:250H; 1:50V

153.050 153.060 159.965 159.975

175.083 176.823 178.836 180.187 180.337 180.320 197.653 197.653

A person using the Aurecon drawings and other data accepts the risk of:

1. Using the drawings and other data in electronic form without requesting and checking them for accuracy against the original hard copy

2. Using the drawing or other data for any purpose not agreed to in writing by Aurecon.

Wherever a discrepancy in the contract documents is found and unless directed otherwise by the Principal/Engineer, the contractor shall adopt, at their own cost the greater quantum, class of finish, grade, or specification where applicable.

> NOTE: ALL DRAWINGS ARE BASED ON FROZEN ARCHITECTURAL MODEL V177 ISSUED ON THE 30/06/2023

POPULOUS°





COST CONSULTANT



DISCLAIMER

USE FIGURED DIMENSIONS ONLY DO NOT SCALE FROM DRAWING CHECK & VERIFY ALL DIMENSIONS ON SITE BEFORE FABRICATION OR SET OUT.

This drawing is diagrammatic and shows general arrangements. Any information involving measurement of the works shall be taken from documented dimensions on the architectural and structural drawings, workshop drawings by others and conditions on site. The works shall comply with the contract conditions and Statutory

All rights reserved. This work is copyright and cannot be reproduced or copied in any form or by any means graphic, electronic or mechanical, including photocopying without the written permission of Populous architects in association. Any licence, expressed or implied, to use this document for any purpose whatsoever is restricted to the terms of the agreement or implied agreement between Populous and the instructing party.

THIS DRAWING IS AN UNCONTROLLED COPY. UNLESS NOTED OTHERWISE

REV	DESCRIPTION	DATE
1	DA AMENDMENT SUBMISSION	14/07/2023
2	70% DD TENDER ISSUE	18/08/2023
3	REVISED DA SUBMISSION	16/02/2023

STRUCTURAL, CIVIL AND SERVICES ENGINEER

aurecon

LEVEL 11 73 Miller Street North Sydney, NSW 2060 AUSTRALIA t: +61(0) 2 9465 5599 f: +61(0) 2 9465 5598


www.aurecongroup.com

ST. GEORGE ILLAWARRA DRAGONS COMMUNITY & HIGH PERFORMANCE TRAINING CENTRE

SHEET TITLE CIVIL WORKS SITE SECTIONS SHEET 3

PROJECT NUMBER 520547 E.WILLIAMS E.SELL G.CHRISTIE SCALE 100% @ A1 NORTH POINT W 00.00 DEG NTS PHASE DRAWING NUMBER
DD 520547-SGID



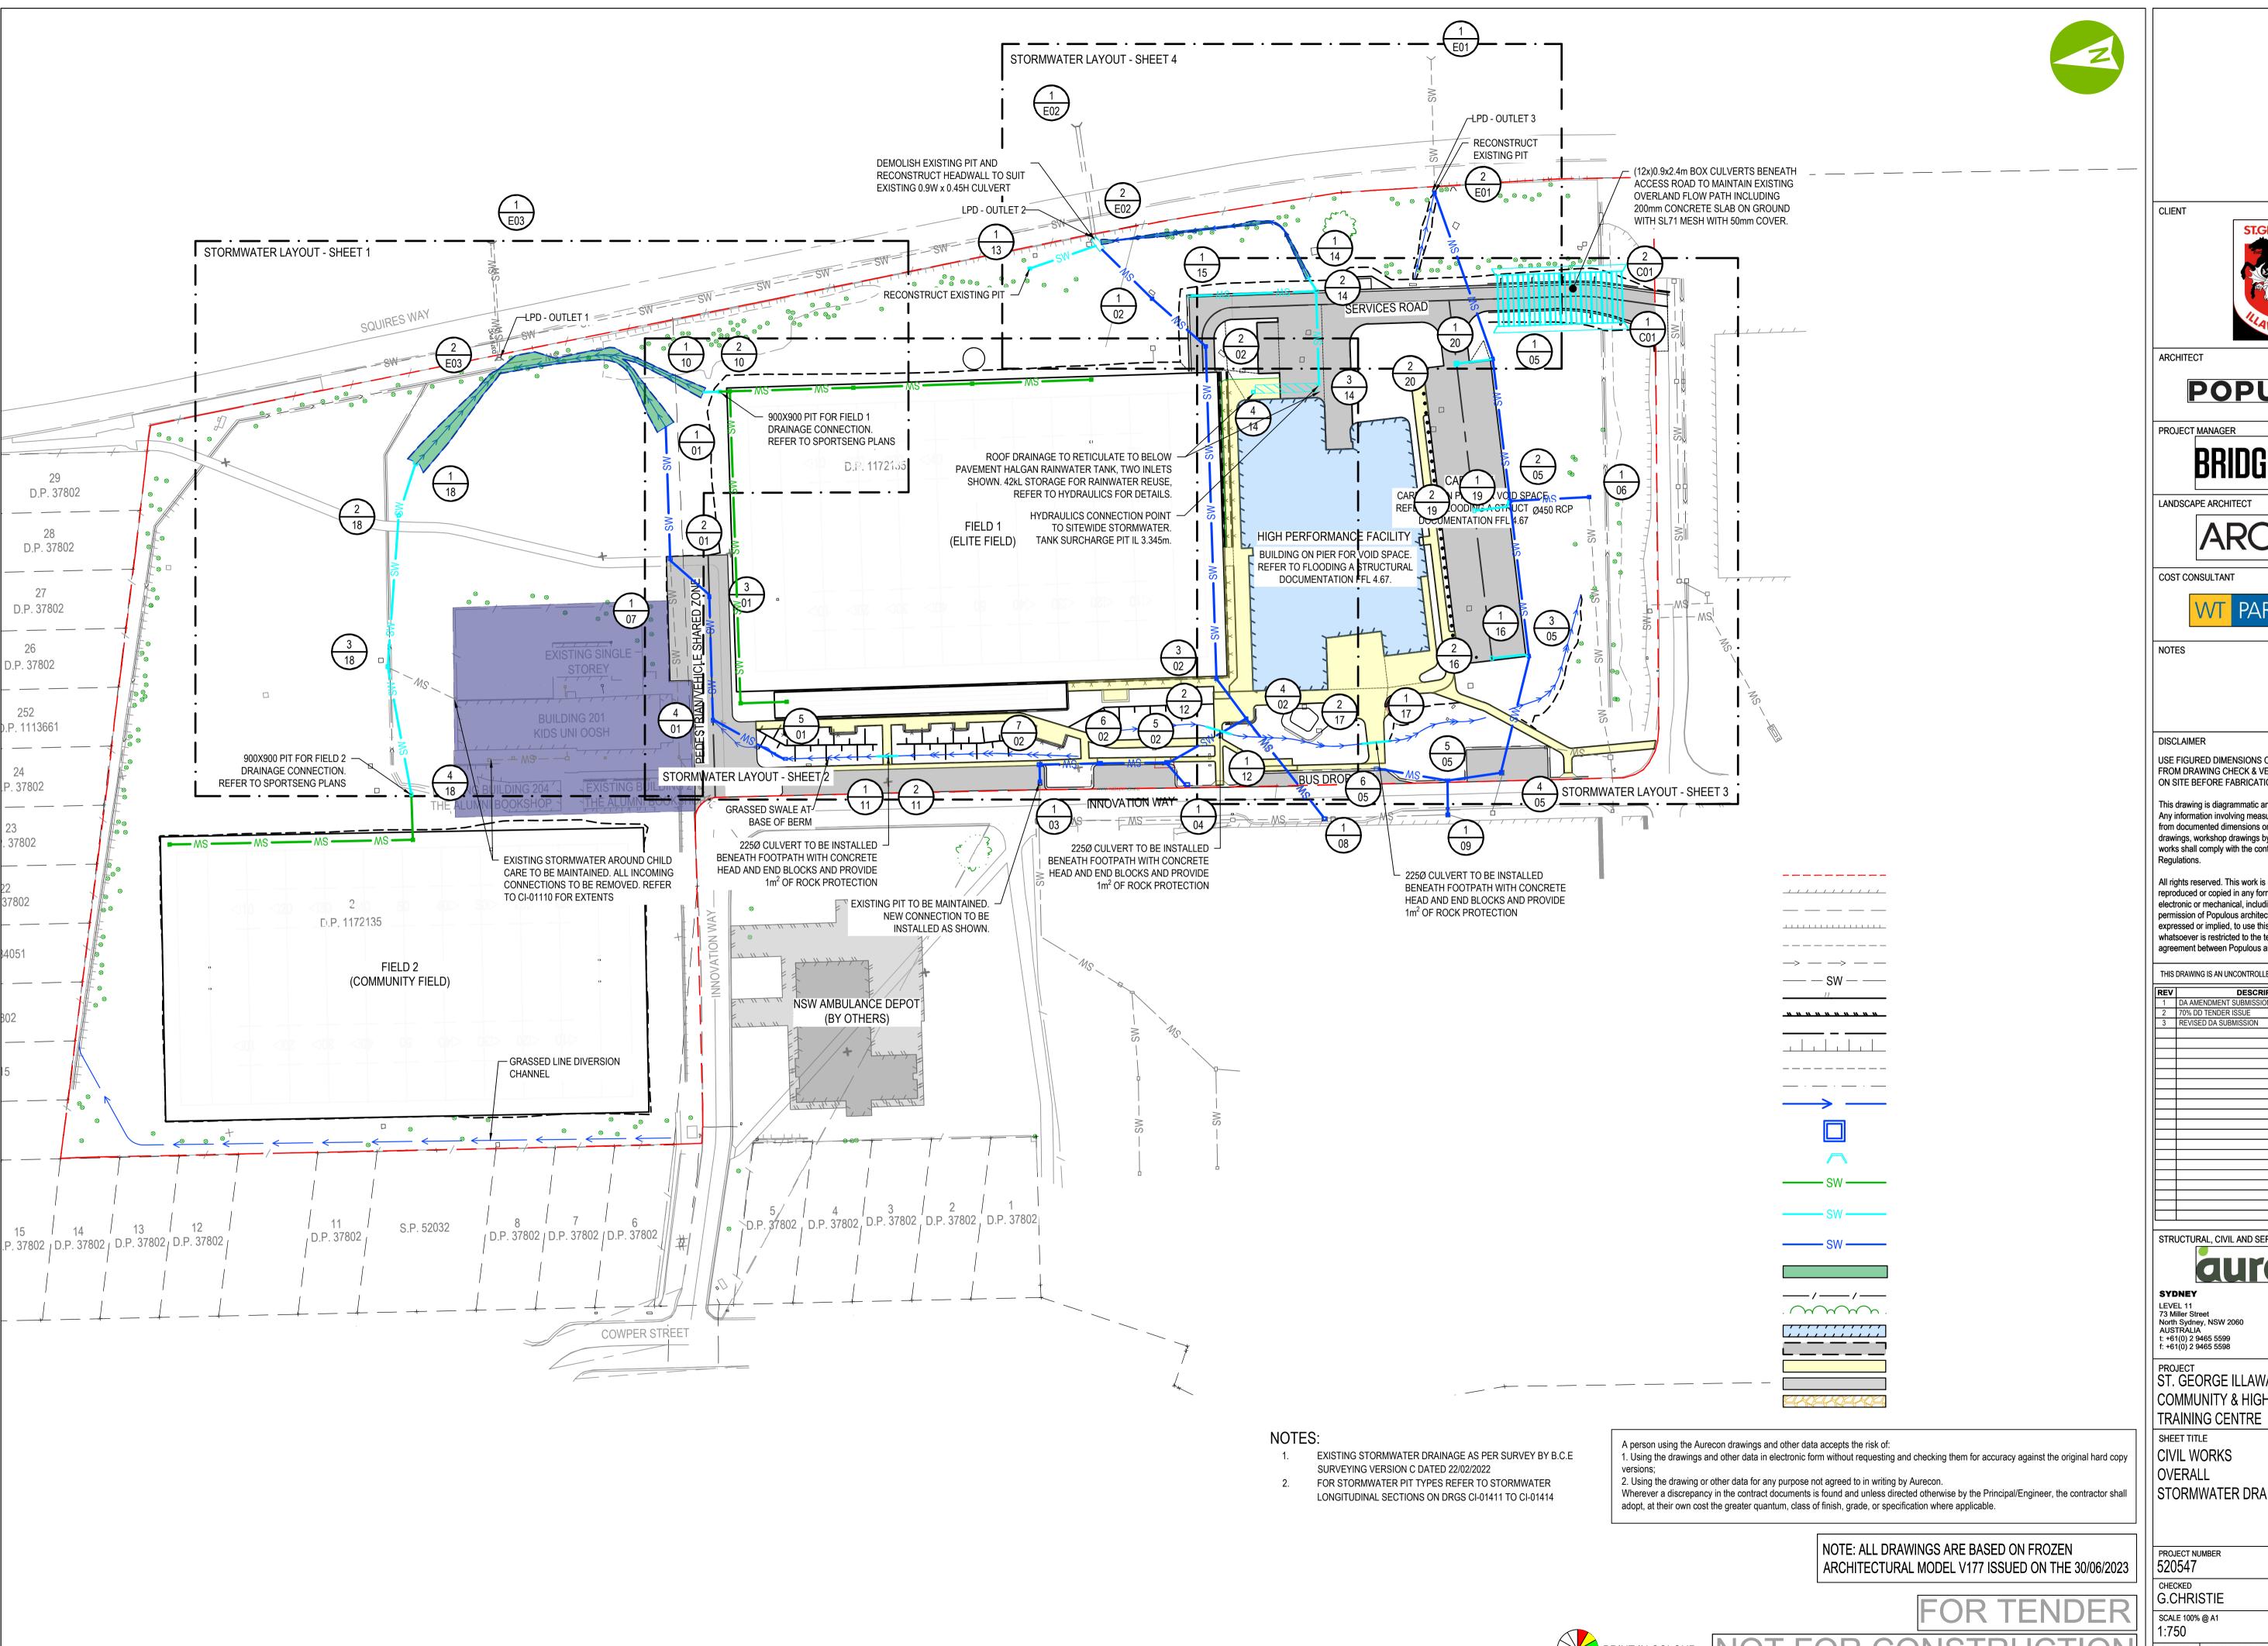



POPULOUS°



COST CONSULTANT



USE FIGURED DIMENSIONS ONLY DO NOT SCALE FROM DRAWING CHECK & VERIFY ALL DIMENSIONS ON SITE BEFORE FABRICATION OR SET OUT.

This drawing is diagrammatic and shows general arrangements. Any information involving measurement of the works shall be taken from documented dimensions on the architectural and structural drawings, workshop drawings by others and conditions on site. The works shall comply with the contract conditions and Statutory

All rights reserved. This work is copyright and cannot be reproduced or copied in any form or by any means graphic electronic or mechanical, including photocopying without the written permission of Populous architects in association. Any licence, expressed or implied, to use this document for any purpose whatsoever is restricted to the terms of the agreement or implied agreement between Populous and the instructing party.

THIS DRAWING IS AN UNCONTROLLED COPY. UNLESS NOTED OTHERWISE

1	DA AMENDMENT SUBMISSION	14/07/2023
2	70% DD TENDER ISSUE	18/08/2023
3	REVISED DA SUBMISSION	16/02/2023
		·
		, i
		, i
		, in the second second
		, in the second second
		, in the second second
		, in the second second
		The state of the s

STRUCTURAL, CIVIL AND SERVICES ENGINEER

aurecon

LEVEL 11 73 Miller Street North Sydney, NSW 2060 AUSTRALIA t: +61(0) 2 9465 5599 f: +61(0) 2 9465 5598

ST. GEORGE ILLAWARRA DRAGONS COMMUNITY & HIGH PERFORMANCE


www.aurecongroup.com


CIVIL WORKS


STORMWATER DRAINAGE

PROJECT NUMBER E.WILLIAMS E.SELL **G.CHRISTIE** SCALE 100% @ A1 NORTH POINT W 00.00 DEG PHASE DRAWING NUMBER DD 520547-SGID

PRINT IN COLOUR NOT FOR CONSTRUCTION

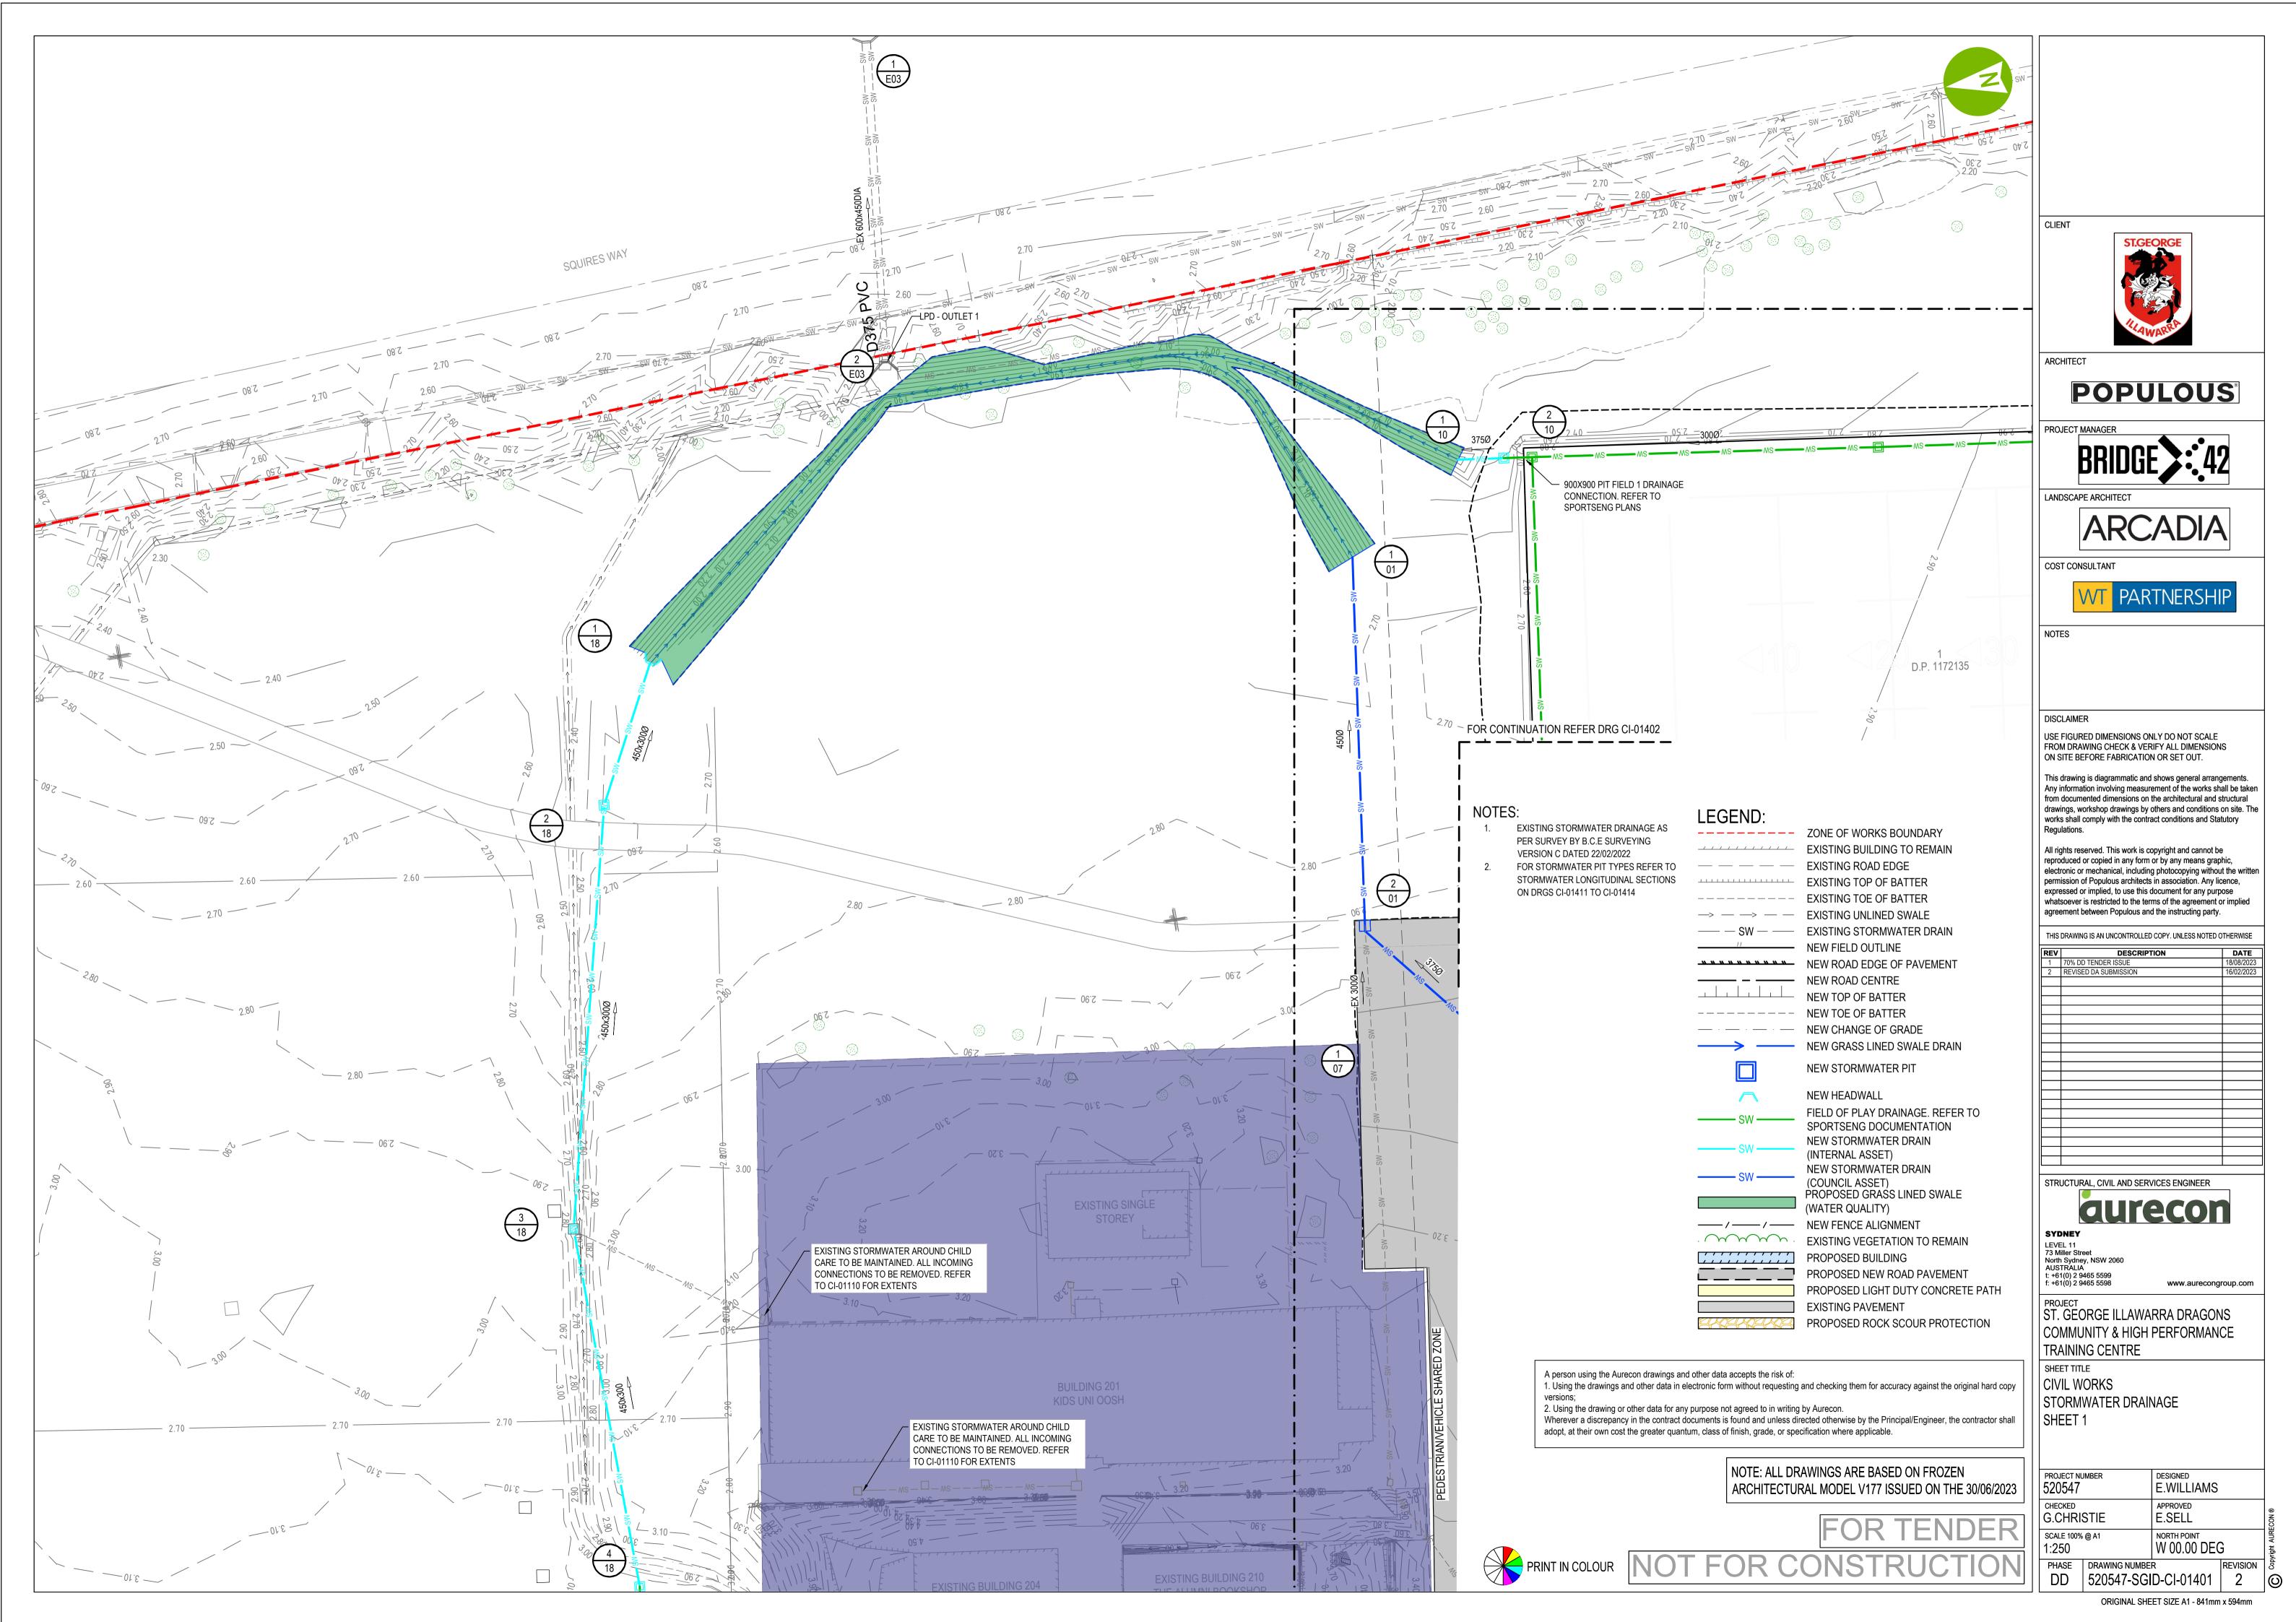

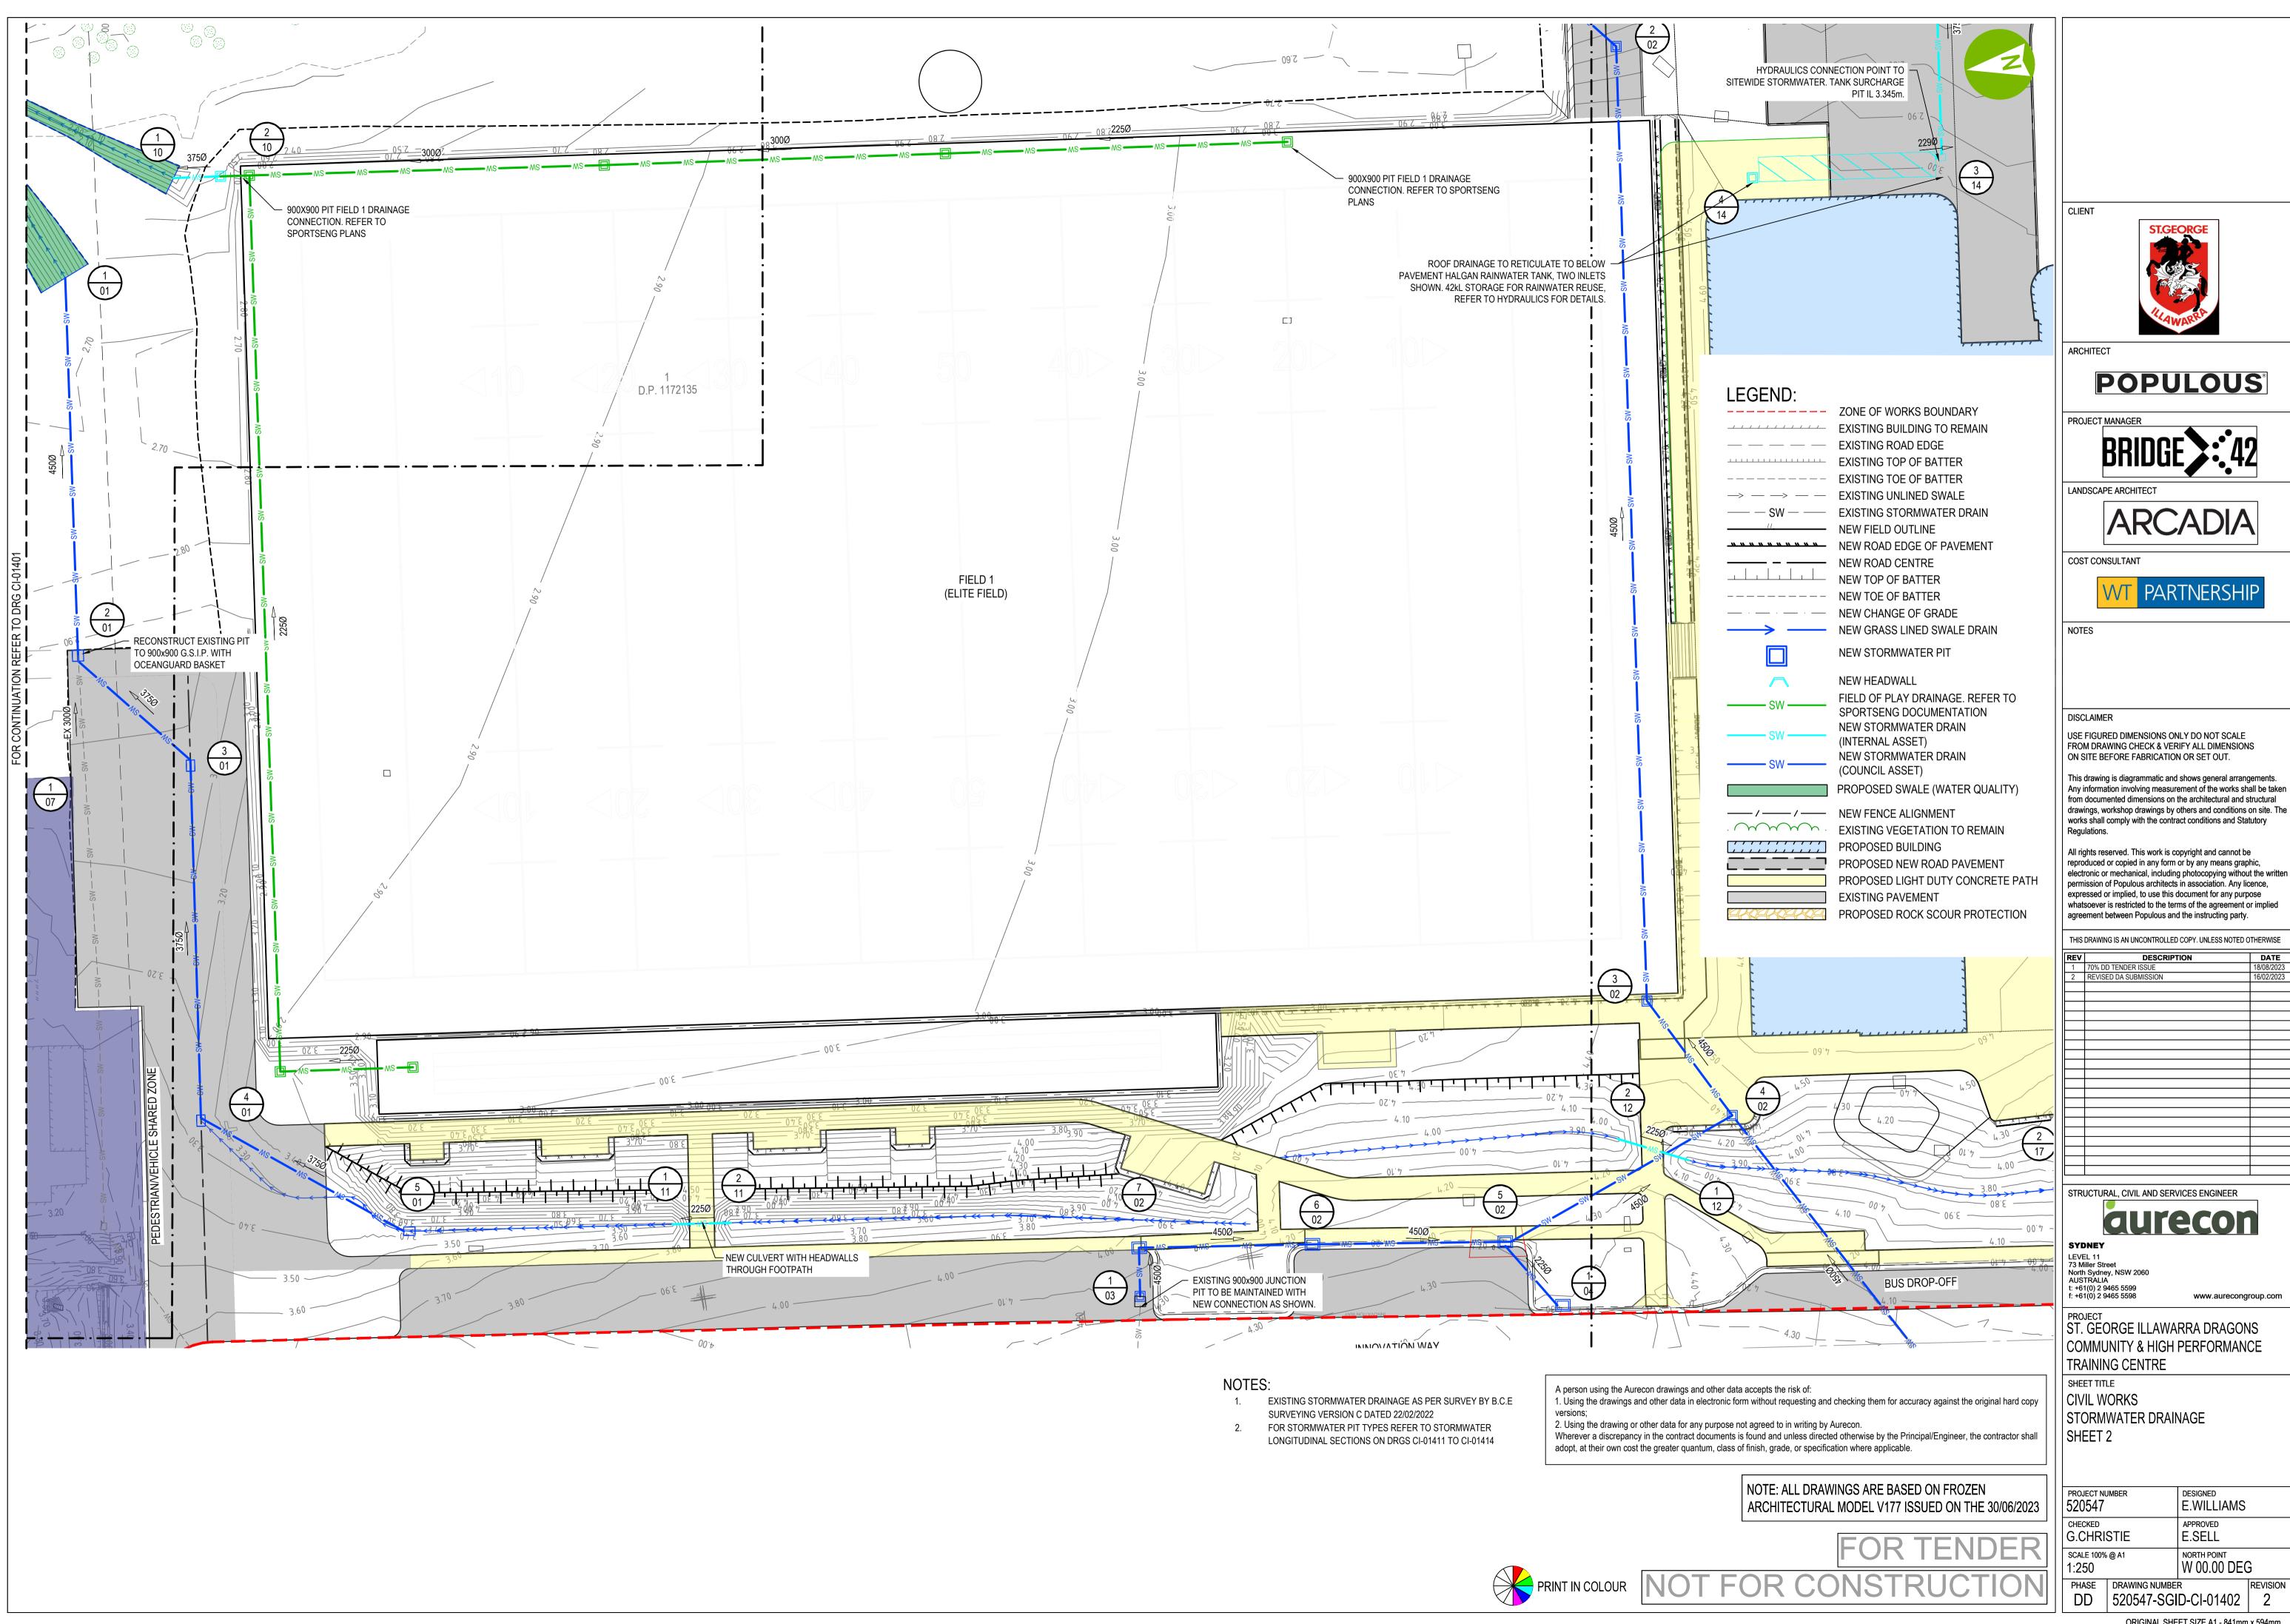

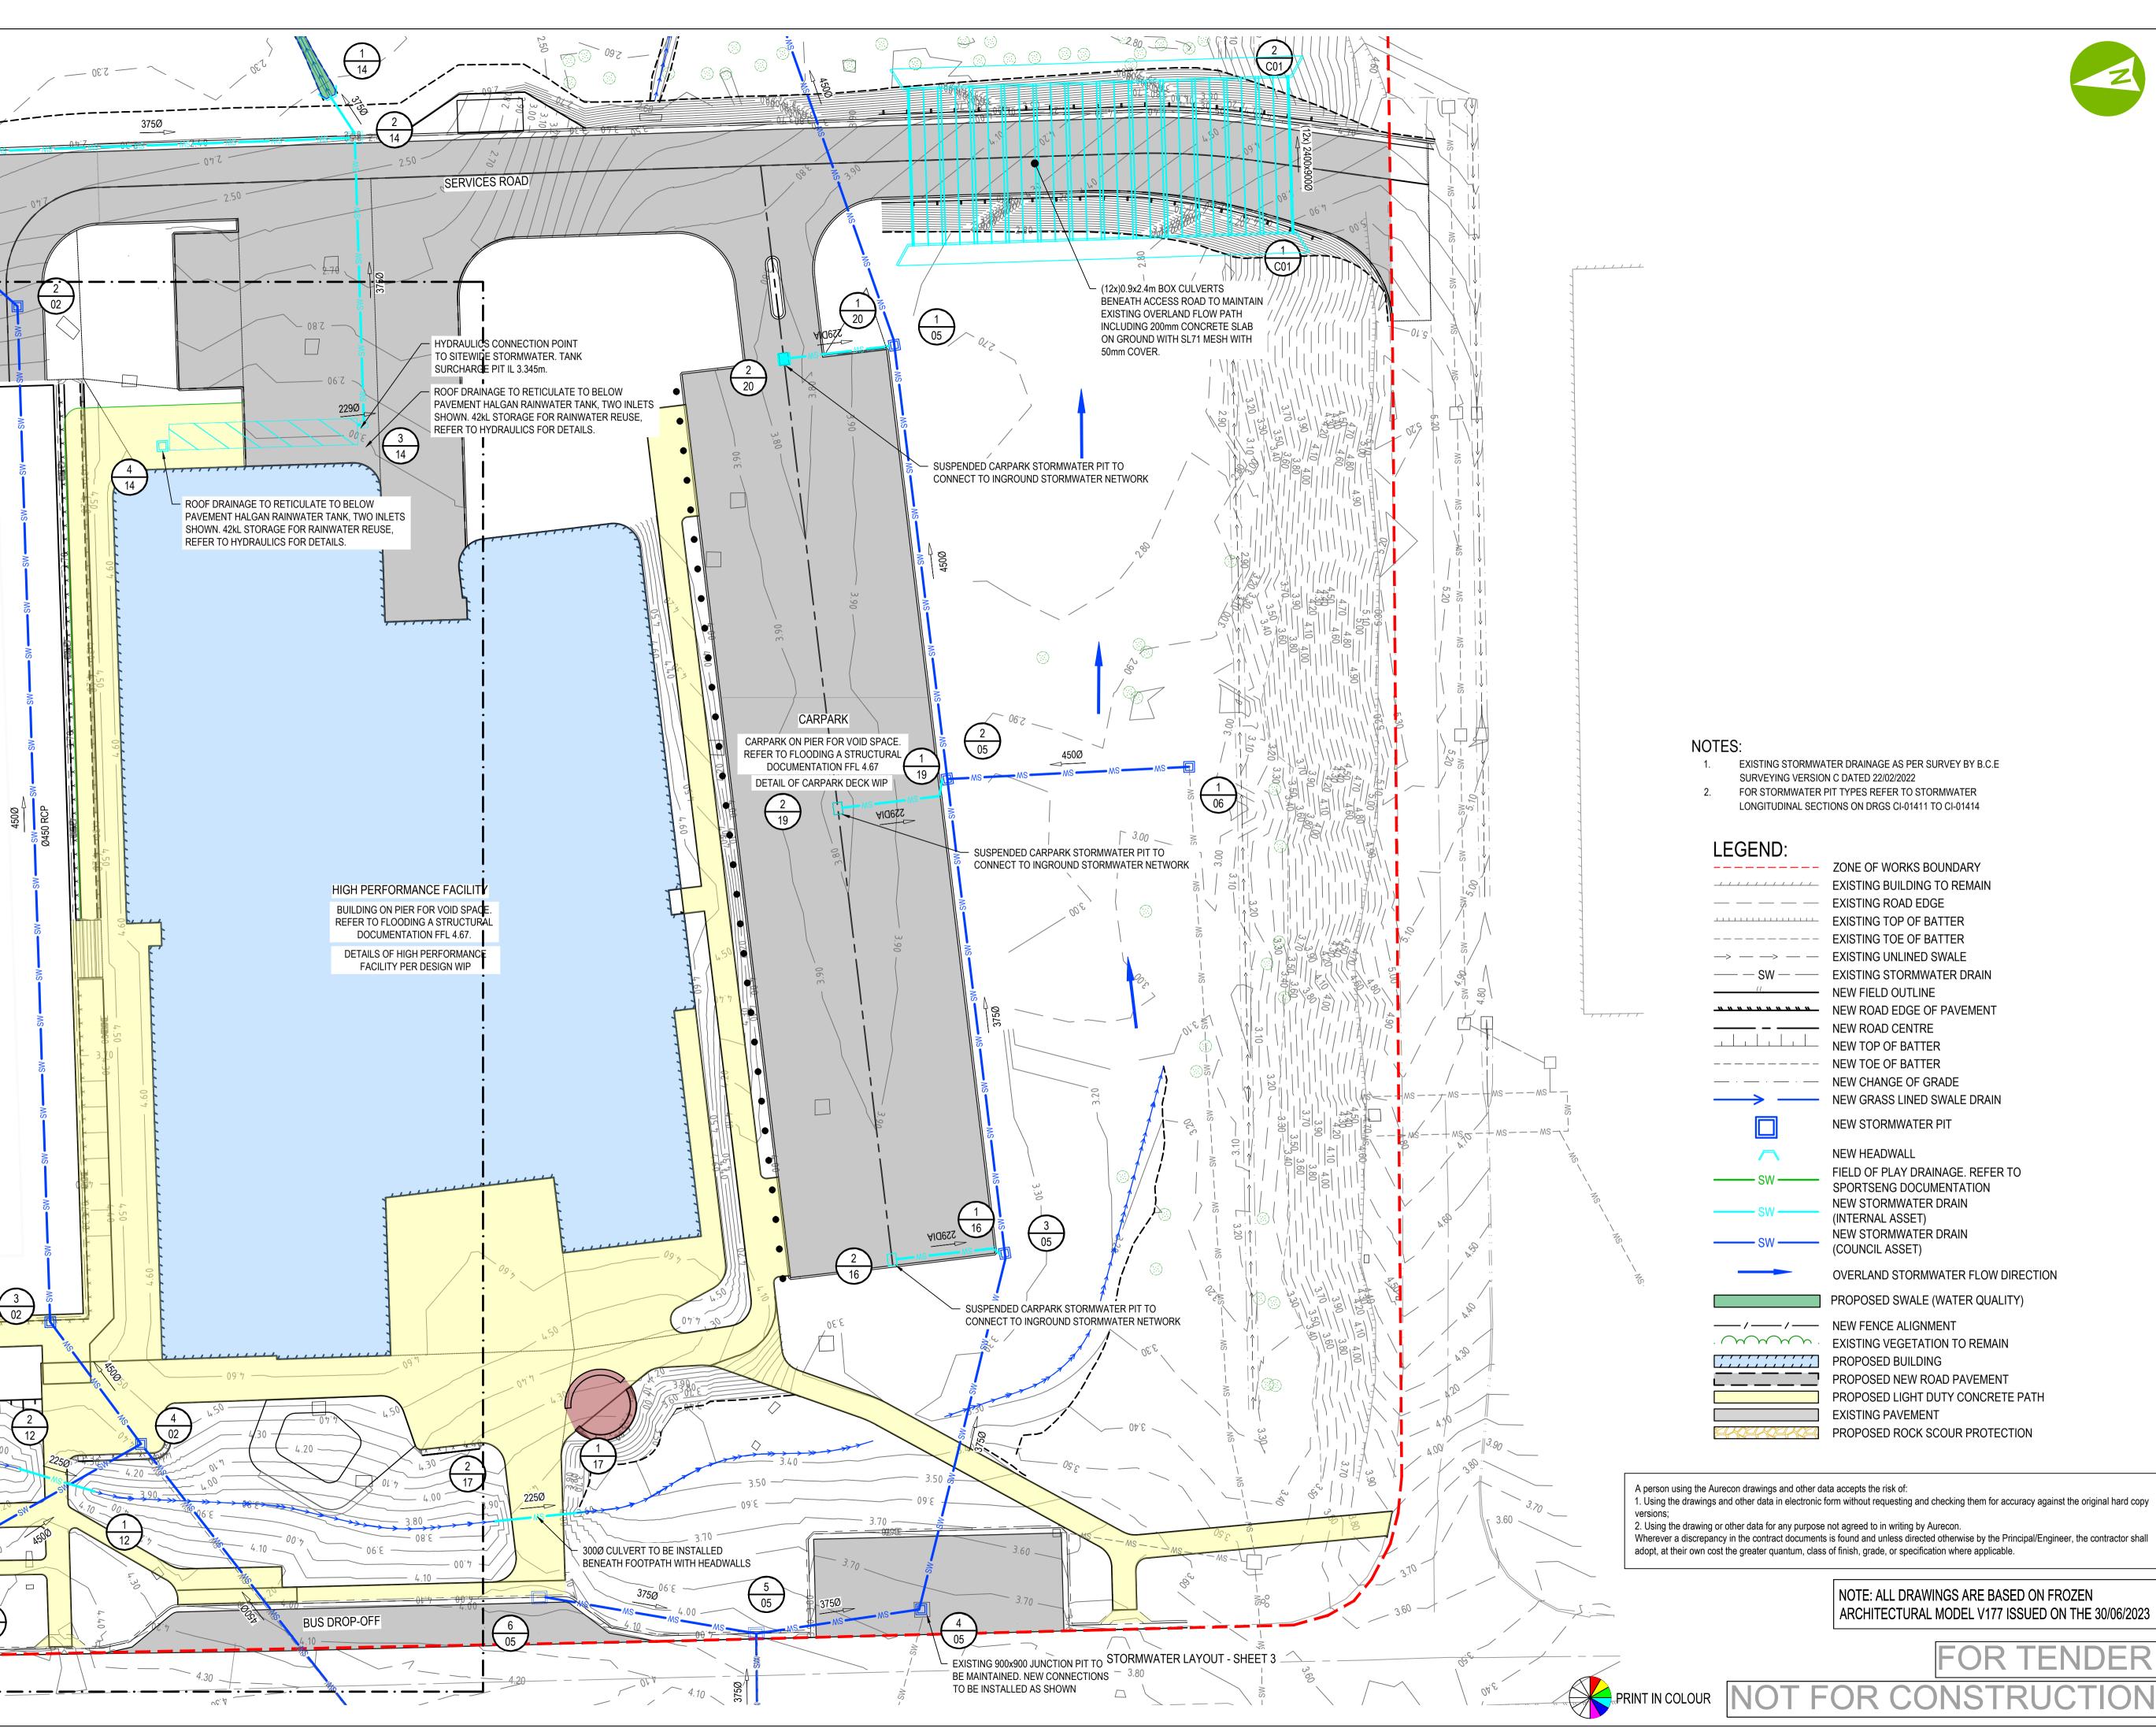





POPULOUS°



COST CONSULTANT



DISCLAIMER

USE FIGURED DIMENSIONS ONLY DO NOT SCALE FROM DRAWING CHECK & VERIFY ALL DIMENSIONS ON SITE BEFORE FABRICATION OR SET OUT.

This drawing is diagrammatic and shows general arrangements. Any information involving measurement of the works shall be taken from documented dimensions on the architectural and structural drawings, workshop drawings by others and conditions on site. The works shall comply with the contract conditions and Statutory

All rights reserved. This work is copyright and cannot be reproduced or copied in any form or by any means graphic, electronic or mechanical, including photocopying without the written permission of Populous architects in association. Any licence, expressed or implied, to use this document for any purpose whatsoever is restricted to the terms of the agreement or implied

agreement between Populous and the instructing party.

THIS DRAWING IS AN UNCONTROLLED COPY. UNLESS NOTED OTHERWISE

2	REVISED DA SUBMISSION	16/02/2023

STRUCTURAL, CIVIL AND SERVICES ENGINEER

aurecon

LEVEL 11 73 Miller Street North Sydney, NSW 2060 AUSTRALIA t: +61(0) 2 9465 5599 f: +61(0) 2 9465 5598

SHEET 3

www.aurecongroup.com


ST. GEORGE ILLAWARRA DRAGONS COMMUNITY & HIGH PERFORMANCE TRAINING CENTRE

SHEET TITLE CIVIL WORKS STORMWATER DRAINAGE

PROJECT NUMBER 520547 E.WILLIAMS E.SELL **G.CHRISTIE** SCALE 100% @ A1 NORTH POINT W 00.00 DEG 1:250

PHASE DRAWING NUMBER DD 520547-SGID 520547-SGID-CI-01403 ORIGINAL SHEET SIZE A1 - 841mm x 594mm



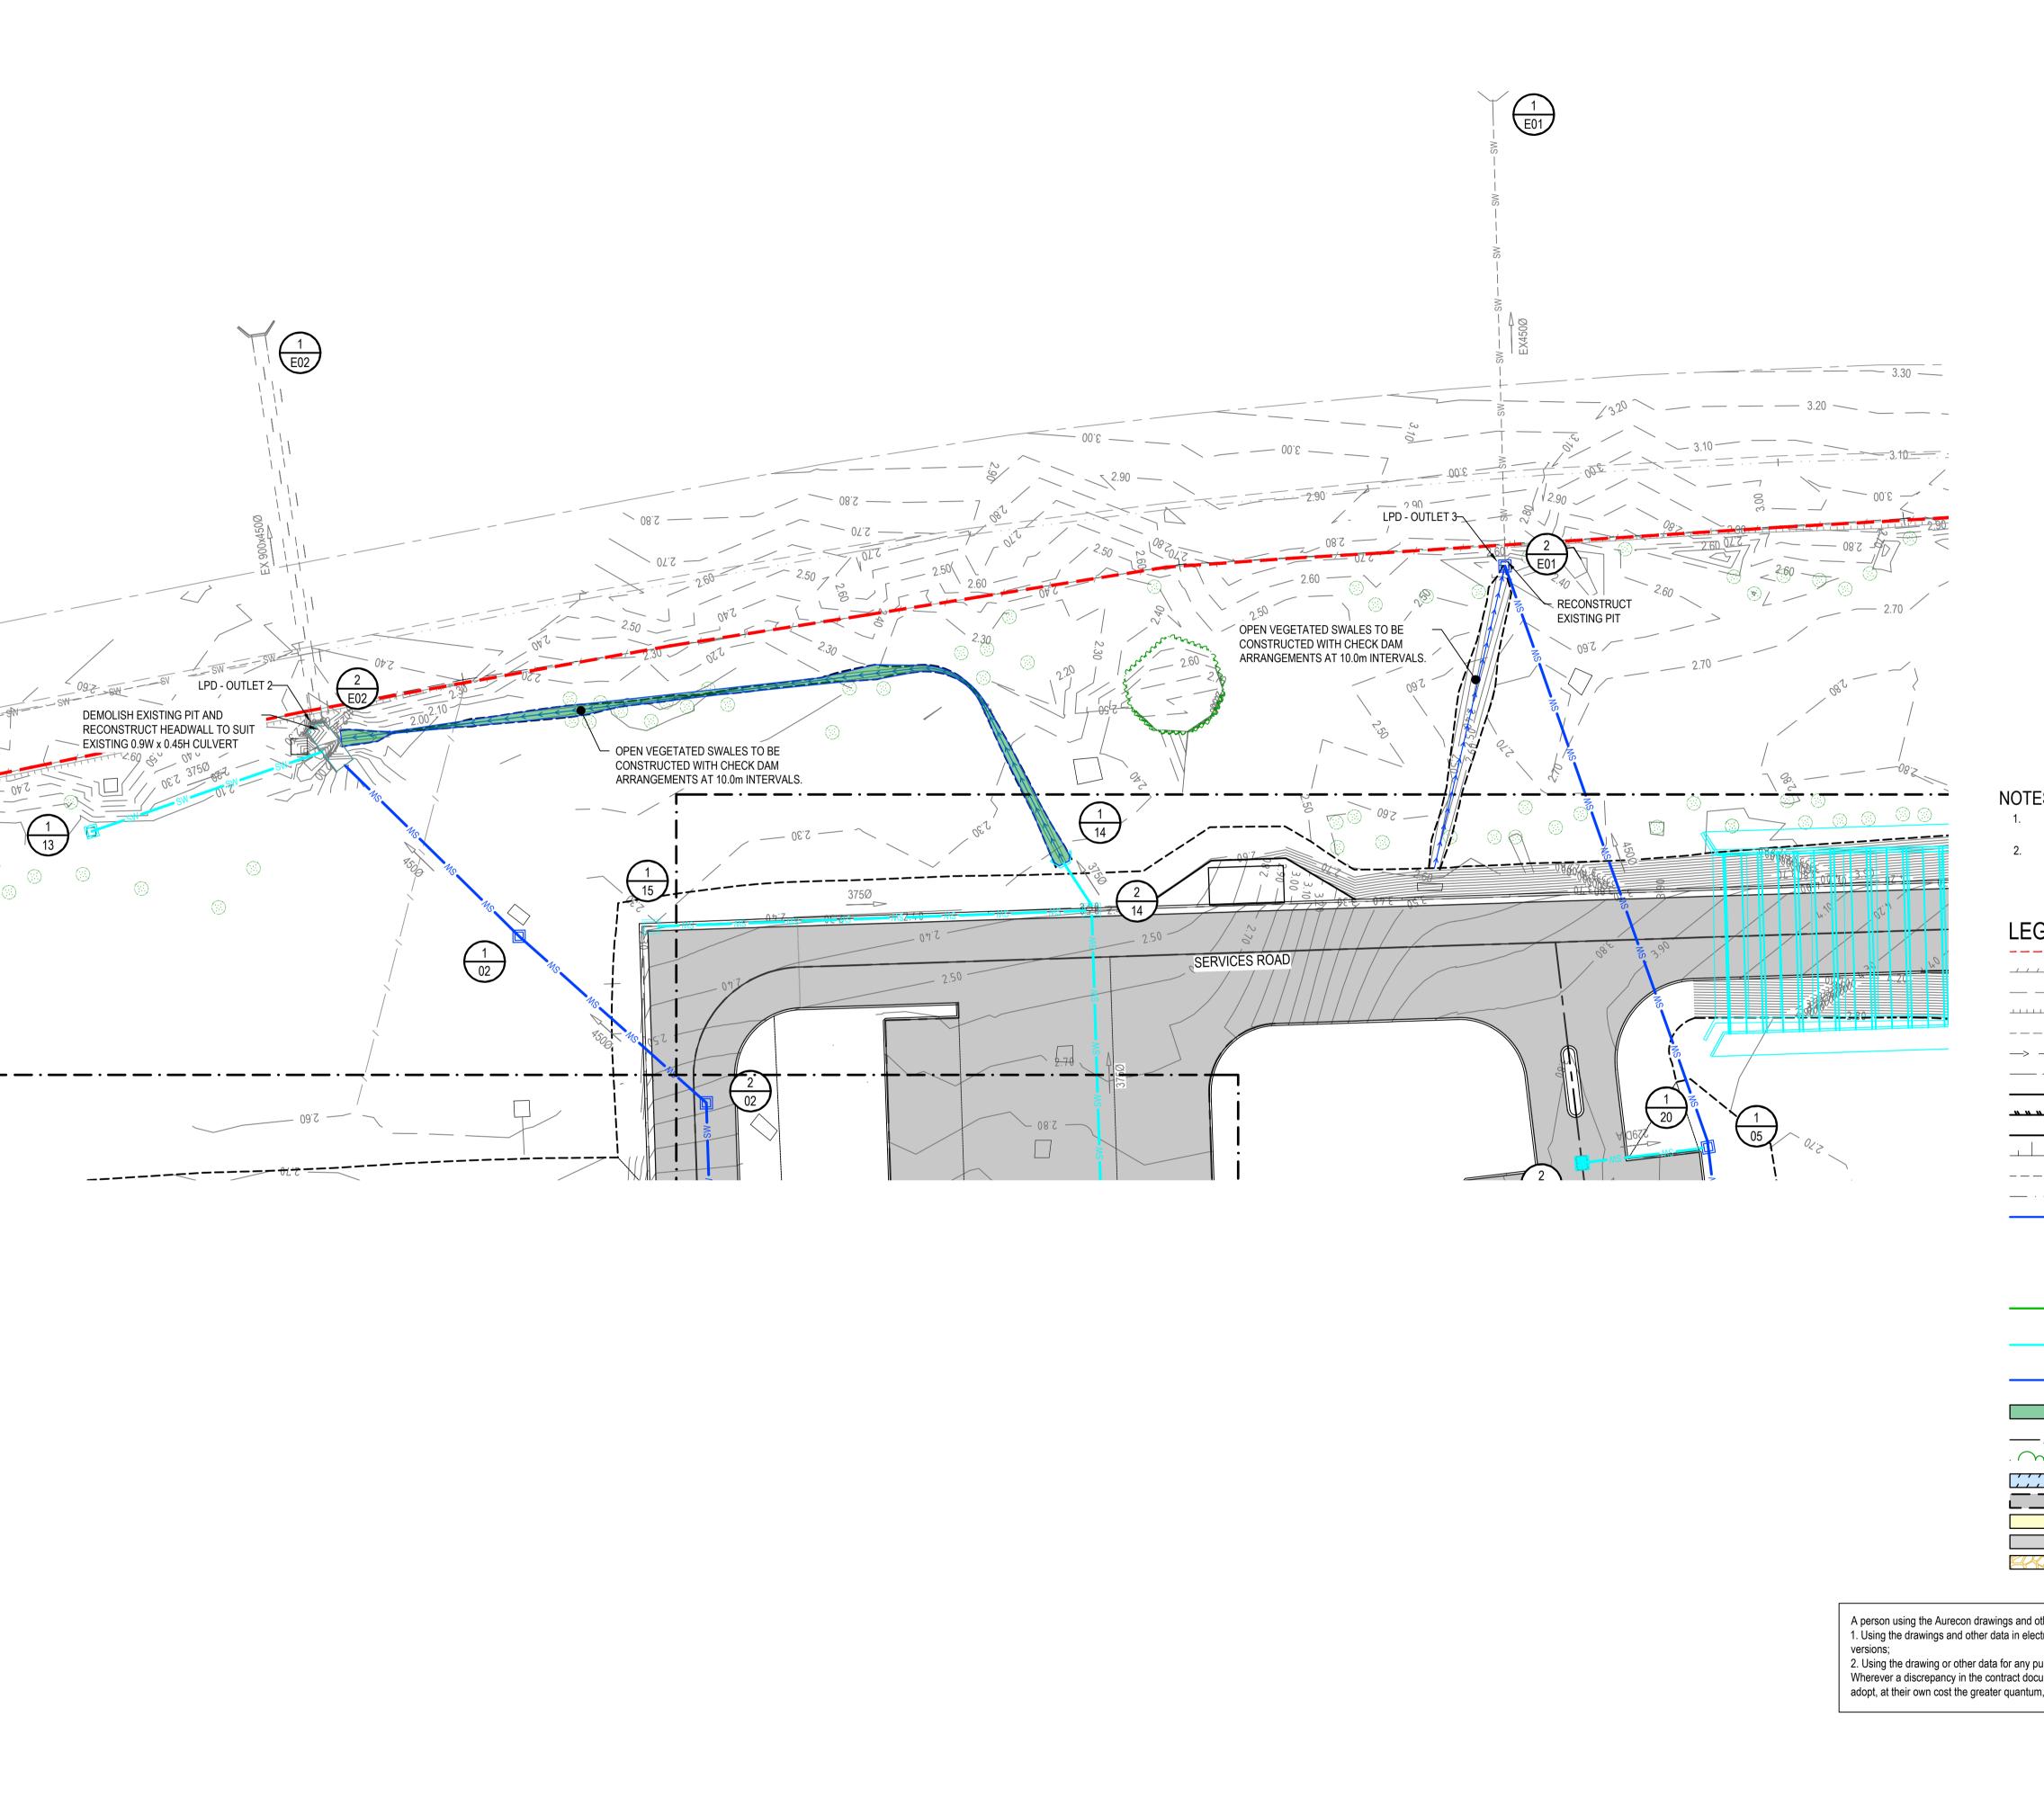

EXISTING STORMWATER DRAINAGE AS PER SURVEY BY B.C.E SURVEYING VERSION C DATED 22/02/2022

2. FOR STORMWATER PIT TYPES REFER TO STORMWATER LONGITUDINAL SECTIONS ON DRGS CI-01411 TO CI-01414

LEGEND:

---- ZONE OF WORKS BOUNDARY EXISTING BUILDING TO REMAIN — — — EXISTING ROAD EDGE EXISTING TOP OF BATTER ---- EXISTING TOE OF BATTER -> -- -> -- EXISTING UNLINED SWALE —— — SW — — EXISTING STORMWATER DRAIN NEW FIELD OUTLINE NEW ROAD EDGE OF PAVEMENT ——— — NEW ROAD CENTRE NEW TOP OF BATTER ---- NEW TOE OF BATTER — NEW CHANGE OF GRADE NEW GRASS LINED SWALE DRAIN **NEW STORMWATER PIT NEW HEADWALL**

FIELD OF PLAY DRAINAGE. REFER TO SPORTSENG DOCUMENTATION NEW STORMWATER DRAIN (INTERNAL ASSET) NEW STORMWATER DRAIN

(COUNCIL ASSET) PROPOSED SWALE (WATER QUALITY)

——/——/—— NEW FENCE ALIGNMENT EXISTING VEGETATION TO REMAIN PROPOSED BUILDING 1111111111 PROPOSED NEW ROAD PAVEMENT PROPOSED LIGHT DUTY CONCRETE PATH

> EXISTING PAVEMENT PROPOSED ROCK SCOUR PROTECTION

A person using the Aurecon drawings and other data accepts the risk of:

1. Using the drawings and other data in electronic form without requesting and checking them for accuracy against the original hard copy

2. Using the drawing or other data for any purpose not agreed to in writing by Aurecon.

Wherever a discrepancy in the contract documents is found and unless directed otherwise by the Principal/Engineer, the contractor shall adopt, at their own cost the greater quantum, class of finish, grade, or specification where applicable.

> NOTE: ALL DRAWINGS ARE BASED ON FROZEN ARCHITECTURAL MODEL V177 ISSUED ON THE 30/06/2023



POPULOUS°



COST CONSULTANT



DISCLAIMER

USE FIGURED DIMENSIONS ONLY DO NOT SCALE FROM DRAWING CHECK & VERIFY ALL DIMENSIONS ON SITE BEFORE FABRICATION OR SET OUT.

This drawing is diagrammatic and shows general arrangements. Any information involving measurement of the works shall be taken from documented dimensions on the architectural and structural drawings, workshop drawings by others and conditions on site. The works shall comply with the contract conditions and Statutory

All rights reserved. This work is copyright and cannot be reproduced or copied in any form or by any means graphic, electronic or mechanical, including photocopying without the written permission of Populous architects in association. Any licence, expressed or implied, to use this document for any purpose whatsoever is restricted to the terms of the agreement or implied agreement between Populous and the instructing party.

REV	DESCRIPTION	DATE
1	70% DD TENDER ISSUE	18/08/20
2	REVISED DA SUBMISSION	16/02/20

STRUCTURAL, CIVIL AND SERVICES ENGINEER

aurecon

LEVEL 11 73 Miller Street North Sydney, NSW 2060 AUSTRALIA t: +61(0) 2 9465 5599 f: +61(0) 2 9465 5598


ST. GEORGE ILLAWARRA DRAGONS COMMUNITY & HIGH PERFORMANCE TRAINING CENTRE

www.aurecongroup.com

SHEET TITLE CIVIL WORKS STORMWATER DRAINAGE SHEET 4

PROJECT NUMBER 520547 E.WILLIAMS E.SELL G.CHRISTIE SCALE 100% @ A1 NORTH POINT W 00.00 DEG 1:250



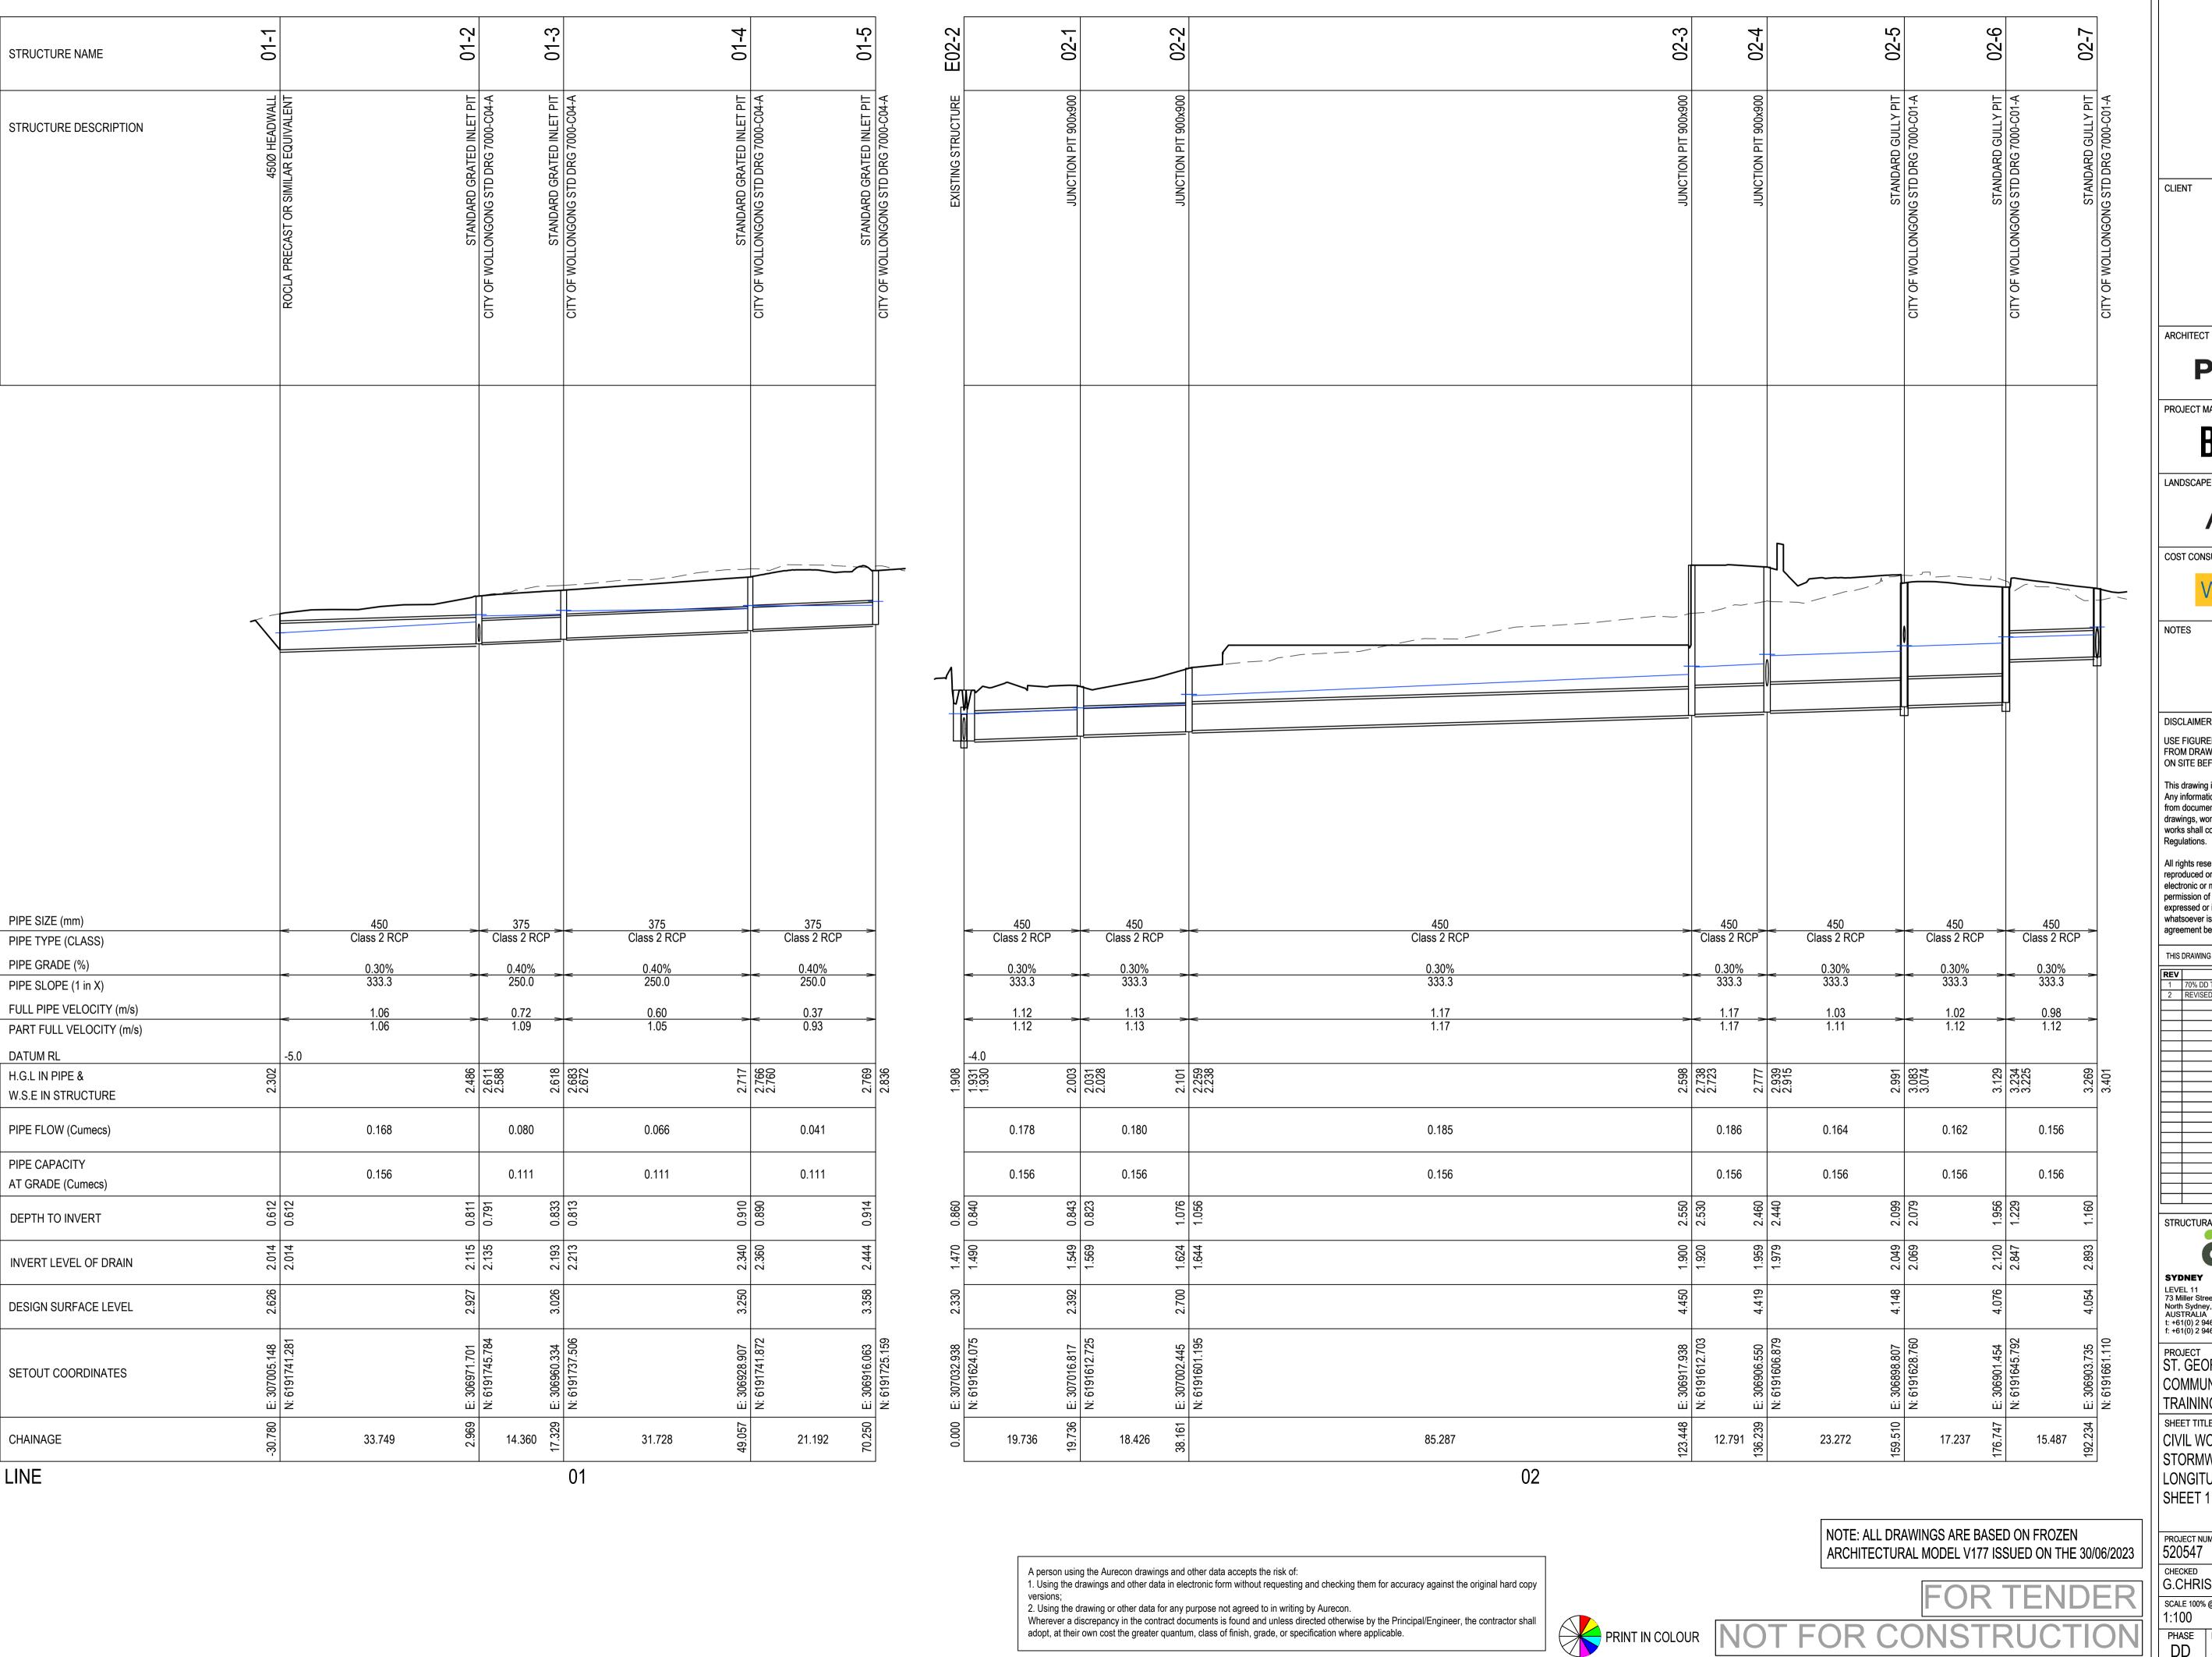



POPULOUS°

ARCADIA

COST CONSULTANT



DISCLAIMER

USE FIGURED DIMENSIONS ONLY DO NOT SCALE FROM DRAWING CHECK & VERIFY ALL DIMENSIONS ON SITE BEFORE FABRICATION OR SET OUT.

This drawing is diagrammatic and shows general arrangements. Any information involving measurement of the works shall be taken from documented dimensions on the architectural and structural drawings, workshop drawings by others and conditions on site. The works shall comply with the contract conditions and Statutory

All rights reserved. This work is copyright and cannot be electronic or mechanical, including photocopying without the written permission of Populous architects in association. Any licence, expressed or implied, to use this document for any purpose whatsoever is restricted to the terms of the agreement or implied

agreement between Populous and the instructing party. THIS DRAWING IS AN UNCONTROLLED COPY. UNLESS NOTED OTHERWISE

70% DD TENDER ISSUE	18/08/2023
REVISED DA SUBMISSION	16/02/2023

aurecon


LEVEL 11 73 Miller Street North Sydney, NSW 2060 AUSTRALIA t: +61(0) 2 9465 5599 f: +61(0) 2 9465 5598

ST. GEORGE ILLAWARRA DRAGONS COMMUNITY & HIGH PERFORMANCE TRAINING CENTRE

www.aurecongroup.com

SHEET TITLE CIVIL WORKS STORMWATER DRAINAGE LONGITUDINAL SECTIONS

	PROJECT NUMBER 520547		E.WILLIAMS	
	CHECKED G.CHRISTIE		APPROVED E.SELL	
	SCALE 100% @ A1 1:100		NORTH POINT W 00.00 DEG	
l	PHASE DRAWING NUMBER		R	REVISION

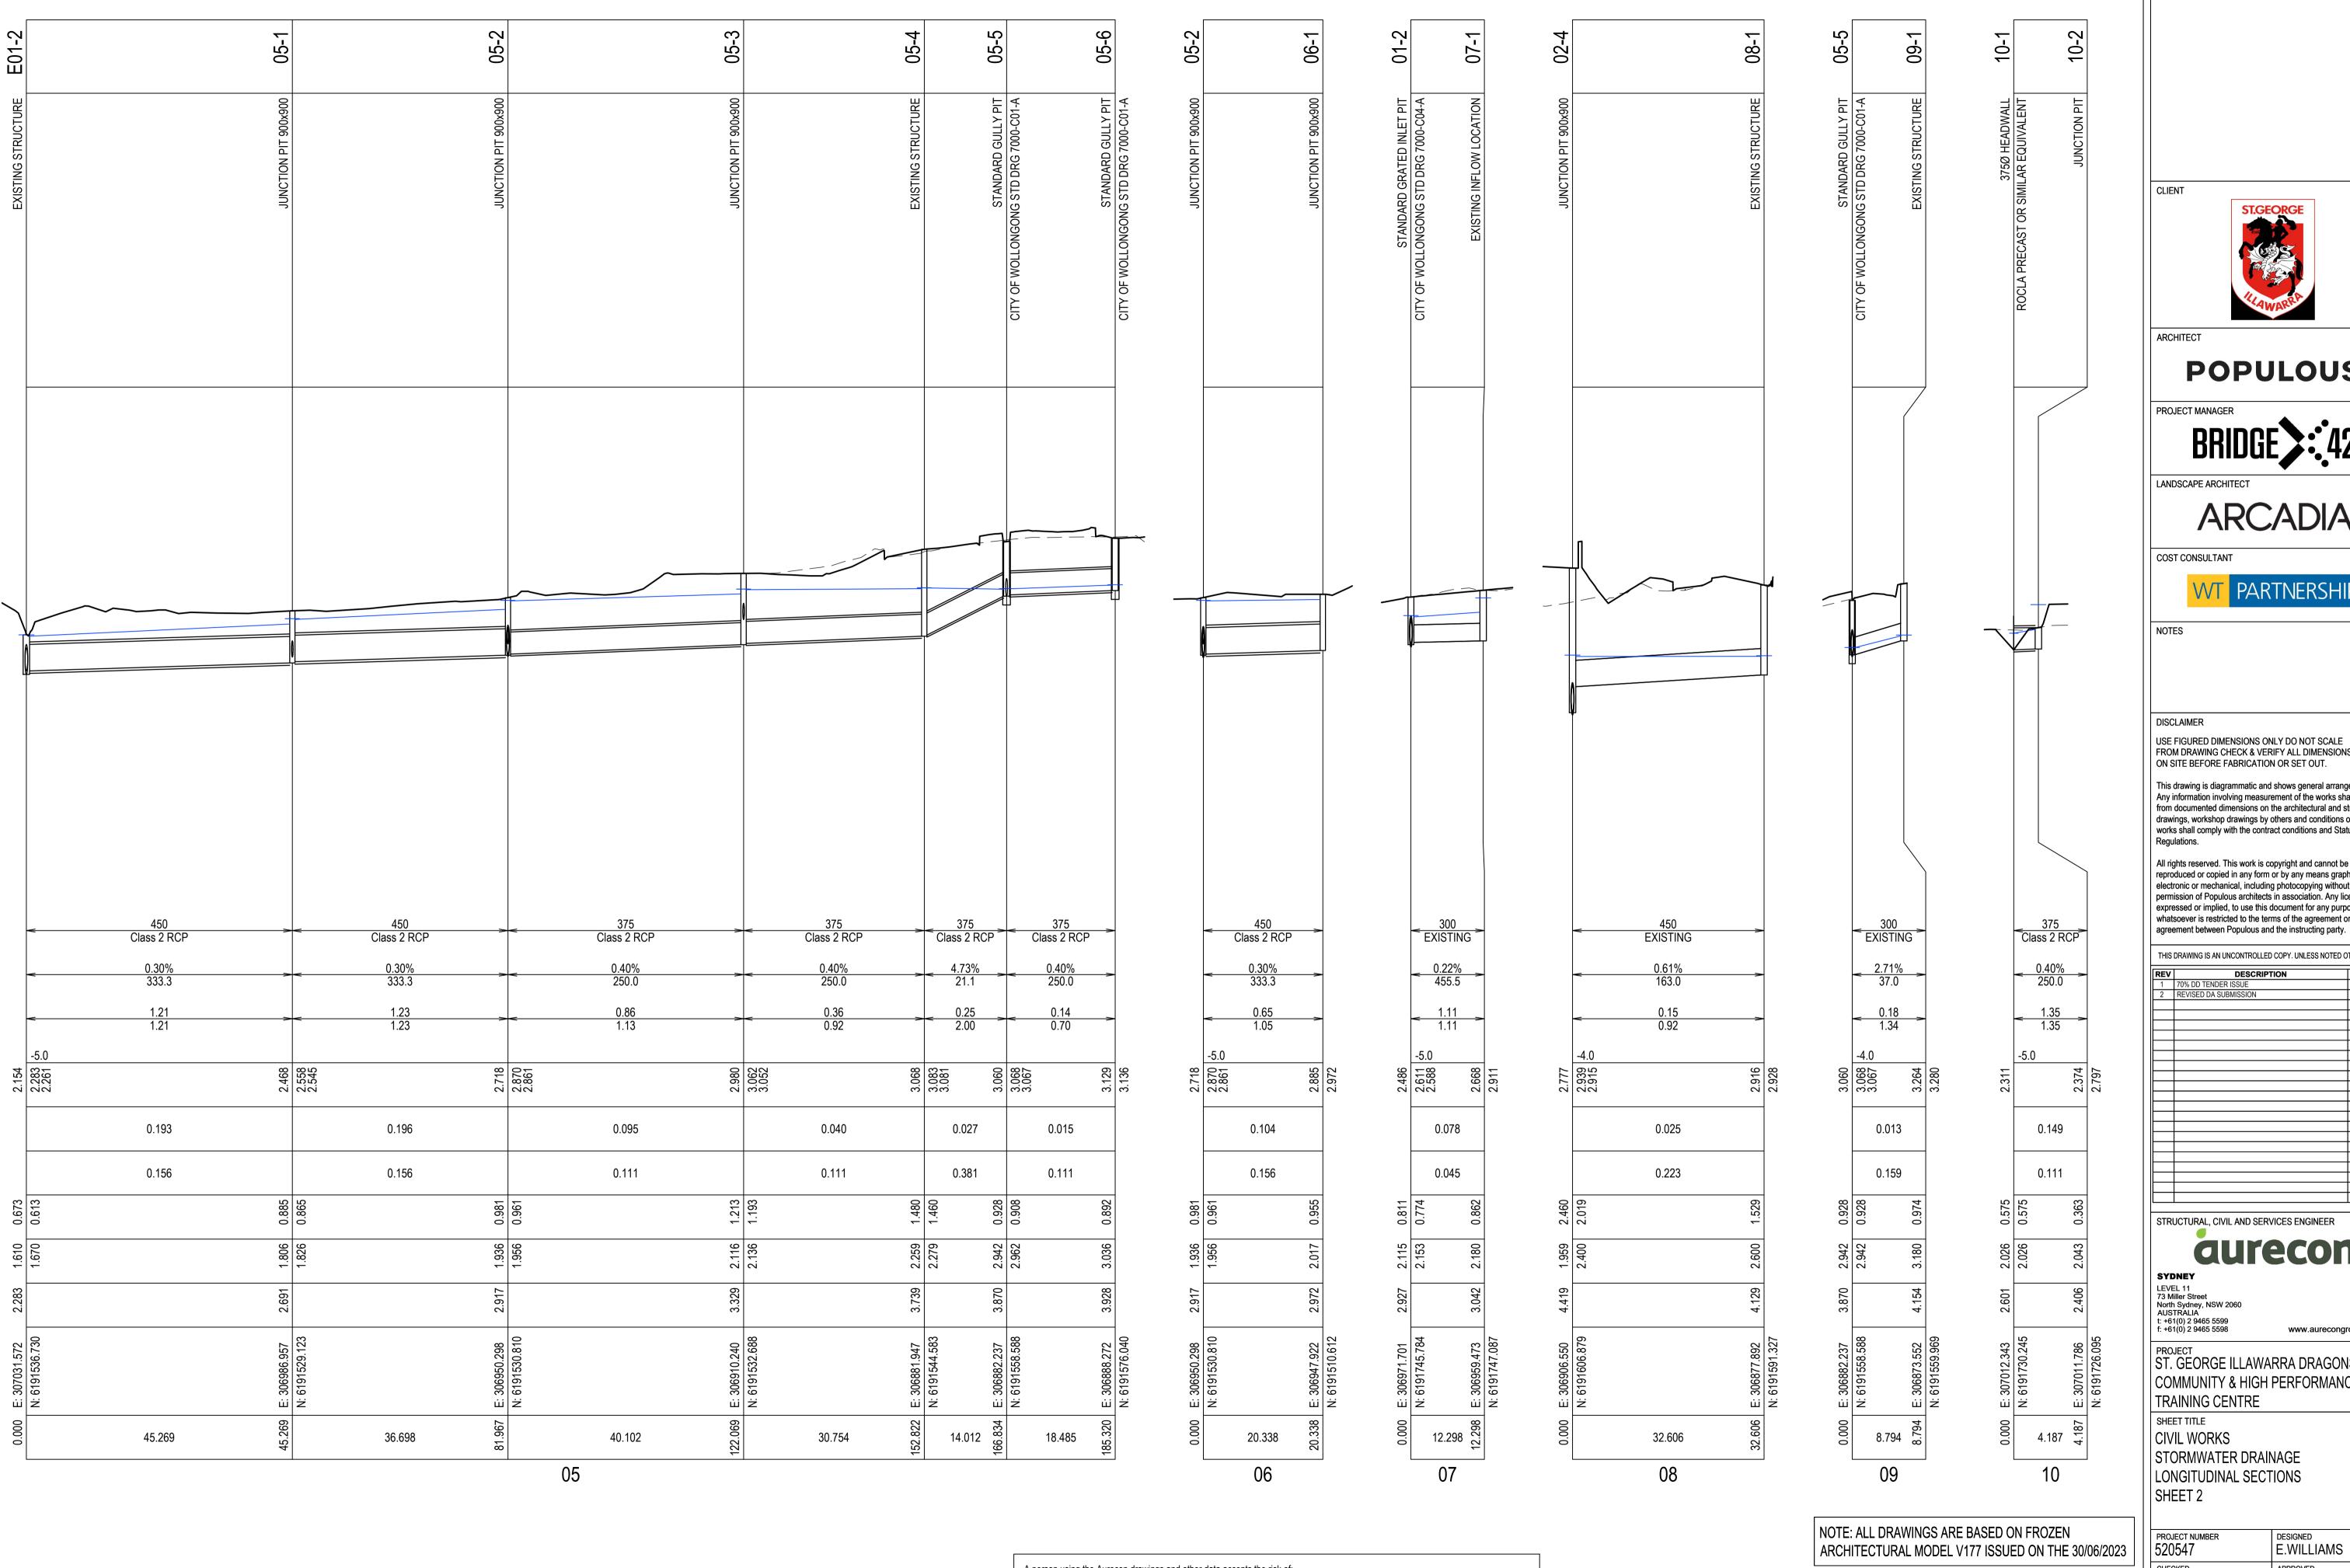



POPULOUS[®]

ARCADIA

COST CONSULTANT



DISCLAIMER

USE FIGURED DIMENSIONS ONLY DO NOT SCALE FROM DRAWING CHECK & VERIFY ALL DIMENSIONS ON SITE BEFORE FABRICATION OR SET OUT.

This drawing is diagrammatic and shows general arrangements. Any information involving measurement of the works shall be taken from documented dimensions on the architectural and structural drawings, workshop drawings by others and conditions on site. The works shall comply with the contract conditions and Statutory

All rights reserved. This work is copyright and cannot be electronic or mechanical, including photocopying without the written permission of Populous architects in association. Any licence, expressed or implied, to use this document for any purpose whatsoever is restricted to the terms of the agreement or implied

THIS DRAWING IS AN UNCONTROLLED COPY. UNLESS NOTED OTHERWISE | REV | DESCRIPTION | 1 | 70% DD TENDER ISSUE | 2 | REVISED DA SUBMISSION |

STRUCTURAL, CIVIL AND SERVICES ENGINEER

aurecon

LEVEL 11 73 Miller Street North Sydney, NSW 2060 AUSTRALIA t: +61(0) 2 9465 5599 f: +61(0) 2 9465 5598

FOR TENDER

PRINT IN COLOUR NOT FOR CONSTRUCTION

www.aurecongroup.com

ST. GEORGE ILLAWARRA DRAGONS COMMUNITY & HIGH PERFORMANCE TRAINING CENTRE


SHEET TITLE CIVIL WORKS STORMWATER DRAINAGE LONGITUDINAL SECTIONS SHEET 2

PROJECT NUMBER 520547 E.WILLIAMS E.SELL G.CHRISTIE SCALE 100% @ A1 NORTH POINT W 00.00 DEG 1:100 PHASE DRAWING NUMBER DD 520547-SGID 520547-SGID-CI-01412 2

A person using the Aurecon drawings and other data accepts the risk of: 1. Using the drawings and other data in electronic form without requesting and checking them for accuracy against the original hard copy

2. Using the drawing or other data for any purpose not agreed to in writing by Aurecon.

Wherever a discrepancy in the contract documents is found and unless directed otherwise by the Principal/Engineer, the contractor shall adopt, at their own cost the greater quantum, class of finish, grade, or specification where applicable.

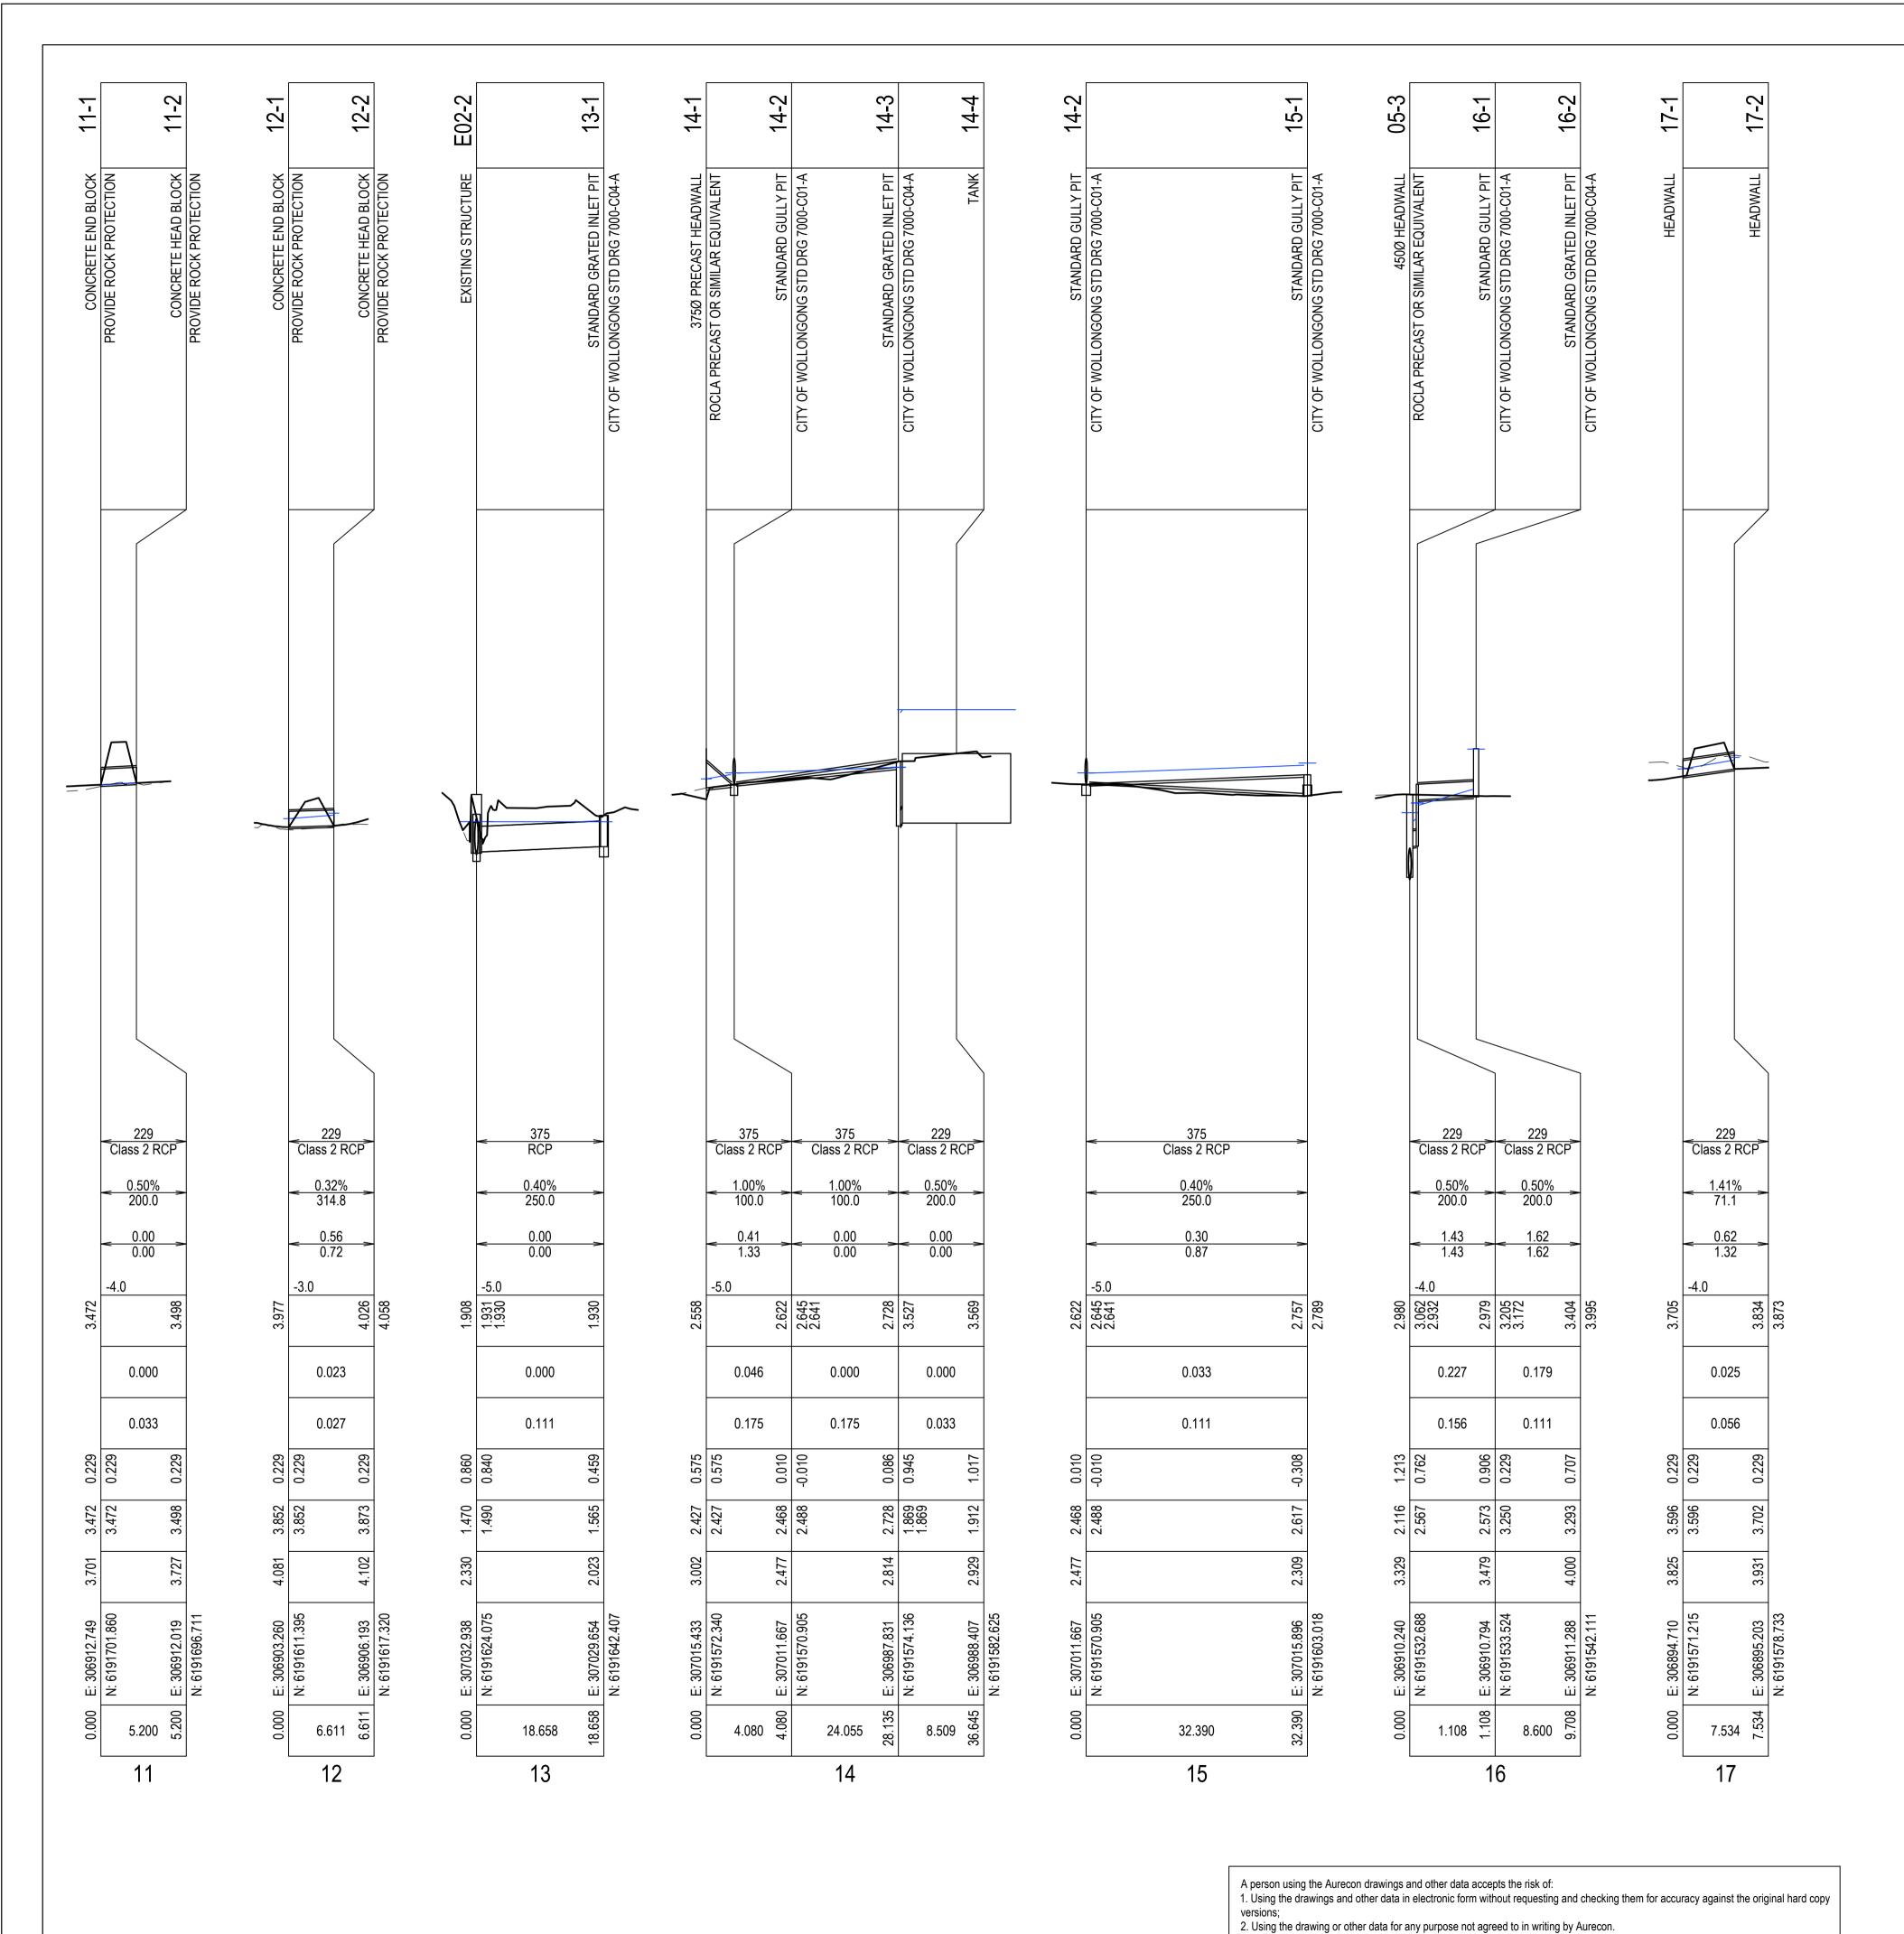

NOTE: ALL DRAWINGS ARE BASED ON FROZEN ARCHITECTURAL MODEL V177 ISSUED ON THE 30/06/2023

1:100 PHASE DD

PROJECT NUMBER 520547 E.WILLIAMS E.SELL G.CHRISTIE SCALE 100% @ A1 NORTH POINT W 00.00 DEG DRAWING NUMBER 520547-SGID-CI-01413 2

POPULOUS[®]

ARCADIA

USE FIGURED DIMENSIONS ONLY DO NOT SCALE FROM DRAWING CHECK & VERIFY ALL DIMENSIONS ON SITE BEFORE FABRICATION OR SET OUT.

This drawing is diagrammatic and shows general arrangements. Any information involving measurement of the works shall be taken from documented dimensions on the architectural and structural drawings, workshop drawings by others and conditions on site. The works shall comply with the contract conditions and Statutory

All rights reserved. This work is copyright and cannot be

agreement between Populous and the instructing party.

STRUCTURAL, CIVIL AND SERVICES ENGINEER

ST. GEORGE ILLAWARRA DRAGONS COMMUNITY & HIGH PERFORMANCE

LEVEL 11 73 Miller Street North Sydney, NSW 2060 AUSTRALIA t: +61(0) 2 9465 5599 f: +61(0) 2 9465 5598

TRAINING CENTRE

STORMWATER DRAINAGE

LONGITUDINAL SECTIONS

SHEET TITLE

SHEET 3

CIVIL WORKS

aurecon

www.aurecongroup.com

REV DESCRIPTION
1 70% DD TENDER ISSUE

2 REVISED DA SUBMISSION

electronic or mechanical, including photocopying without the written permission of Populous architects in association. Any licence, expressed or implied, to use this document for any purpose

whatsoever is restricted to the terms of the agreement or implied

THIS DRAWING IS AN UNCONTROLLED COPY. UNLESS NOTED OTHERWISE

PARTNERSHIP


COST CONSULTANT

DISCLAIMER

Wherever a discrepancy in the contract documents is found and unless directed otherwise by the Principal/Engineer, the contractor shall

adopt, at their own cost the greater quantum, class of finish, grade, or specification where applicable.

PRINT IN COLOUR NOT FOR CONSTRUCTION

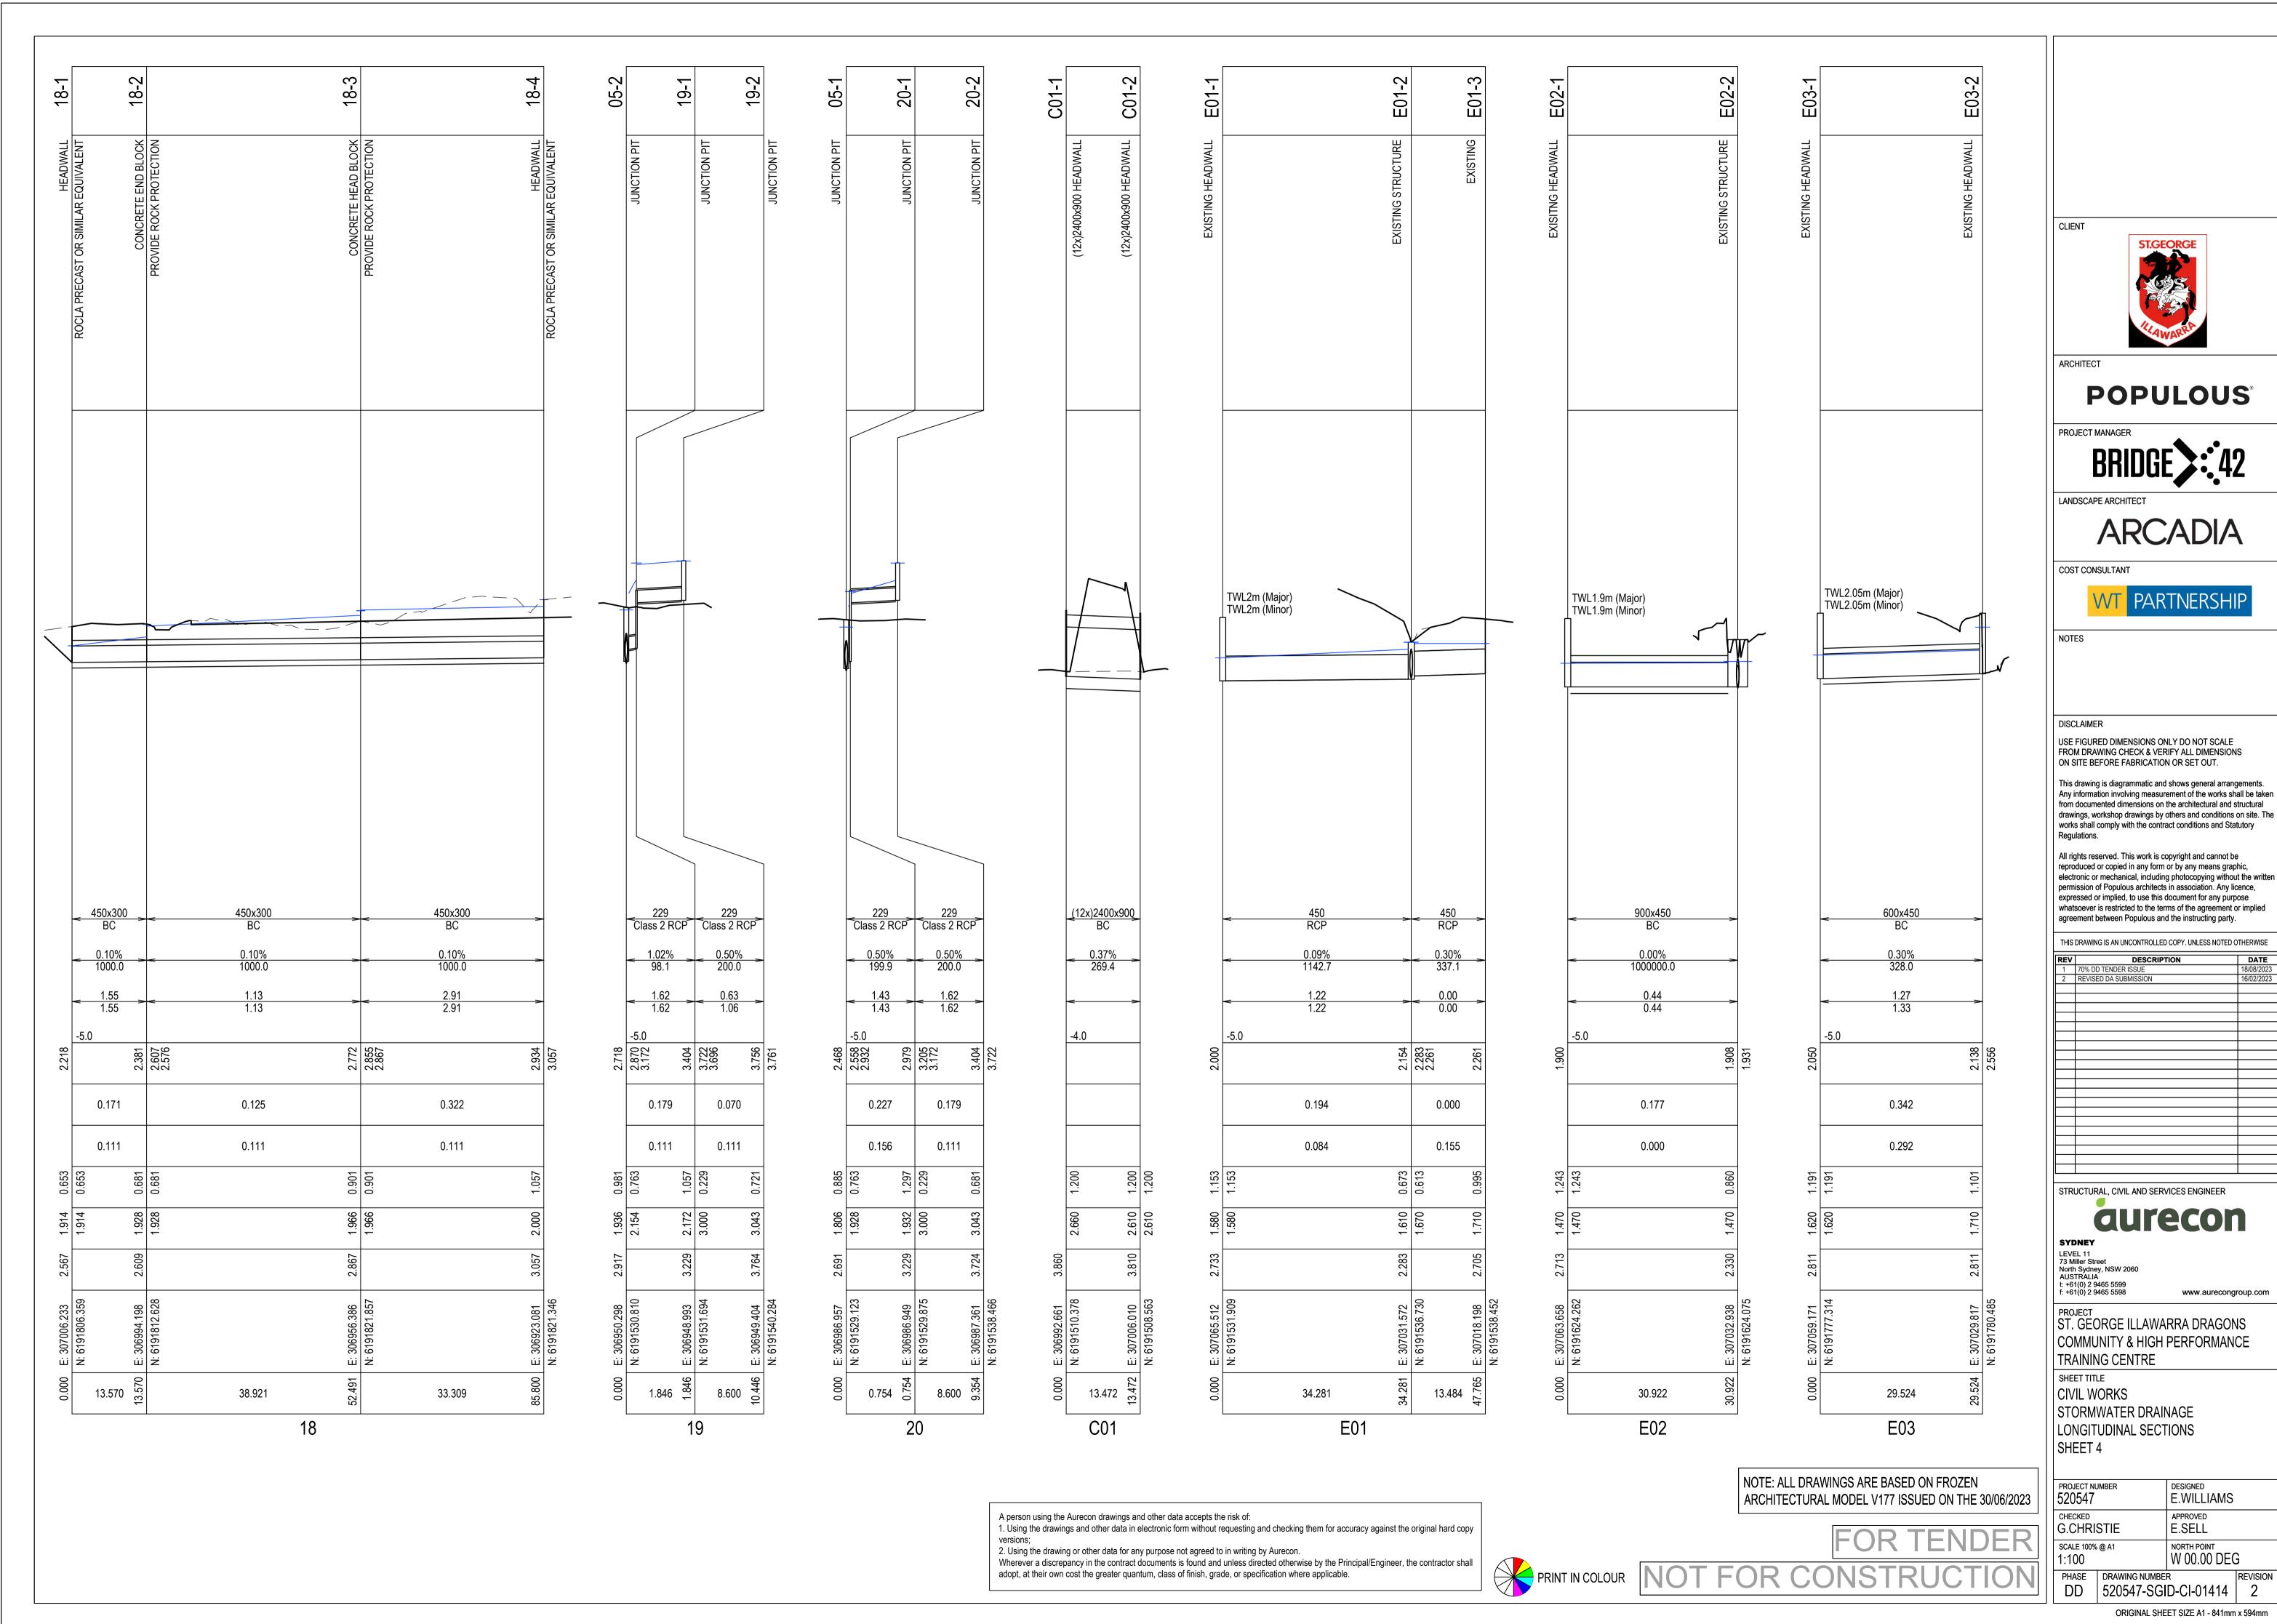

ORIGINAL SHEET SIZE A1 - 841mm x 594mm


E.WILLIAMS

E.SELL

NORTH POINT

W 00.00 DEG

www.aurecongroup.com

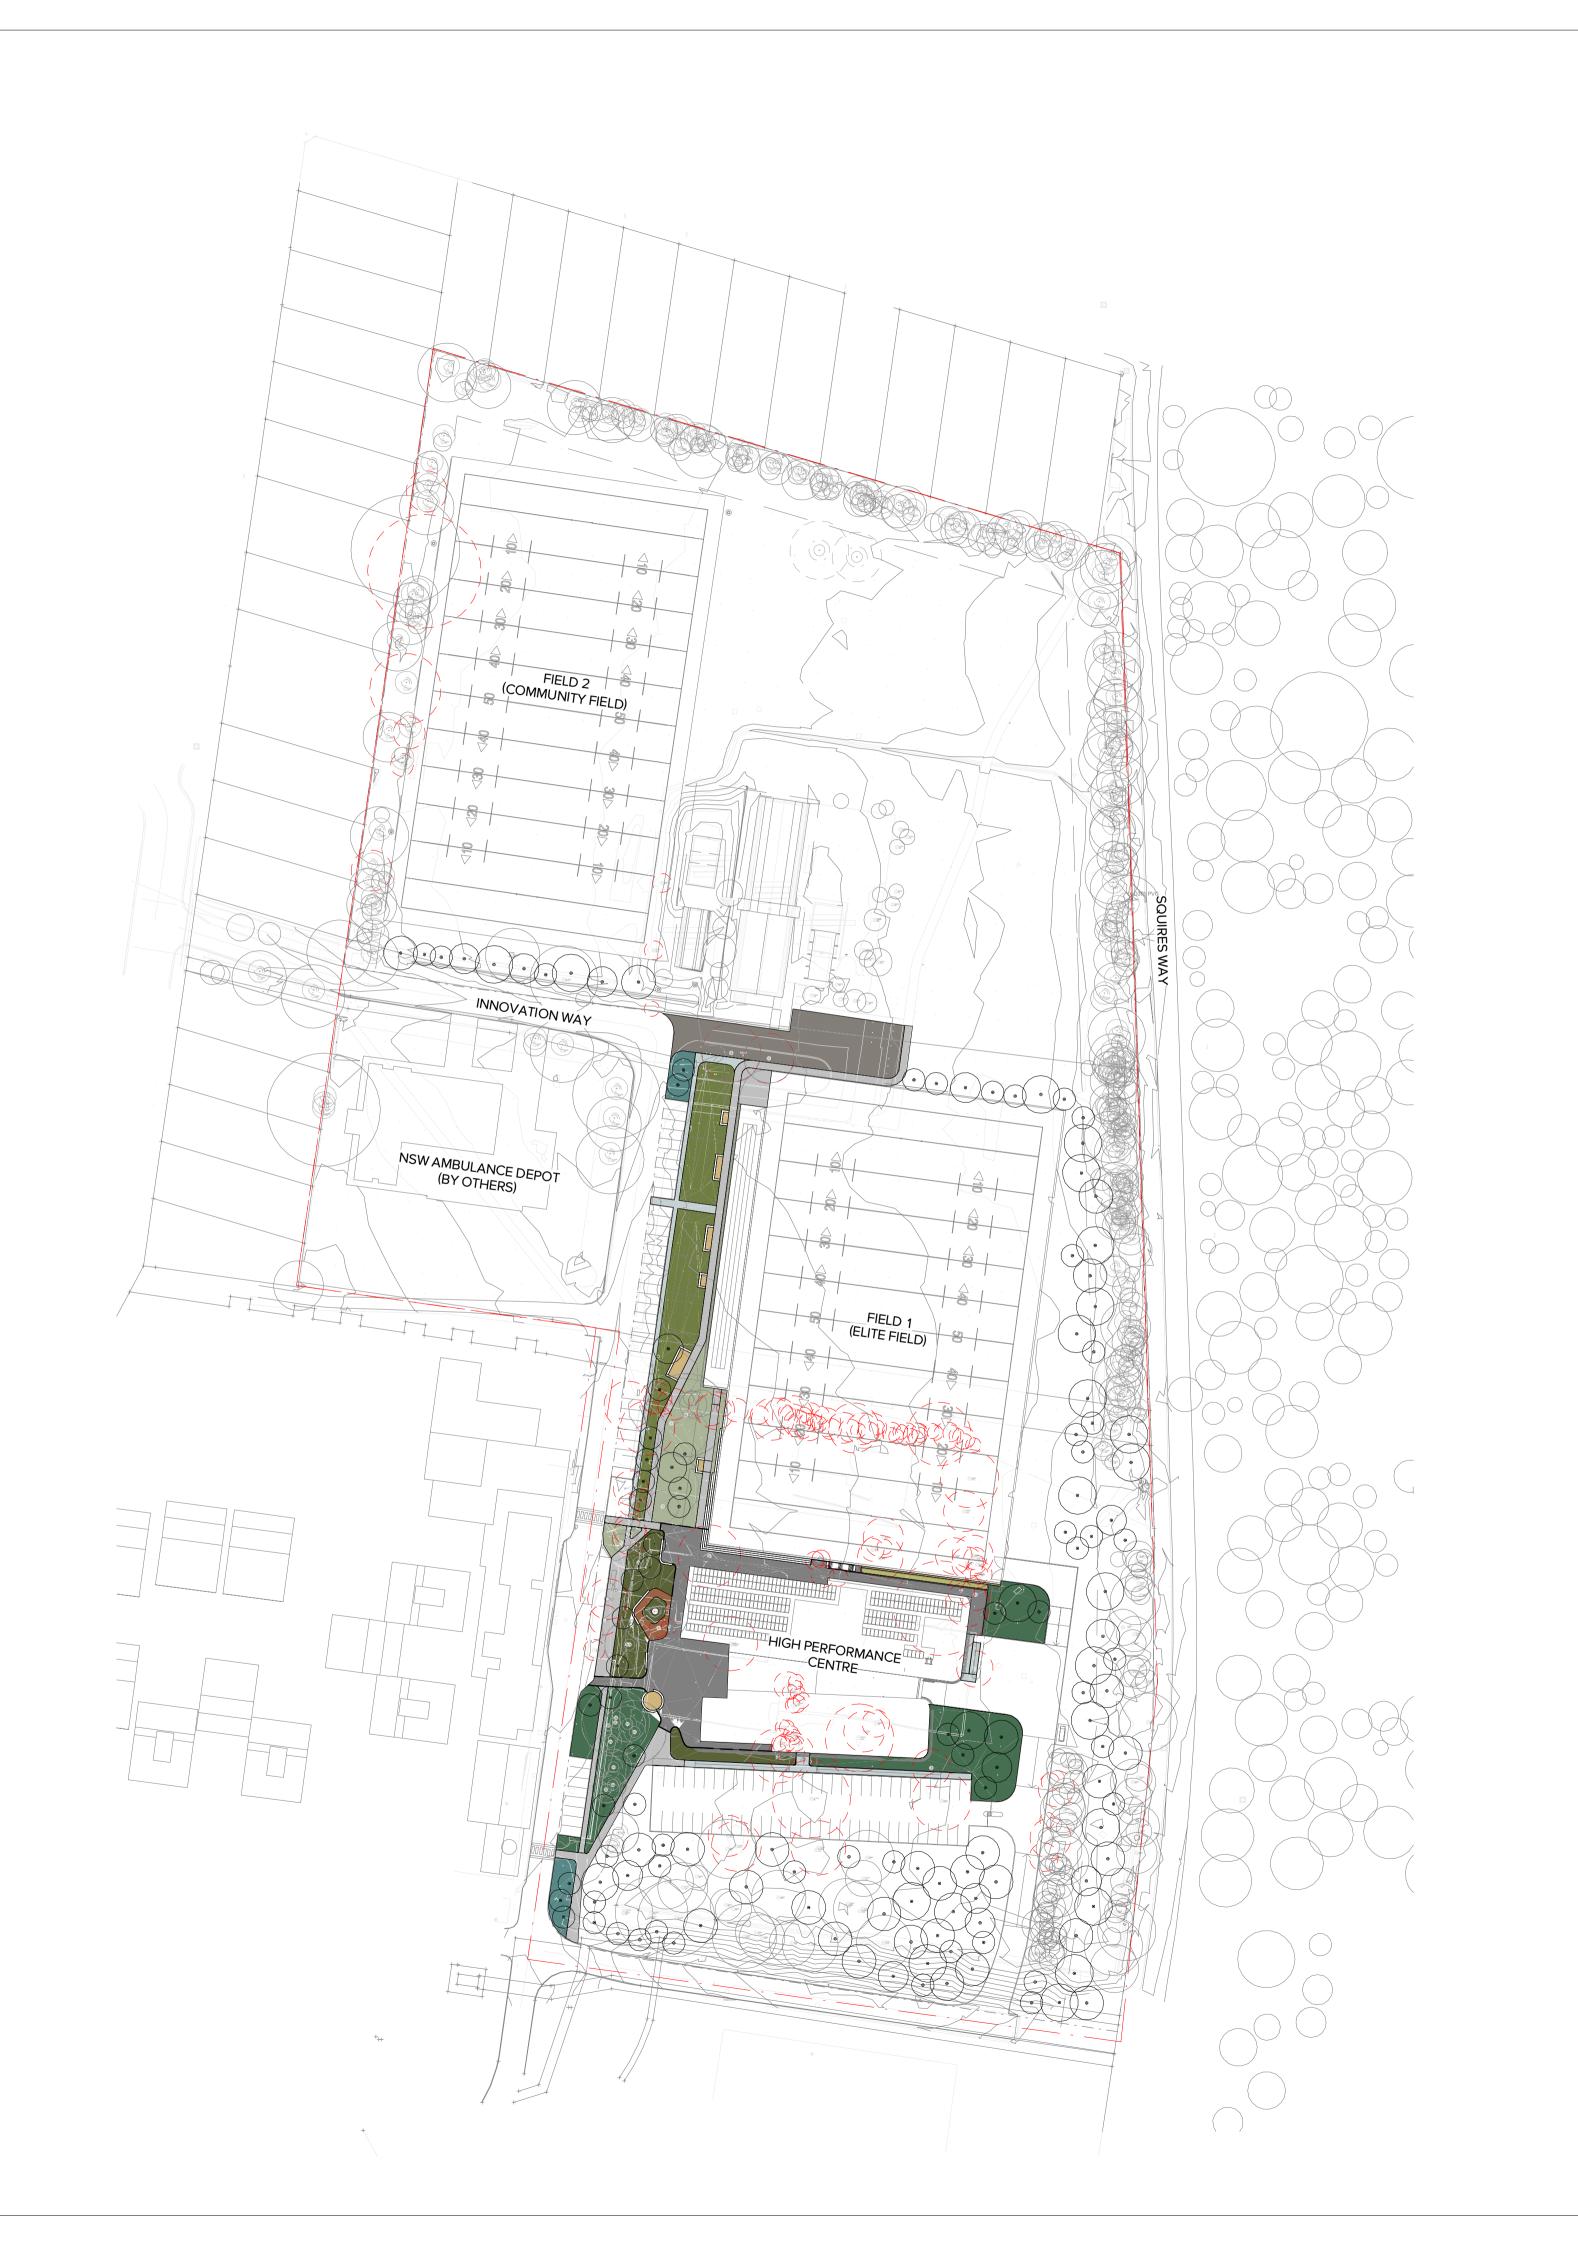

L	DRAFT FOR INFORMATION	21.02.2024
K	DA AMENDMENT SUBMISSION	11.08.2023
J	DRAFT DA RESUBMISSION	14.07.2023
- 1	70% DD ISSUE	16.12.2022
Н	50% DD ISSUE	18.11.2022
G	50% DD ISSUE	04.11.2022
F	50% DD ISSUE	21.10.2022
E	ISSUE FOR INFORMATION	06.10.2022
D	DA SUBMISSION	12.08.2022

Revision Revision Description Revision Date

ST. GEORGE **ILLAWARRA DRAGONS**

COMMUNITY & HIGH PERFORMANCE CENTRE

Project Status

Development Application



Drawing No.

0002

Drawing Name LANDSCAPE MASTERPLAN

21-787

Sydney, Suite 70, Jones Bay Wharf, 26-32 Pirrama Road, Pyrmont NSW 2009 E sydney@arcadiala.com.au T 02 8571 2900





L	DRAFT FOR INFORMATION	21.02.2024
K	DA AMENDMENT SUBMISSION	11.08.2023
J	DRAFT DA RESUBMISSION	14.07.2023
1	70% DD ISSUE	16.12.2022
Н	50% DD ISSUE	18.11.2022
G	50% DD ISSUE	04.11.2022
F	50% DD ISSUE	21.10.2022
Е	ISSUE FOR INFORMATION	06.10.2022
D	DA SUBMISSION	12.08.2022

ST. GEORGE **ILLAWARRA DRAGONS**

COMMUNITY & HIGH PERFORMANCE CENTRE

Development Application



Drawing Name

LANDSCAPE DETAIL PLAN

01

1:100@A1

21-787

Sydney, Suite 70, Jones Bay Wharf, 26-32 Pirrama Road, Pyrmont NSW 2009 E sydney@arcadiala.com.au T 02 8571 2900





DRAFT FOR 21.02.2024 INFORMATION DA AMENDMENT 11.08.2023 SUBMISSION 14.07.2023 DRAFT DA RESUBMISSION 70% DD ISSUE 50% DD ISSUE 04.11.2022 50% DD ISSUE 50% DD ISSUE 21.10.2022 ISSUE FOR 06.10.2022 INFORMATION

Revision Revision Description Revision Date

ST. GEORGE **ILLAWARRA**

COMMUNITY & HIGH PERFORMANCE CENTRE

Development Application




Drawing Name LANDSCAPE


DETAIL PLAN 02


1:100@A1

Sydney, Suite 70, Jones Bay Wharf, 26-32 Pirrama Road, Pyrmont NSW 2009 E sydney@arcadiala.com.au T 02 8571 2900

ARCADIA

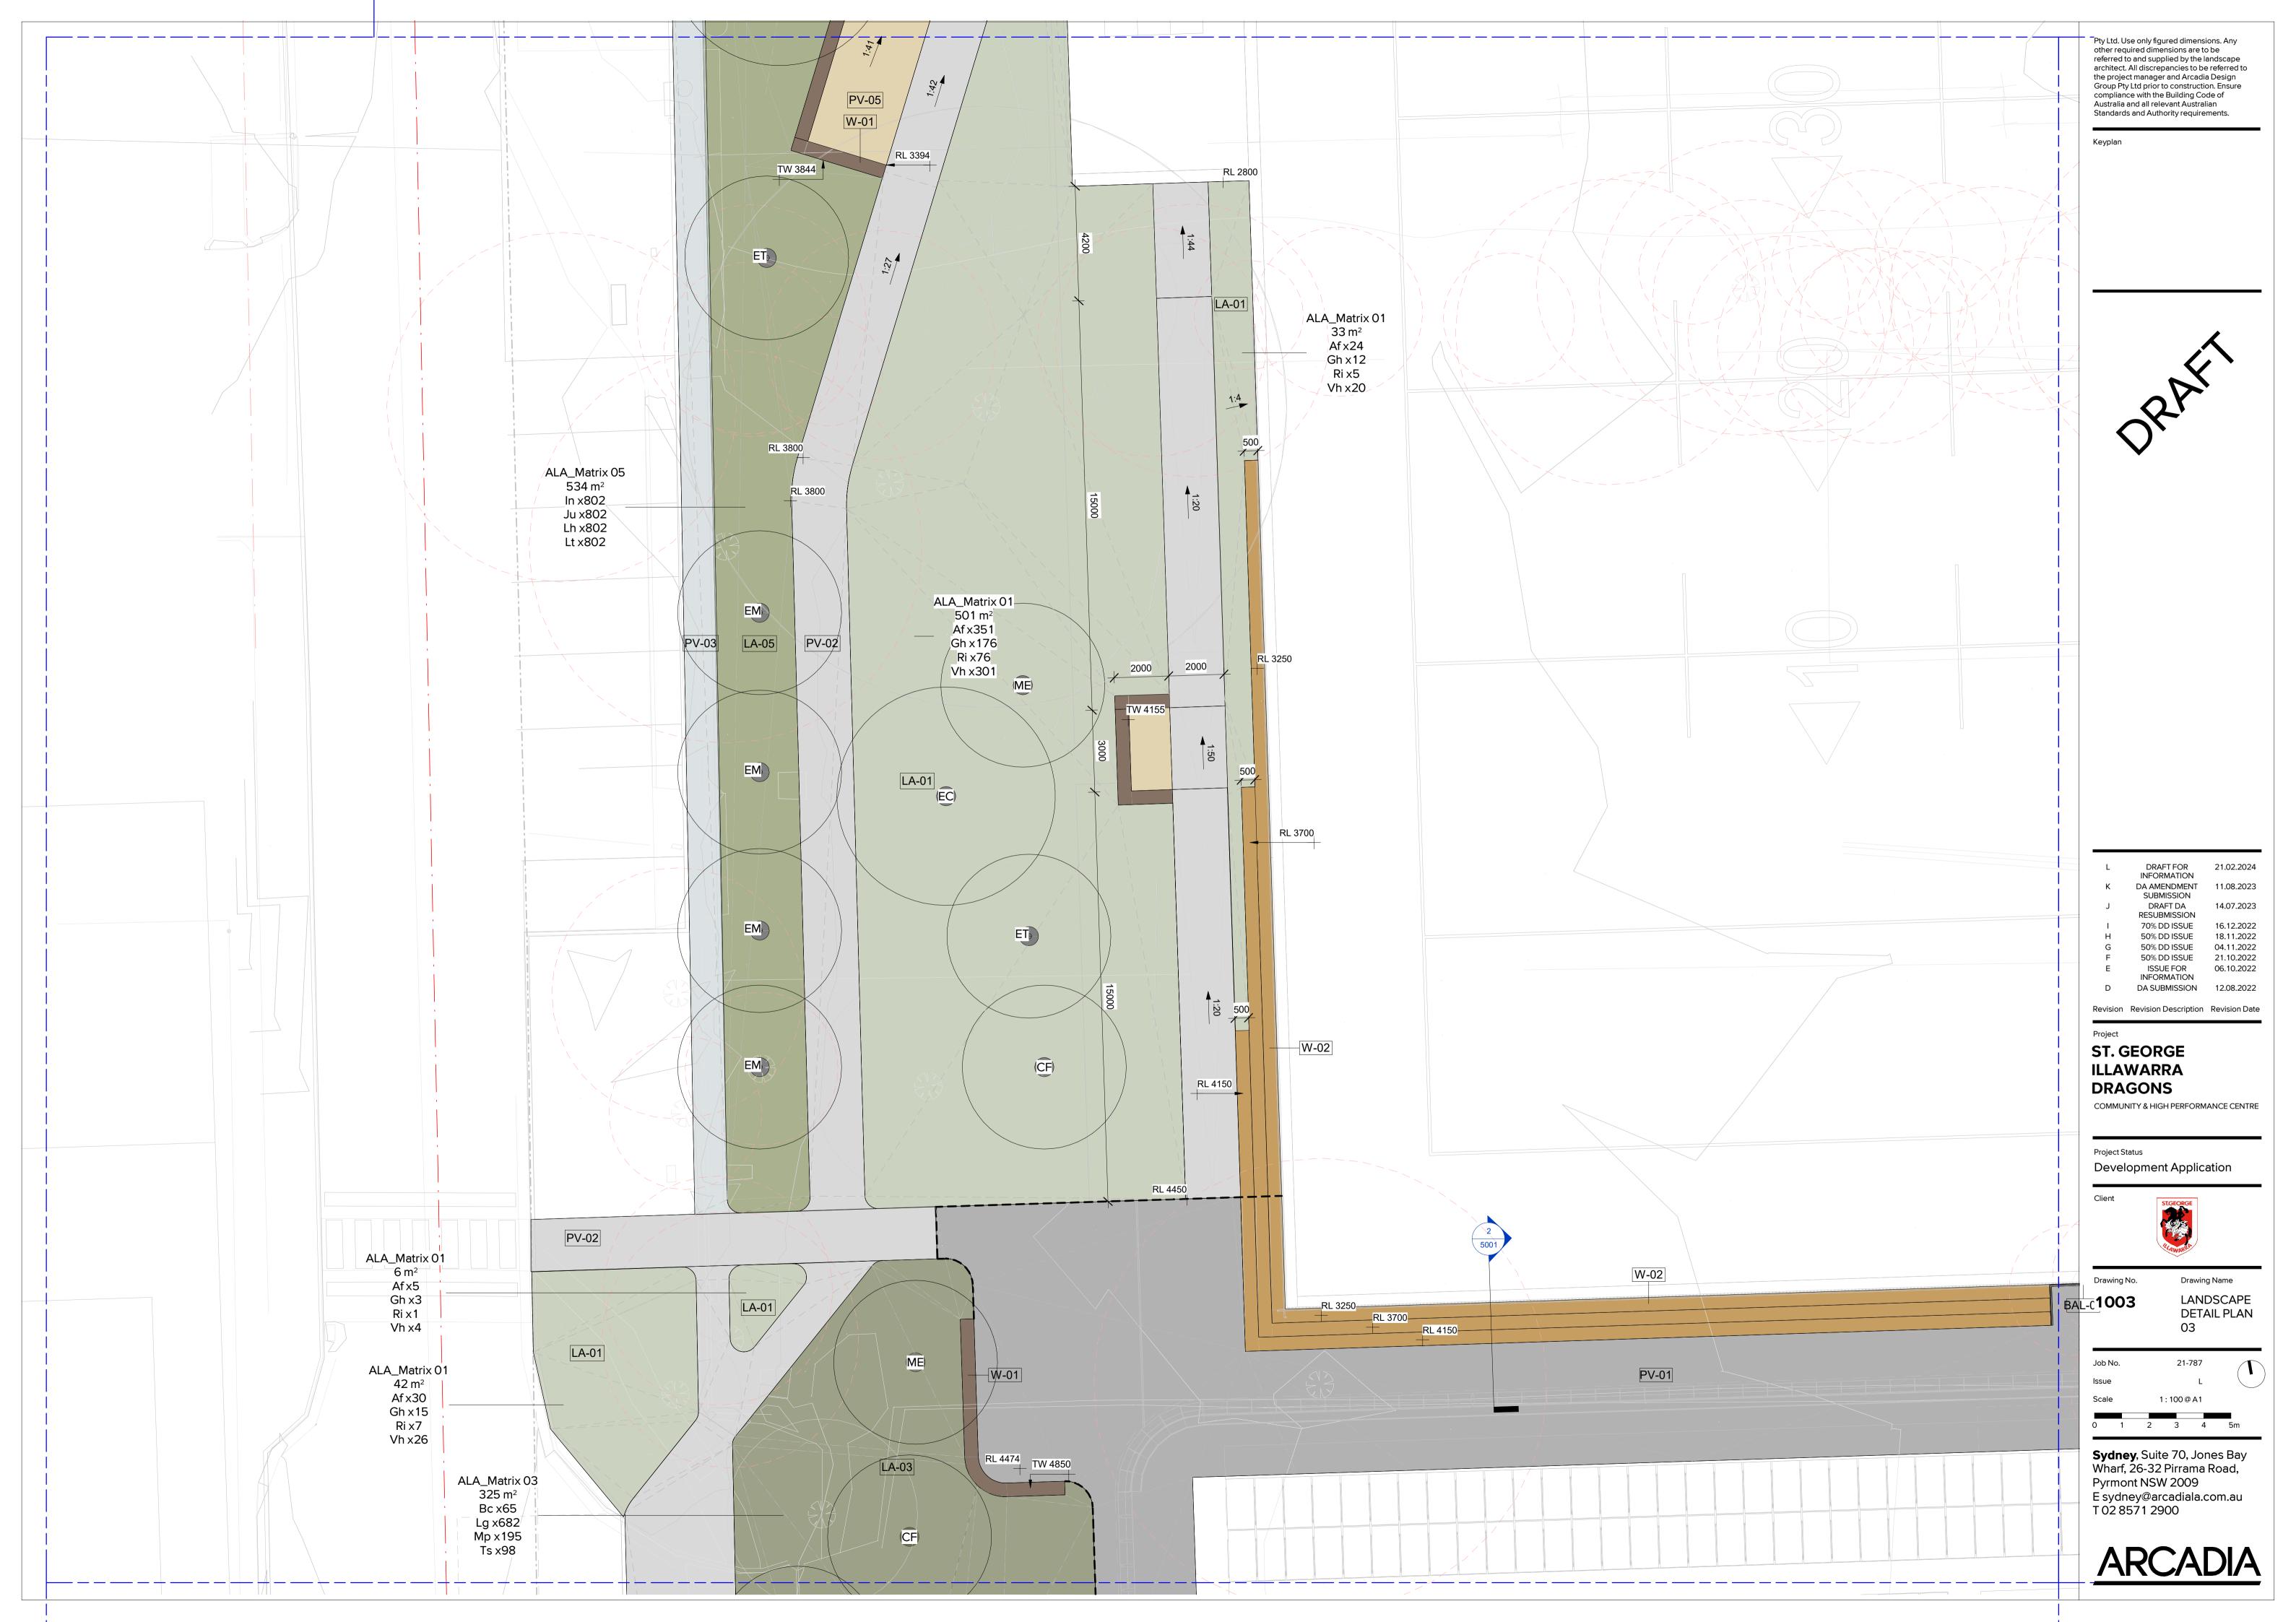

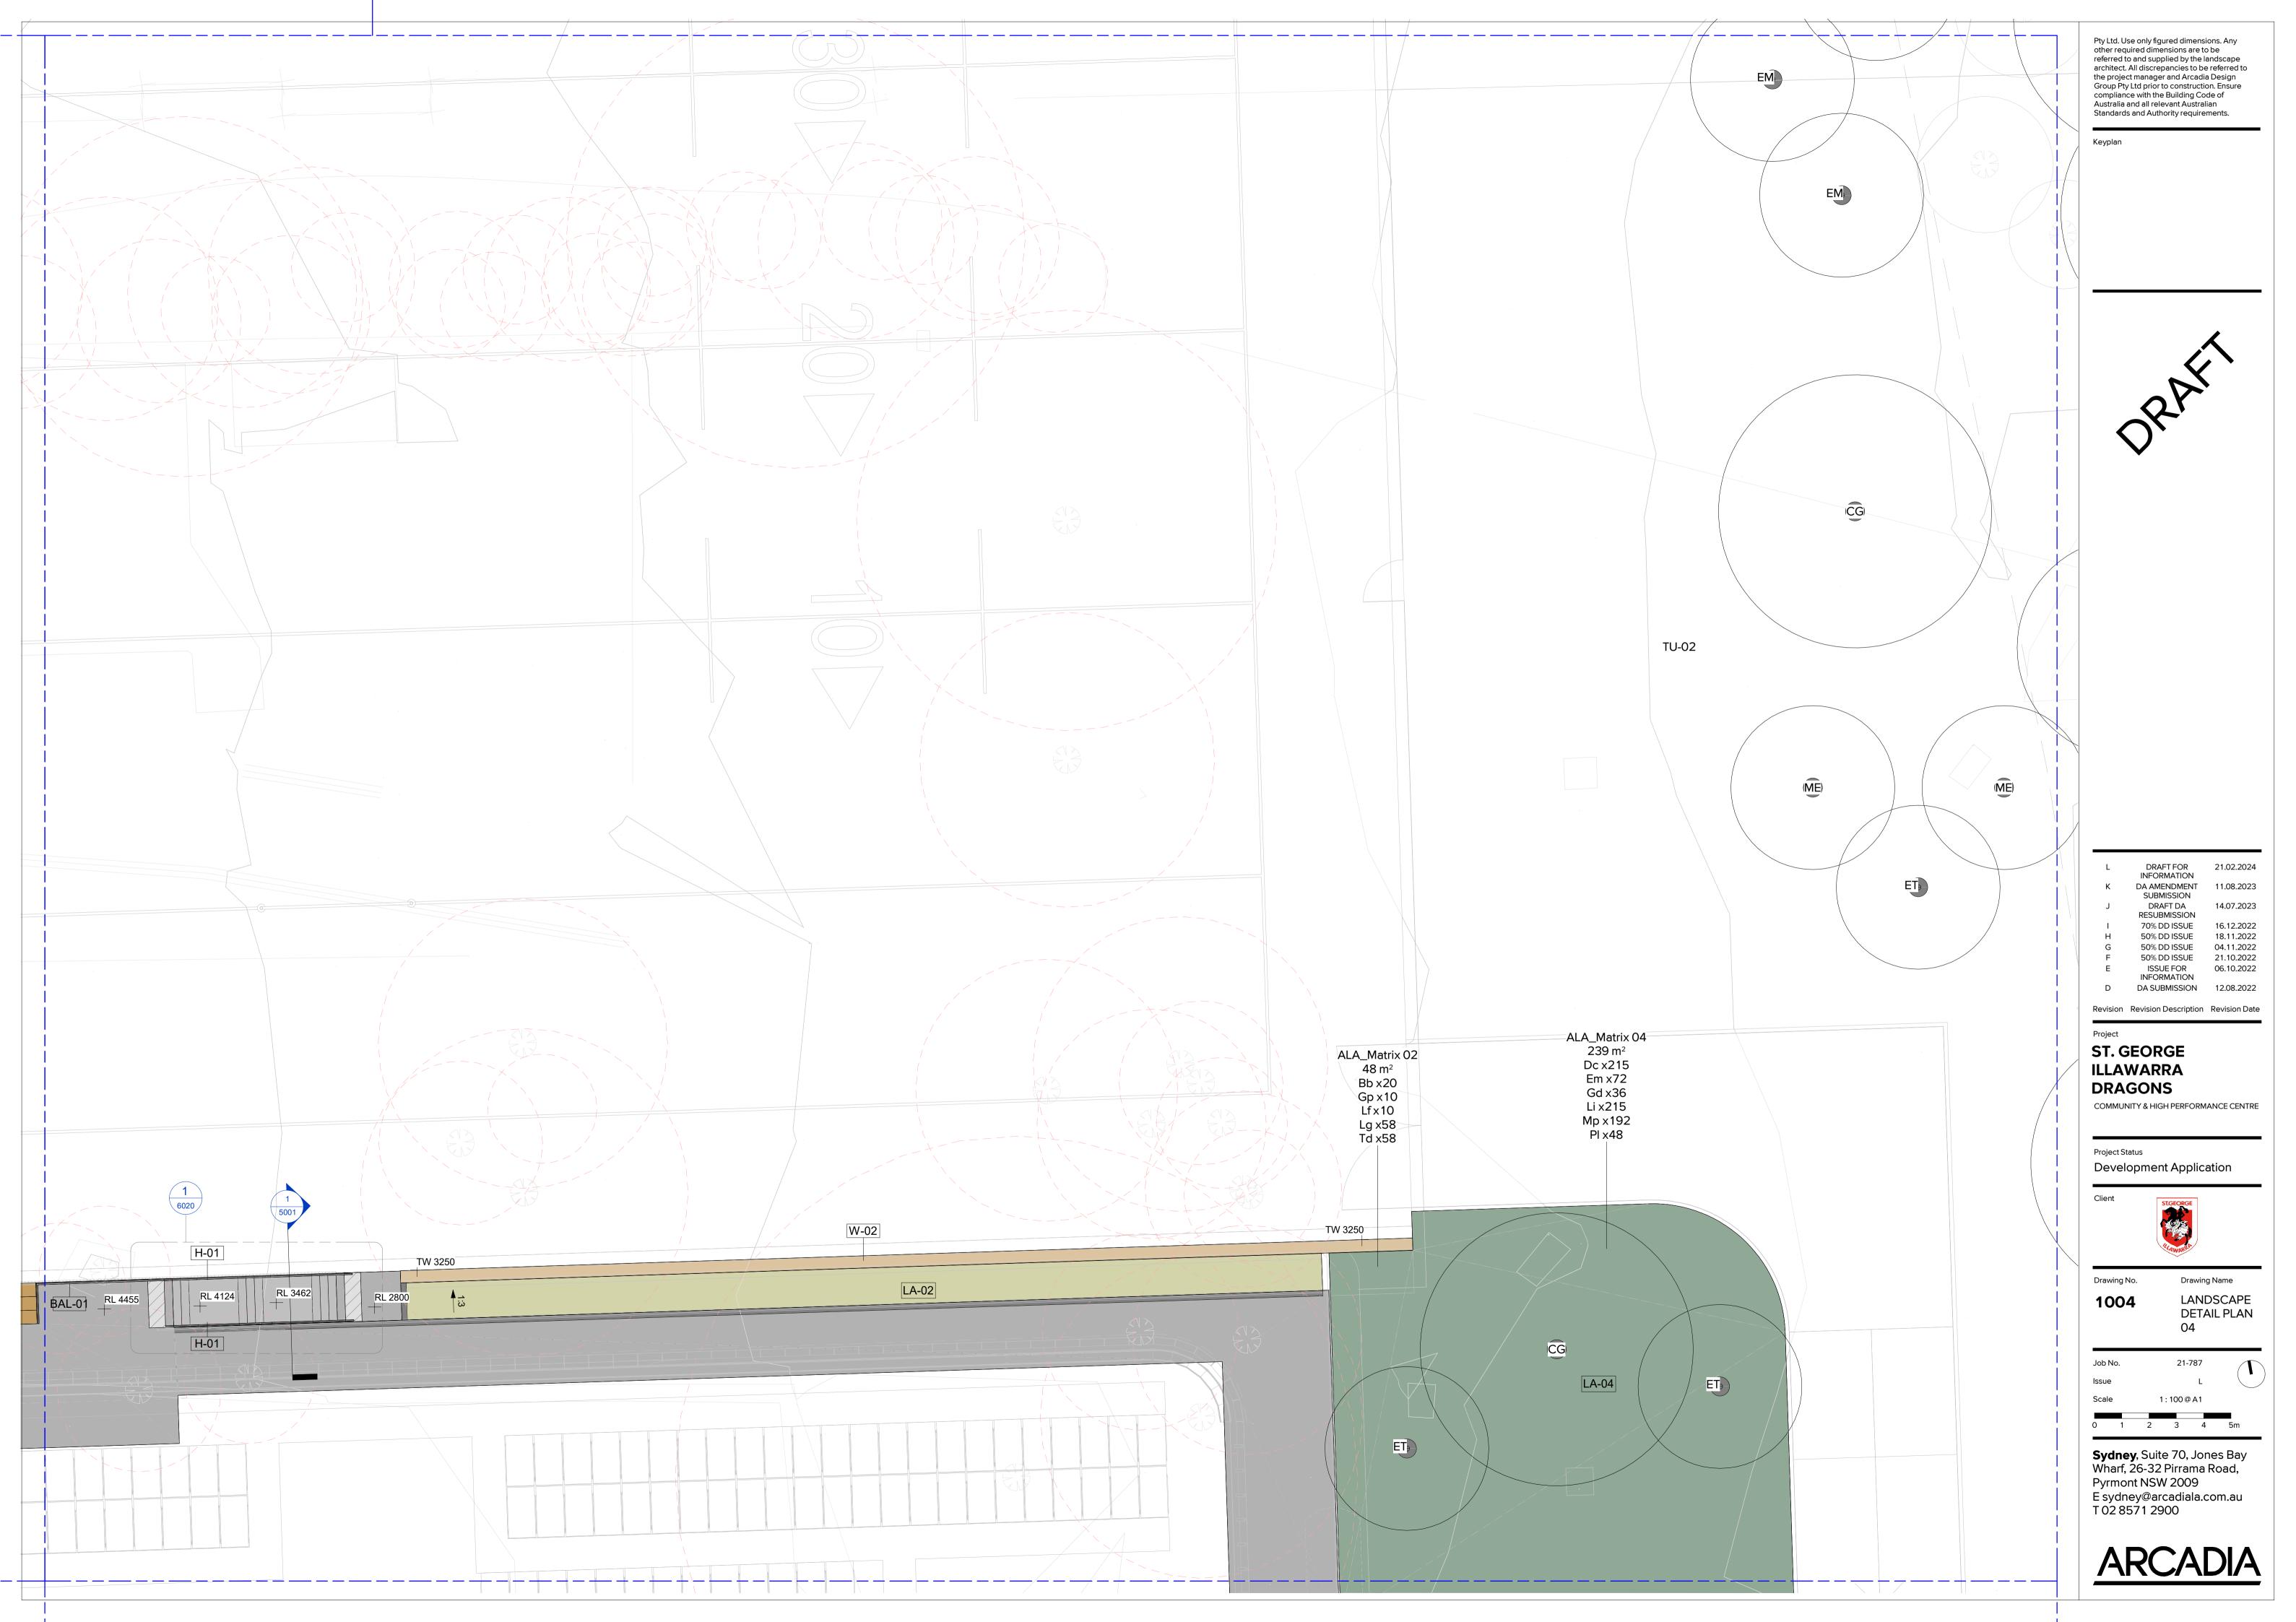

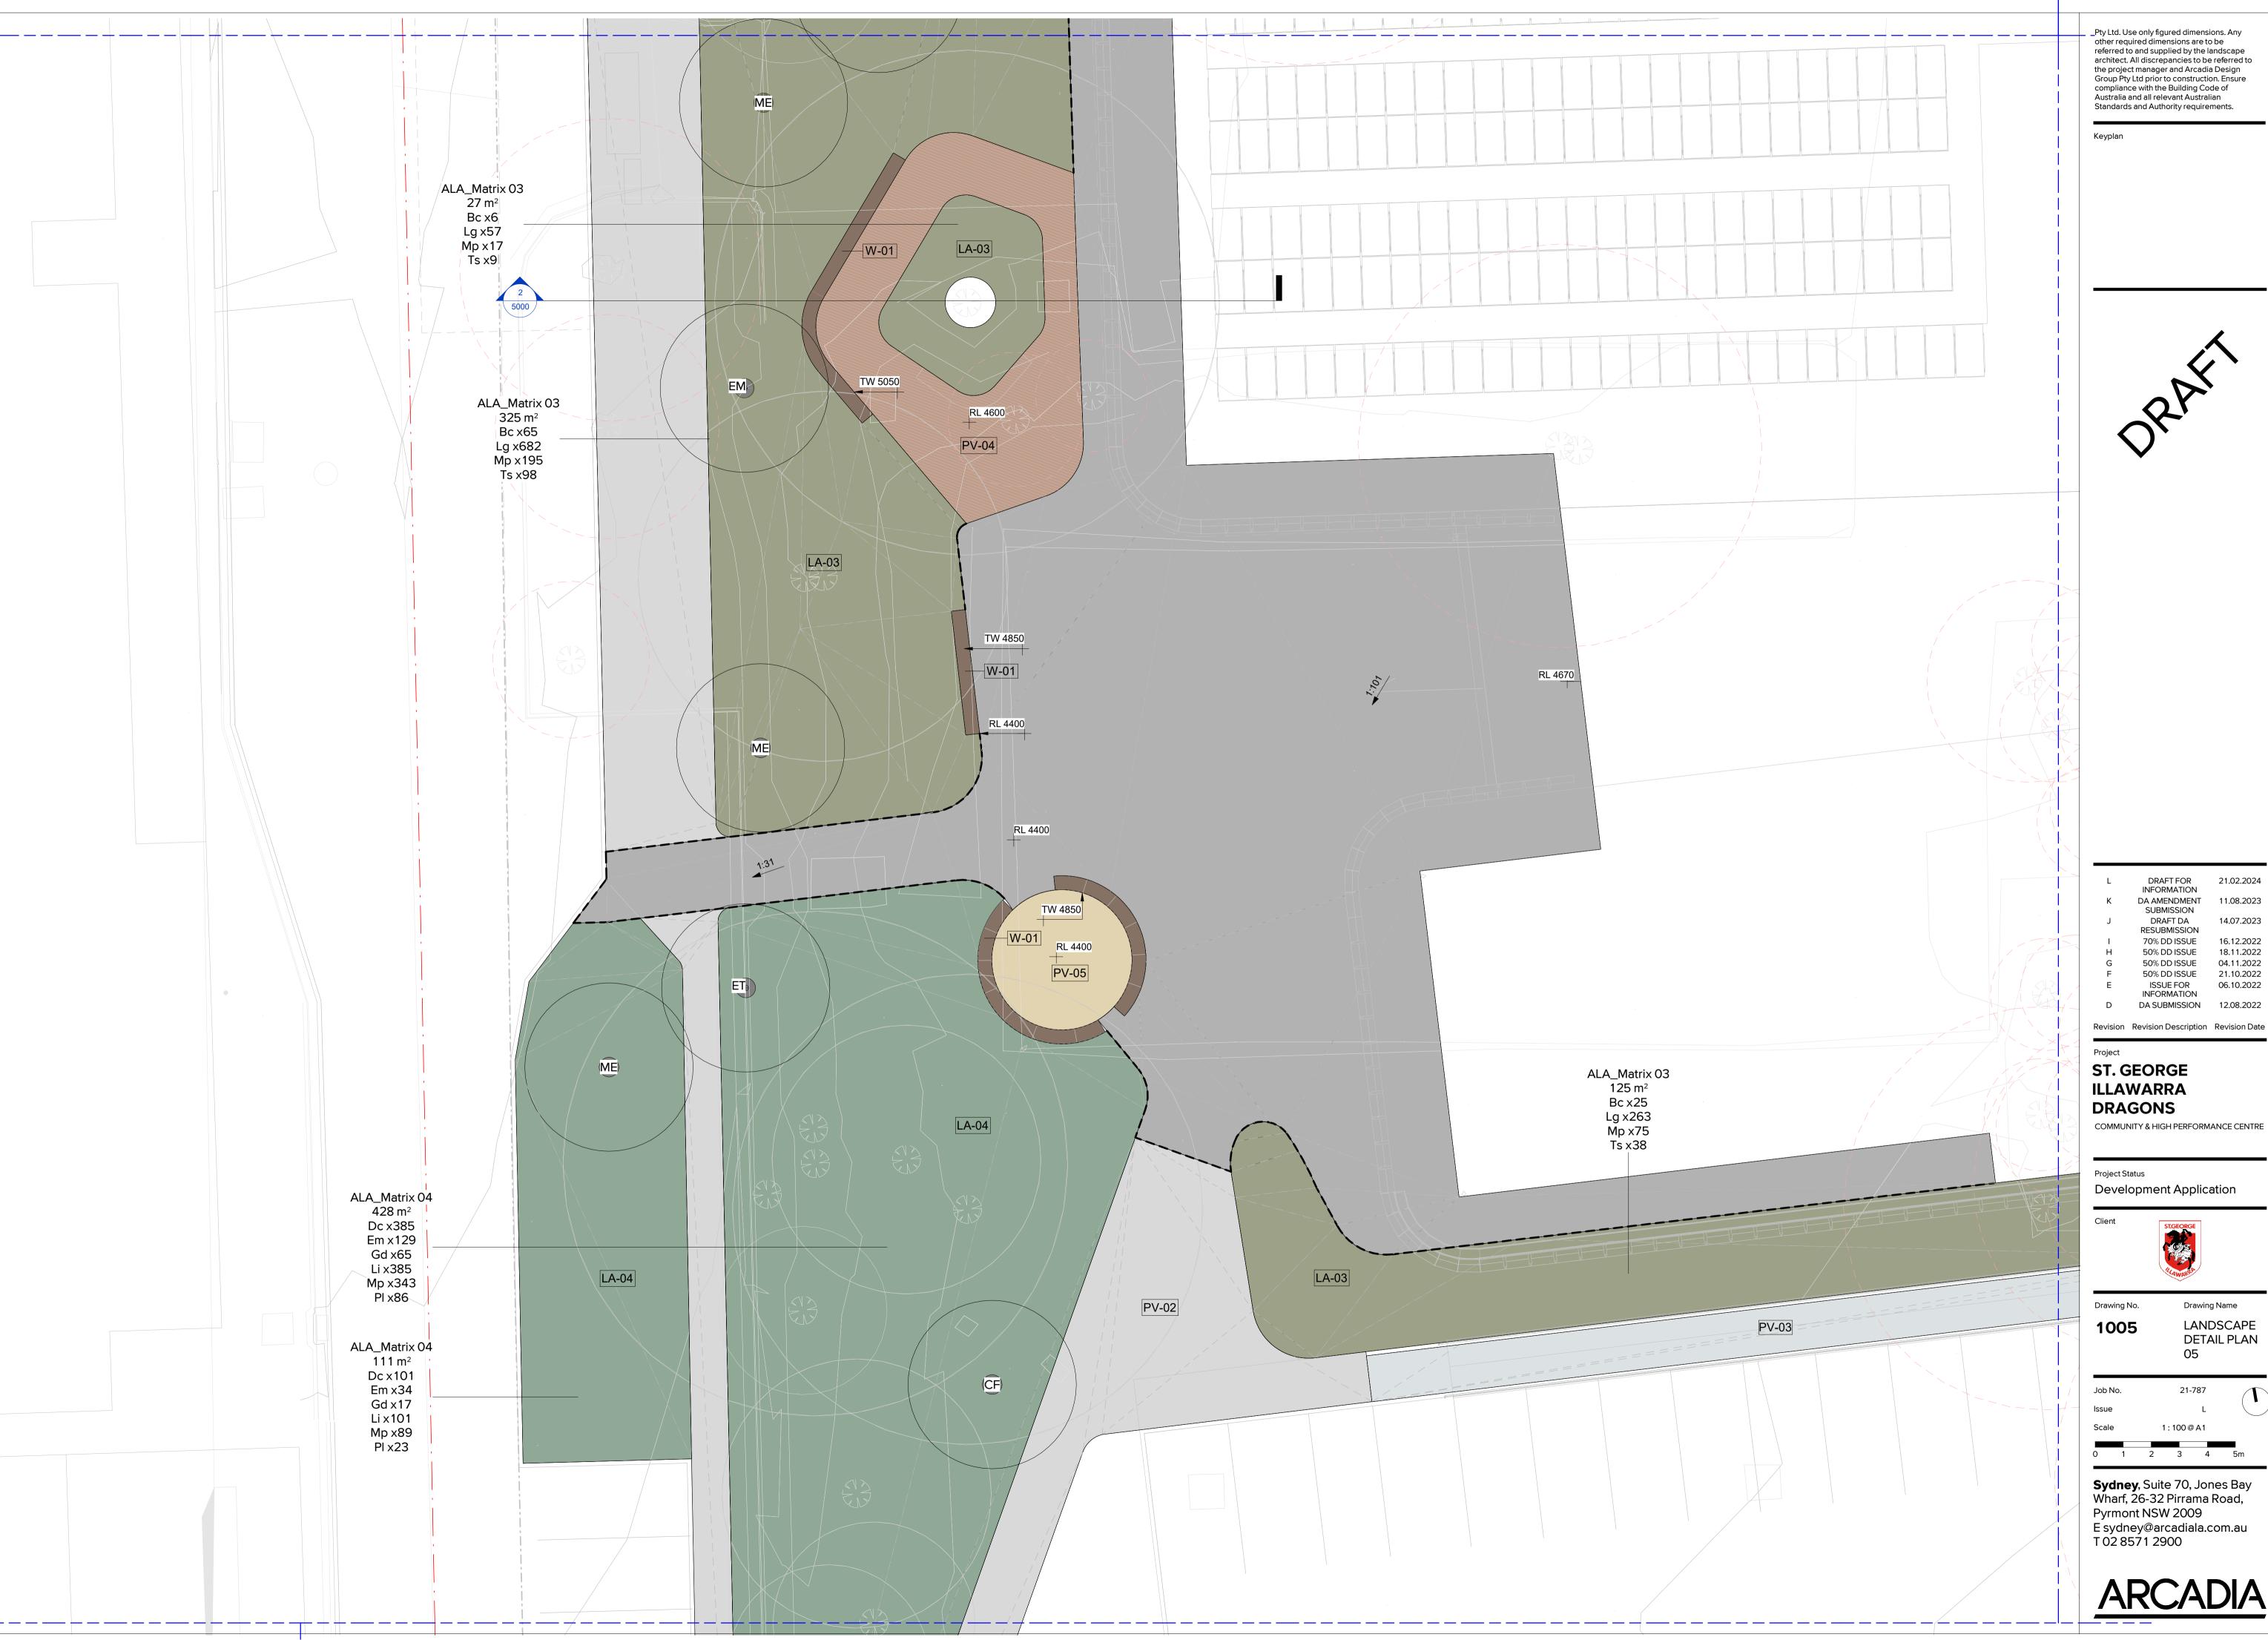

DRAFT FOR 21.02.2024 INFORMATION DA AMENDMENT 11.08.2023 SUBMISSION 14.07.2023 DRAFT DA RESUBMISSION 70% DD ISSUE 50% DD ISSUE 04.11.2022 50% DD ISSUE 50% DD ISSUE 21.10.2022 ISSUE FOR 06.10.2022 INFORMATION DA SUBMISSION 12.08.2022

ILLAWARRA DRAGONS

COMMUNITY & HIGH PERFORMANCE CENTRE

Development Application




Drawing Name

LANDSCAPE DETAIL PLAN 05

21-787

1:100@A1

Sydney, Suite 70, Jones Bay Wharf, 26-32 Pirrama Road,

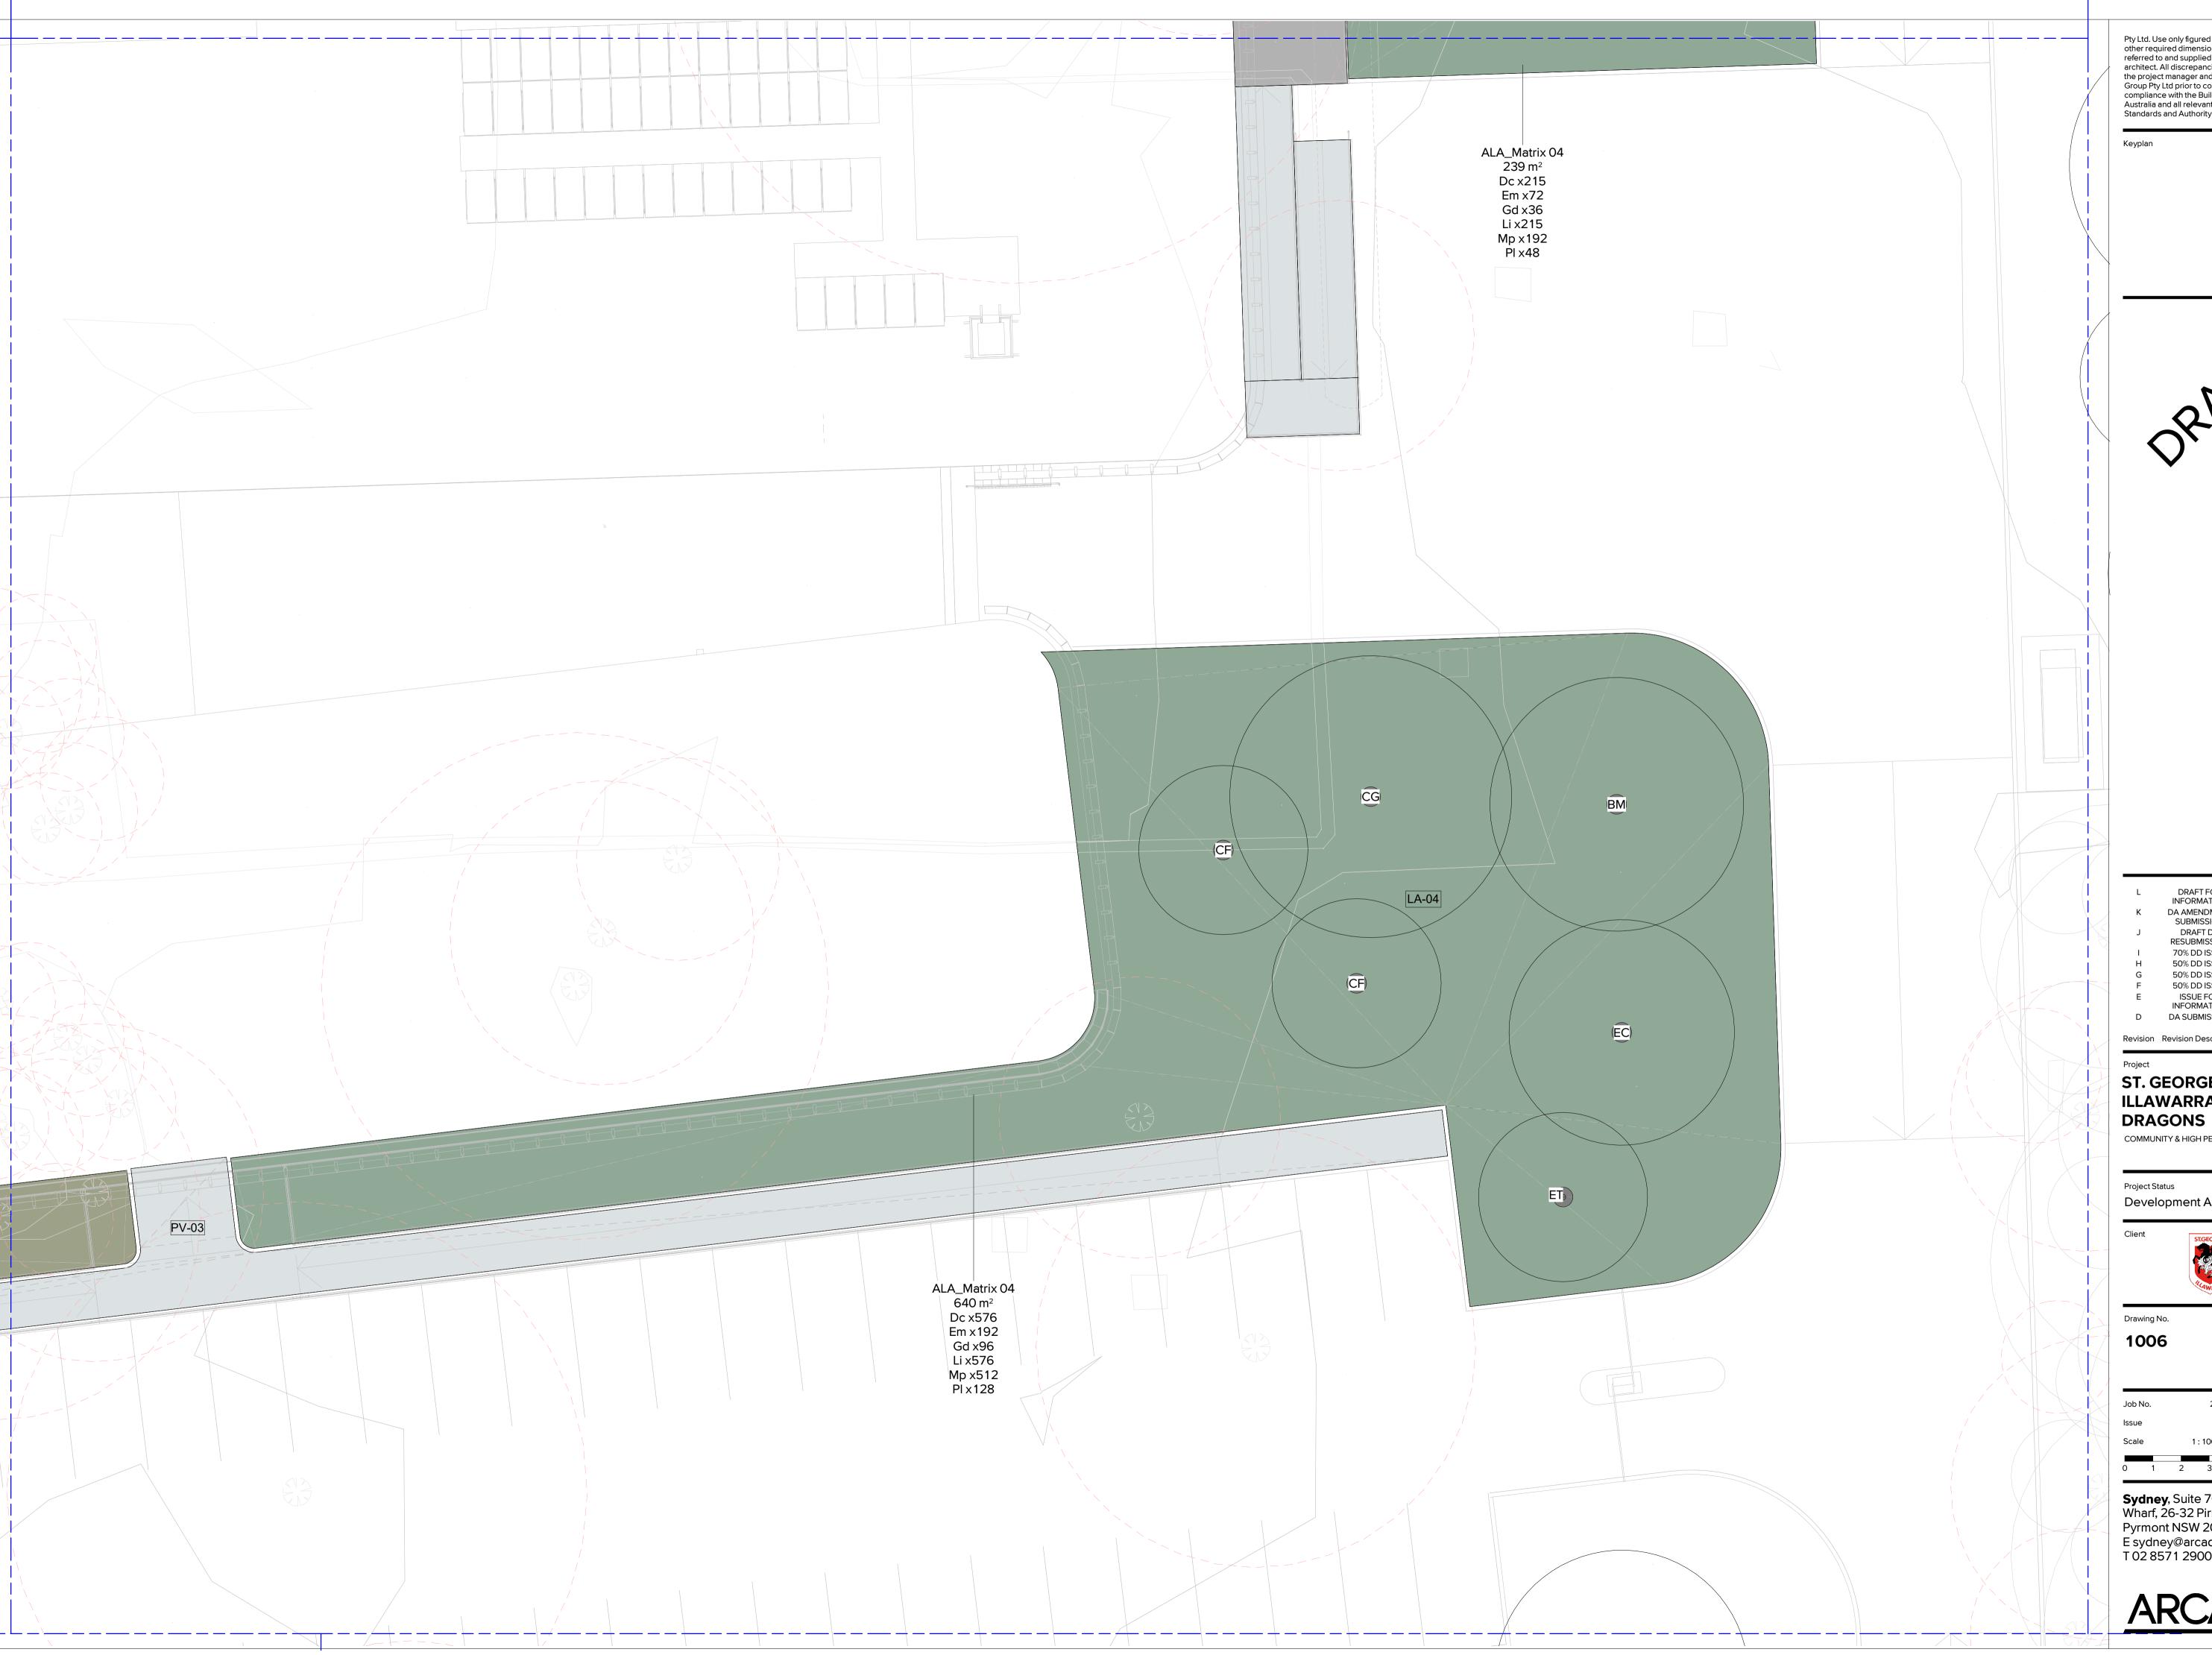

L	DRAFT FOR INFORMATION	21.02.2024
K	DA AMENDMENT SUBMISSION	11.08.2023
J	DRAFT DA RESUBMISSION	14.07.2023
1	70% DD ISSUE	16.12.2022
Н	50% DD ISSUE	18.11.2022
G	50% DD ISSUE	04.11.2022
F	50% DD ISSUE	21.10.2022
E	ISSUE FOR INFORMATION	06.10.2022
D	DA SUBMISSION	12.08.2022

Revision Revision Description Revision Date

ST. GEORGE **ILLAWARRA**

COMMUNITY & HIGH PERFORMANCE CENTRE

Development Application




LANDSCAPE DETAIL PLAN 06

21-787

Sydney, Suite 70, Jones Bay Wharf, 26-32 Pirrama Road, Pyrmont NSW 2009 E sydney@arcadiala.com.au T 02 8571 2900



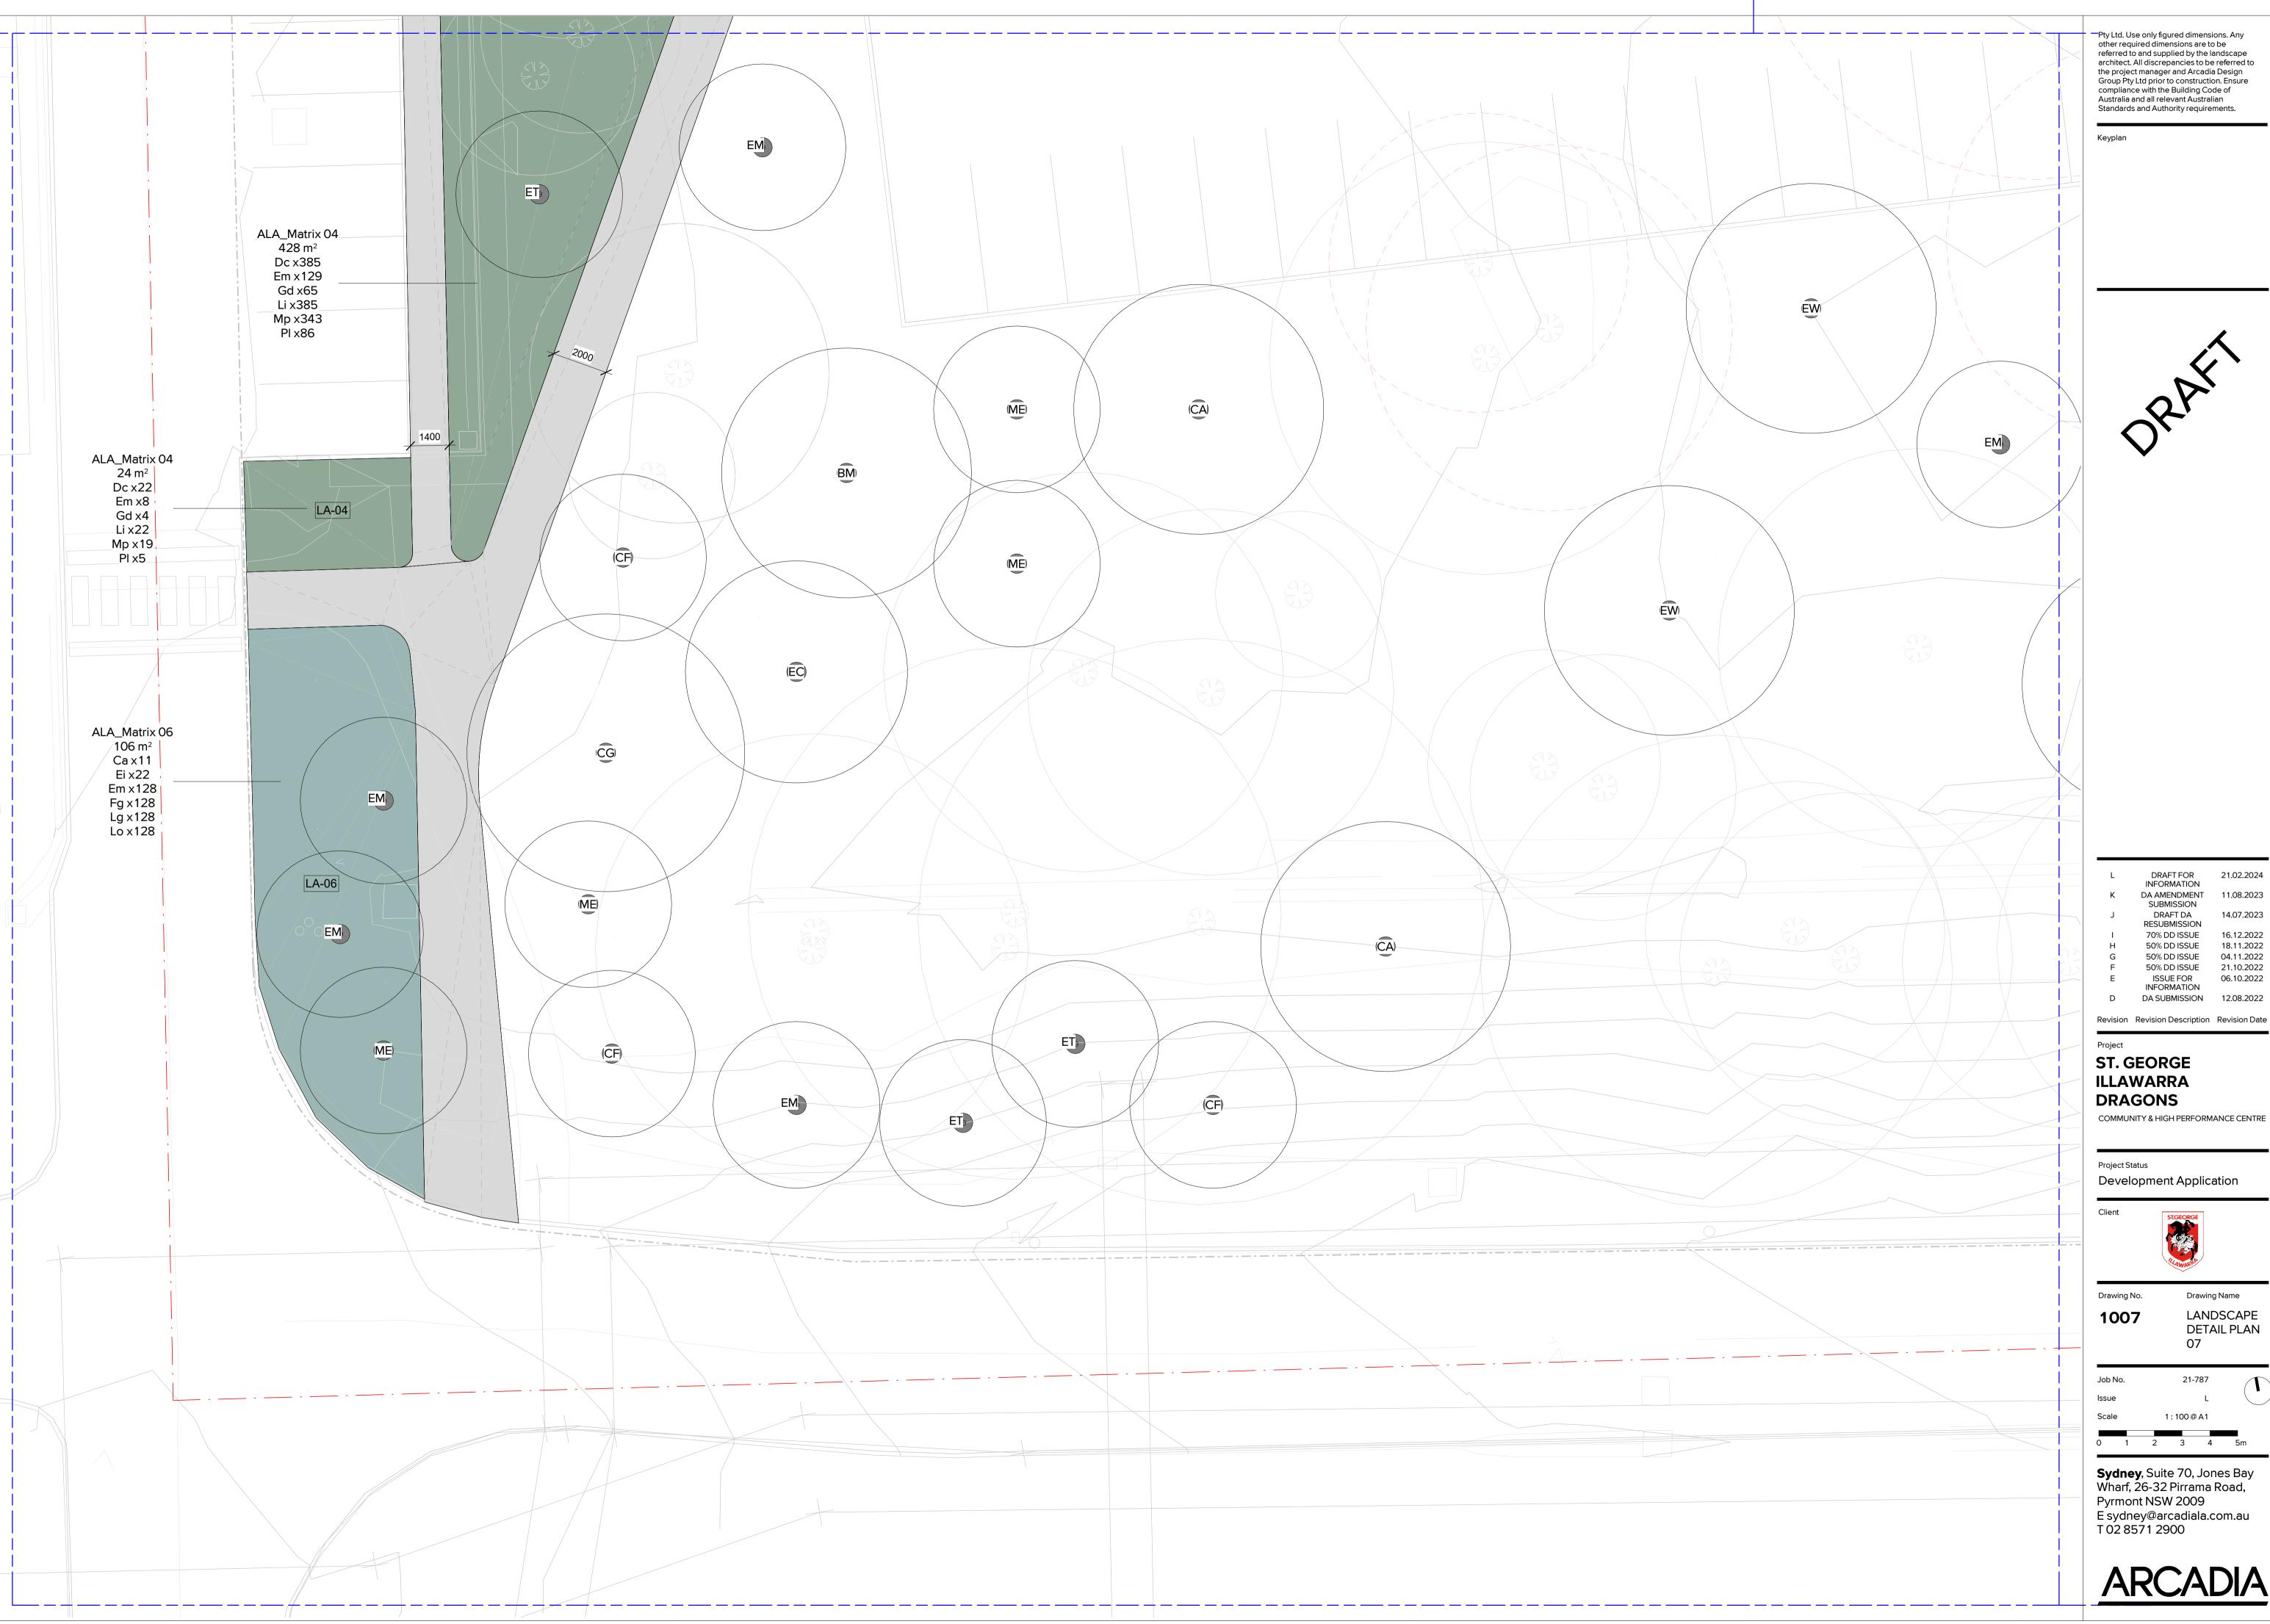

DRAFT FOR 21.02.2024
INFORMATION
DA AMENDMENT 11.08.2023
SUBMISSION DRAFT DA RESUBMISSION 70% DD ISSUE 50% DD ISSUE 50% DD ISSUE 50% DD ISSUE 21.10.2022 ISSUE FOR 06.10.2022 INFORMATION DA SUBMISSION 12.08.2022

COMMUNITY & HIGH PERFORMANCE CENTRE



Drawing Name


LANDSCAPE DETAIL PLAN 07

21-787

1:100@A1

Sydney, Suite 70, Jones Bay Wharf, 26-32 Pirrama Road, Pyrmont NSW 2009 E sydney@arcadiala.com.au T 02 8571 2900



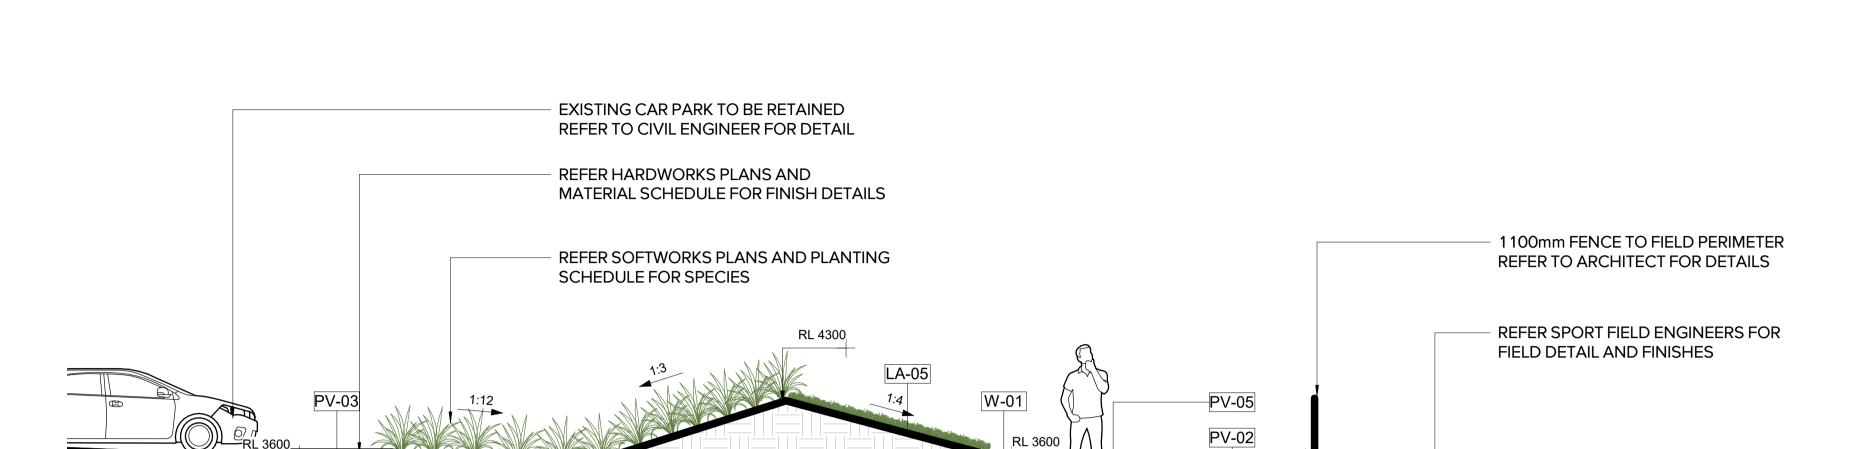


PROPOSED GARDEN BED WITH SWALE

RL 3150

SPRINT TRACK

SEATING WALL-OUTDOOR COMMUNAL AREA

SECTION 01 1:50

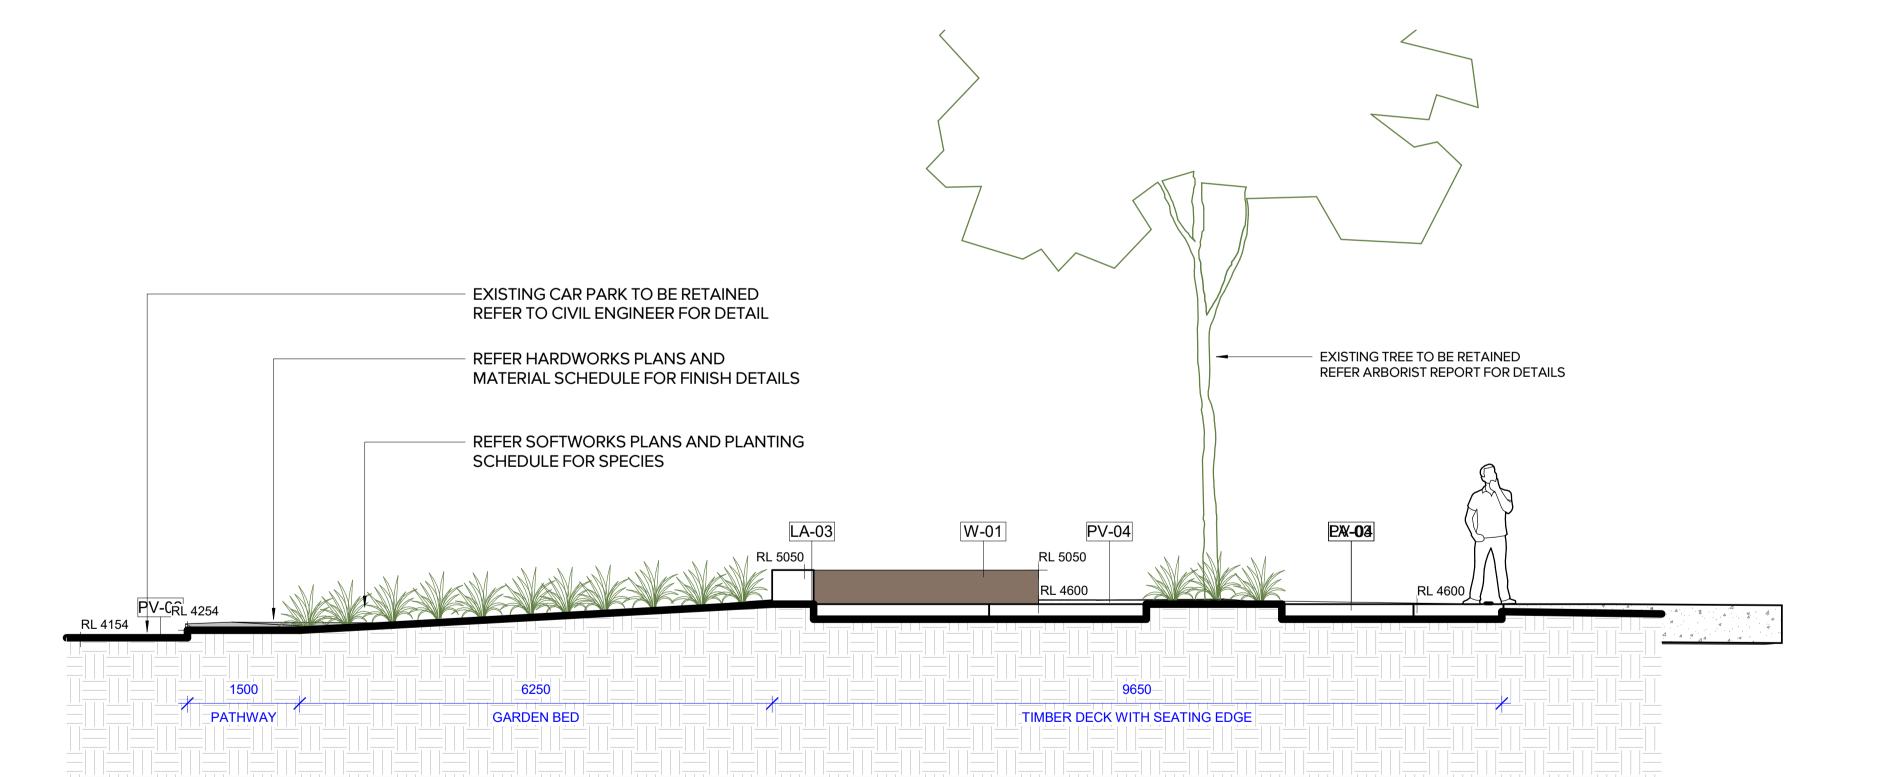

2 SECTION 02 1:50

Pty Ltd. Use only figured dimensions. Any other required dimensions are to be other required dimensions are to be referred to and supplied by the landscape architect. All discrepancies to be referred to the project manager and Arcadia Design Group Pty Ltd prior to construction. Ensure compliance with the Building Code of Australia and all relevant Australian Standards and Authority requirements.

М	DRAFT FOR INFORMATION	21.02.2024
L	70% DD - TENDER ISSUE	21.08.2023
K	DA AMENDMENT SUBMISSION	11.08.2023
J	DRAFT DA RESUBMISSION	14.07.2023
1	70% DD ISSUE	16.12.2022
Н	50% DD ISSUE	18.11.2022
G	50% DD ISSUE	04.11.2022
F	50% DD ISSUE	21.10.2022
E	ISSUE FOR INFORMATION	06.10.2022

Revision Revision Description Revision Date

ST. GEORGE **ILLAWARRA DRAGONS**

COMMUNITY & HIGH PERFORMANCE CENTRE

Project Status

Development Application



Drawing No.

Drawing Name LANDSCAPE 5000 SECTIONS

21-787 Job No. Issue 1:50@A1

Sydney, Suite 70, Jones Bay Wharf, 26-32 Pirrama Road,

Pyrmont NSW 2009 E sydney@arcadiala.com.au T 02 8571 2900

