



DRAWING SCHEDULE				
Sheet Number	Sheet Name	Sheet Issue Date	Current Revision	Current Revision Date
A.000	COVERSHEET	28.02.2025		
A.050	SITE PLAN	28.02.2025		
A.051	DEMOLITION PLAN	28.02.2025		
A.052	GROSS FLOOR AREA	28.02.2025		
A.053	SHADOW DIAGRAMS	28.02.2025		
A.100	FLOOR PLAN	28.02.2025		
A.101	ROOF PLAN	28.02.2025		
A.300	REFLECTED CEILING PLAN	28.02.2025		
A.400	SECTIONS 1	28.02.2025		
A.401	SECTIONS 2	28.02.2025		
A.500	ELEVATIONS 1	28.02.2025		
A.501	ELEVATIONS 2	28.02.2025		
A.800	COLOURBOARD	28.02.2025		
P1	PERSPECTIVES 1	28.02.2025		

SUBJECT SITE



LOCATION PLAN

CONTRACTORS MUST VERIFY ALL DIMENSIONS ON SITE BEFORE COMMENCING ANY WORK OR PREPARING SHOP DRAWINGS

All Architectural drawing sheets to be cross-referenced with other relevant disciplines.

Rev	Description	Date
-----	-------------	------

CONSULTANT 4:

50

YEARS

WEBB

AUSTRALIA GROUP (NSW) PTY LTD

LEVEL 2 17 BOLTON STREET
NEWCASTLE NSW 2300 AUSTRALIA
T +61 2 4929 3225 | M +61 478 412 035
MECHANICAL ENGINEERING

CONSULTANT 3:

GLENN HAIG

& PARTNERS

Coffs Harbour

P. 02 6658 2444 P. 02 9310 1952
PO Box 192 PO Box 489
SARTELL, NSW, 2452 SURRY HILLS, NSW, 2019

HYDRAULIC + FIRE CONSULTANTS office@glennhaig.com.au

CONSULTANT 2:

SPECTRUM

ENGINEERING SOLUTIONS

1 Davis Place
Glenhaven NSW 2156

Phone: (02) 8850 6802
Mobile: 0419 294 533
Email: : nati@spectrumns.com.au

CONSULTANT 1:

PM DESIGN GROUP

Engineering Solutions

50 Glenelg Street
Geelong, Victoria, Australia 3320
PH: 03 5249 4800
e: admin@pmdesign.com.au

STRUCTURAL + CIVIL ENGINEERING

DESIGN ARCHITECT:

FACILITY

DESIGN GROUP

Architecture & Construction

AQUATIC ■ SPORTS ■ LEISURE ■ CIVIC ■ PROJECT MANAGEMENT

NSW Reg. No. 7168
ABN: 75 063 999 424
e: info@fdg.com.au
w: www.fdg.com.au
p: 02 4446 0777
p: PO Box 62
Combeburra NSW 2540

CLIENT:

Snowy

Valleys

Council

PROJECT NAME:

MULTIPURPOSE + EVACUATION CENTRE

for DA

PROJECT ADDRESS:
RICHMOND PARK, TUMUT NSW
Lot 1 Section 81 DP 759004 and
Lot 701 DP 1059193.

DRAWING TITLE:


COVERSHEET

SHEET ISSUE DATE: 28.02.2025		DRAWING NO. REV.	
REVISION DATE:		A.000	
SCALE: @ A1			
JOB NO.: W366			

DRAWN BY: Author CHECKED BY: S. JOHANSSON

COPYRIGHT FACILITY DESIGN GROUP PTY. LIMITED. ALL RIGHTS RESERVED. DO NOT SCALE OFF DRAWINGS. WORK TO FIGURED DIMENSIONS ONLY. VERIFY DIMENSIONS ON SITE PRIOR TO COMMENCING WORK.

NOMINATED ARCHITECT: STEPHEN JOHANSSON - NSW REG No. 7168

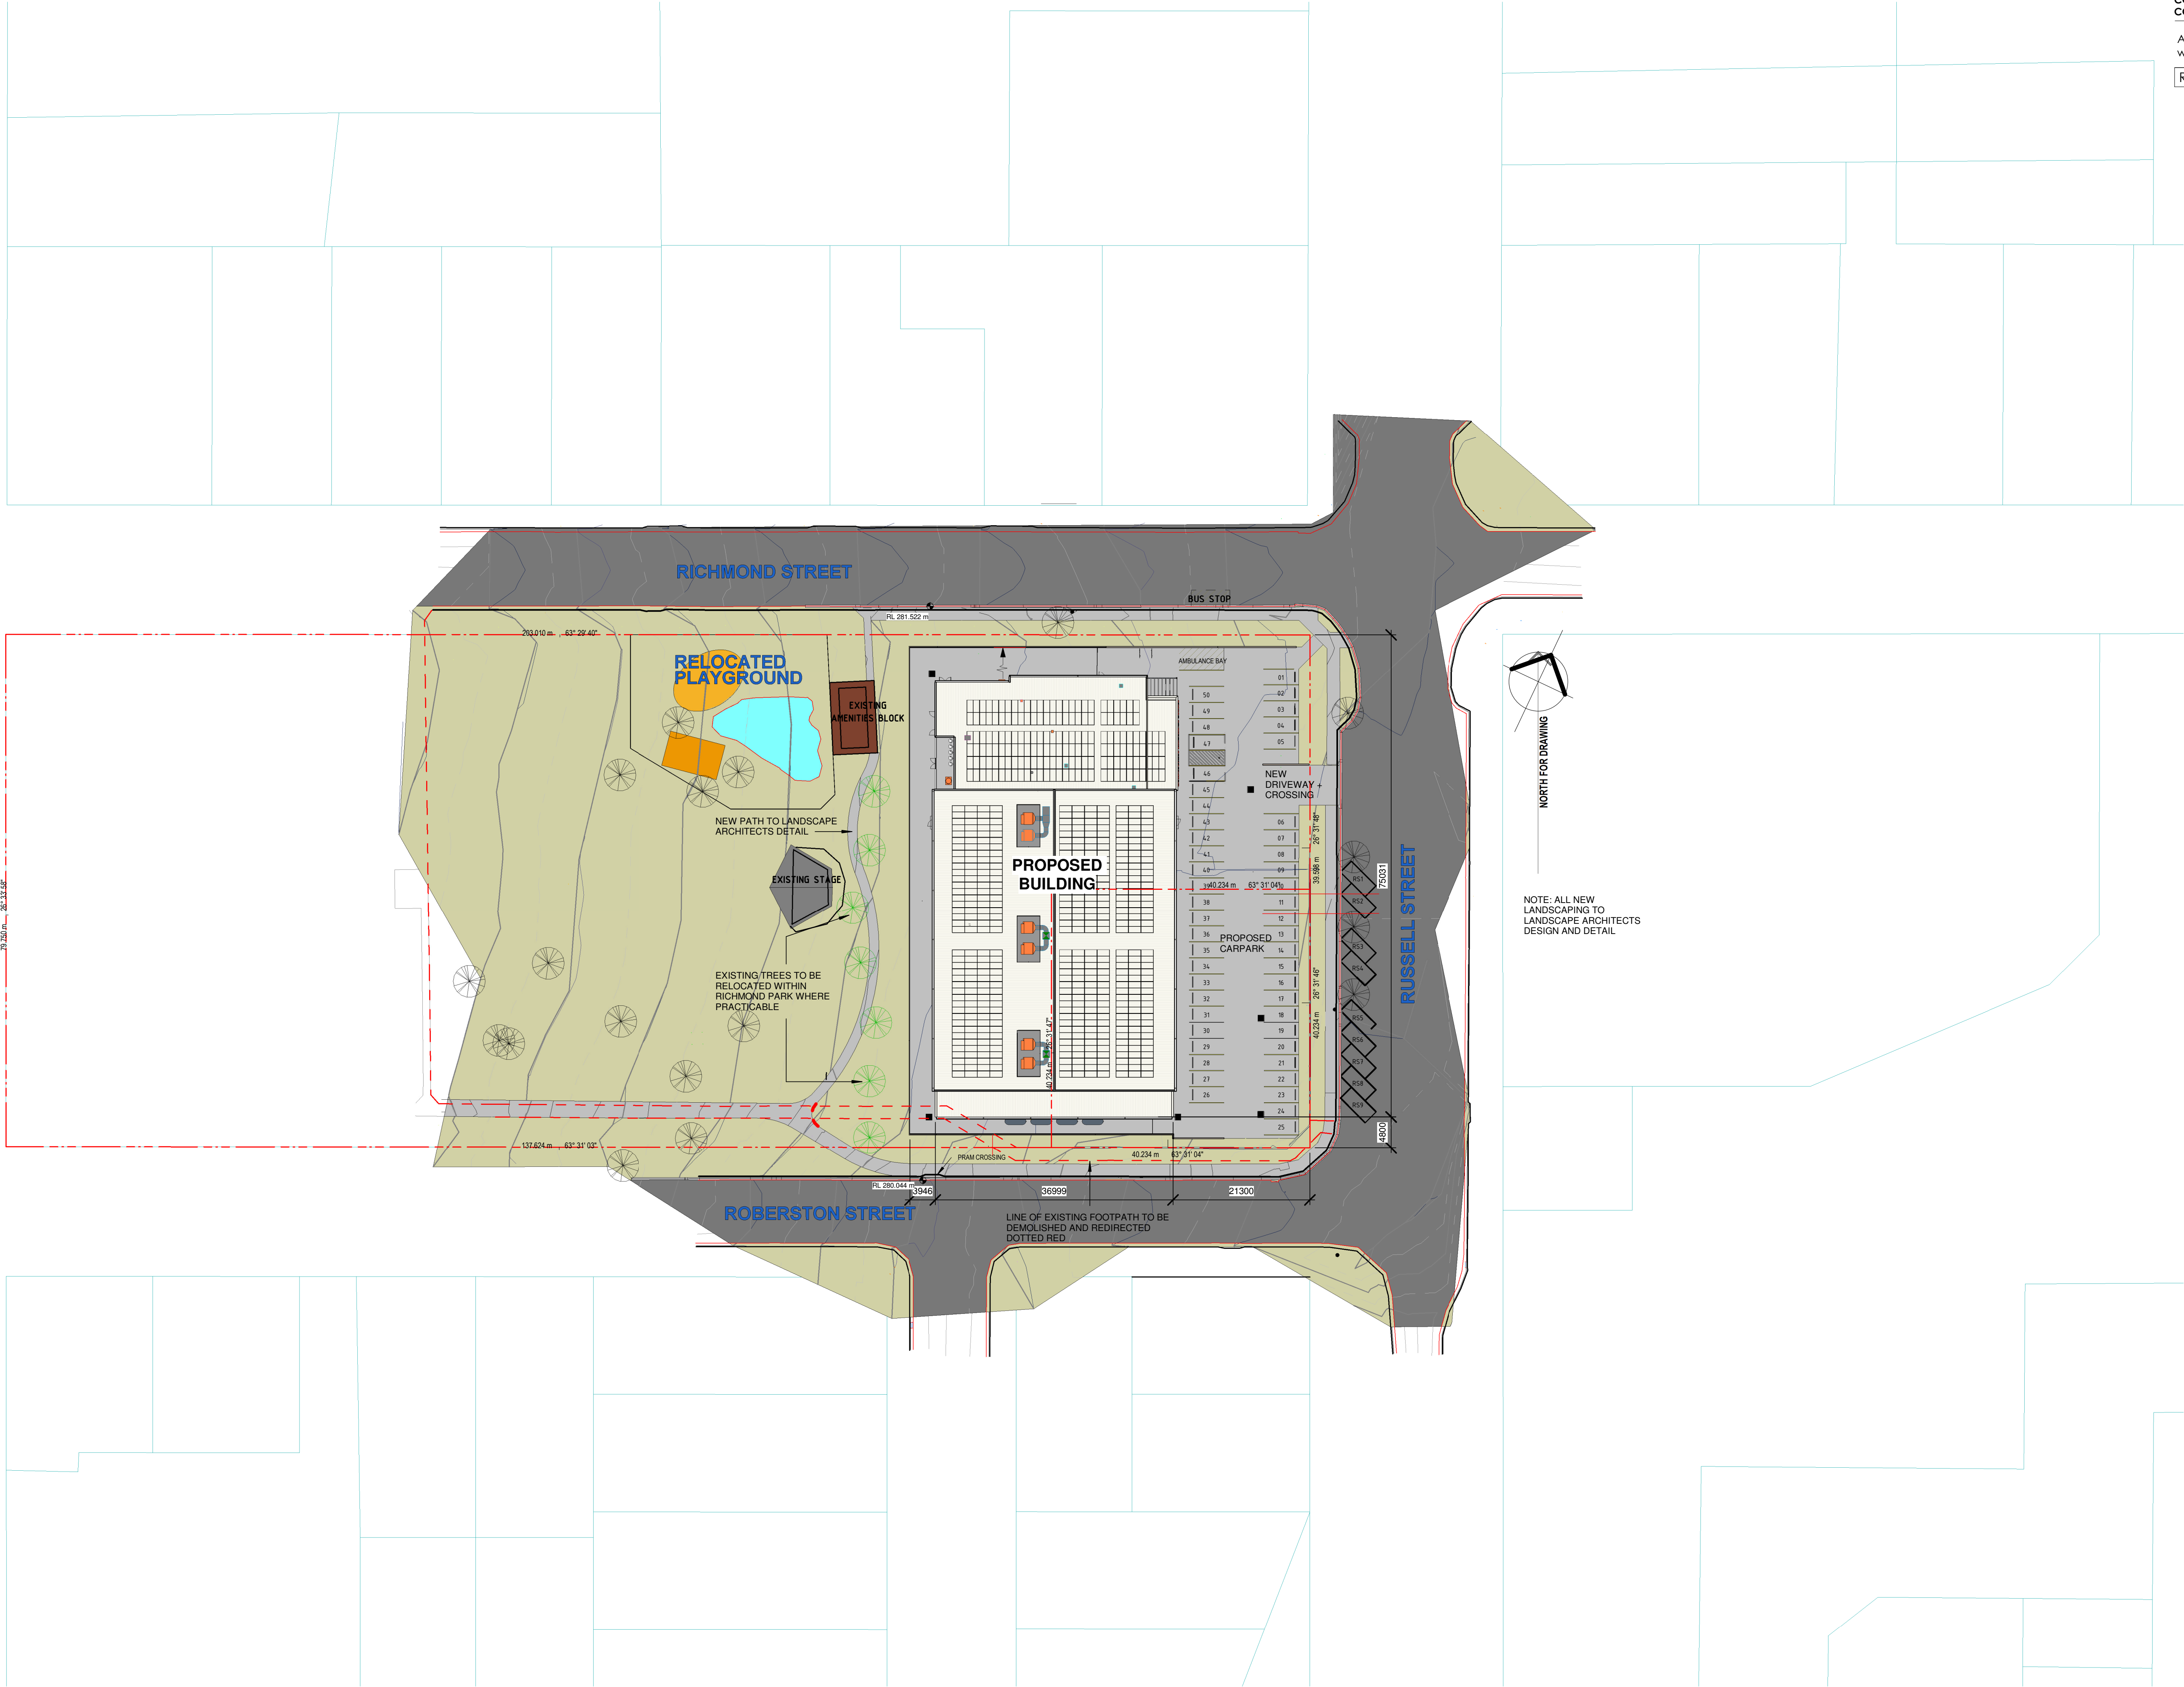

1 SITE PLAN
1:500

CONTRACTORS MUST VERIFY ALL DIMENSIONS ON SITE BEFORE COMMENCING ANY WORK OR PREPARING SHOP DRAWINGS

All Architectural drawing sheets to be cross-referenced with other relevant disciplines.

Rev	Description	Date
-----	-------------	------

CONSULTANT 4:
WEBB AUSTRALIA GROUP (NSW) PTY LTD
LEVEL 2 17 BOLTON STREET
NEWCASTLE NSW 2300 AUSTRALIA
T +61 2 4929 3225 | M +61 478 412 035
MECHANICAL ENGINEERING

CONSULTANT 3:
GLENN HAIG & PARTNERS
Coffs Harbour
P. 02 6658 2444 P. 02 9310 1952
PO Box 192 PO Box 489
SAWTELL, NSW, 2452 SURRY HILLS, NSW, 2090
HYDRAULIC + FIRE CONSULTANTS office@glennhaig.com.au

CONSULTANT 2:
SPECTRUM
ENGINEERING SOLUTIONS
1 Davis Place
Glenhaven NSW 2156
Phone: (02) 8850 6802
Mobile: 0419 294 533
Email: nat@spectrumsolutions.com.au

CONSULTANT 1:
PM DESIGN GROUP
Engineering Solutions
50 Gheringhap Street
Geelong, Victoria, Australia 3320
PH: 03 5249 4800
e: admin@pmdesign.com.au
STRUCTURAL + CIVIL ENGINEERING

DESIGN ARCHITECT:
FACILITY DESIGN GROUP
Architecture & Construction
AQUATIC ■ SPORTS ■ LEISURE ■ CIVIC ■ PROJECT MANAGEMENT
NSW Reg. No. 7168
ABN 75 063 999 424
info@fdg.com.au
www.fdg.com.au
02 4446 0777
PO Box 62
Camberwata NSW 2540

CLIENT:
Snowy Valleys Council

PROJECT NAME:
MULTIPURPOSE + EVACUATION CENTRE
for DA
PROJECT ADDRESS:
RICHMOND PARK, TUMUT NSW
Lot 1 Section 81 DP 759004 and
Lot 701 DP 1059193.

DRAWING TITLE:
SITE PLAN


SHEET ISSUE DATE: 28.02.2025	DRAWING NO. REV.	A1 PRINT SIZE
REVISION DATE:		
SCALE: 1:500 @ A1	A.050	
JOB NO.: W366		

DRAWN BY: AT CHECKED BY: S. JOHANSSON

COPYRIGHT FACILITY DESIGN GROUP PTY. LIMITED. ALL RIGHTS RESERVED. DO NOT SCALE OFF DRAWINGS. WORK TO FIGURED DIMENSIONS ONLY. VERIFY DIMENSIONS ON SITE PRIOR TO COMMENCING WORK.

NOMINATED ARCHITECT: STEPHEN JOHANSSON - NSW REG No. 7168

5/03/2025 12:11:21 PM

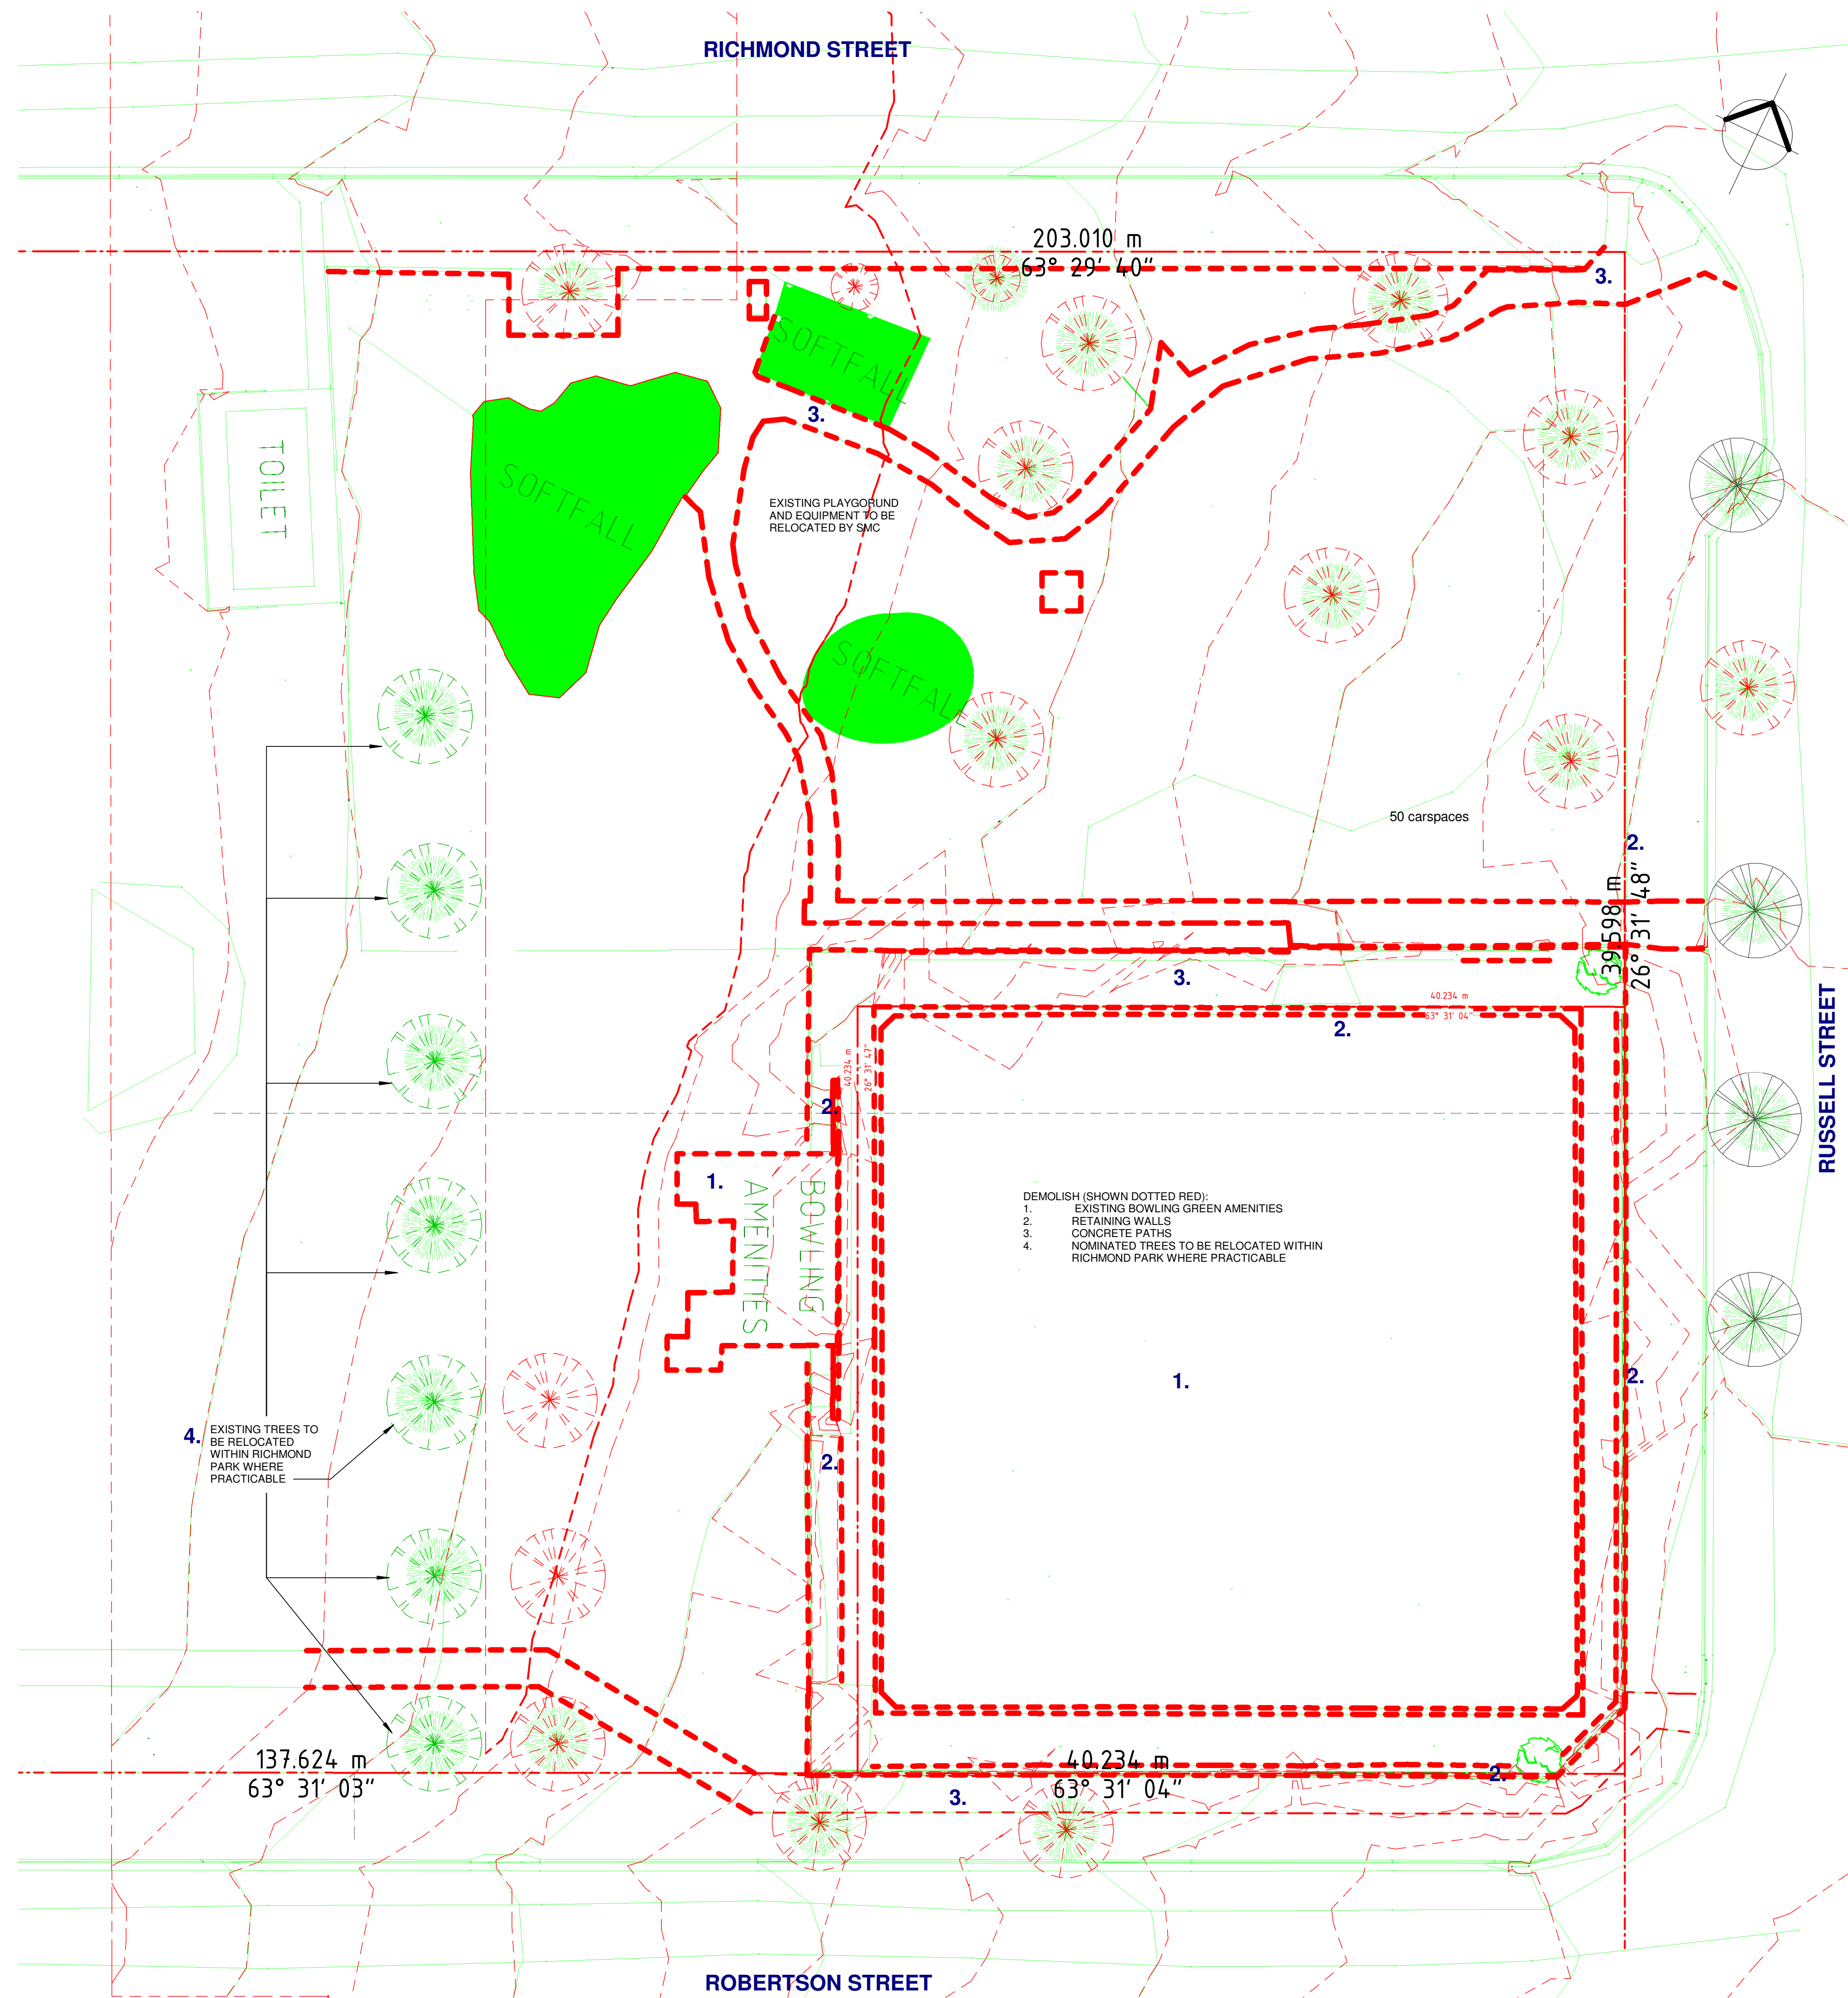

1 DEMOLITION PLAN
1:200

CONTRACTORS MUST VERIFY ALL DIMENSIONS ON SITE BEFORE COMMENCING ANY WORK OR PREPARING SHOP DRAWINGS

All Architectural drawing sheets to be cross-referenced with other relevant disciplines.

Rev	Description	Date
-----	-------------	------

CONSULTANT 4:

WEBB AUSTRALIA GROUP (NSW) PTY LTD

LEVEL 2 17 BOLTON STREET
NEWCASTLE NSW 2300 AUSTRALIA
T +61 2 4929 2225 M +61 478 412 035
MECHANICAL ENGINEERING

CONSULTANT 3:

GLENN HAIG & PARTNERS

Coffs Harbour
P. 02 6658 2444 P. 02 9310 1952
PO Box 192 PO Box 489
SAWTELL, NSW, 2452 SURRY HILLS, NSW, 2090
HYDRAULIC + FIRE CONSULTANTS office@glennhaig.com.au

CONSULTANT 2:

SPECTRUM

1 Davis Place
Glenhaven NSW 2156
ENGINEERING SOLUTIONS
Phone: (02) 8850 6802
Mobile: 0419 294 533
Email: nat@spectrumengineering.com.au

CONSULTANT 1:

PM DESIGN GROUP

50 Gheringhap Street
Geelong, Victoria, Australia 3320
PH: 03 5249 4800
e: admin@pmdesign.com.au
STRUCTURAL + CIVIL ENGINEERING

DESIGN ARCHITECT:

FACILITY DESIGN GROUP

Architecture & Construction
AQUATIC ■ SPORTS ■ LEISURE ■ CIVIC ■ PROJECT MANAGEMENT

NSW Reg. No. 7168
ABN 75 083 999 424
e: info@fdg.com.au
w: www.fdg.com.au
p: 02 4446 0777
p: PO Box 62
Camberwata NSW 2540

CLIENT:

Snowy Valleys Council

PROJECT NAME:

MULTIPURPOSE + EVACUATION CENTRE

for DA

PROJECT ADDRESS:
RICHMOND PARK, TUMUT NSW
Lot 1 Section 81 DP 759004 and
Lot 701 DP 1059193.

DRAWING TITLE:

DEMOLITION PLAN

SHEET ISSUE DATE: 28.02.2025		DRAWING NO. REV.	
REVISION DATE:			
SCALE: 1:200 @ A1		A.051	
JOB NO.: W366			

DRAWN BY: AT CHECKED BY: S. JOHANSSON

COPYRIGHT FACILITY DESIGN GROUP PTY. LIMITED. ALL RIGHTS RESERVED. DO NOT SCALE OFF DRAWINGS. WORK TO FIGURED DIMENSIONS ONLY. VERIFY DIMENSIONS ON SITE PRIOR TO COMMENCING WORK.


NOMINATED ARCHITECT: STEPHEN JOHANSSON - NSW REG No. 7168

5/03/2025 12:11:27 PM

CONTRACTORS MUST VERIFY ALL DIMENSIONS ON SITE BEFORE COMMENCING ANY WORK OR PREPARING SHOP DRAWINGS

All Architectural drawing sheets to be cross-referenced with other relevant disciplines.

Rev	Description	Date
-----	-------------	------

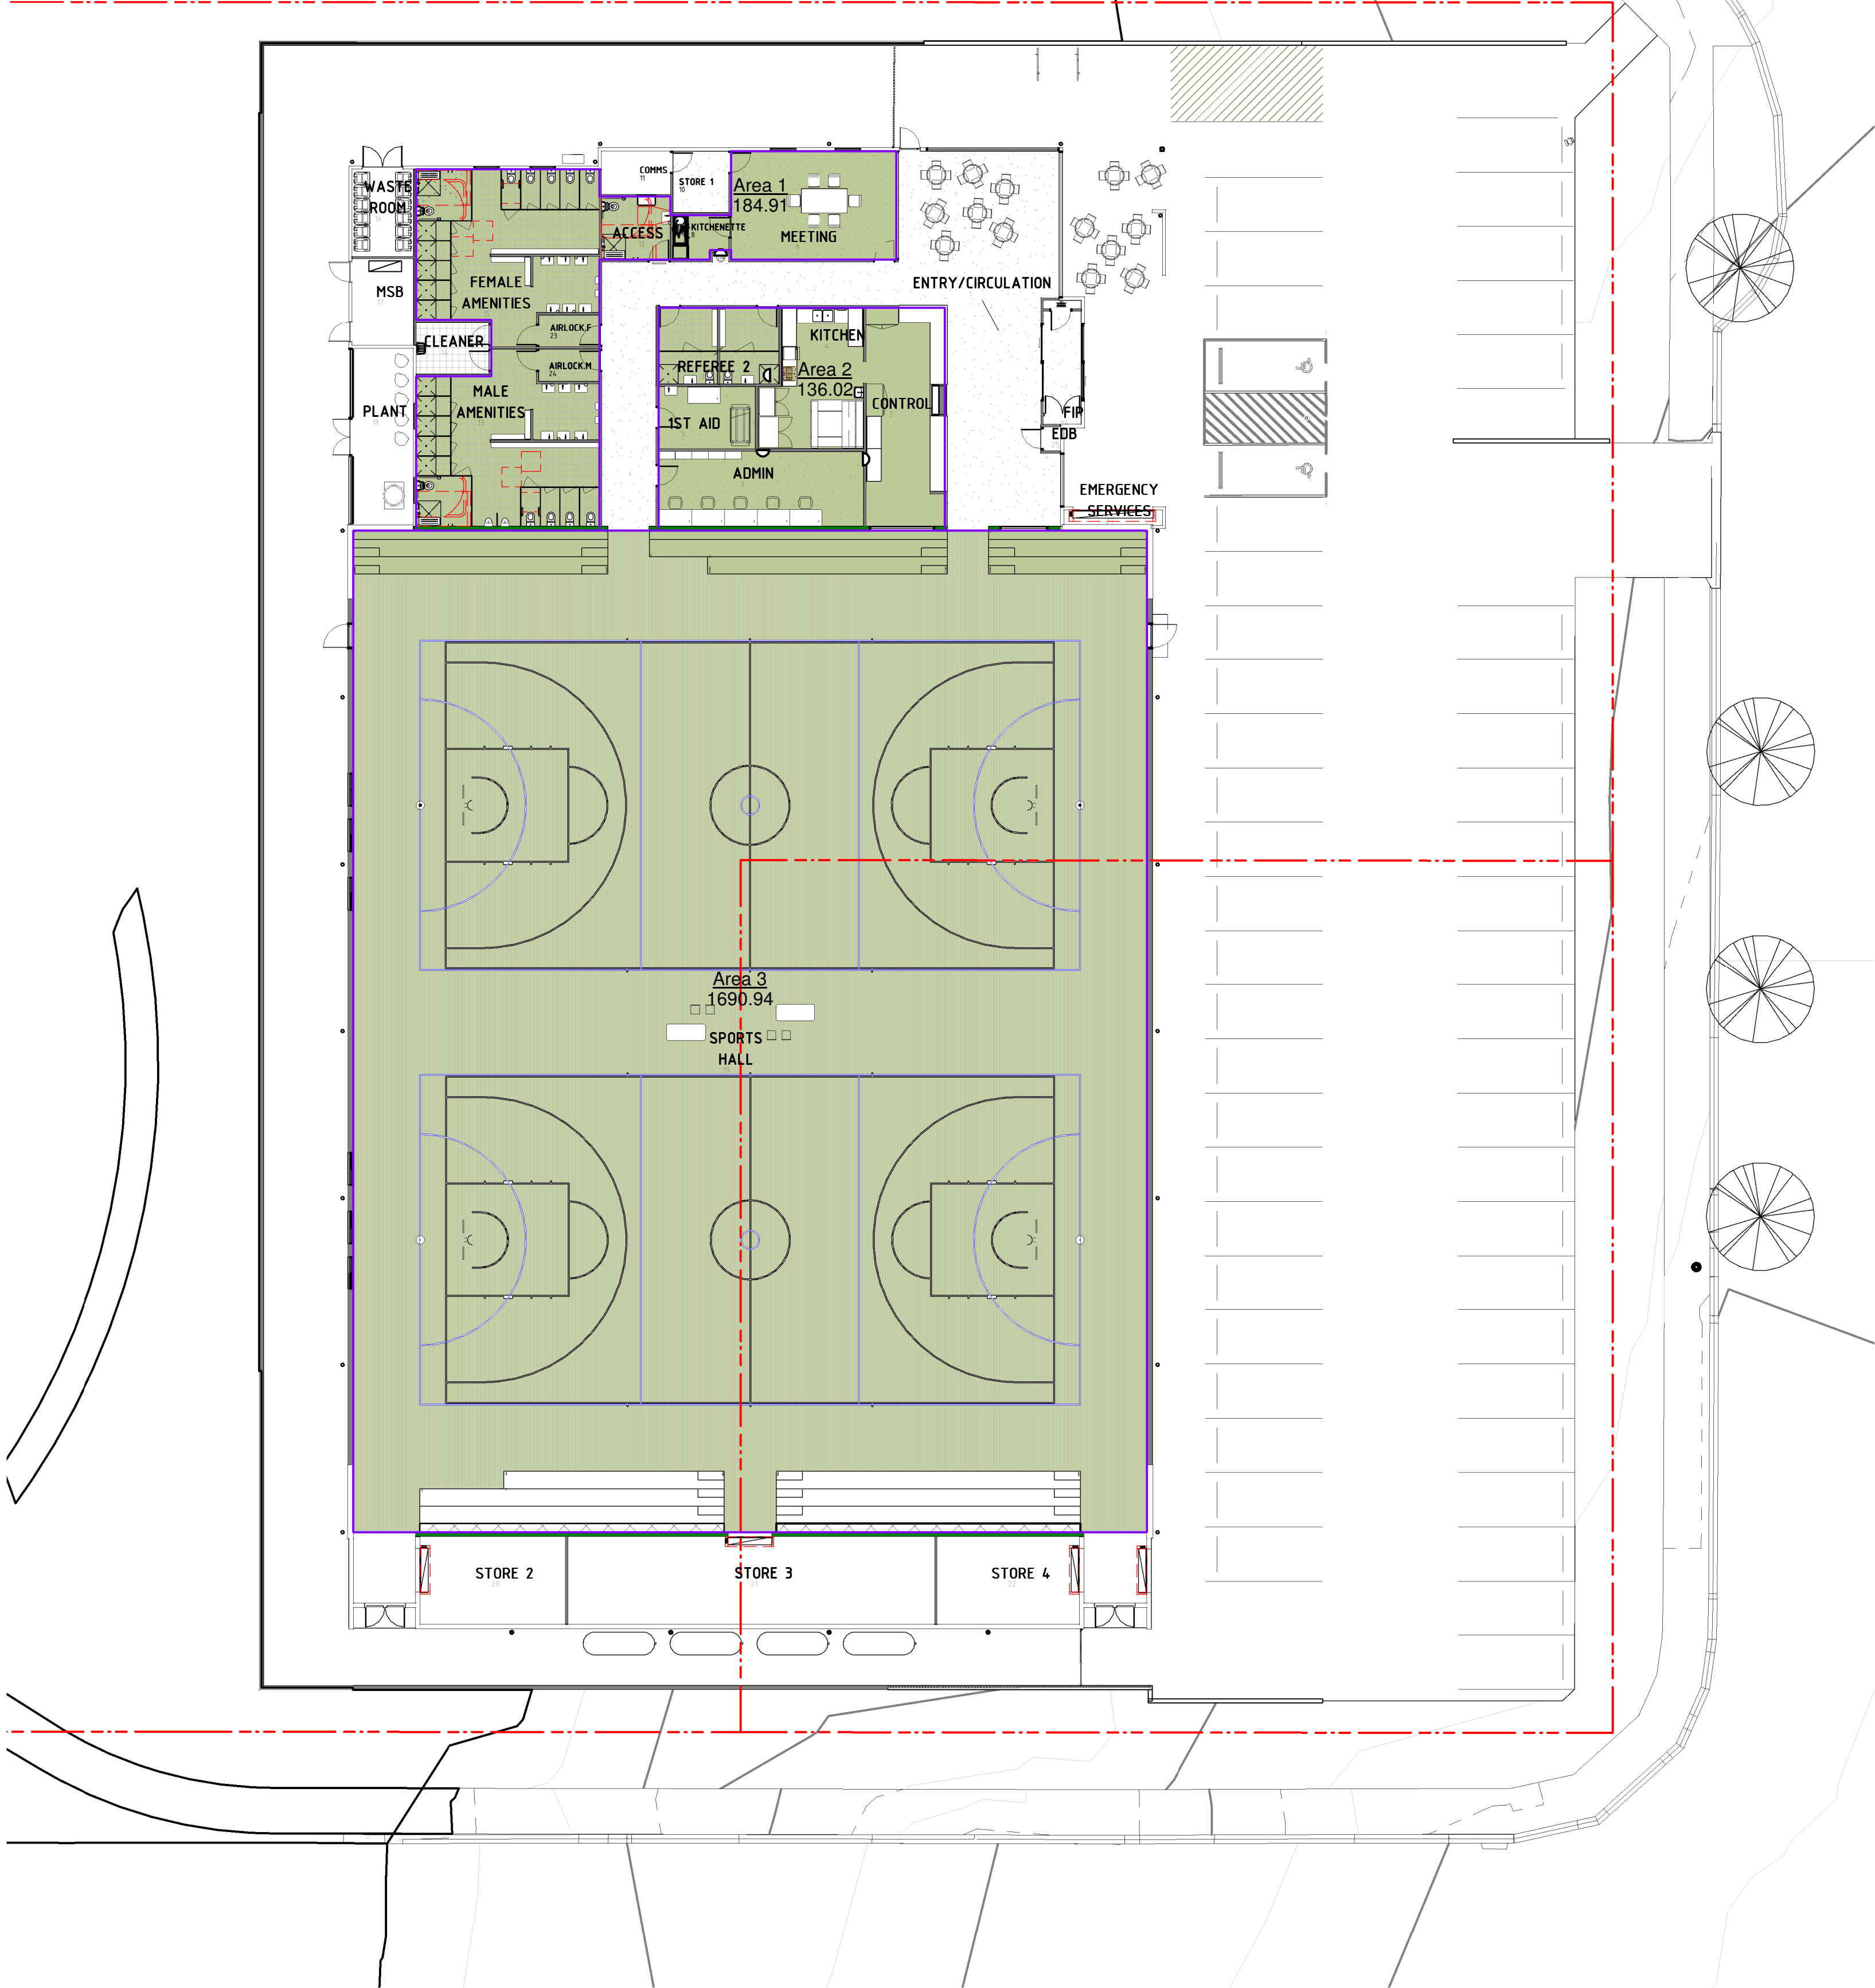

Area Schedule (Gross Floor Area)		
Area No..	Area Type	Area
1	Gross Building Area	184.91 m²
2	Gross Building Area	136.02 m²
3	Gross Building Area	1690.94 m²
		2011.87 m²

TOTAL CONSOLIDATED SITE AREA
(Lot 1 Section 81 DP 759004 +
Lot 701 DP 1059193. = 16,196.29m²

1 LEVEL 00
1:200

CONSULTANT 4:

WEBB AUSTRALIA GROUP (NSW) PTY LTD

LEVEL 2 17 BOLTON STREET
NEWCASTLE NSW 2300 AUSTRALIA
T +61 2 4929 3225 | M +61 478 412 035
MECHANICAL ENGINEERING

CONSULTANT 3:

GLENN HAIG & PARTNERS

Coffs Harbour
P. 02 6658 2444 P. 02 9310 1952
PO Box 192 PO Box 489
SAWTELL, NSW, 2452 SURRY HILLS, NSW, 2010
HYDRAULIC + FIRE CONSULTANTS office@glennhaig.com.au

CONSULTANT 2:

SPECTRUM

1 Davis Place
Glenhaven NSW 2156
ENGINEERING SOLUTIONS
Phone: (02) 8850 6802
Mobile: 0419 294 533
Email: noli@spectrumengineering.com.au

CONSULTANT 1:

PM DESIGN GROUP

50 Ghiesbreght Street
Geelong, Victoria, Australia 3320
PH: 03 5249 4800
e: admin@pmdesign.com.au
STRUCTURAL + CIVIL ENGINEERING

DESIGN ARCHITECT:

FACILITY DESIGN GROUP

Architecture & Construction
AQUATIC ■ SPORTS ■ LEISURE ■ CIVIC ■ PROJECT MANAGEMENT

NSW Reg. No. 7168
ABN: 75 083 999 424
e: info@fdg.com.au
w: www.fdg.com.au
p: 02 4446 0777
p: PO Box 62
Combarawa NSW 2540

CLIENT:

Snowy Valleys Council

PROJECT NAME:
MULTIPURPOSE + EVACUATION CENTRE

for DA

PROJECT ADDRESS:
RICHMOND PARK, TUMUT NSW
Lot 1 Section 81 DP 759004 and
Lot 701 DP 1059193.

DRAWING TITLE:

GROSS FLOOR AREA

A1 PRINT SIZE

SHEET ISSUE DATE: 28.02.2025	DRAWING NO. REV.
REVISION DATE:	A.052
SCALE: 1:200 @ A1	
JOB NO.: W366	
DRAWN BY: AT	CHECKED BY: S. JOHANSSON

COPYRIGHT FACILITY DESIGN GROUP PTY. LIMITED. ALL RIGHTS RESERVED. DO NOT SCALE OFF DRAWINGS. WORK TO FIGURED DIMENSIONS ONLY. VERIFY DIMENSIONS ON SITE PRIOR TO COMMENCING WORK.


NOMINATED ARCHITECT: STEPHEN JOHANSSON - NSW REG NO. 7168

5/03/2025 12:11:31 PM


CONTRACTORS MUST VERIFY ALL DIMENSIONS ON SITE BEFORE COMMENCING ANY WORK OR PREPARING SHOP DRAWINGS

All Architectural drawing sheets to be cross-referenced with other relevant disciplines.


Rev	Description	Date
-----	-------------	------

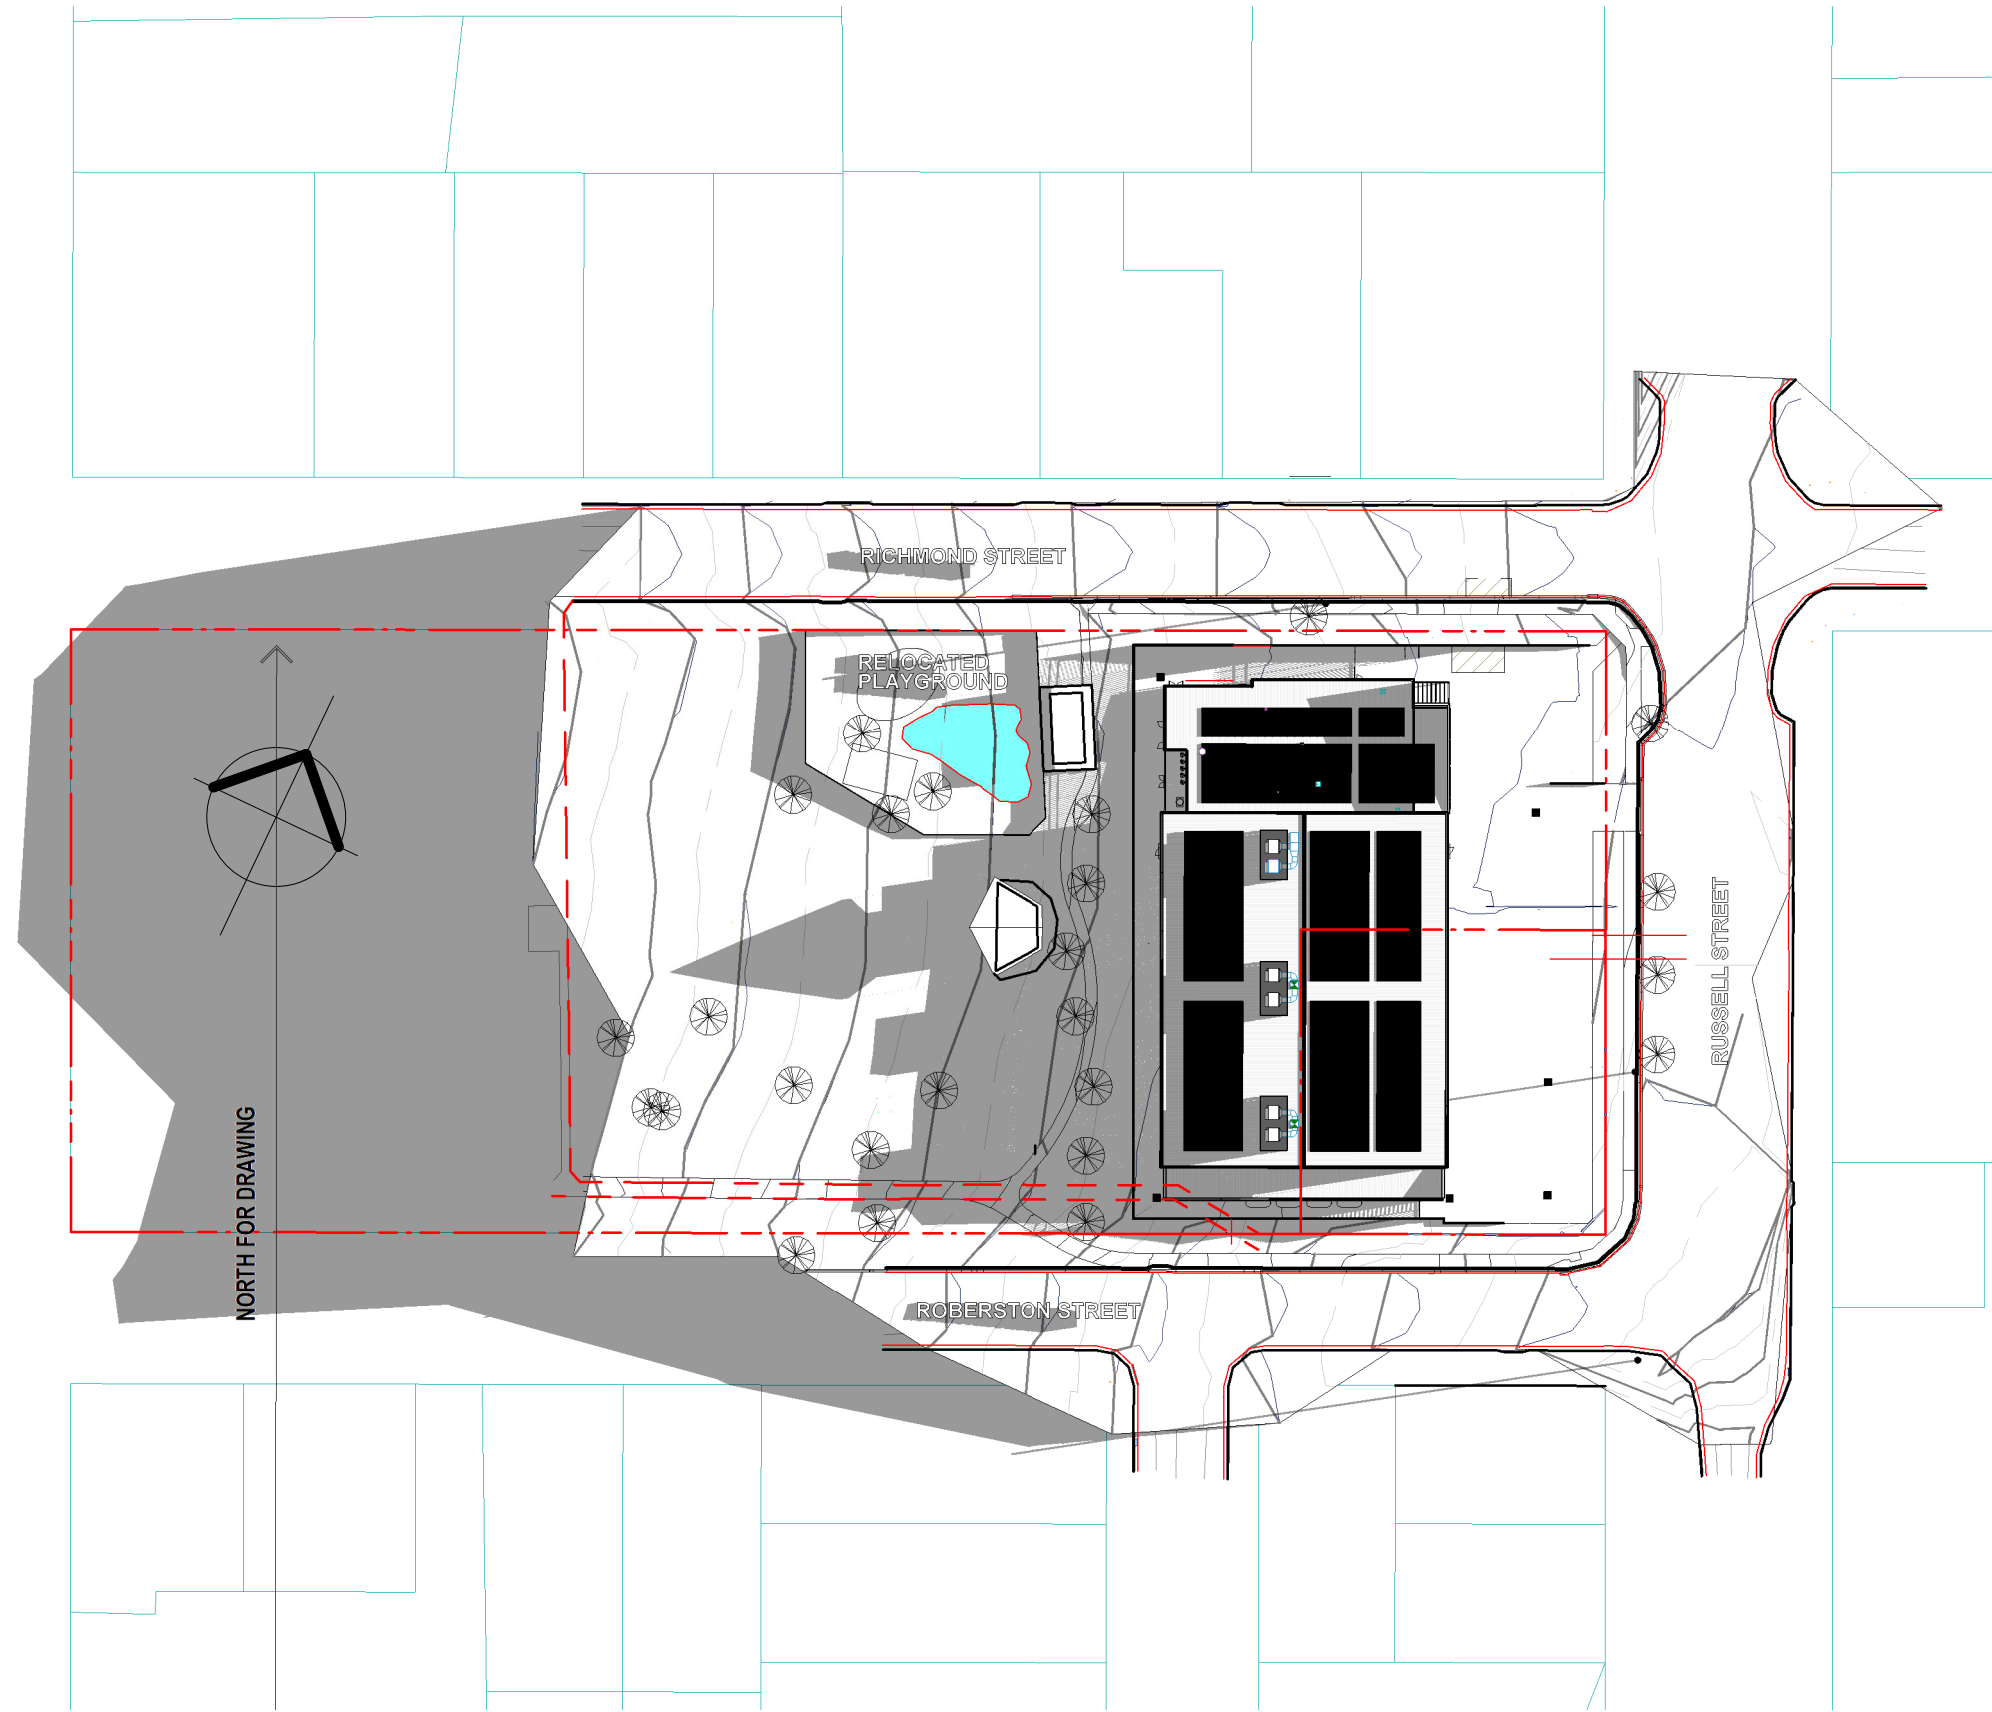


1 SITE PLAN Solar Study 22June 2025 9.00am
1:1000

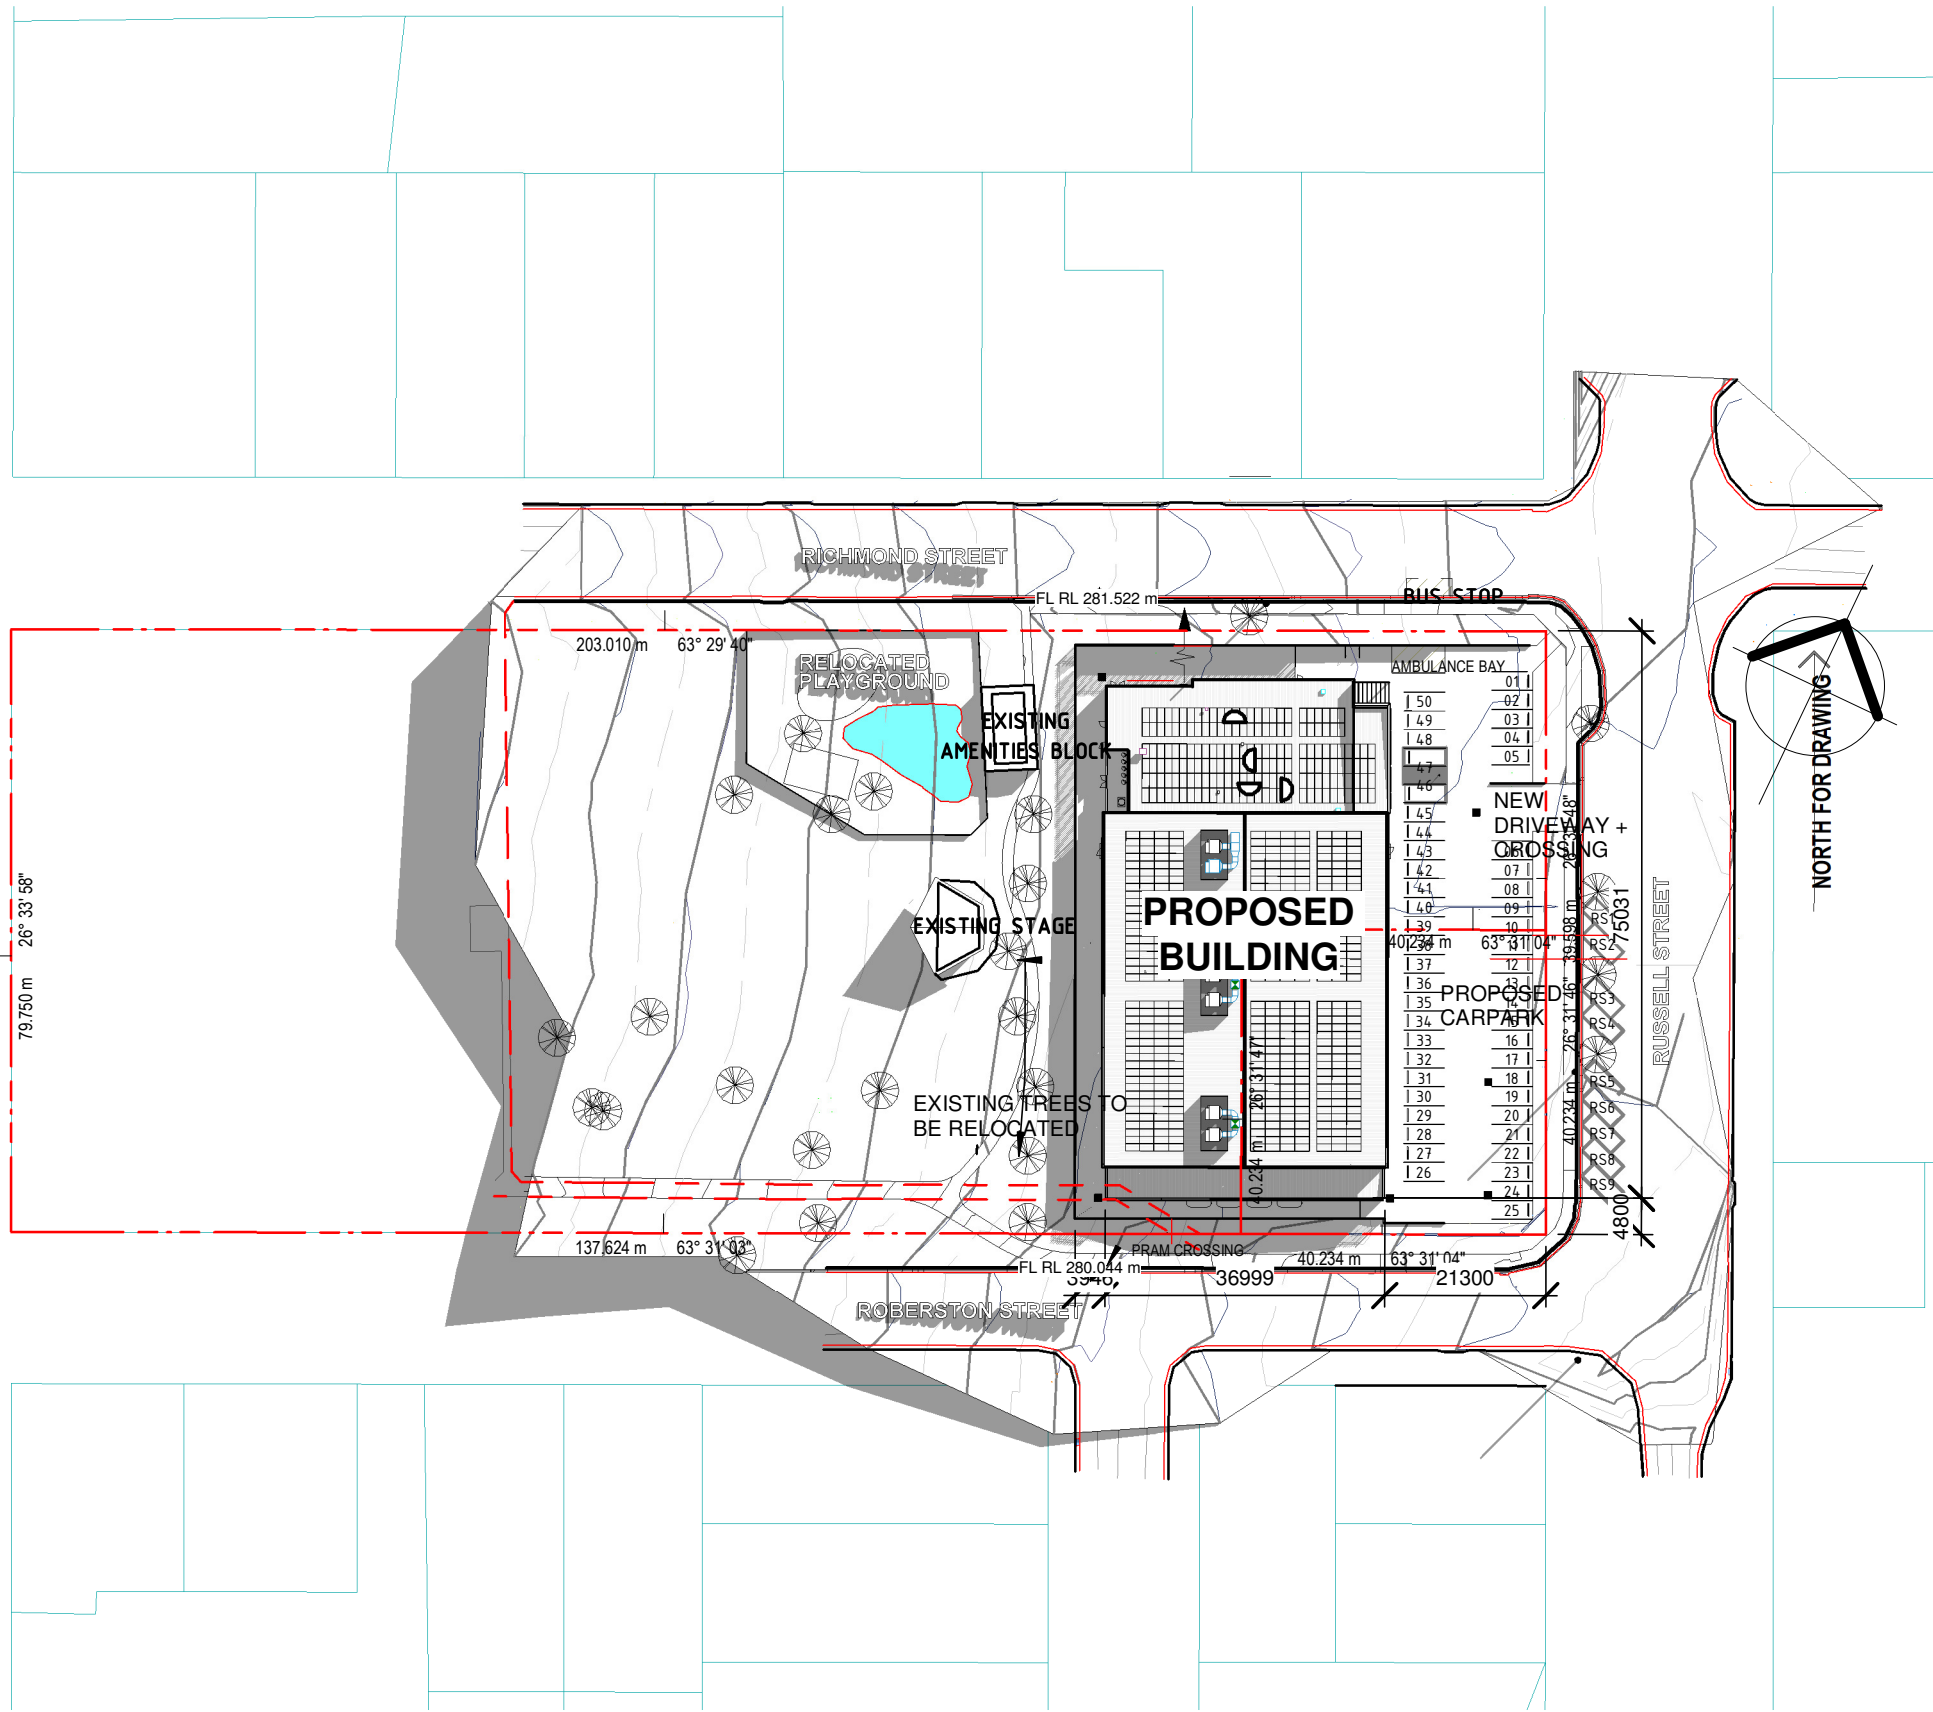

2 SITE PLAN Solar Study 22June 2025 12.00pm
1:1000

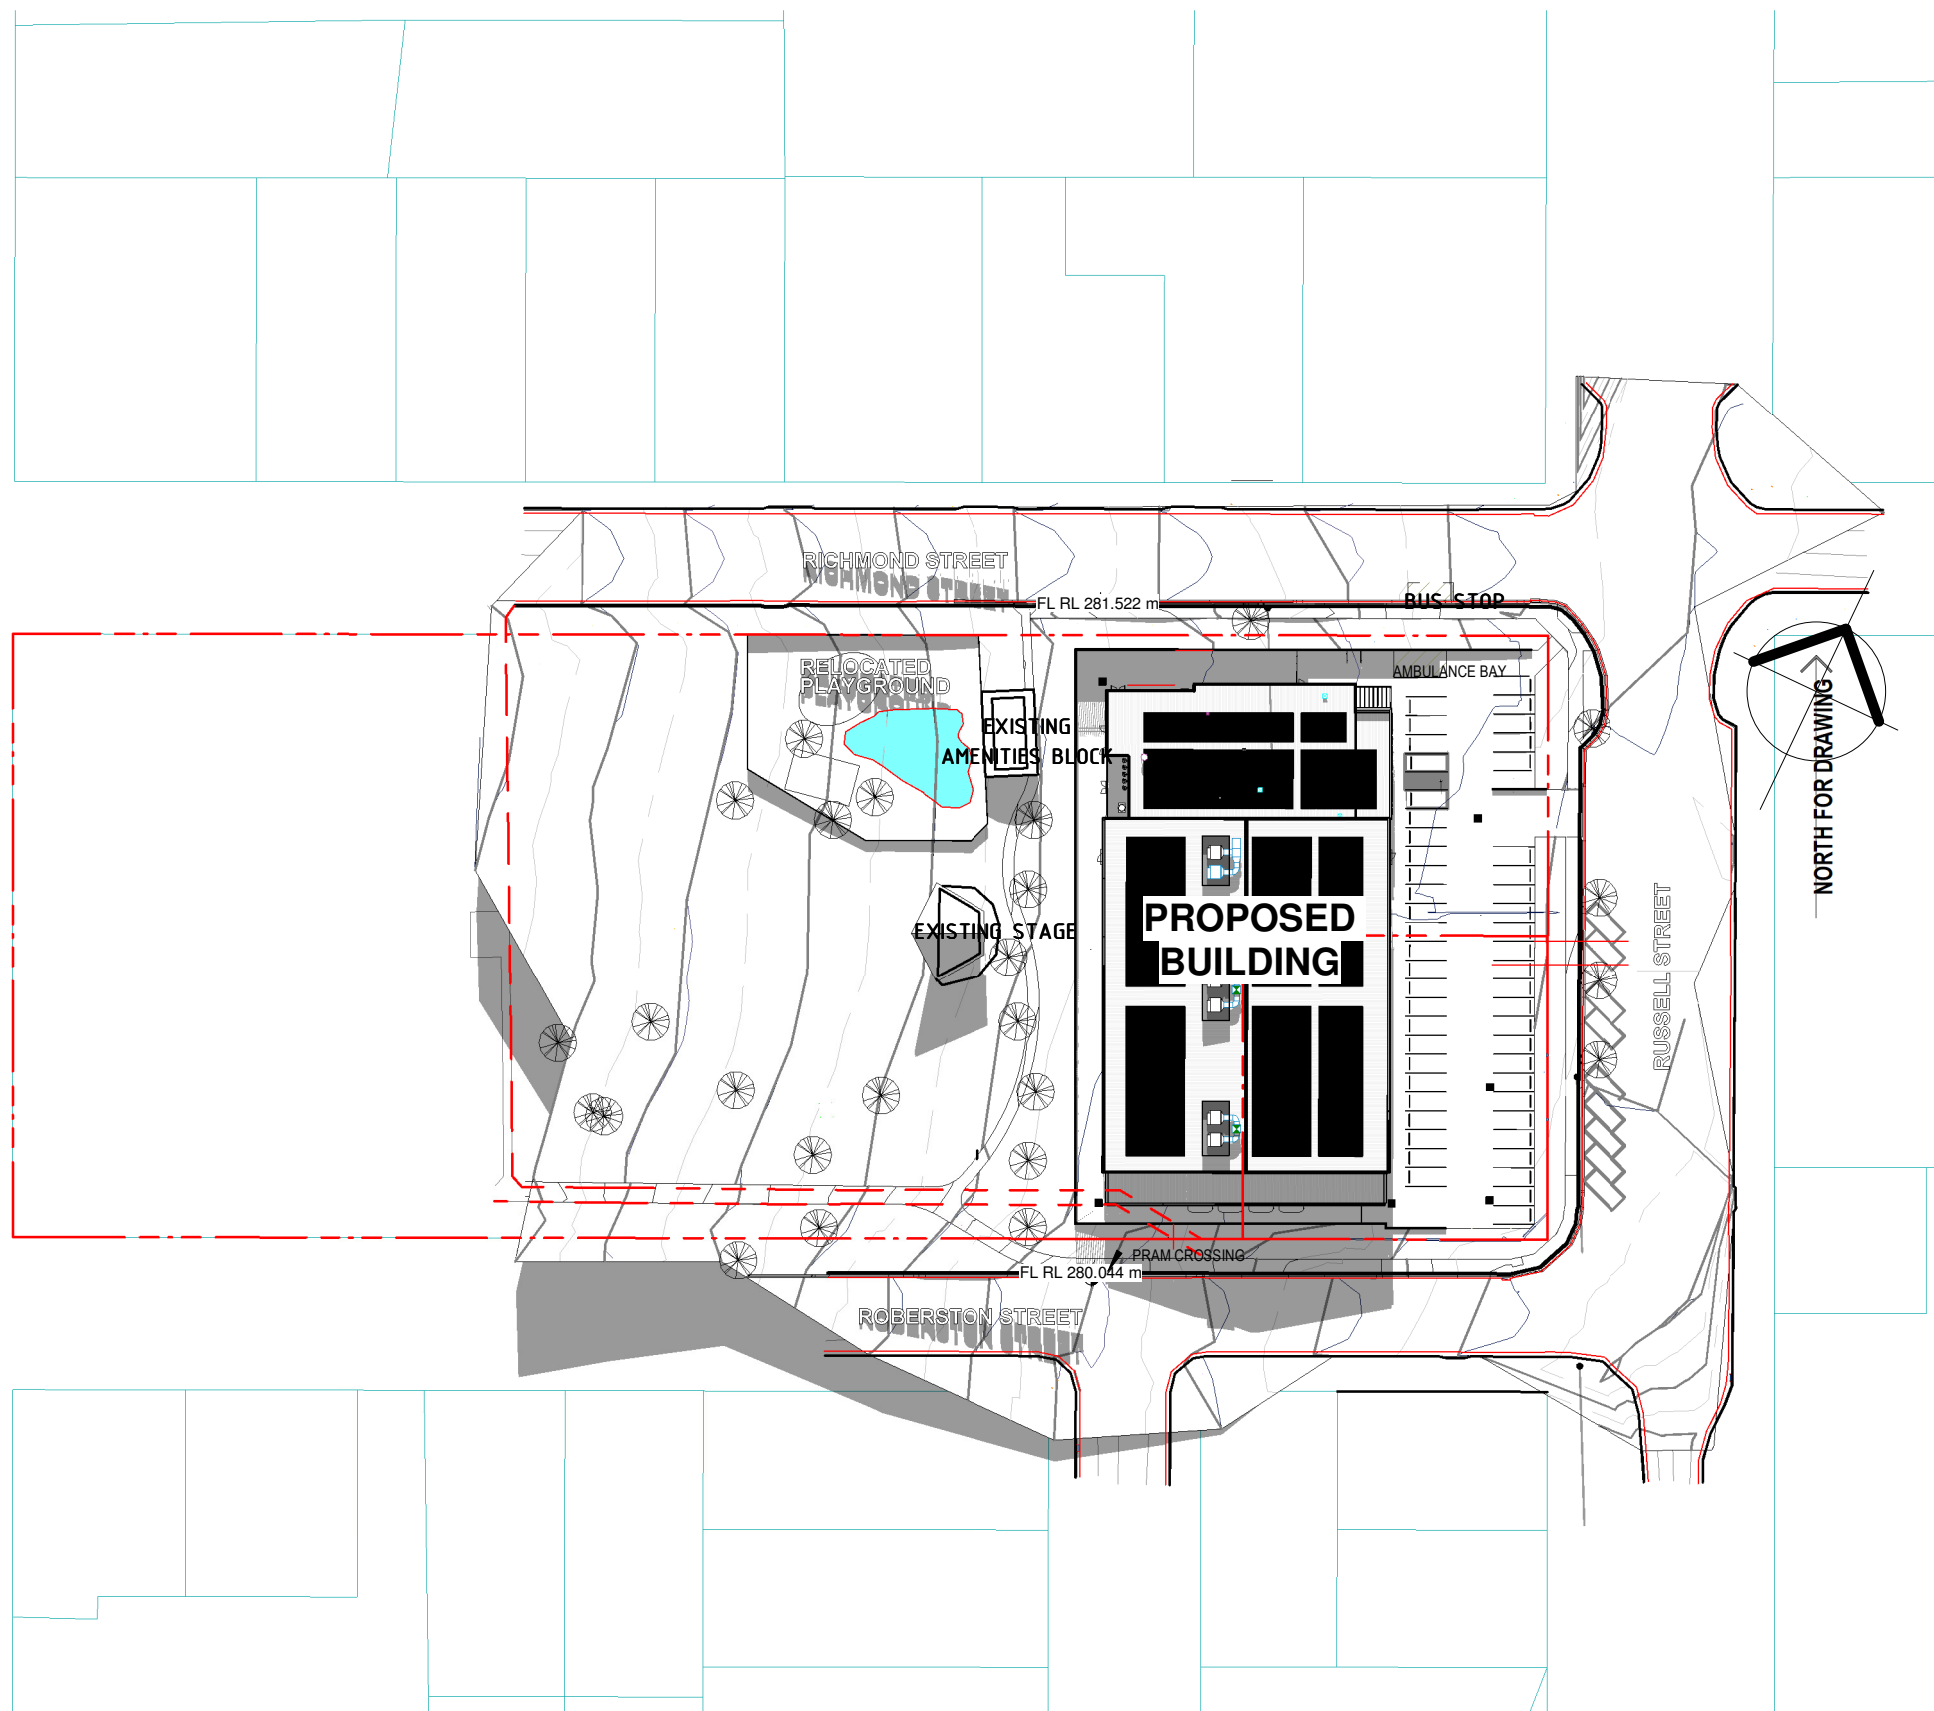

3 SITE PLAN Solar Study 22June 2025 3.00pm
1:1000

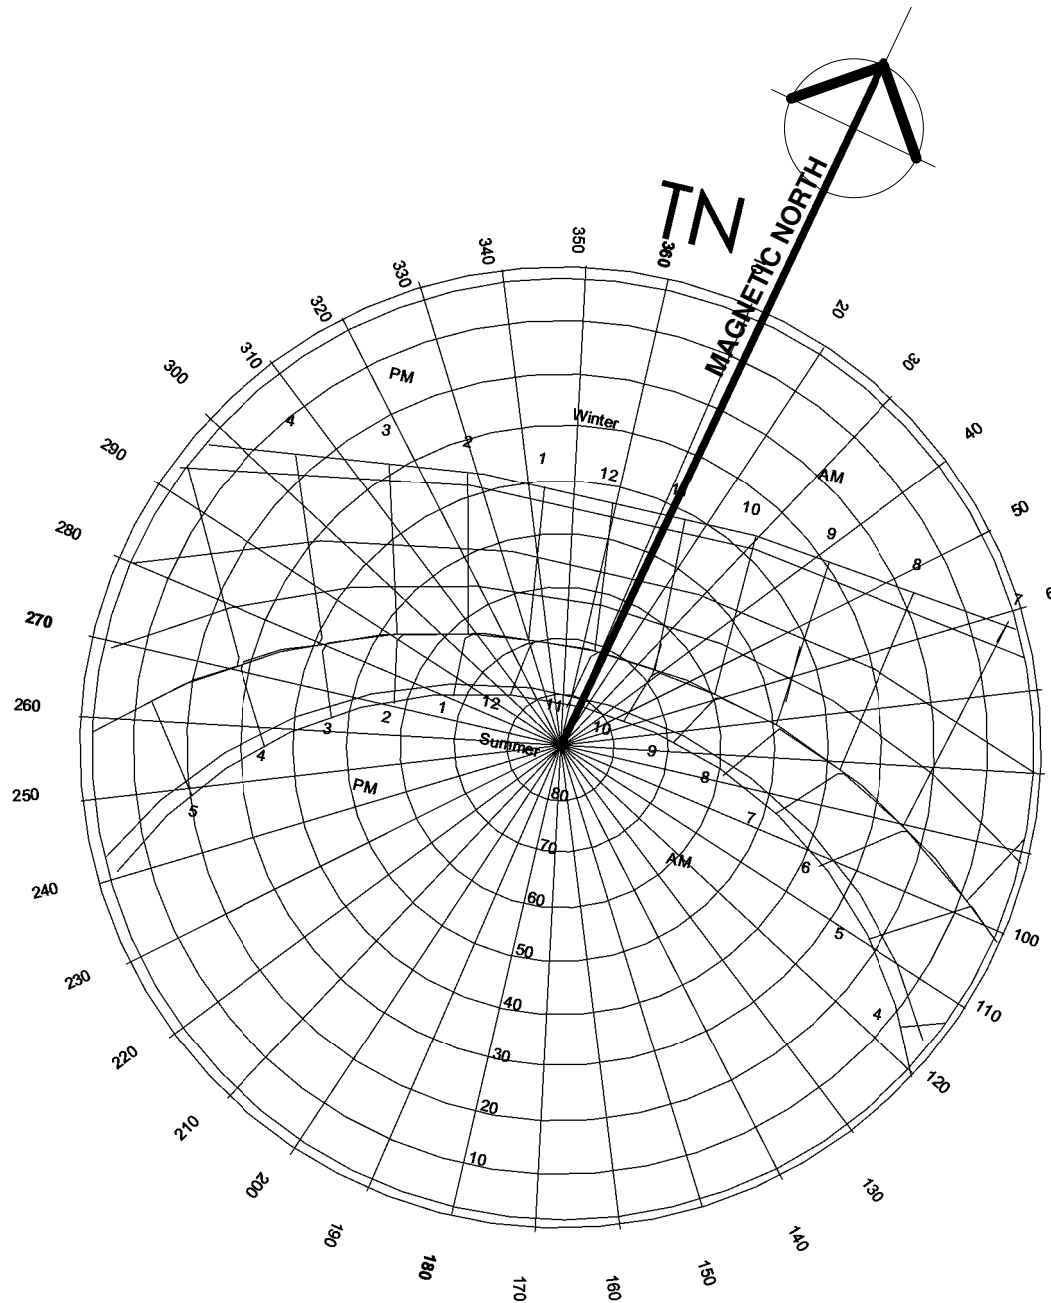

CONSULTANT 4:

50

YEARS

WEBB

WEBB AUSTRALIA GROUP (NSW) PTY LTD
LEVEL 2 17 BOLTON STREET
NEWCASTLE NSW 2300 AUSTRALIA
T +61 2 4929 3225 | M +61 478 412 035
MECHANICAL ENGINEERING

CONSULTANT 3:

GLENN HAIG

& PARTNERS

Coffs Harbour
P. 02 6658 2444 P. 02 9310 1952
PO Box 192 PO Box 489
SAWTELL, NSW, 2452 SURRY HILLS, NSW, 2090
HYDRAULIC + FIRE CONSULTANTS office@glennhaig.com.au

CONSULTANT 2:

SPECTRUM

ENGINEERING SOLUTIONS

1 Davis Place
Glenhaven NSW 2156
Phone: (02) 8850 6802
Mobile: 0419 294 533
Email: noli@specengsolutions.com.au

CONSULTANT 1:

PM DESIGN GROUP

Engineering Solutions

PM DESIGN GROUP
50 Glenelg Street
Geelong, Victoria, Australia 3320
PH: 03 5249 4800
e: admin@pmdesign.com.au
STRUCTURAL + CIVIL ENGINEERING

FACILITY

DESIGN GROUP

Architecture & Construction
AQUATIC ■ SPORTS ■ LEISURE ■ CIVIC ■ PROJECT MANAGEMENT

NSW Reg. No. 7168
ABN 75 083 999 424
e: info@fdg.com.au
w: www.fdg.com.au
p: 02 4446 0777
p: PO Box 62
Camberwell NSW 2340

CLIENT:



PROJECT NAME:

MULTIPURPOSE + EVACUATION CENTRE

for DA

PROJECT ADDRESS:
RICHMOND PARK, TUMUT NSW
Lot 1 Section 81 DP 759004 and
Lot 701 DP 1059193.

DRAWING TITLE:

SHADOW DIAGRAMS

SHEET ISSUE DATE: 28.02.2025
REVISION DATE:

SCALE: 1:1000 @ A1


JOB NO.: W366

DRAWN BY: AT CHECKED BY: S. JOHANSSON

COPYRIGHT FACILITY DESIGN GROUP PTY. LIMITED. ALL RIGHTS RESERVED. DO NOT SCALE OFF DRAWINGS. WORK TO FIGURED DIMENSIONS ONLY. VERIFY DIMENSIONS ON SITE PRIOR TO COMMENCING WORK.

NOMINATED ARCHITECT: STEPHEN JOHANSSON - NSW REG No. 7168

5/03/2025 12:12:40 PM

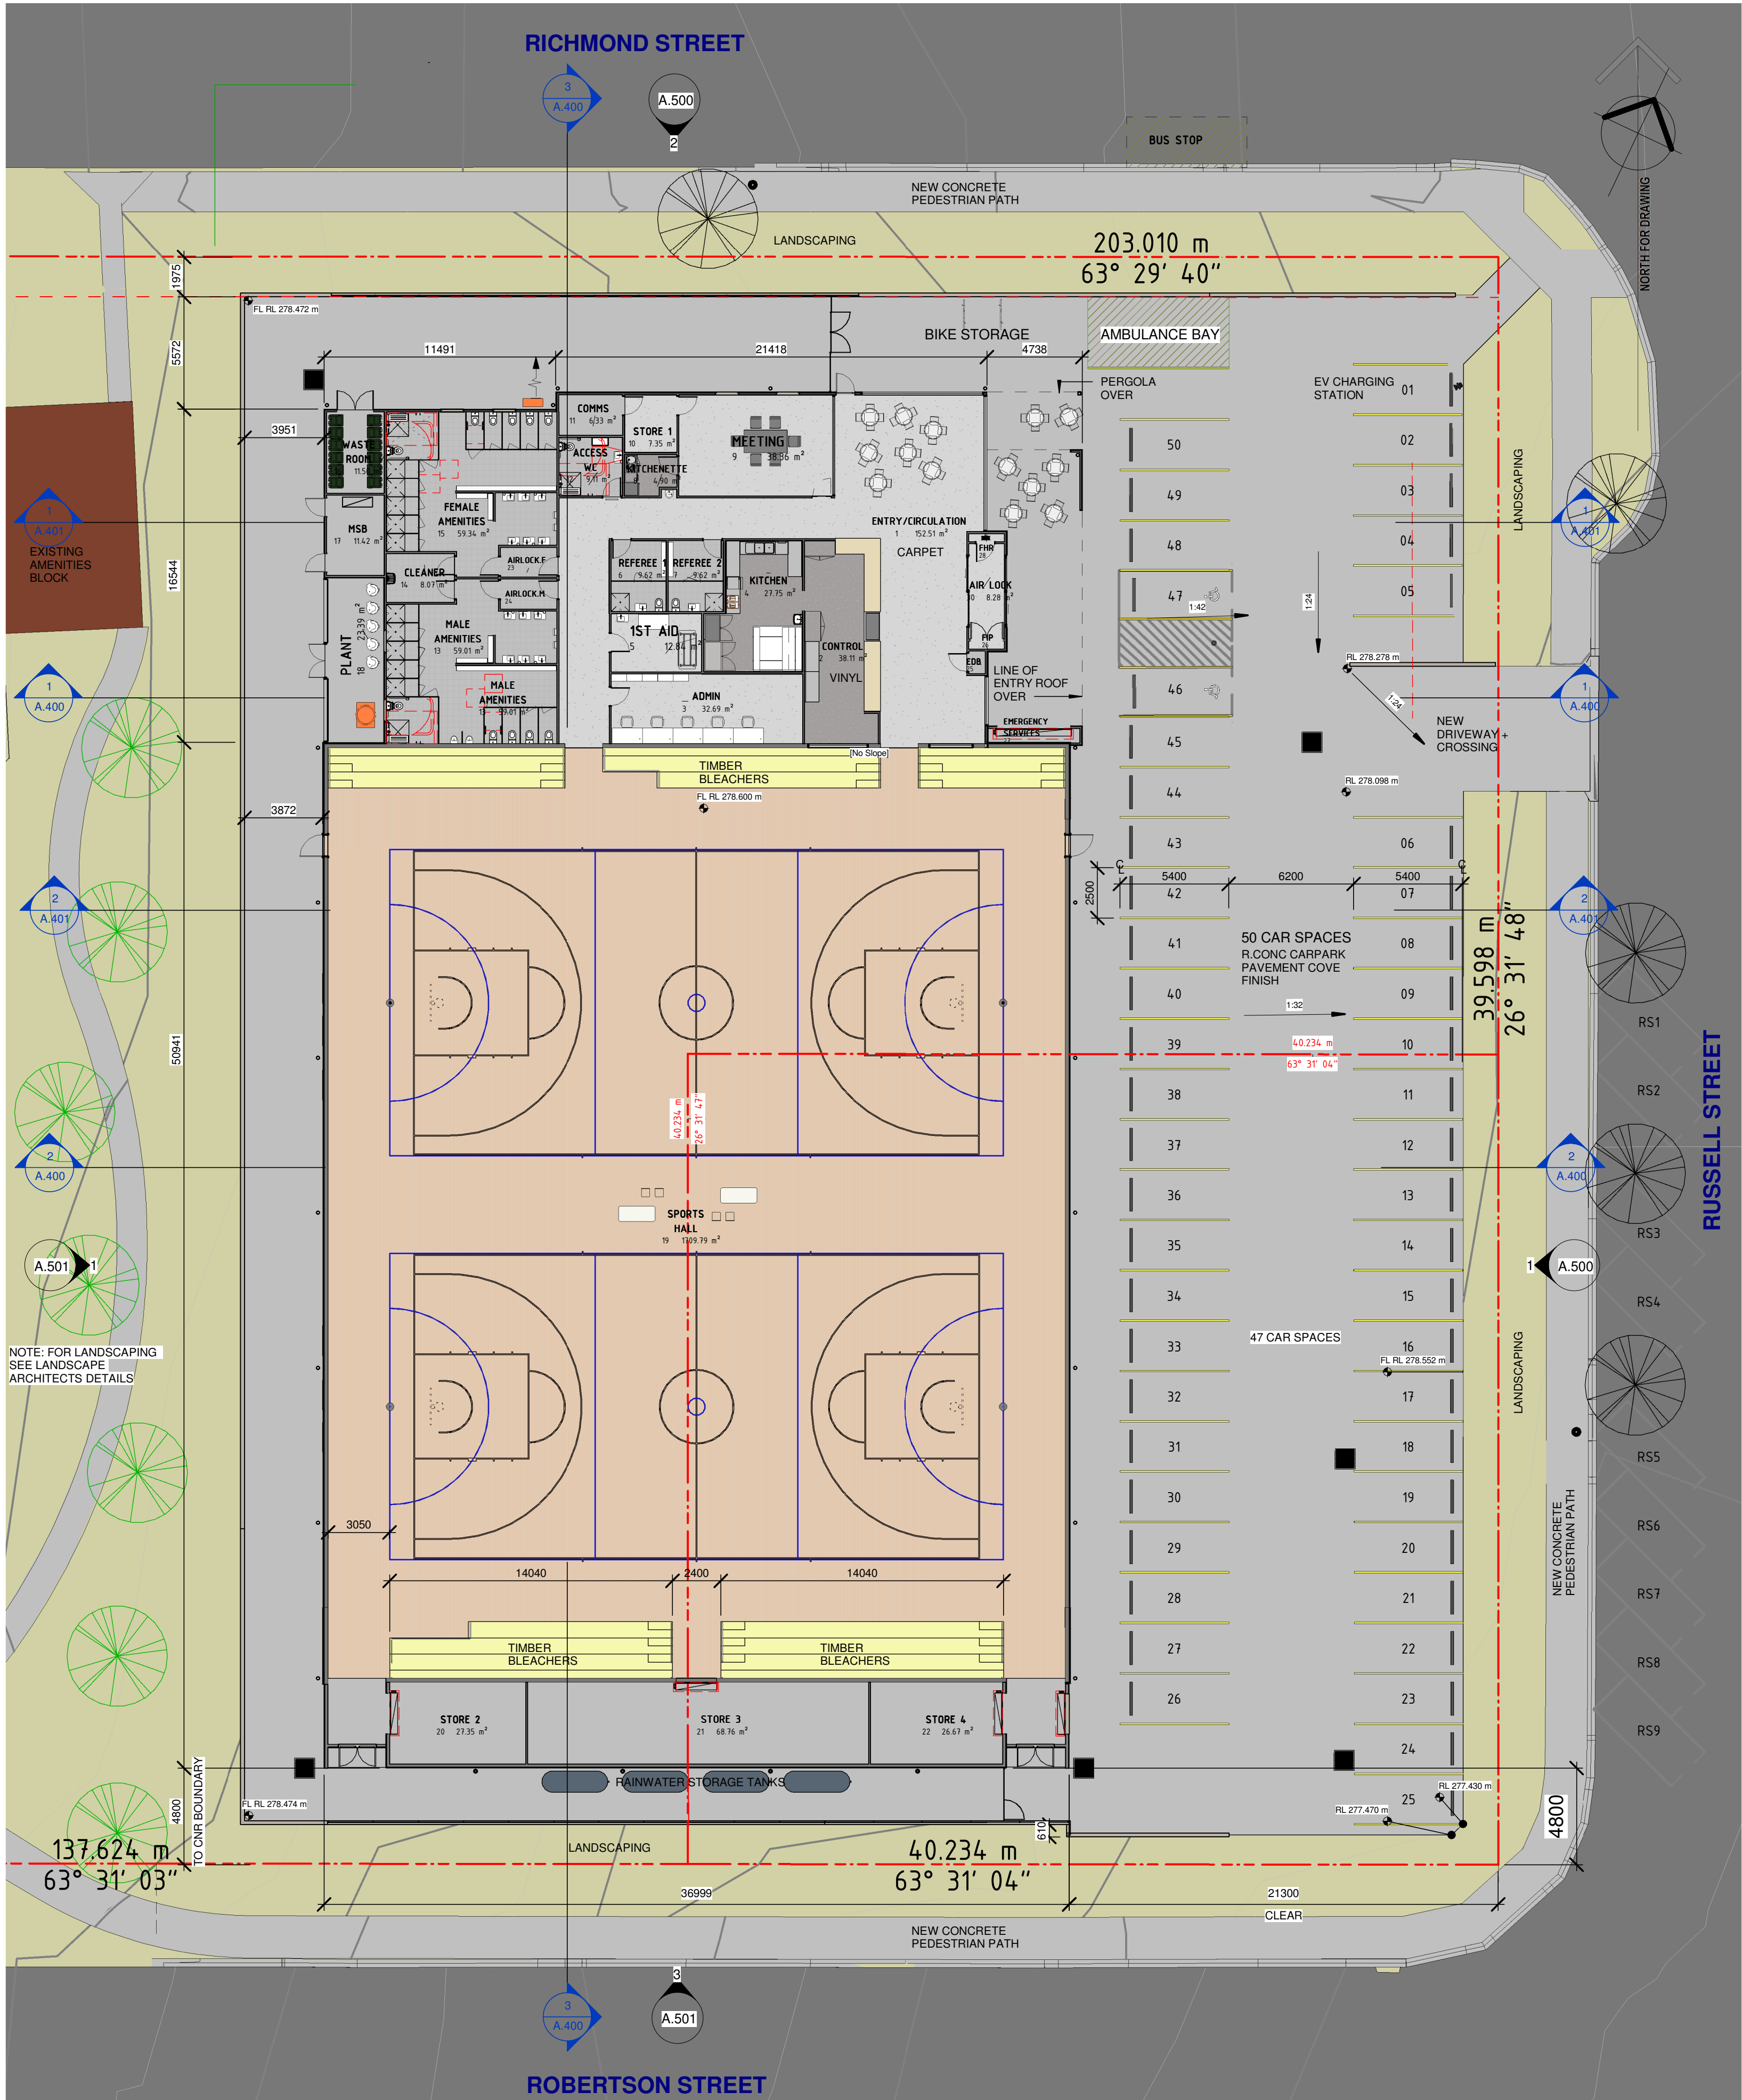

1 FLOOR PLAN
1:200

Room Schedule			
Level	Rm. No.	Name	Area
LEVEL 00	1	ENTRY/CIRCULATION	152.51 m ²
LEVEL 00	2	CONTROL	38.11 m ²
LEVEL 00	3	ADMIN	32.69 m ²
LEVEL 00	4	KITCHEN	27.75 m ²
LEVEL 00	5	1ST AID	12.84 m ²
LEVEL 00	6	REFEREE 1	9.62 m ²
LEVEL 00	7	REFEREE 2	9.62 m ²
LEVEL 00	8	KITCHENETTE	4.90 m ²
LEVEL 00	9	MEETING	38.36 m ²
LEVEL 00	10	STORE 1	7.35 m ²
LEVEL 00	11	COMMS	6.33 m ²
LEVEL 00	12	ACCESS WC	9.11 m ²
LEVEL 00	13	MALE AMENITIES	59.01 m ²
LEVEL 00	14	CLEANER	8.07 m ²
LEVEL 00	15	FEMALE AMENITIES	59.34 m ²
LEVEL 00	16	WASTE ROOM	11.50 m ²
LEVEL 00	17	MSB	11.42 m ²
LEVEL 00	18	PLANT	23.39 m ²
LEVEL 00	19	SPORTS HALL	1709.79 m ²
LEVEL 00	20	STORE 2	27.35 m ²
LEVEL 00	21	STORE 3	68.76 m ²
LEVEL 00	22	STORE 4	26.67 m ²
LEVEL 00	23	AIRLOCK.F	4.11 m ²
LEVEL 00	24	AIRLOCK.M	4.11 m ²
LEVEL 00	25	EDB	0.87 m ²
LEVEL 00	26	FIP	0.67 m ²
LEVEL 00	27	EMERGENCY SERVICES	3.14 m ²
LEVEL 00	28	FHR	0.67 m ²
Not Placed	29	Room	Not Placed
LEVEL 00	30	AIR LOCK	8.28 m ²
			2376.35 m ²

CONTRACTORS MUST VERIFY ALL DIMENSIONS ON SITE BEFORE COMMENCING ANY WORK OR PREPARING SHOP DRAWINGS

All Architectural drawing sheets to be cross-referenced with other relevant disciplines.

Rev	Description	Date
-----	-------------	------

CONSULTANT 4:

50 YEARS 1973-2023

WEBB AUSTRALIA GROUP (NSW) PTY LTD

LEVEL 2 17 BOLTON STREET
NEWCASTLE NSW 2300 AUSTRALIA
T +61 2 4929 2225 | M +61 478 478 035
MECHANICAL ENGINEERING

CONSULTANT 3:

GLENN HAIG & PARTNERS

Coffs Harbour
P. 02 6658 2444 P. 02 9310 1952
PO Box 192 PO Box 489
SAWTELL, NSW, 2452 SURRY HILLS, NSW, 2030
HYDRAULIC + FIRE CONSULTANTS office@glennhaig.com.au

CONSULTANT 2:

SPECTRUM

1 Davis Place
Glenhaven NSW 2156
Phone: (02) 8850 6802
Mobile: 0419 294 533
Email: nat@spectrum-solutions.com.au

CONSULTANT 1:

PM DESIGN GROUP

50 Gheringhap Street
Geelong, Victoria, Australia 3320
PH: 03 5249 4800
e: admin@pmdesign.com.au
STRUCTURAL + CIVIL ENGINEERING

DESIGN ARCHITECT:

FACILITY DESIGN GROUP

Architecture & Construction
AQUATIC ■ SPORTS ■ LEISURE ■ CIVIC ■ PROJECT MANAGEMENT

NSW Reg. No. 7168
ABN 75 583 999 424
info@fdg.com.au
www.fdg.com.au
02 4446 0777
PO Box 62
Cammeray NSW 1580

CLIENT:

Snowy Valleys Council

PROJECT NAME:

MULTIPURPOSE + EVACUATION CENTRE

for DA

PROJECT ADDRESS:
RICHMOND PARK, TUMUT NSW
Lot 1 Section 81 DP 759004 and
Lot 701 DP 1059193.

DRAWING TITLE:

FLOOR PLAN

SHEET ISSUE DATE: 28.02.2025

REVISION DATE:

SCALE: 1:200 @ A1

JOB NO.: W366

DRAWN BY: AT

CHECKED BY: S. JOHANSSON

COPYRIGHT FACILITY DESIGN GROUP PTY. LIMITED. ALL RIGHTS RESERVED. DO NOT SCALE OFF DRAWINGS. WORK TO FIGURED DIMENSIONS ONLY. VERIFY DIMENSIONS ON SITE PRIOR TO COMMENCING WORK.

NOMINATED ARCHITECT: STEPHEN JOHANSSON - NSW REG NO. 7168

8/03/2025 12:12:46 PM



1 ROOF PLAN
1:200

CONTRACTORS MUST VERIFY ALL DIMENSIONS ON SITE BEFORE COMMENCING ANY WORK OR PREPARING SHOP DRAWINGS

All Architectural drawing sheets to be cross-referenced with other relevant disciplines.

Rev	Description	Date
-----	-------------	------

CONSULTANT 4:

50

1973

2023

WEBB

WEBB AUSTRALIA GROUP (NSW) PTY LTD

LEVEL 2 17 BOLTON STREET
NEWCASTLE NSW 2300 AUSTRALIA
T +61 2 4929 3225 | M +61 478 412 035
MECHANICAL ENGINEERING

CONSULTANT 3:

GLENN HAIG

8 PARTNERS

Coffs Harbour
P. 02 6658 2444 P. 02 9310 1952
PO Box 192 PO Box 489
SAWTELL, NSW, 2452 SURRY HILLS, NSW, 2010
HYDRAULIC + FIRE CONSULTANTS office@glennhaig.com.au

CONSULTANT 2:

SPECTRUM

ENGINEERING SOLUTIONS

1 Davis Place
Glenhaven NSW 2156
Phone: (02) 8850 6802
Mobile: 0419 294 533
Email: nat@spectrumsolutions.com.au

CONSULTANT 1:

PM DESIGN GROUP

Engineering Solutions

50 Gheringhap Street
Geelong, Victoria, Australia 3320
Ph: 03 5249 4800
e: admin@pmdesign.com.au
STRUCTURAL + CIVIL ENGINEERING

DESIGN ARCHITECT:

FACILITY DESIGN GROUP

Architecture & Construction

NSW Reg. No. 7168
ABN: 75 063 999 424
e: info@fdg.com.au
w: www.fdg.com.au
p: 02 4446 0777
p: PO Box 62
Camberwell NSW 2540
AQUATIC ■ SPORTS ■ LEISURE ■ CIVIC ■ PROJECT MANAGEMENT

CLIENT:

Snowy Valleys Council

PROJECT NAME:

MULTIPURPOSE + EVACUATION CENTRE

for DA

PROJECT ADDRESS:
RICHMOND PARK, TUMUT NSW
Lot 1 Section 81 DP 759004 and
Lot 701 DP 1059193.

DRAWING TITLE:

ROOF PLAN

SHEET ISSUE DATE: 28.02.2025

REVISION DATE:

SCALE: 1:200 @ A1

JOB NO.: W366

DRAWING NO.

REV.

A.101

DRAWN BY: AT

CHECKED BY: S. JOHANSSON


COPYRIGHT FACILITY DESIGN GROUP PTY. LIMITED. ALL RIGHTS RESERVED. DO NOT SCALE OFF DRAWINGS. WORK TO FIGURED DIMENSIONS ONLY. VERIFY DIMENSIONS ON SITE PRIOR TO COMMENCING WORK.

NOMINATED ARCHITECT: STEPHEN JOHANSSON - NSW REG No. 7168

DRAWN BY: AT CHECKED BY: S. JOHANSSON

NOMINATED ARCHITECT: STEPHEN JOHANSSON - NSW REG No. 7168

03/2025 12:13:04 PM

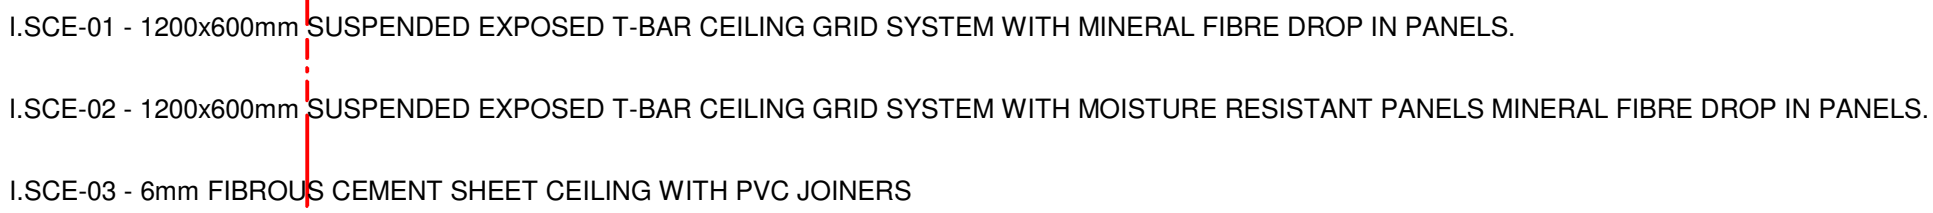

1 : 200



 LEVEL 2 17 BOLTON STREET
 NEWCASTLE NSW 2300 AUSTRALIA
 T +61 2 4929 5225 | M +61 478 412 035
 MECHANICAL ENGINEERING

CONSULTANT 3:

 **GLENN HAIG
& PARTNERS**

HYDRAULIC + FIRE CONSULTANTS

Coffs Harbour

P. 02 6658 2444
PO Box 192
SAWTELL, NSW, 2452

P. 02 9310 1352
PO Box 689
SURREY HILLS, NSW, 2010

office@glennhaig.com.au

CONSULTANT 2:



SPECTRUM
ENGINEERING SOLUTIONS

1 Davis Place
Glenhaven NSW 2156

Phone: (02) 8850 6802
Mobile: 0419 294 533
Email: nat@specengsolutions.com.au

CONSULTANT 1:

PM DESIGN GROUP
50 Gheringhoo Street
Geelong, Victoria, Australia 3320
PH: 03 5249 4800
e: admin@pmdesign.com.au

PM DESIGN GROUP
Engineering Solutions
STRUCTURAL + CIVIL ENGINEERING

DESIGN ARCHITECT:

 **FACILITY
DESIGN GROUP**
Architecture & Construction

NSW Reg. No. 7168
ABN 75 083 999 624
e: info@fdg.com.au
w: www.fdg.com.au
p: 02 4446 0777
PO Box 62,
Camden NSW 2540

AQUATIC ■ SPORTS ■ LEISURE ■ CIVIC ■ PROJECT MANAGEMENT

CLIENT:  Snowy Valleys Council

PROJECT NAME:
**MULTIPURPOSE + EVACUATION
CENTRE**

for DA
PROJECT ADDRESS:
RICHMOND PARK, TUMUT NSW
Lot 1 Section 81 DP 759004 and
Lot 701 DP 1059193.

DRAWING TITLE:

REFLECTED CEILING PLAN

A1 PRINT SIZE

HEET ISSUE DATE: 28.02.2025	DRAWING NO.	REV.
-----------------------------	-------------	------

SCALE: 1:200 @ A1	A.300
JOB NO.: W366	

DRAWN BY: AT CHECKED BY: S. JOHANSSON




COPYRIGHT FACILITY DESIGN GROUP PTY. LIMITED. ALL RIGHTS RESERVED. DO NOT SCALE OFF DRAWINGS. WORK TO FIGURED DIMENSIONS ONLY. VERIFY DIMENSIONS ON SITE PRIOR TO COMMENCING WORK.

NOMINATED ARCHITECT: STEPHEN JOHANSSON - NSW REG No. 7168

CONTRACTORS MUST VERIFY ALL DIMENSIONS ON SITE BEFORE COMMENCING ANY WORK OR PREPARING SHOP DRAWINGS

All Architectural drawing sheets to be cross-referenced with other relevant disciplines.

Rev	Description	Date
-----	-------------	------

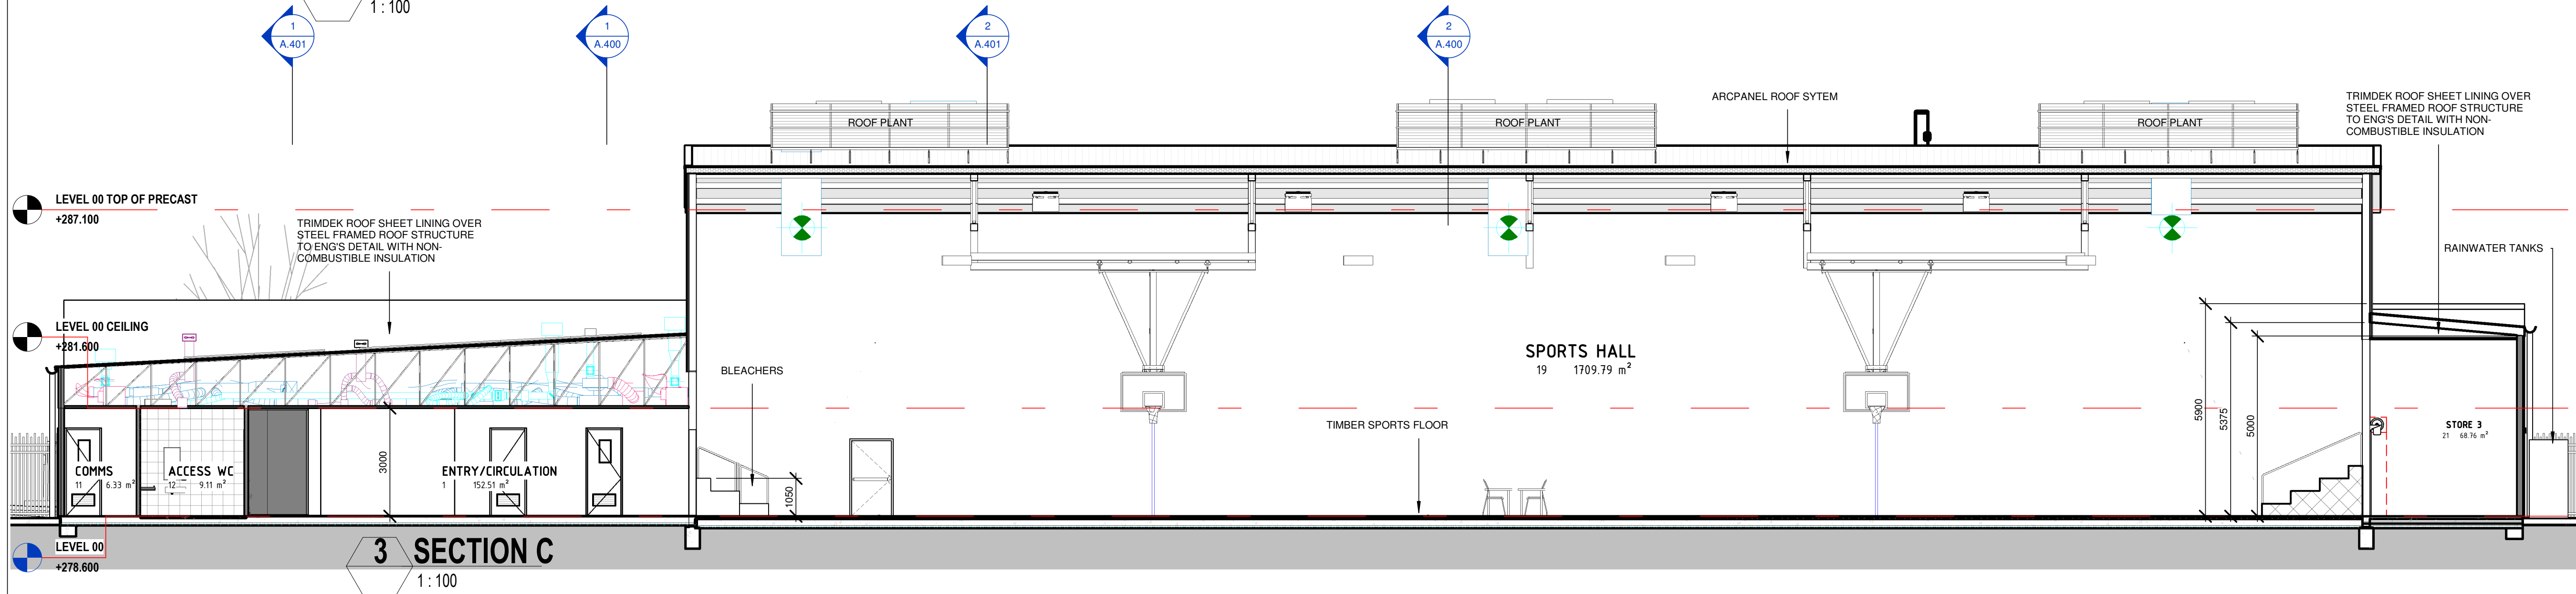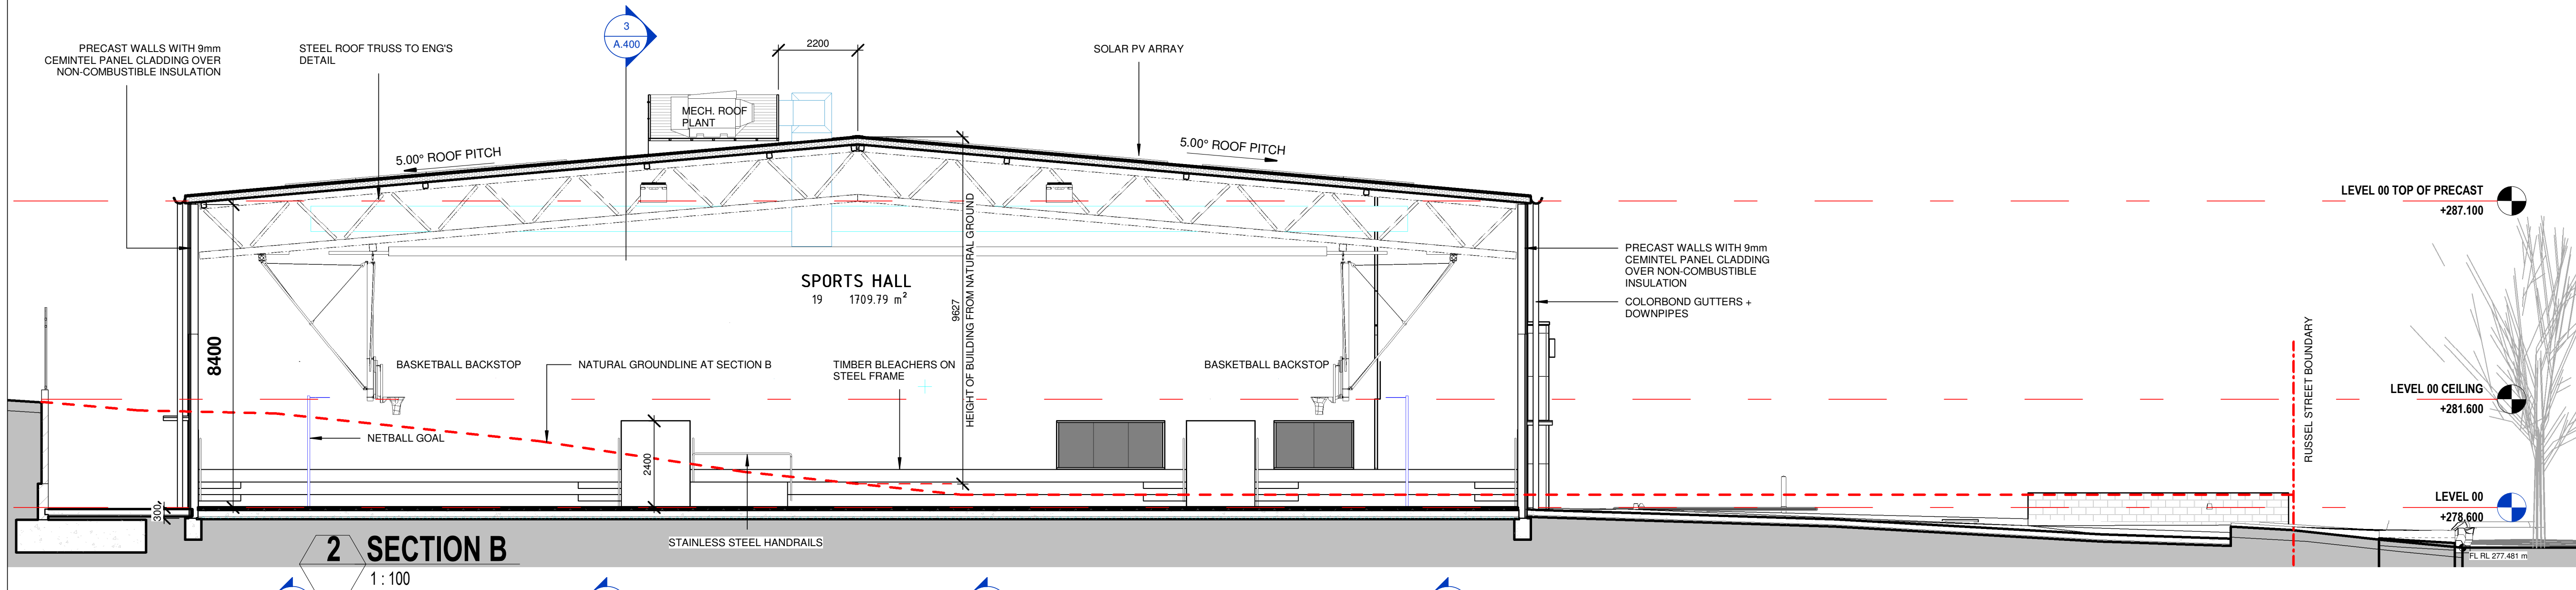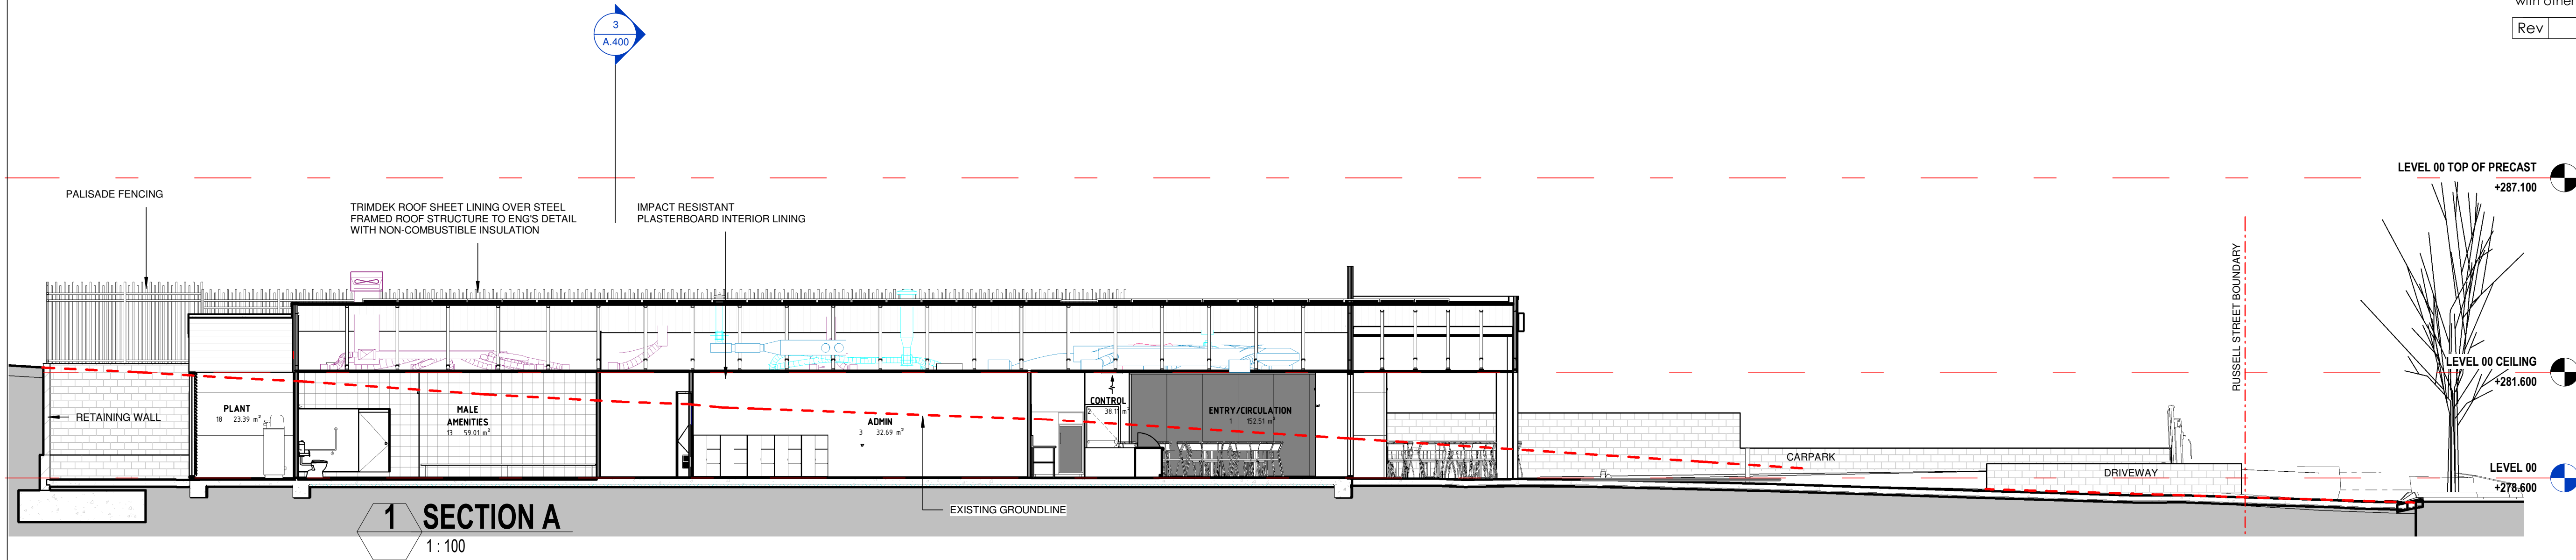

CONSULTANT 4:
WEBB AUSTRALIA GROUP (NSW) PTY LTD
LEVEL 2 17 BOLTON STREET
NEWCASTLE NSW 2300 AUSTRALIA
T +61 2 4929 3225 | M +61 478 412 035
MECHANICAL ENGINEERING

CONSULTANT 3:
GLENN HAIG & PARTNERS
Coffs Harbour
P. 02 6658 2444 P. 02 9310 1952
PO Box 192 PO Box 489
SAWTELL, NSW, 2452 SURRY HILLS, NSW, 2019
HYDRAULIC + FIRE CONSULTANTS office@glennhaig.com.au

CONSULTANT 2:
SPECTRUM
ENGINEERING SOLUTIONS
1 Davis Place
Glenhaven NSW 2156
Phone: (02) 8850 6802
Mobile: 0419 294 533
Email: info@spectrumengineering.com.au

CONSULTANT 1:
PM DESIGN GROUP
50 Glenelgh Street
Geelong, Victoria, Australia 3320
PH: 03 5249 4800
e: admin@pmdesign.com.au
STRUCTURAL + CIVIL ENGINEERING

DESIGN ARCHITECT:
FACILITY DESIGN GROUP
Architecture & Construction
AQUATIC ■ SPORTS ■ LEISURE ■ CIVIC ■ PROJECT MANAGEMENT
NSW Reg. No. 7168
ABN: 75 083 999 424
e: info@fdg.com.au
w: www.fdg.com.au
p: 02 4446 0777
PO Box 62
Camberwell NSW 3184

CLIENT:
Snowy Valleys Council

PROJECT NAME:
MULTIPURPOSE + EVACUATION CENTRE
for DA
PROJECT ADDRESS:
RICHMOND PARK, TUMUT NSW
Lot 1 Section 81 DP 759004 and
Lot 701 DP 1059193.


DRAWING TITLE:

SECTIONS 1

SHEET ISSUE DATE: 28.02.2025		DRAWING NO. REV.	
REVISION DATE:		A.400	
SCALE: 1:100 @ A1		JOB NO.: W366	
DRAWN BY: AT		CHECKED BY: S. JOHANSSON	

COPYRIGHT FACILITY DESIGN GROUP PTY. LIMITED. ALL RIGHTS RESERVED. DO NOT SCALE OFF DRAWINGS. WORK TO FIGURED DIMENSIONS ONLY. VERIFY DIMENSIONS ON SITE PRIOR TO COMMENCING WORK.

 
NOMINATED ARCHITECT: STEPHEN JOHANSSON - NSW REG No. 7168
5/03/2025 12:13:48 PM




CONTRACTORS MUST VERIFY ALL DIMENSIONS ON SITE BEFORE COMMENCING ANY WORK OR PREPARING SHOP DRAWINGS

All Architectural drawing sheets to be cross-referenced with other relevant disciplines.


Rev	Description	Date
-----	-------------	------

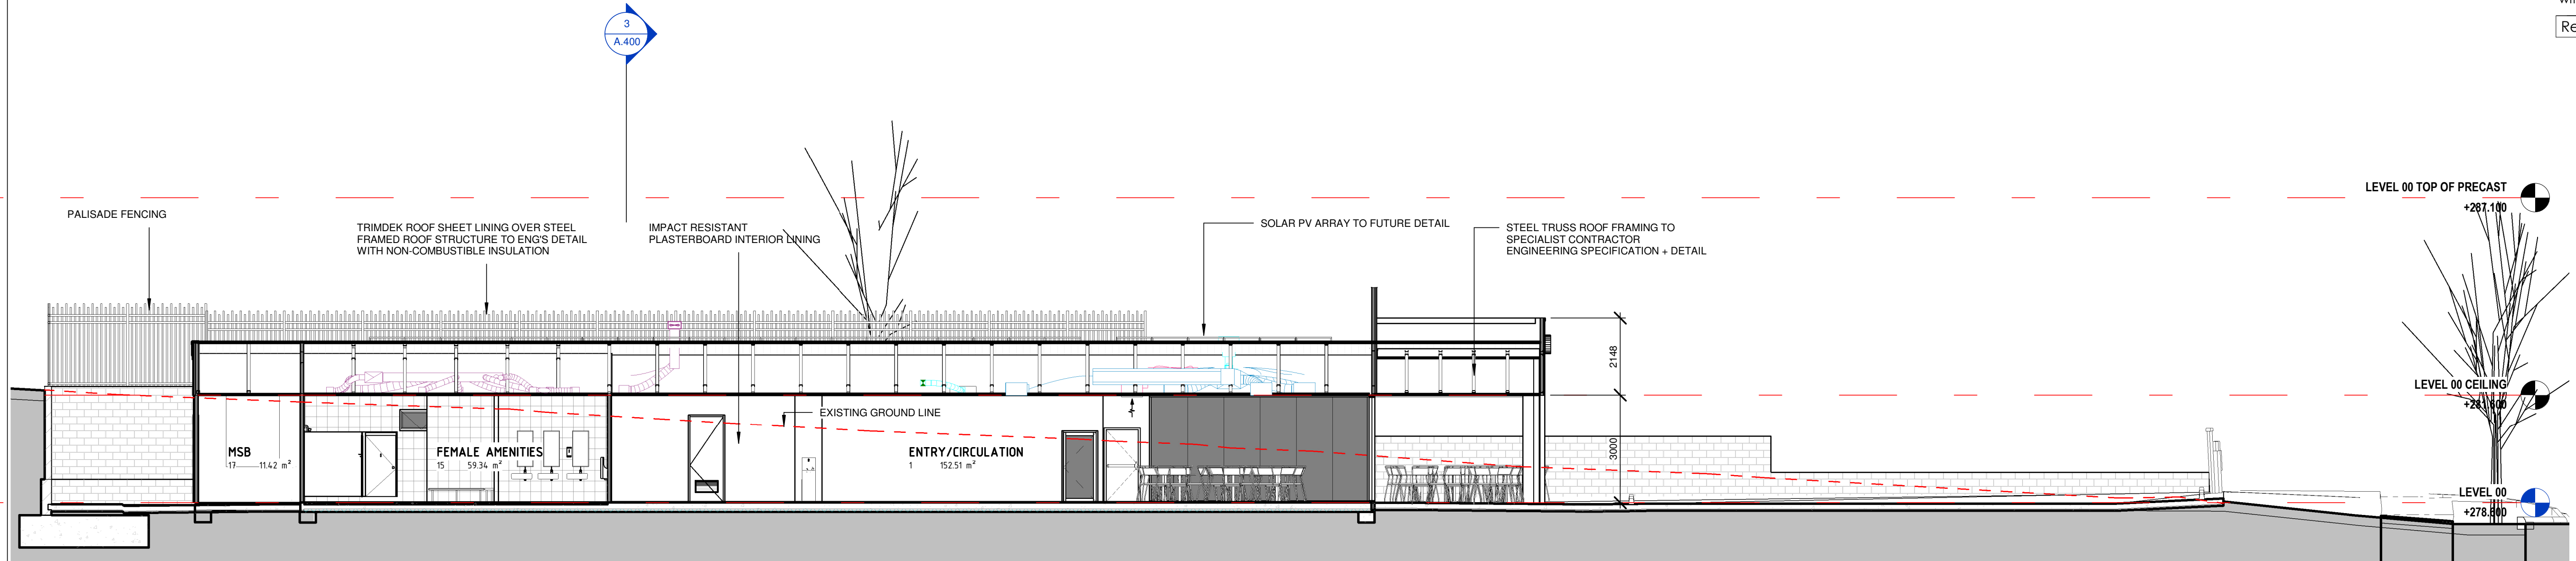

1 SECTION A1
1:100

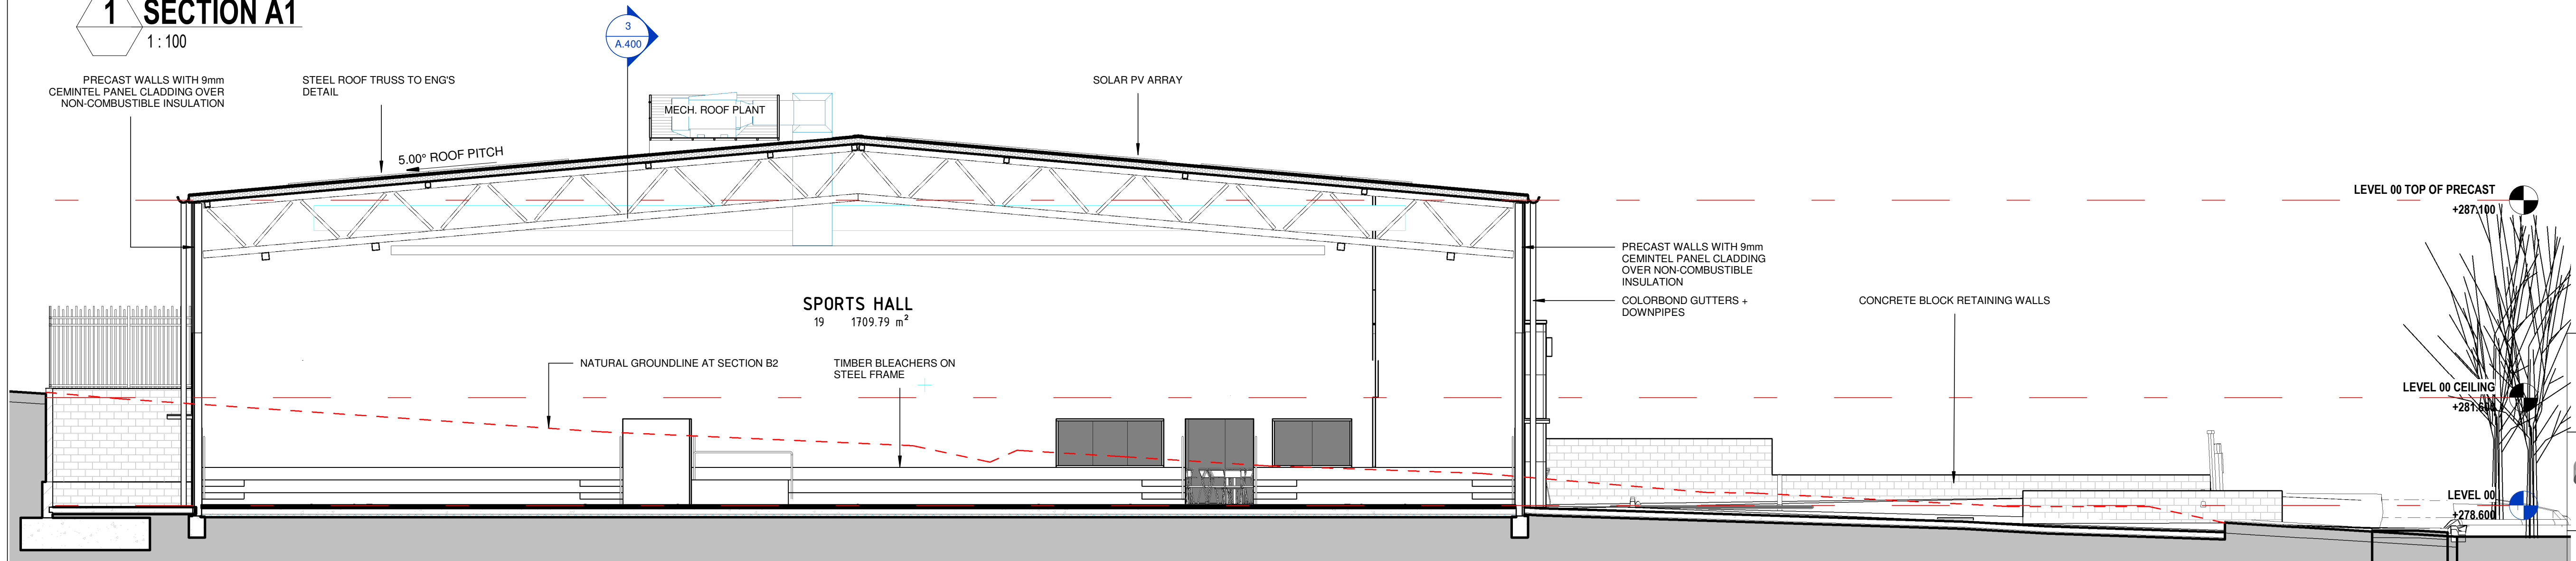

2 SECTION B2
1:100

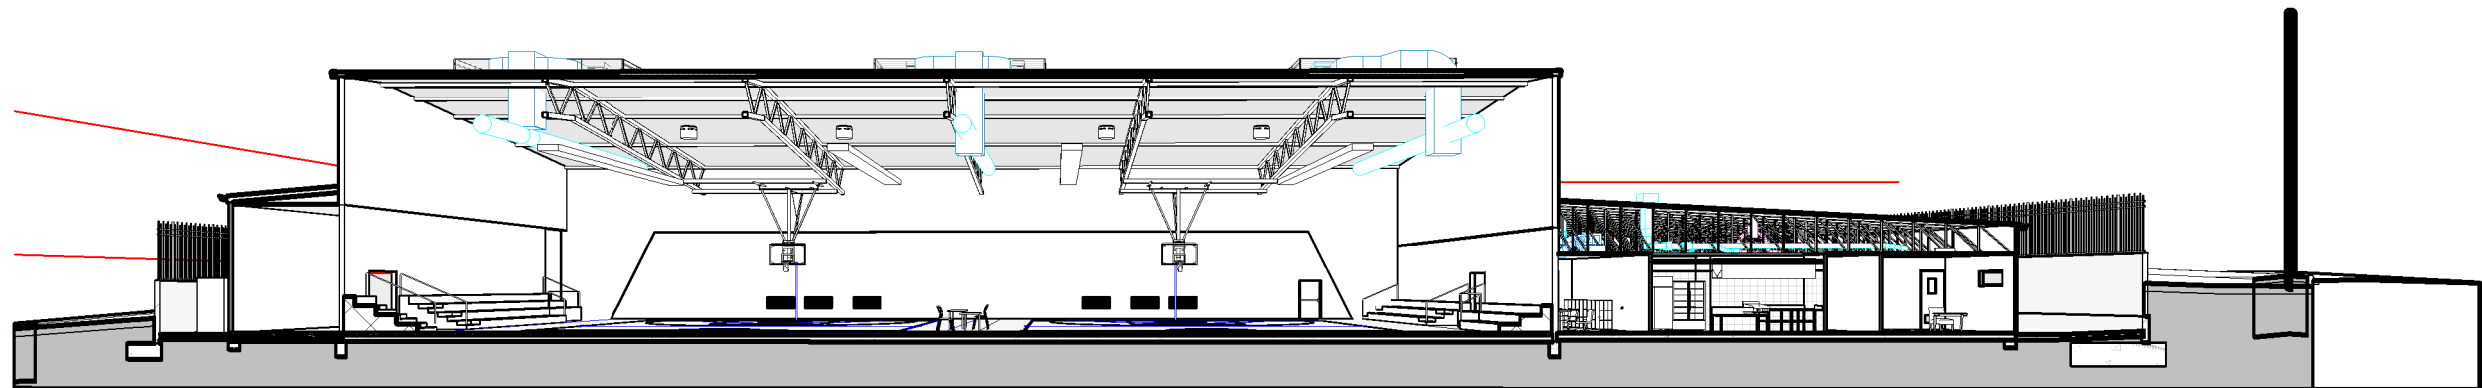

3 LONG SECTION PERSPECTIVE

CONSULTANT 4:
WEBB AUSTRALIA GROUP (NSW) PTY LTD
LEVEL 2 17 BOLTON STREET
NEWCASTLE NSW 2300 AUSTRALIA
T +61 2 4928 2225 | M +61 478 412 035
MECHANICAL ENGINEERING

CONSULTANT 3:
GLENN HAIG & PARTNERS
P. 02 6658 2444 P. 02 9310 1952
PO Box 192 PO Box 489
SAWTELL NSW, 2452 SURRY HILLS, NSW, 2019
HYDRAULIC + FIRE CONSULTANTS office@glennhaig.com.au

CONSULTANT 2:
SPECTRUM
1 Davis Place
Glenhaven NSW 2156
ENGINEERING SOLUTIONS
Phone: (02) 8850 6802
Mobile: 0419 294 533
Email: info@spectrumengineering.com.au

CONSULTANT 1:
PM DESIGN GROUP
50 Gheringhap Street
Geelong, Victoria, Australia 3320
PH: 03 5249 4800
e: admin@pmdesign.com.au
STRUCTURAL + CIVIL ENGINEERING

DESIGN ARCHITECT:
FACILITY DESIGN GROUP
Architecture & Construction
AQUATIC ■ SPORTS ■ LEISURE ■ CIVIC ■ PROJECT MANAGEMENT
NSW Reg. No. 7168
ABN: 75 063 999 424
info@fdg.com.au
www.fdg.com.au
p: 02 4446 0777
PO Box 62
Camberwell NSW 2540

CLIENT:
Snowy Valleys Council

PROJECT NAME:
MULTIPURPOSE + EVACUATION CENTRE
for DA
PROJECT ADDRESS:
RICHMOND PARK, TUMUT NSW
Lot 1 Section 81 DP 759004 and
Lot 701 DP 1059193.

DRAWING TITLE:
SECTIONS 2

SHEET ISSUE DATE: 28.02.2025		DRAWING NO. REV.	
REVISION DATE:		A.401	
SCALE: 1:100 @ A1			
JOB NO.: W366			


DRAWN BY: AT CHECKED BY: S. JOHANSSON

COPYRIGHT FACILITY DESIGN GROUP PTY. LIMITED. ALL RIGHTS RESERVED. DO NOT SCALE OFF DRAWINGS. WORK TO FIGURED DIMENSIONS ONLY. VERIFY DIMENSIONS ON SITE PRIOR TO COMMENCING WORK.


NOMINATED ARCHITECT: STEPHEN JOHANSSON - NSW REG No. 7168

5/03/2025 12:14:04 PM


0 1 2 3 4 5 10
SCALE BAR 1:100

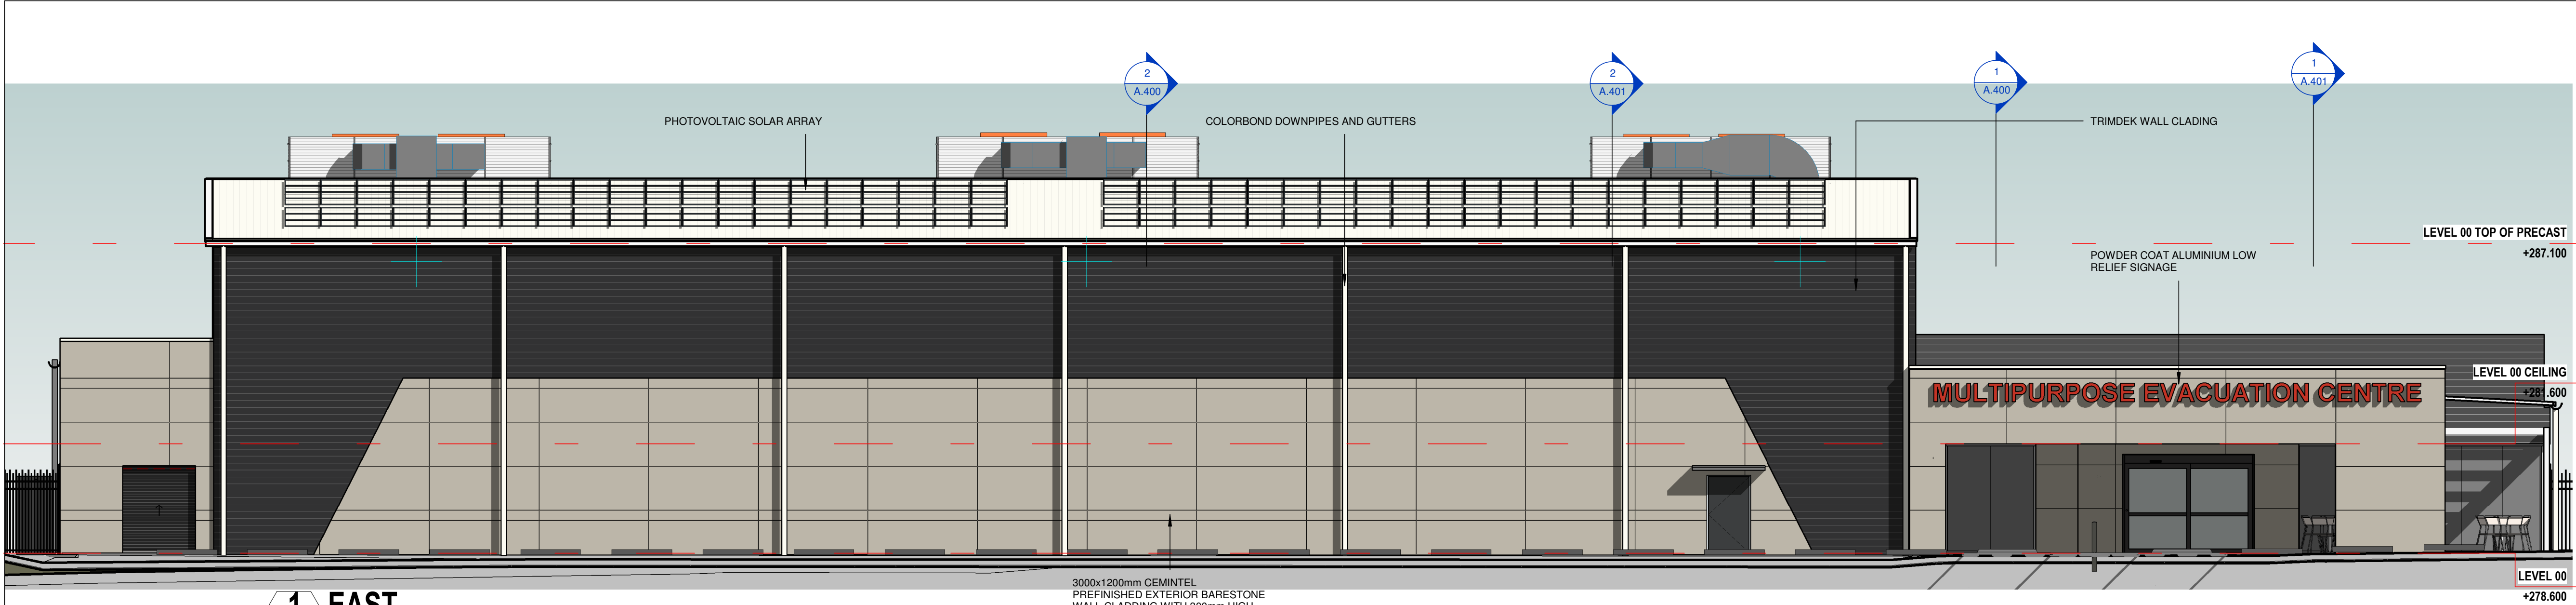

1 EAST
1:100

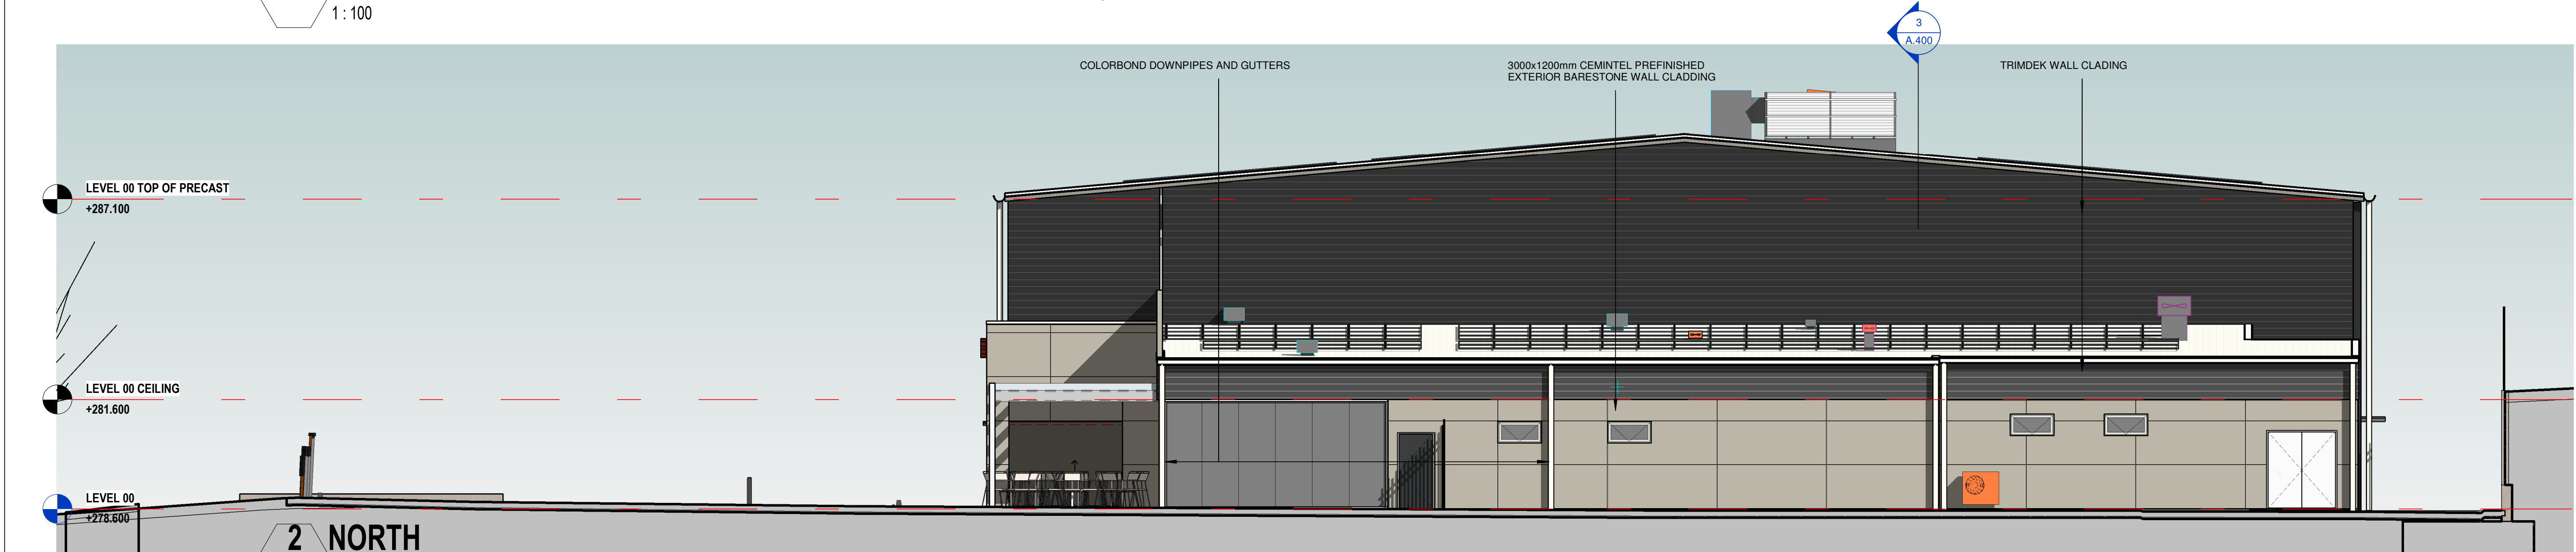

2 NORTH
1:100

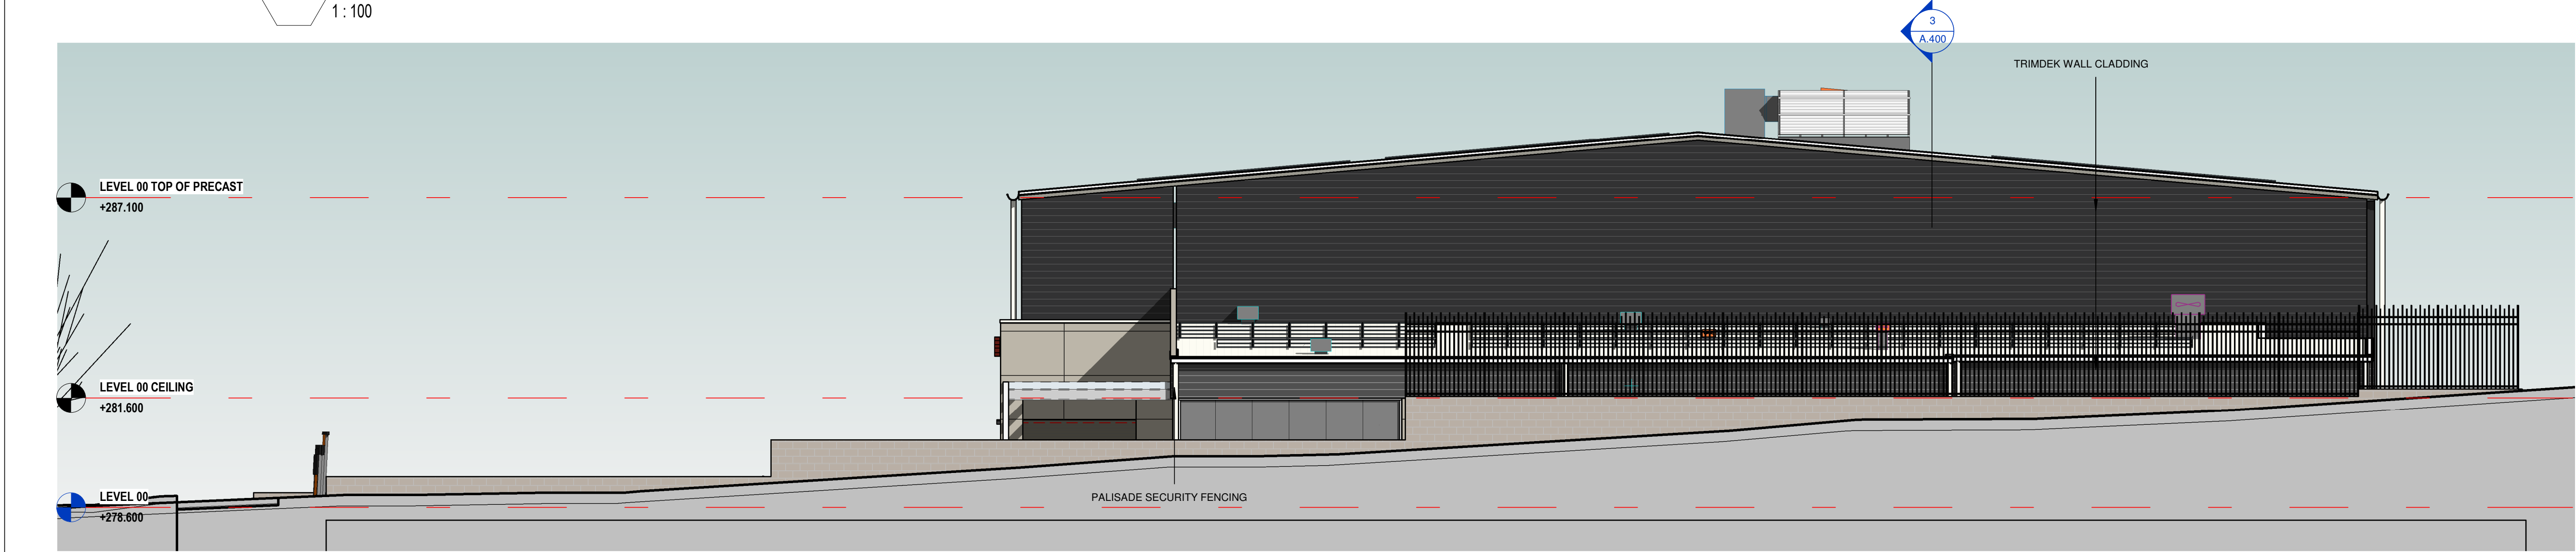

3 NORTH - RICHMOND STREETSCAPE
1:100

CONTRACTORS MUST VERIFY ALL DIMENSIONS ON SITE BEFORE COMMENCING ANY WORK OR PREPARING SHOP DRAWINGS

All Architectural drawing sheets to be cross-referenced with other relevant disciplines.

Rev	Description	Date
-----	-------------	------

CONSULTANT 4:

WEBB AUSTRALIA GROUP (NSW) PTY LTD
LEVEL 2 17 BOLTON STREET
NEWCASTLE NSW 2300 AUSTRALIA
T +61 2 4929 3225 | M +61 478 412 035
MECHANICAL ENGINEERING

CONSULTANT 3:

GLENN HAIG & PARTNERS
P. 02 6658 2444 P. 02 9310 1352
PO Box 192 PO Box 489
SAWTELL, NSW, 2152 SURRY HILLS, NSW, 2010
HYDRAULIC + FIRE CONSULTANTS office@glennhaig.com.au

CONSULTANT 2:

SPECTRUM
ENGINEERING SOLUTIONS
1 Davis Place
Glenhaven NSW 2156
Phone: (02) 8850 6802
Mobile: 0419 294 533
Email: noli@spectrumengineering.com.au

CONSULTANT 1:

PM DESIGN GROUP
50 Gheringhap Street
Geelong, Victoria, Australia 3320
PH: 03 5249 4800
e: admin@pmdesign.com.au
STRUCTURAL + CIVIL ENGINEERING

DESIGN ARCHITECT:

FACILITY DESIGN GROUP
Architecture & Construction
AQUATIC ■ SPORTS ■ LEISURE ■ CIVIC ■ PROJECT MANAGEMENT
NSW Reg. No. 7168
ABN 75 063 999 424
e: info@fdg.com.au
w: www.fdg.com.au
p: 02 4446 0777
p: 02 4446 0777
PO Box 62
Camberwell NSW 3184

CLIENT:



PROJECT NAME:

MULTIPURPOSE + EVACUATION CENTRE

for DA

PROJECT ADDRESS:
RICHMOND PARK, TUMUT NSW
Lot 1 Section 81 DP 759004 and
Lot 701 DP 1059193.

DRAWING TITLE:

ELEVATIONS 1

SHEET ISSUE DATE: 28.02.2025		DRAWING NO. REV.	
REVISION DATE:		A.500	
SCALE: 1:100 @ A1			
JOB NO.: W366			

DRAWN BY: AT CHECKED BY: S. JOHANSSON

COPYRIGHT FACILITY DESIGN GROUP PTY. LIMITED. ALL RIGHTS RESERVED. DO NOT SCALE OFF DRAWINGS. WORK TO FIGURED DIMENSIONS ONLY. VERIFY DIMENSIONS ON SITE PRIOR TO COMMENCING WORK.

NOMINATED ARCHITECT: STEPHEN JOHANSSON - NSW REG No. 7168


5/03/2025 12:14:48 PM




CONTRACTORS MUST VERIFY ALL DIMENSIONS ON SITE BEFORE COMMENCING ANY WORK OR PREPARING SHOP DRAWINGS

All Architectural drawing sheets to be cross-referenced with other relevant disciplines.


Rev	Description	Date
-----	-------------	------

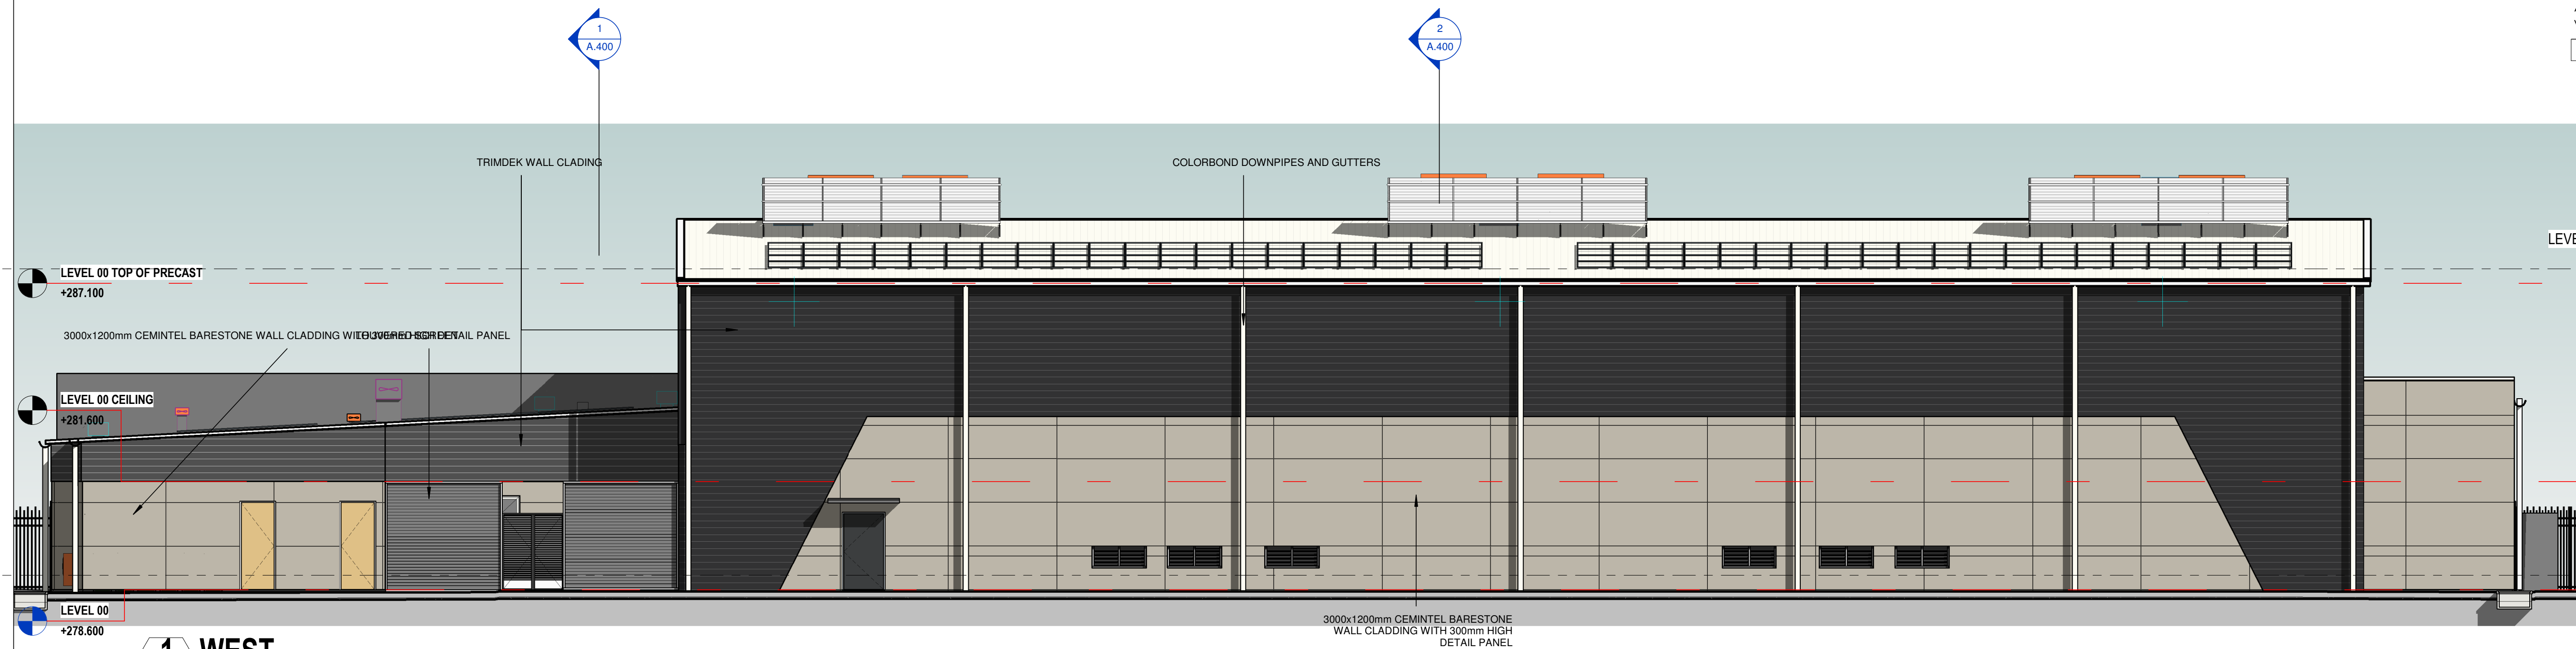

1 WEST
1:100

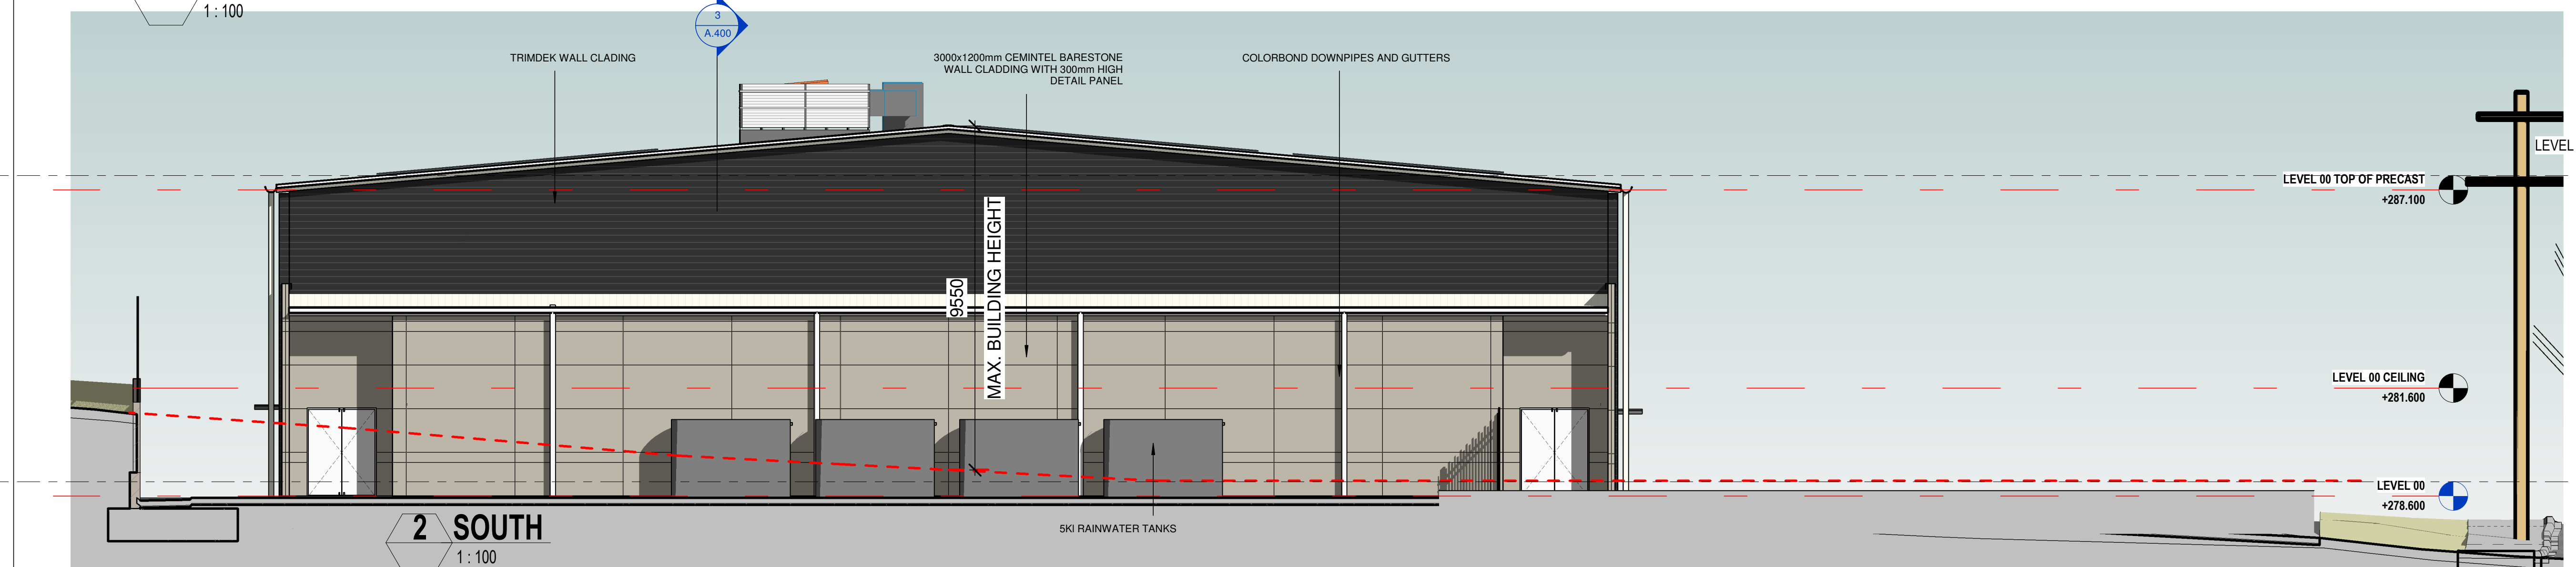

2 SOUTH
1:100

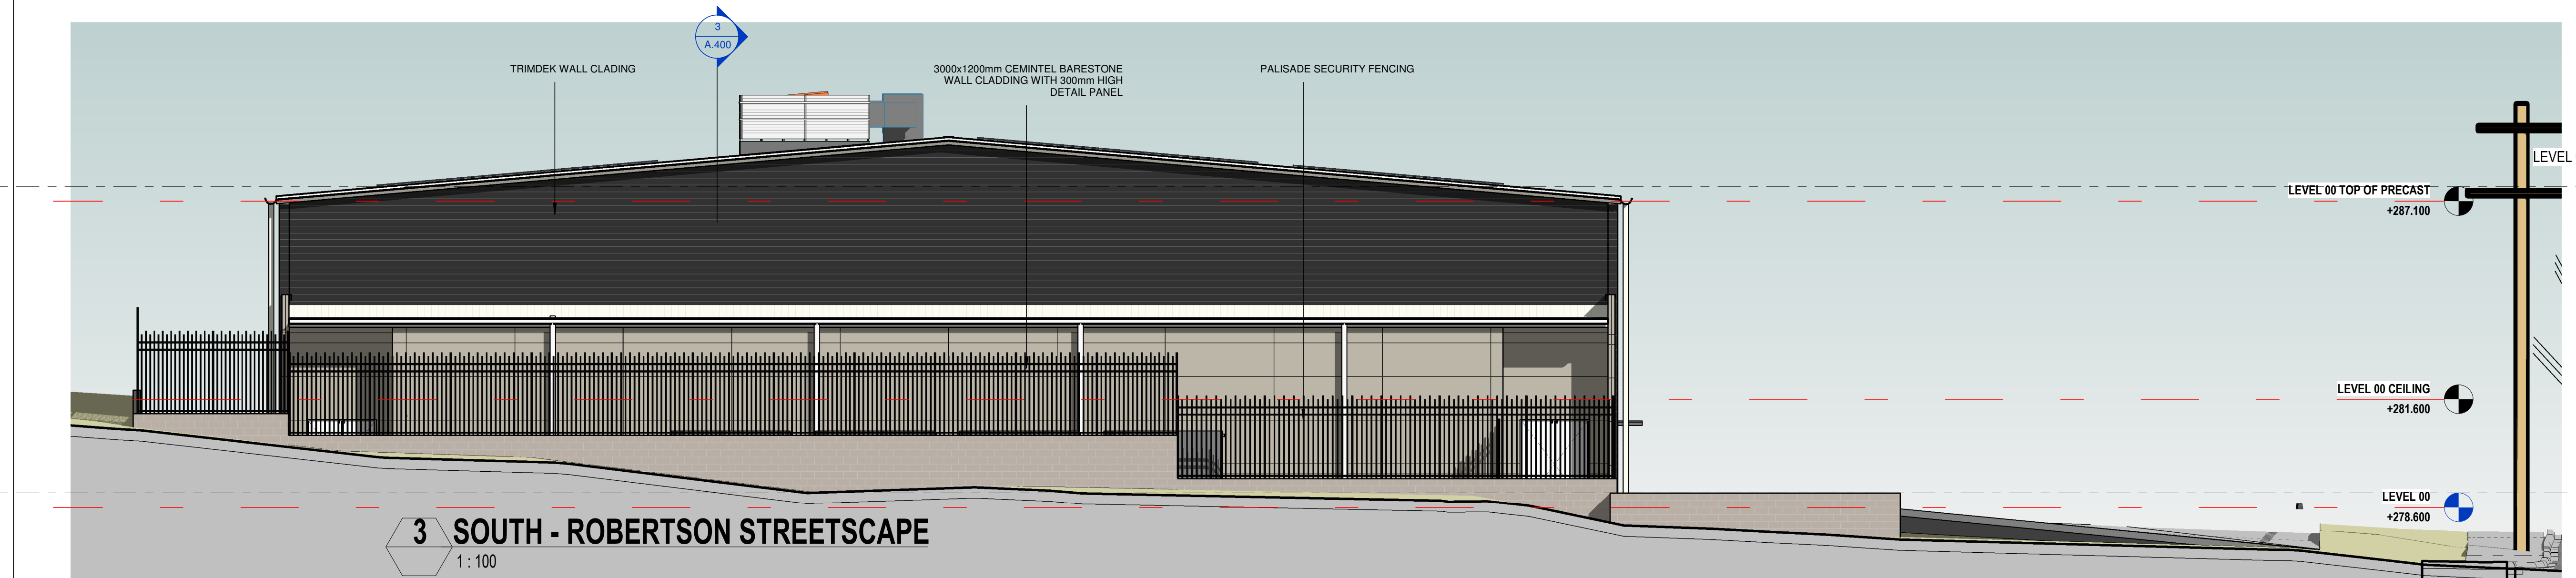

3 SOUTH - ROBERTSON STREETSCAPE
1:100

CONSULTANT 4:
WEBB AUSTRALIA GROUP (NSW) PTY LTD
LEVEL 2 17 BOLTON STREET
NEWCASTLE NSW 2300 AUSTRALIA
T +61 2 4929 3225 | M +61 478 412 035
MECHANICAL ENGINEERING

CONSULTANT 3:
GLENN HAIG & PARTNERS
P. 02 6558 2444 P. 02 9310 1352
PO Box 192 PO Box 489
SAYRELL NSW, 2452 SURRY HILLS, NSW, 2010
HYDRAULIC + FIRE CONSULTANTS office@glennhaig.com.au

CONSULTANT 2:
SPECTRUM
ENGINEERING SOLUTIONS
1 Davis Place
Glenhaven NSW 2156
Phone: (02) 8850 6802
Mobile: 0419 294 533
Email: info@spectrumengineering.com.au

CONSULTANT 1:
PM DESIGN GROUP
50 Glenelg Street
Geelong, Victoria, Australia 3320
PH: 03 5249 4800
e: admin@pmdesign.com.au
STRUCTURAL + CIVIL ENGINEERING

DESIGN ARCHITECT:
FACILITY DESIGN GROUP
Architecture & Construction
AQUATIC ■ SPORTS ■ LEISURE ■ CIVIC ■ PROJECT MANAGEMENT
NSW Reg. No. 7168
ABN 75 063 999 424
info@fdg.com.au
www.fdg.com.au
p: 02 4446 0777
PO Box 62
Camden NSW 2580

Snowy Valleys Council

PROJECT NAME:
MULTIPURPOSE + EVACUATION CENTRE
for DA
PROJECT ADDRESS:
RICHMOND PARK, TUMUT NSW
Lot 1 Section 81 DP 759004 and
Lot 701 DP 1059193.

DRAWING TITLE:
ELEVATIONS 2


SHEET ISSUE DATE: 28.02.2025
REVISION DATE:

SCALE: 1:100 @ A1
JOB NO.: W366







DRAWN BY: AT
CHECKED BY: S. JOHANSSON

COPYRIGHT FACILITY DESIGN GROUP PTY. LIMITED. ALL RIGHTS RESERVED. DO NOT SCALE OFF DRAWINGS. WORK TO FIGURED DIMENSIONS ONLY. VERIFY DIMENSIONS ON SITE PRIOR TO COMMENCING WORK.
NOMINATED ARCHITECT: STEPHEN JOHANSSON - NSW REG NO. 7168
5/03/2025 12:15:18 PM

SCALE BAR 1:100

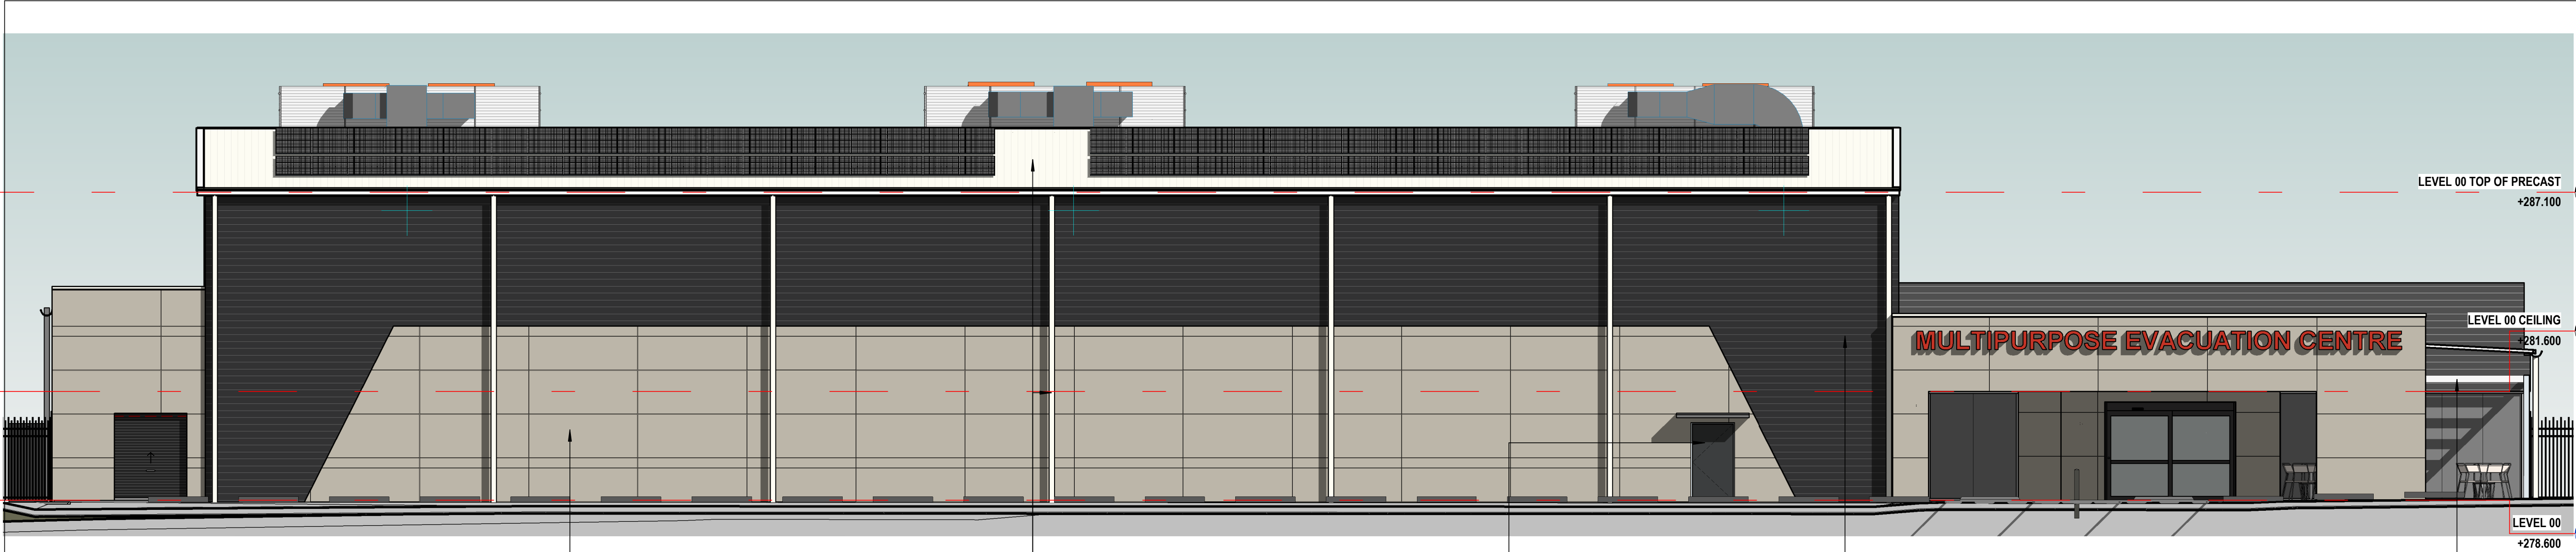

1 EAST - COLOURS
1:100

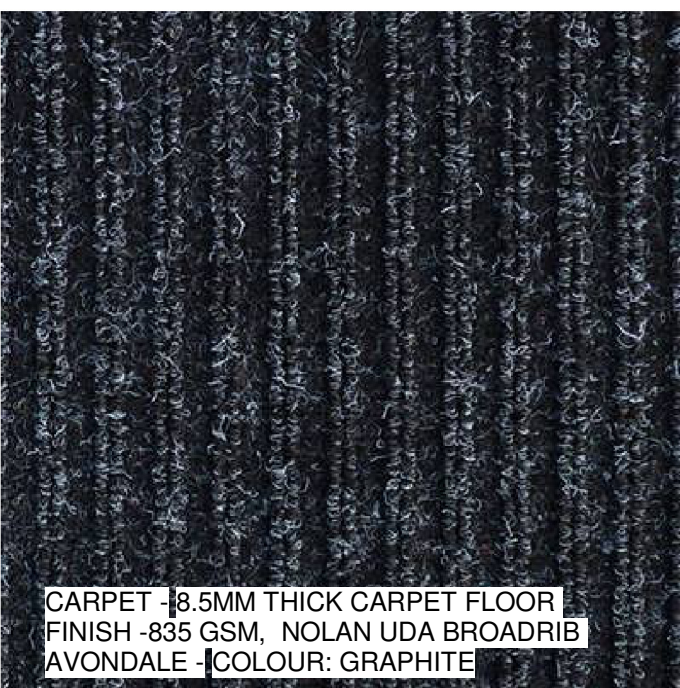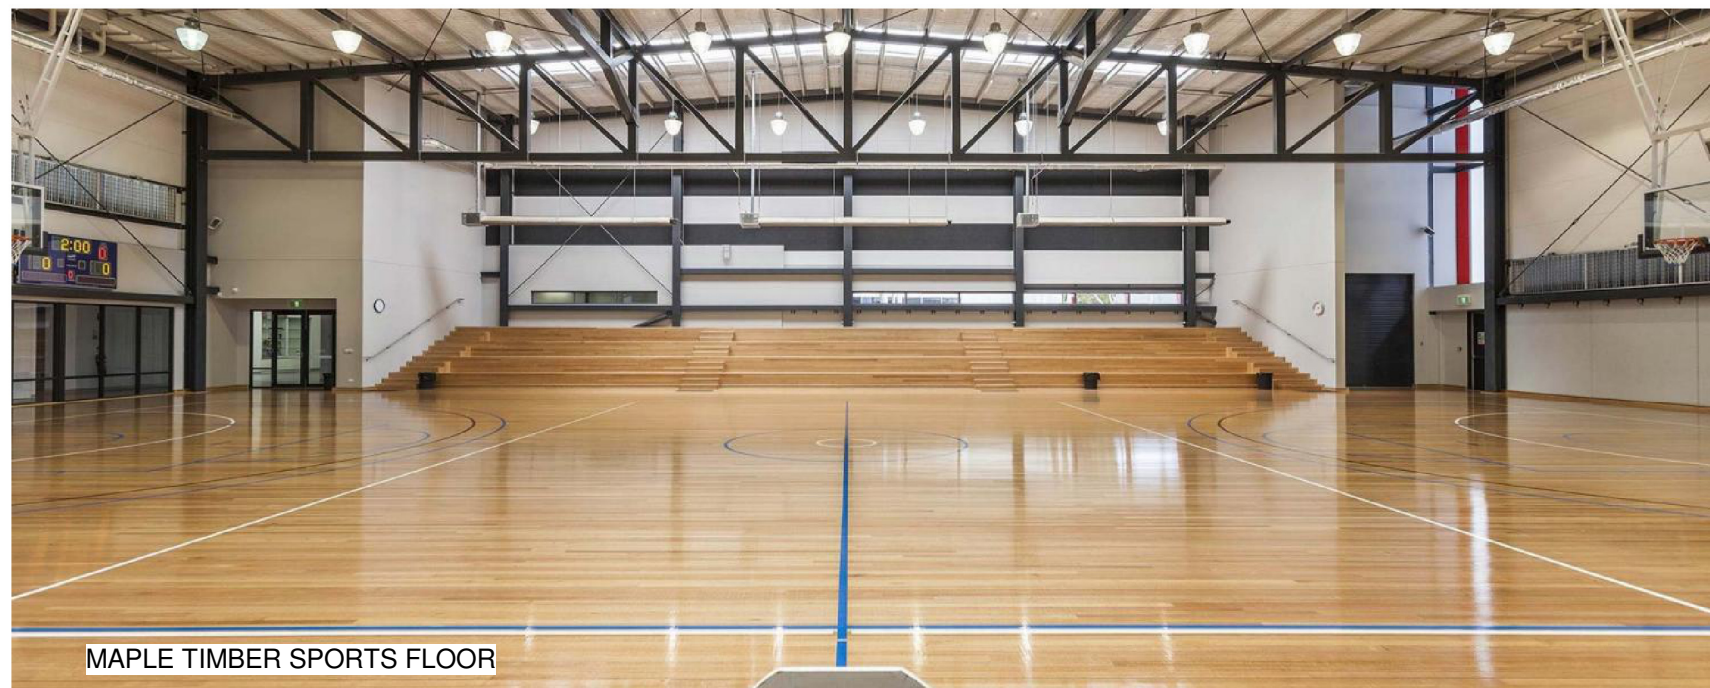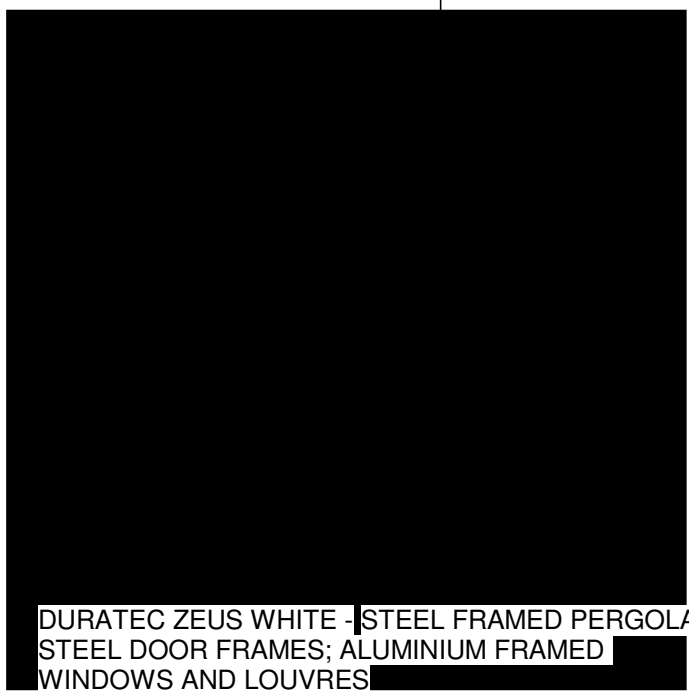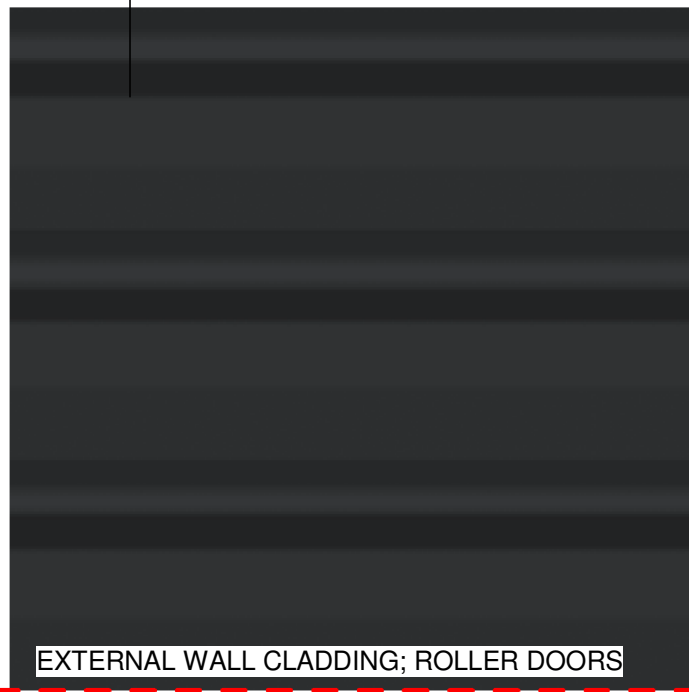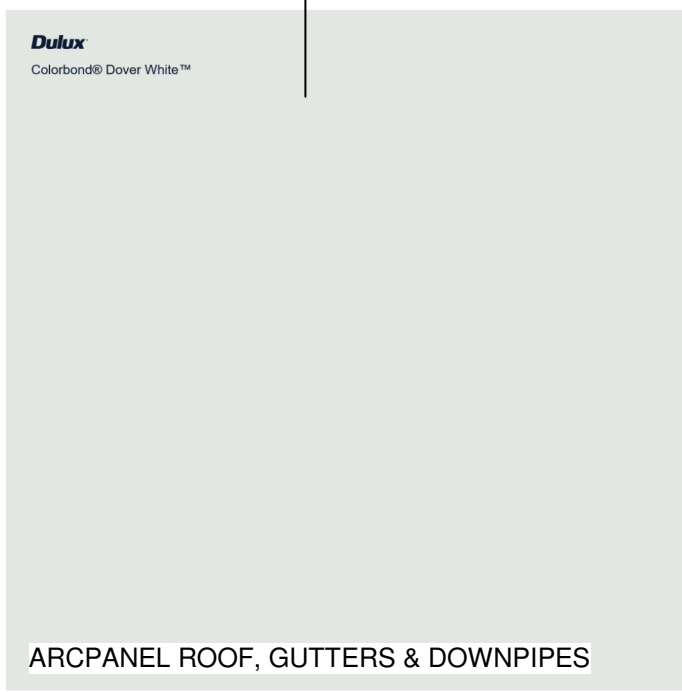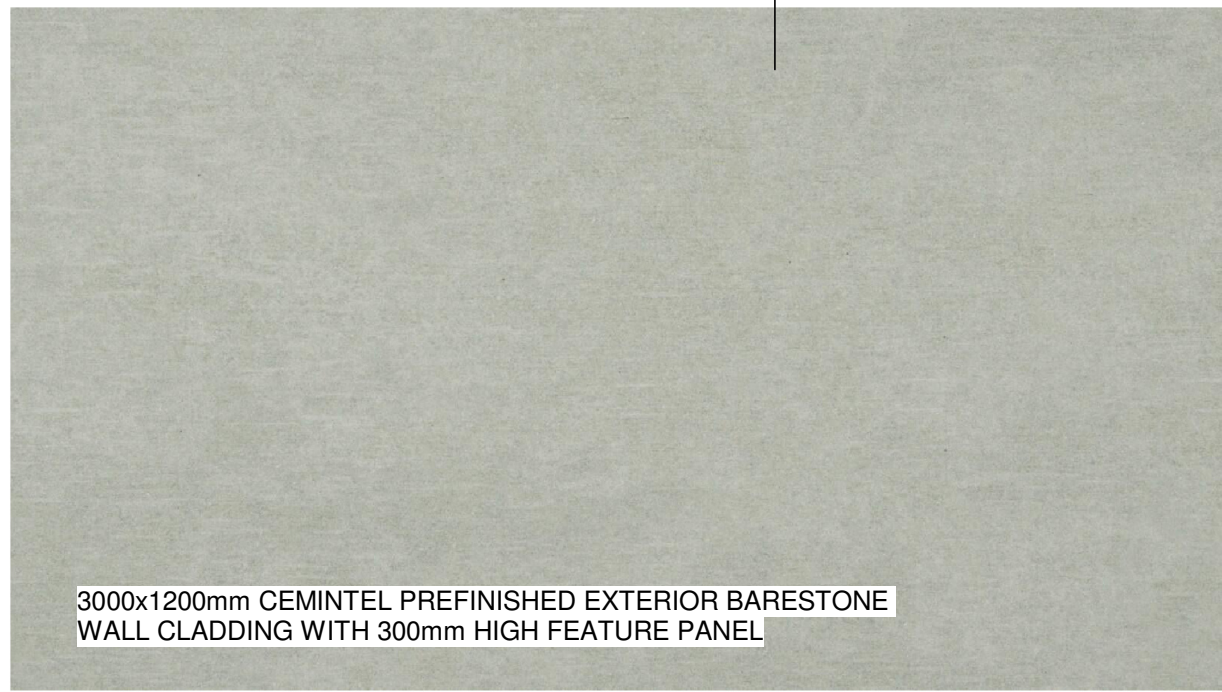

CONTRACTORS MUST VERIFY ALL DIMENSIONS ON SITE BEFORE COMMENCING ANY WORK OR PREPARING SHOP DRAWINGS

All Architectural drawing sheets to be cross-referenced with other relevant disciplines.

Rev	Description	Date
-----	-------------	------

CONSULTANT 4:

WEBB AUSTRALIA GROUP (NSW) PTY LTD
LEVEL 2 17 BOLTON STREET
NEWCASTLE NSW 2300 AUSTRALIA
T +61 2 4929 3225 | M +61 478 412 035
MECHANICAL ENGINEERING

GLENN HAIG & PARTNERS
Coffs Harbour
P. 02 6658 2444 P. 02 9310 1352
PO Box 192 PO Box 489
SAWTELL, NSW, 2452 SURRY HILLS, NSW, 2010
HYDRAULIC + FIRE CONSULTANTS office@glennhaig.com.au

SPECTRUM
ENGINEERING SOLUTIONS
1 Davis Place
Glenhaven NSW 2156
Phone: (02) 8850 6802
Mobile: 0419 294 533
Email: info@spectrumengineering.com.au

PM DESIGN GROUP
Engineering Solutions
STRUCTURAL + CIVIL ENGINEERING
50 Gheringhap Street
Geelong, Victoria, Australia 3320
PH: 03 5249 4800
e: admin@pmdesign.com.au

FACILITY DESIGN GROUP
Architecture & Construction
AQUATIC ■ SPORTS ■ LEISURE ■ CIVIC ■ PROJECT MANAGEMENT
NSW Reg. No. 7168
ABN 75 083 999 424
info@fdg.com.au
www.fdg.com.au
02 4446 0777
PO Box 62
Camberwell NSW 2540

Snowy Valleys Council

PROJECT NAME:
MULTIPURPOSE + EVACUATION CENTRE
for DA
PROJECT ADDRESS:
RICHMOND PARK, TUMUT NSW
Lot 1 Section 81 DP 759004 and
Lot 701 DP 1059193.

DRAWING TITLE:
COLOURBOARD

SHEET ISSUE DATE: 28.02.2025	DRAWING NO. REV.	A.800
REVISION DATE:		
SCALE: 1:100 @ A1		
JOB NO.: W366		

DRAWN BY: Author CHECKED BY: S. JOHANSSON

COPYRIGHT FACILITY DESIGN GROUP PTY. LIMITED. ALL RIGHTS RESERVED. DO NOT SCALE OFF DRAWINGS. WORK TO FIGURED DIMENSIONS ONLY. VERIFY DIMENSIONS ON SITE PRIOR TO COMMENCING WORK.


NOMINATED ARCHITECT: STEPHEN JOHANSSON - NSW REG No. 7168

5/03/2025 12:16:47 PM

CONTRACTORS MUST VERIFY ALL DIMENSIONS ON SITE BEFORE COMMENCING ANY WORK OR PREPARING SHOP DRAWINGS

All Architectural drawing sheets to be cross-referenced with other relevant disciplines.

Rev	Description	Date
-----	-------------	------

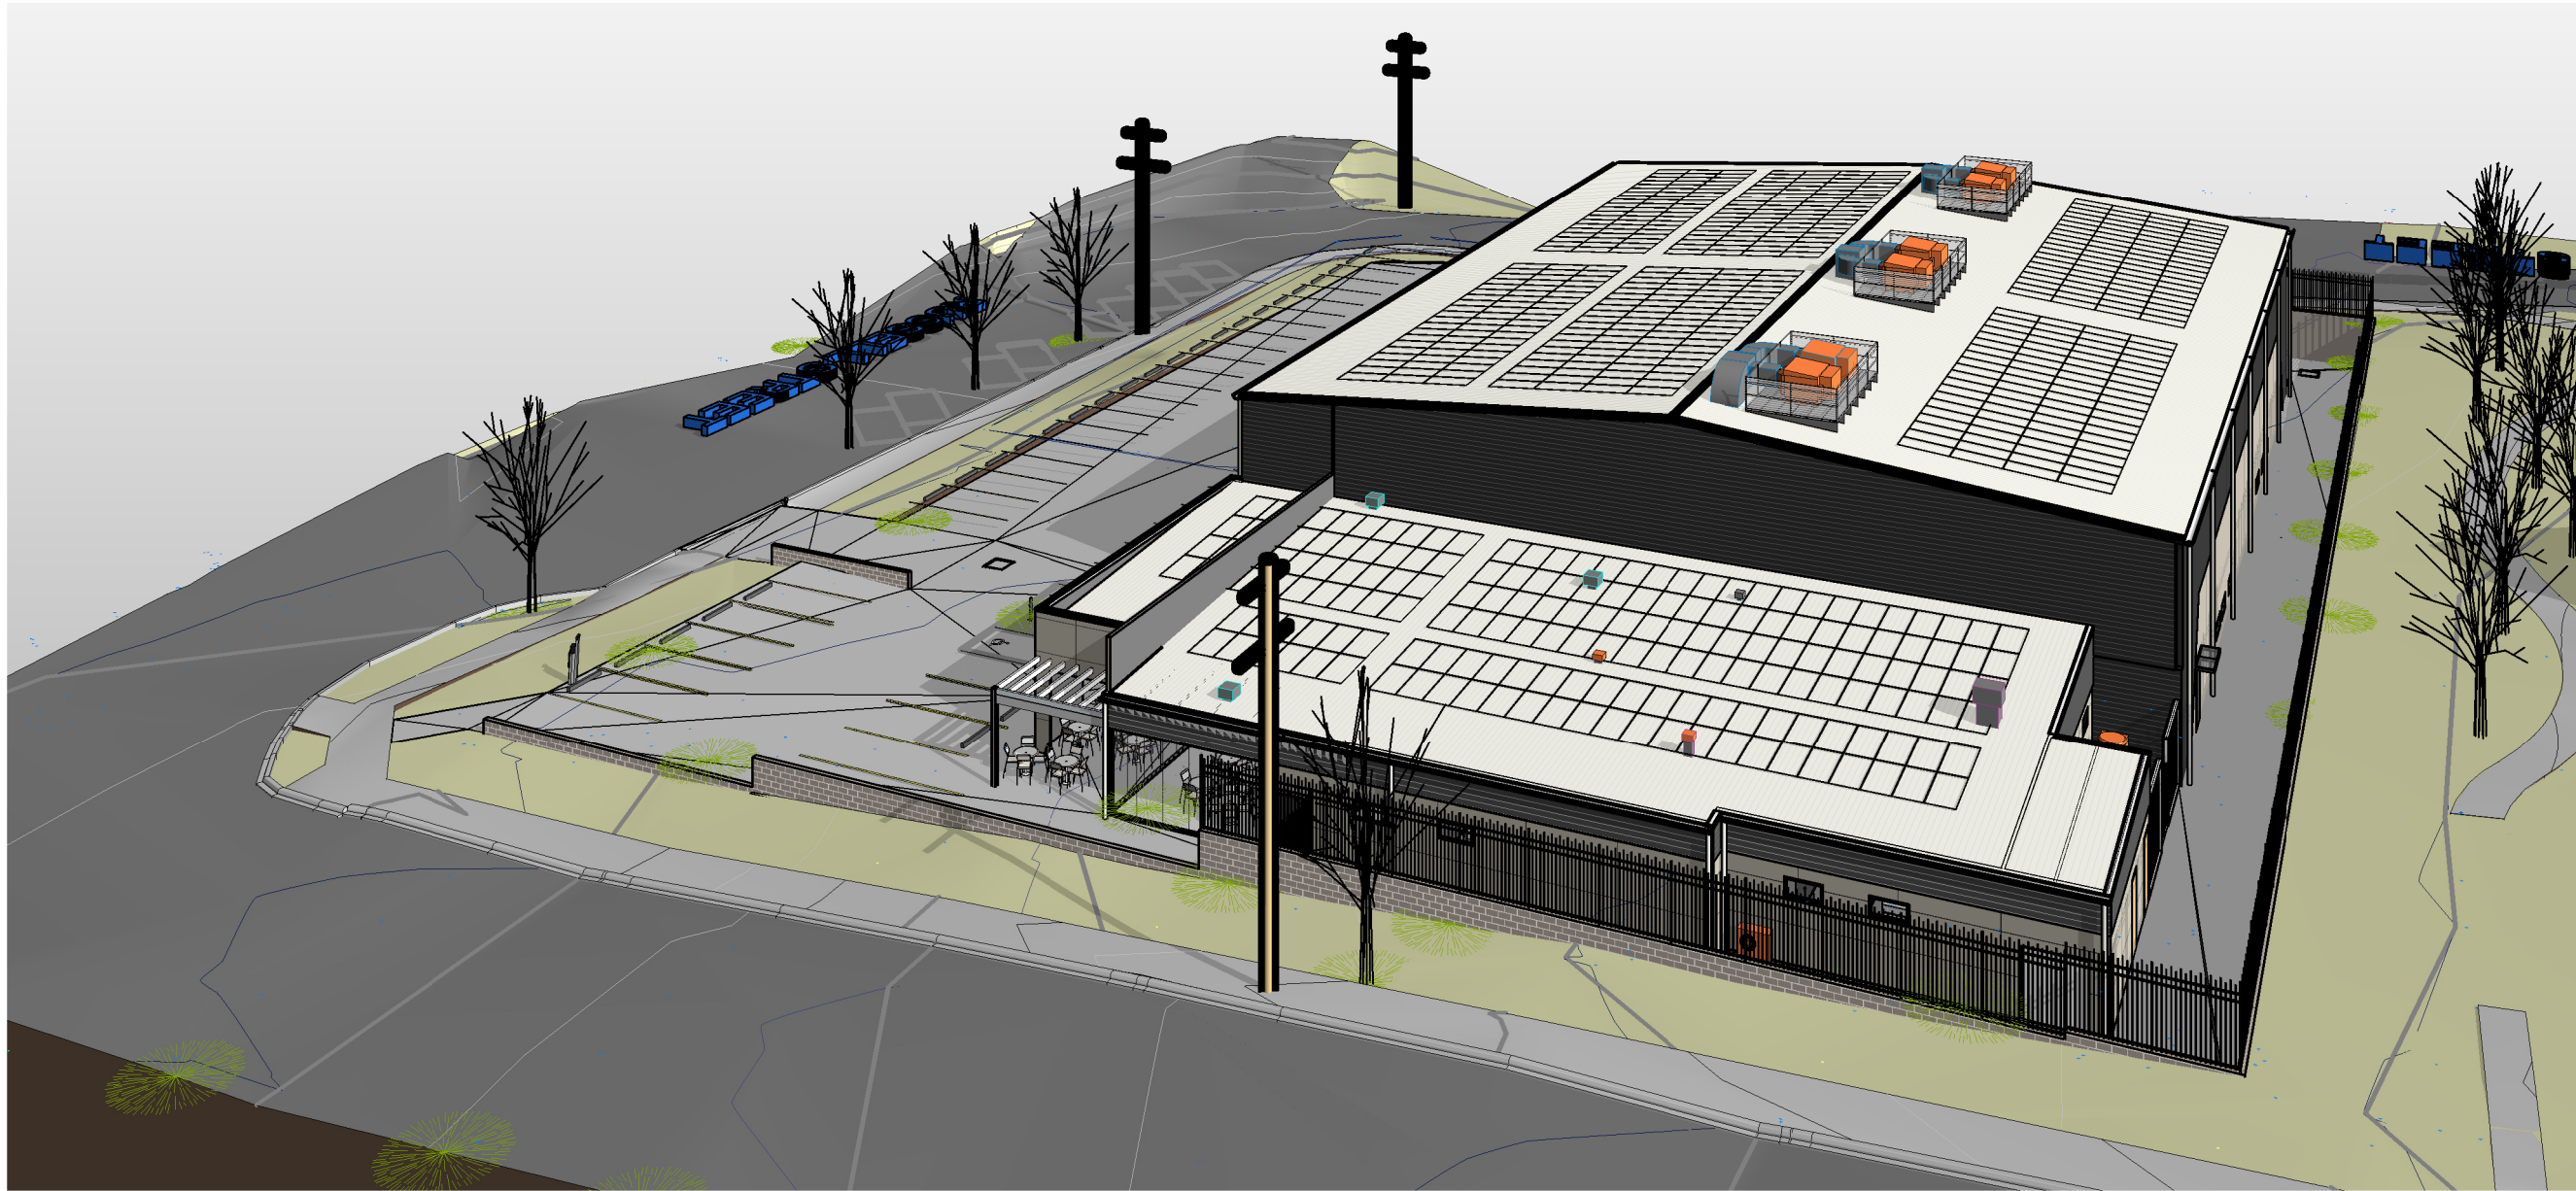

1 NORTH WESTERN VIEW



2 NORTHERN VIEW



3 SOUTH EASTERN VIEW



4 SOUTHERN VIEW

CONSULTANT 4:
WEBB AUSTRALIA GROUP (NSW) PTY LTD
LEVEL 2 17 BOLTON STREET
NEWCASTLE NSW 2300 AUSTRALIA
T +61 2 4928 2225 F +61 478 412 035
MECHANICAL ENGINEERING

CONSULTANT 3:
GLENN HAIG & PARTNERS
Coffs Harbour
P. 02 6658 2444 P. 02 9310 1952
PO Box 192 PO Box 489
SAWTELL, NSW, 2452 SURRY HILLS, NSW, 2010
HYDRAULIC + FIRE CONSULTANTS office@glennhaig.com.au

CONSULTANT 2:
SPECTRUM
1 Davis Place
Glenhaven NSW 2156
Phone: (02) 8850 6802
Mobile: 0419 294 533
Email: info@spectrumengineering.com.au

CONSULTANT 1:
PM DESIGN GROUP
50 Glenelg Street
Geelong, Victoria, Australia 3320
PH: 03 5249 4800
e: admin@pmdesign.com.au
STRUCTURAL + CIVIL ENGINEERING

DESIGN ARCHITECT:
FACILITY DESIGN GROUP
Architecture & Construction
AQUATIC ■ SPORTS ■ LEISURE ■ CIVIC ■ PROJECT MANAGEMENT
NSW Reg. No. 7168
ABN: 75 063 999 424
e: info@fdg.com.au
w: www.fdg.com.au
p: 02 4446 0777
p: 02 4446 0777
PO Box 62
Cammeray NSW 1580

CLIENT:
Snowy Valleys Council

PROJECT NAME:
MULTIPURPOSE + EVACUATION CENTRE
for DA
PROJECT ADDRESS:
RICHMOND PARK, TUMUT NSW
Lot 1 Section 81 DP 759004 and
Lot 701 DP 1059193.

DRAWING TITLE:
PERSPECTIVES 1

SHEET ISSUE DATE: 28.02.2025	DRAWING NO. REV.	A1 PRINT SIZE
REVISION DATE:		
SCALE: @ A1	P1	
JOB NO.: W366		

DRAWN BY: AT CHECKED BY: S. JOHANSSON

COPYRIGHT FACILITY DESIGN GROUP PTY. LIMITED. ALL RIGHTS RESERVED. DO NOT SCALE OFF DRAWINGS. WORK TO FIGURED DIMENSIONS ONLY. VERIFY DIMENSIONS ON SITE PRIOR TO COMMENCING WORK.

NOMINATED ARCHITECT: STEPHEN JOHANSSON - NSW REG No. 7168
5/03/2025 12:18:07 PM